



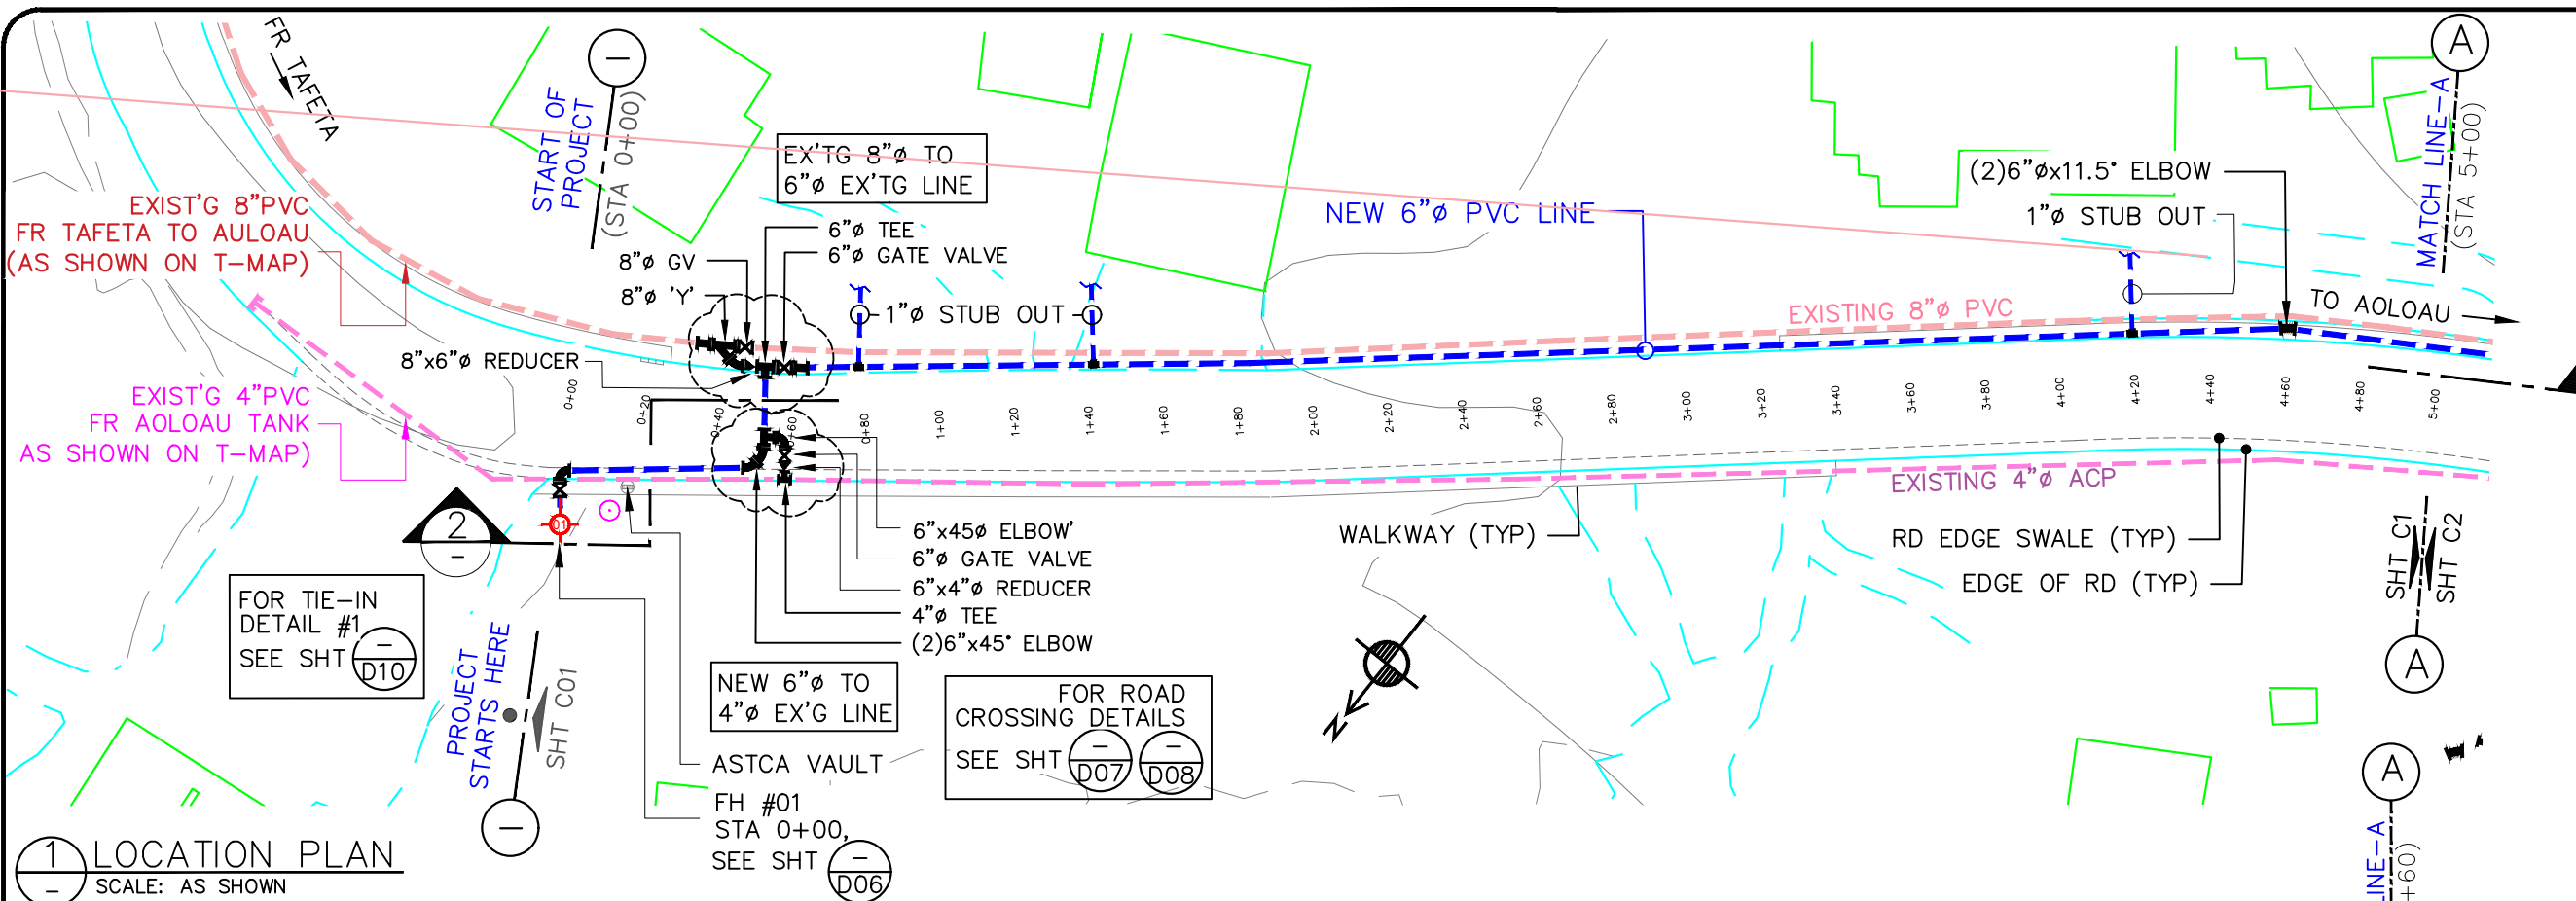


LEGEND:

EXISTING ACP WATER LINE:	
NEW 16" ϕ PVC:	
SEWER SERVICE LINE:	
EXISTING MAIN SEWER LINE:	
EXISTING STORM DRAIN:	
TELEPHONE CONDUIT:	
ELBOWS: 11.25' = 22.5' = 45' =	
FIRE HYDRANT: EXISTING NEW	
POWER/TEL POLE: TELEPHONE POLE ELECTRICITY POLE ALL IN 1 POLE	
TREES: HEDGES:	
SERVICE METER:	
GATE VALVE:	
STUB-OUT:	
AIR RELIEVE VALVE:	
BAC-T SAMPLING STN:	
PRV / PSV:	
ROADS: DIRT ROADS:	

GENERAL NOTE:

- CONSTRUCTION CONTRACTOR SHALL FIELD VERIFY ALL EXISTING UNDERGROUND INFRASTRUCTURE TO ENSURE SAFETY OF ITS WORKERS.
- AVOID ANY DAMAGES TO EXISTING GOVERNMENT UTILITIES.
- INSTALL 16" ϕ X 16" ϕ X 6" ϕ SADDLE FOR FIRE HYDRANT CONNECTION. (OR SIMILAR CONNECTION)
- INSTALL 2" ϕ X 16" ϕ SADDLE OR SIMILAR CONNECTION FOR NEW SERVICE CONNECTION @ EVERY 500 FEET.

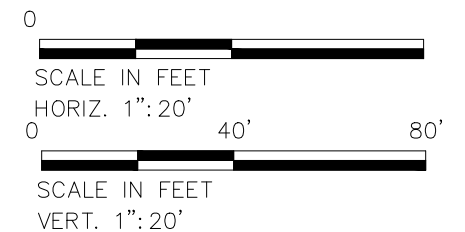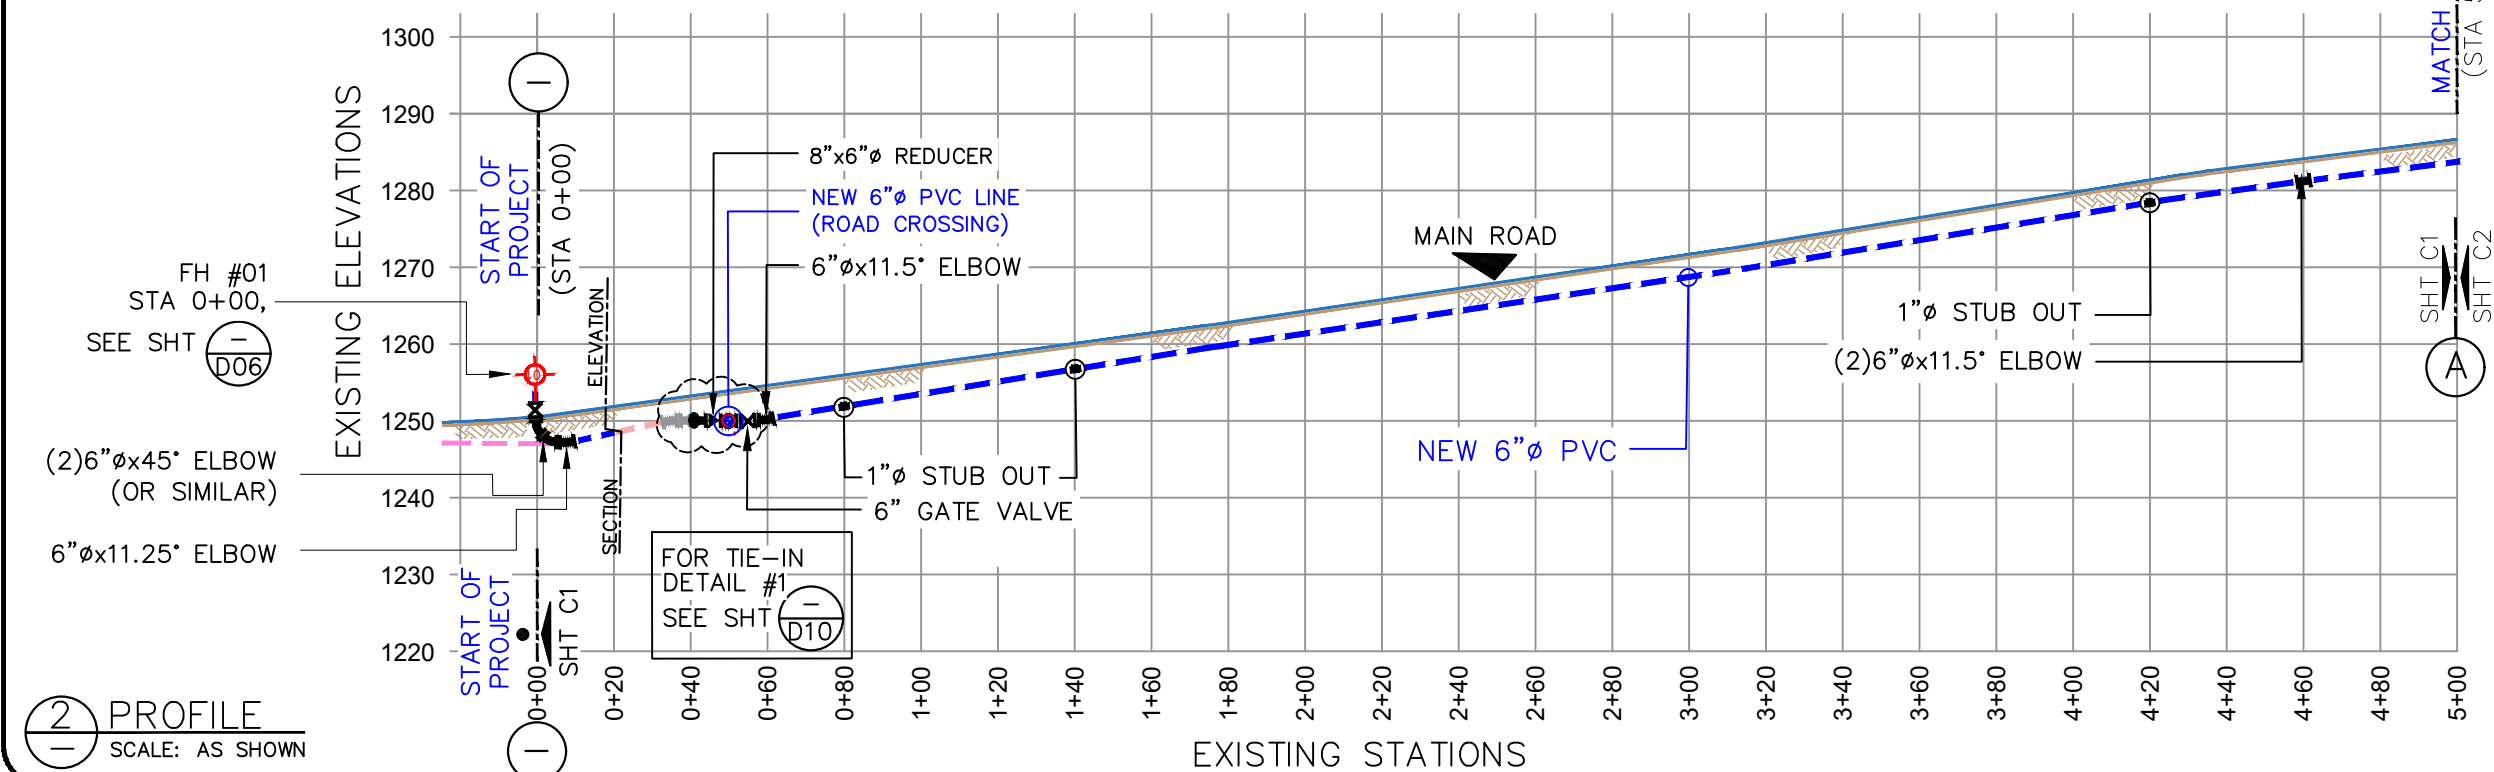

No.	Description	Date	REV. NO.:	PREPARED BY:
				FToala
			REVISION:	CHECKED BY:
				LTyrell
			CHECKED BY:	APPROVED BY:
				FAguila / LTyrell
			APPROVED BY:	ISSUE FOR:
				Construction
			DATE:	



AMERICAN SAMOA POWER AUTHORITY

AMERICAN SAMOA POWER AUTHORITY
ENGINEERING SERVICES DIVISION

P.O.BOX PPB, TAFUNA, PAGO PAGO, AS 96799

PROJECT NAME:

AOLOAU 6" ϕ WATERLINE REPLACEMENT PROJECT

DRAWING TITLE:

START OF SEGMENT 1
PROFILE & PLAN (STA. 0+00 to 5+00)

PROJECT LOCATION:

AOLOAU VILLAGE, AMERICAN SAMOA

SCALE:

AS SHOWN

PROJECT NO.:

1958785

DATE:


APRIL 2023

SIGNATURE:

DATE:

SHEET NO.

C01


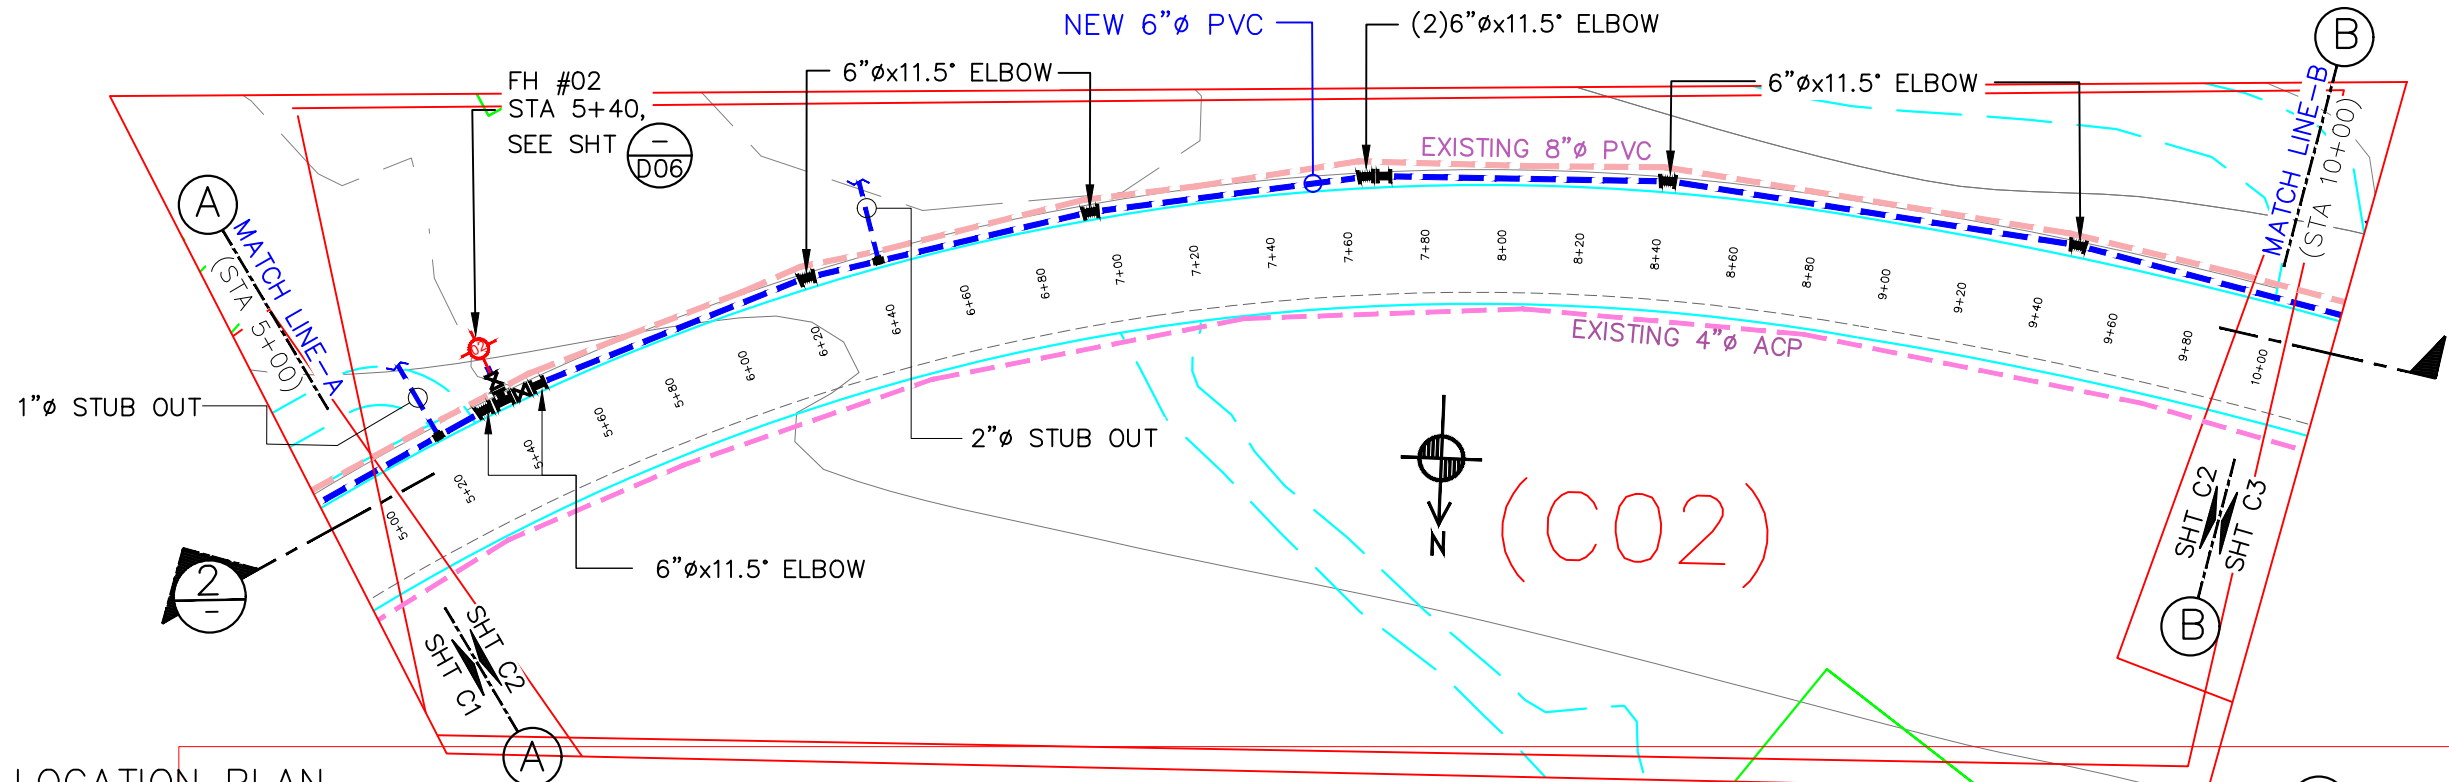


LEGEND:	
EXISTING ACP WATER LINE:	
NEW 16"Ø PVC:	
SEWER SERVICE LINE:	
EXISTING MAIN SEWER LINE:	
EXISTING STORM DRAIN:	
TELEPHONE CONDUIT:	
ELBOWS: 11.25"=	
22.5"=	
45"=	
FIRE HYDRANT: EXISTING	
NEW	
POWER/TEL POLE: TELEPHONE POLE	
ELECTRICITY POLE	
ALL IN 1 POLE	
TREES:	
HEDGES:	
SERVICE METER:	
GATE VALVE:	
STUB-OUT:	
AIR RELIEVE VALVE:	
BAC-T SAMPLING STN:	
PRV / PSV :	
ROADS:	
DIRT ROADS:	

GENERAL NOTE:

- CONSTRUCTION CONTRACTOR SHALL FIELD VERIFY ALL EXISTING UNDERGROUND INFRASTRUCTURE TO ENSURE SAFETY OF ITS WORKERS.
- AVOID ANY DAMAGES TO EXISTING GOVERNMENT UTILITIES.
- INSTALL 16"ØX16"ØX6: Ø SADDLE FOR FIRE HYDRANT CONNECTION. (OR SIMILAR CONNECTION)
- INSTALL 2"ØX16"Ø SADDLE OR SIMILAR CONNECTION FOR NEW SERVICE CONNECTION @ EVERY 500 FEET.

1 LOCATION PLAN
SCALE: AS SHOWN

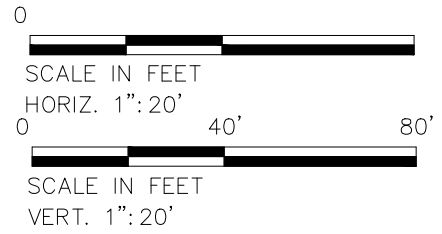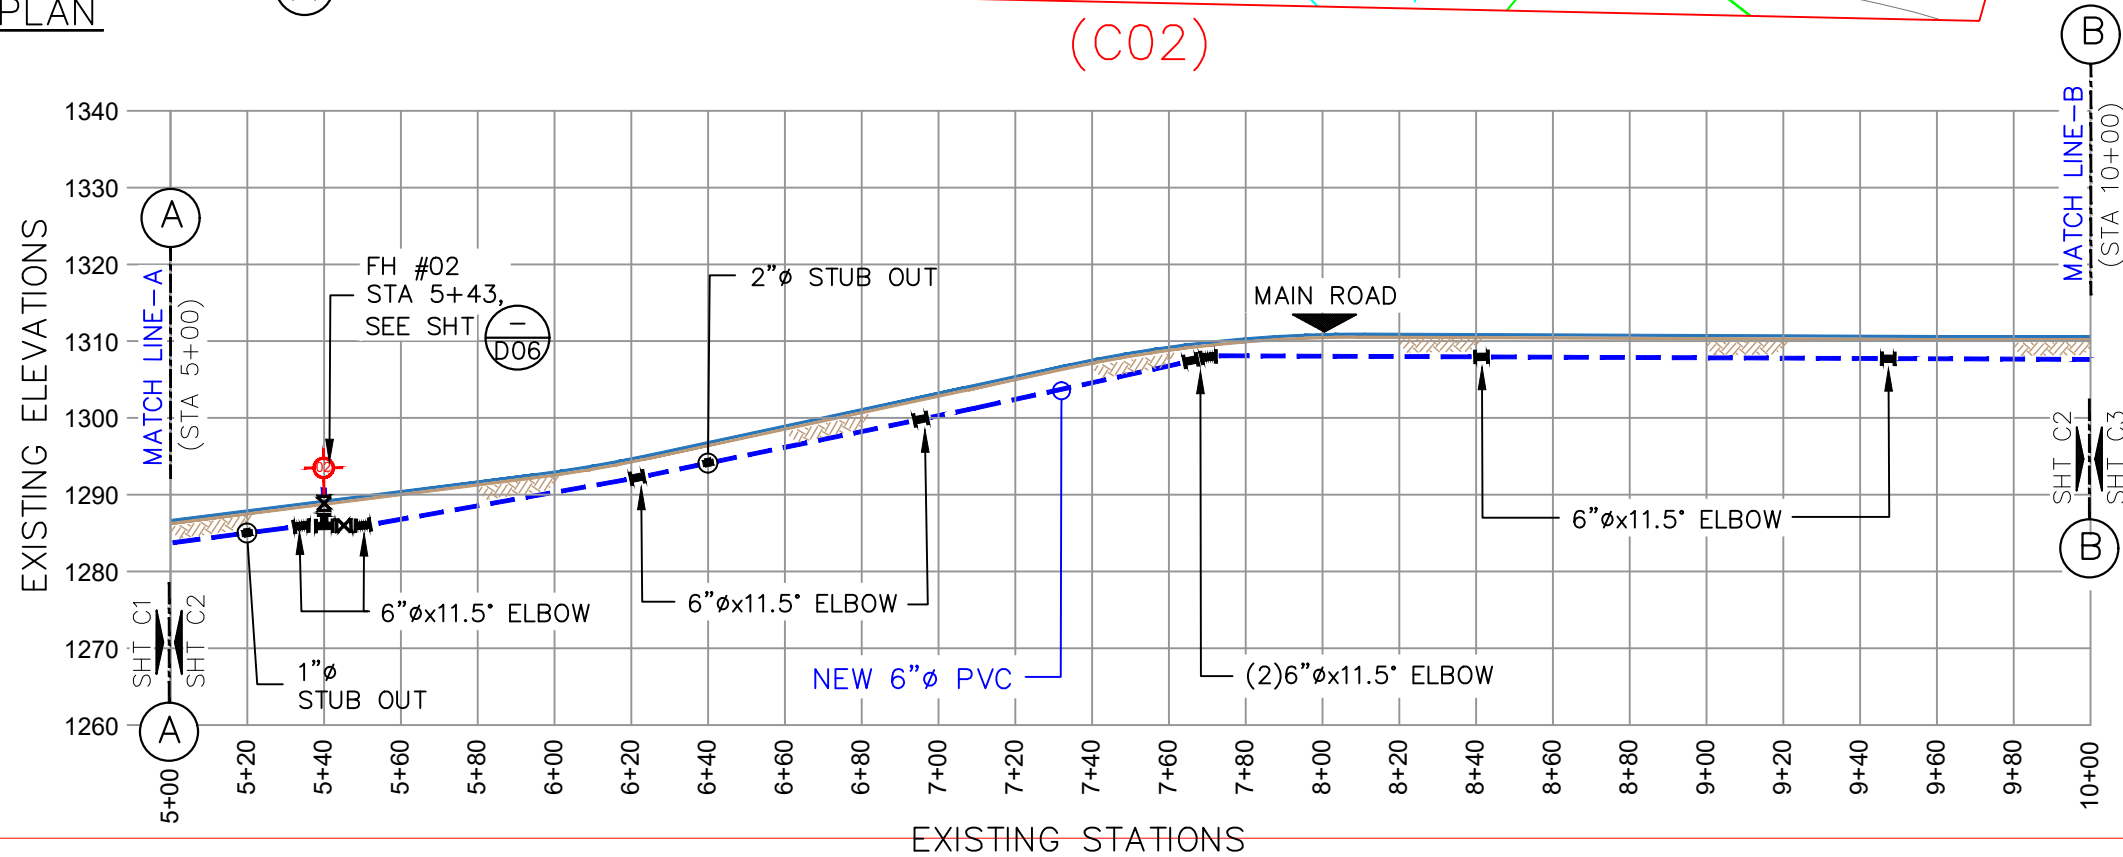

2 PROFILE
SCALE: AS SHOWN

No.	Description	Date

REV. NO.:	PREPARED BY:
	FToala
REVISION:	CHECKED BY:
	LTyrell
CHECKED BY:	APPROVED BY:
	FAguila / LTyrell
APPROVED BY:	ISSUE FOR:
	Construction
DATE:	




AMERICAN SAMOA POWER AUTHORITY
ENGINEERING SERVICES DIVISION
P.O.BOX PPB, TAFUNA, PAGO PAGO, AS 96799

PROJECT NAME:
AOLOAU 6"Ø WATERLINE REPLACEMENT PROJECT
DRAWING TITLE:
SEGMENT 1 PROFILE & PLAN (STA. 5+00 to 10+00)
PROJECT LOCATION:
AOLOAU VILLAGE, AMERICAN SAMOA

SCALE:
AS SHOWN
PROJECT NO:
1958785
DATE:
APRIL 2023


SIGNATURE:
DATE:
SHEET NO.
C02

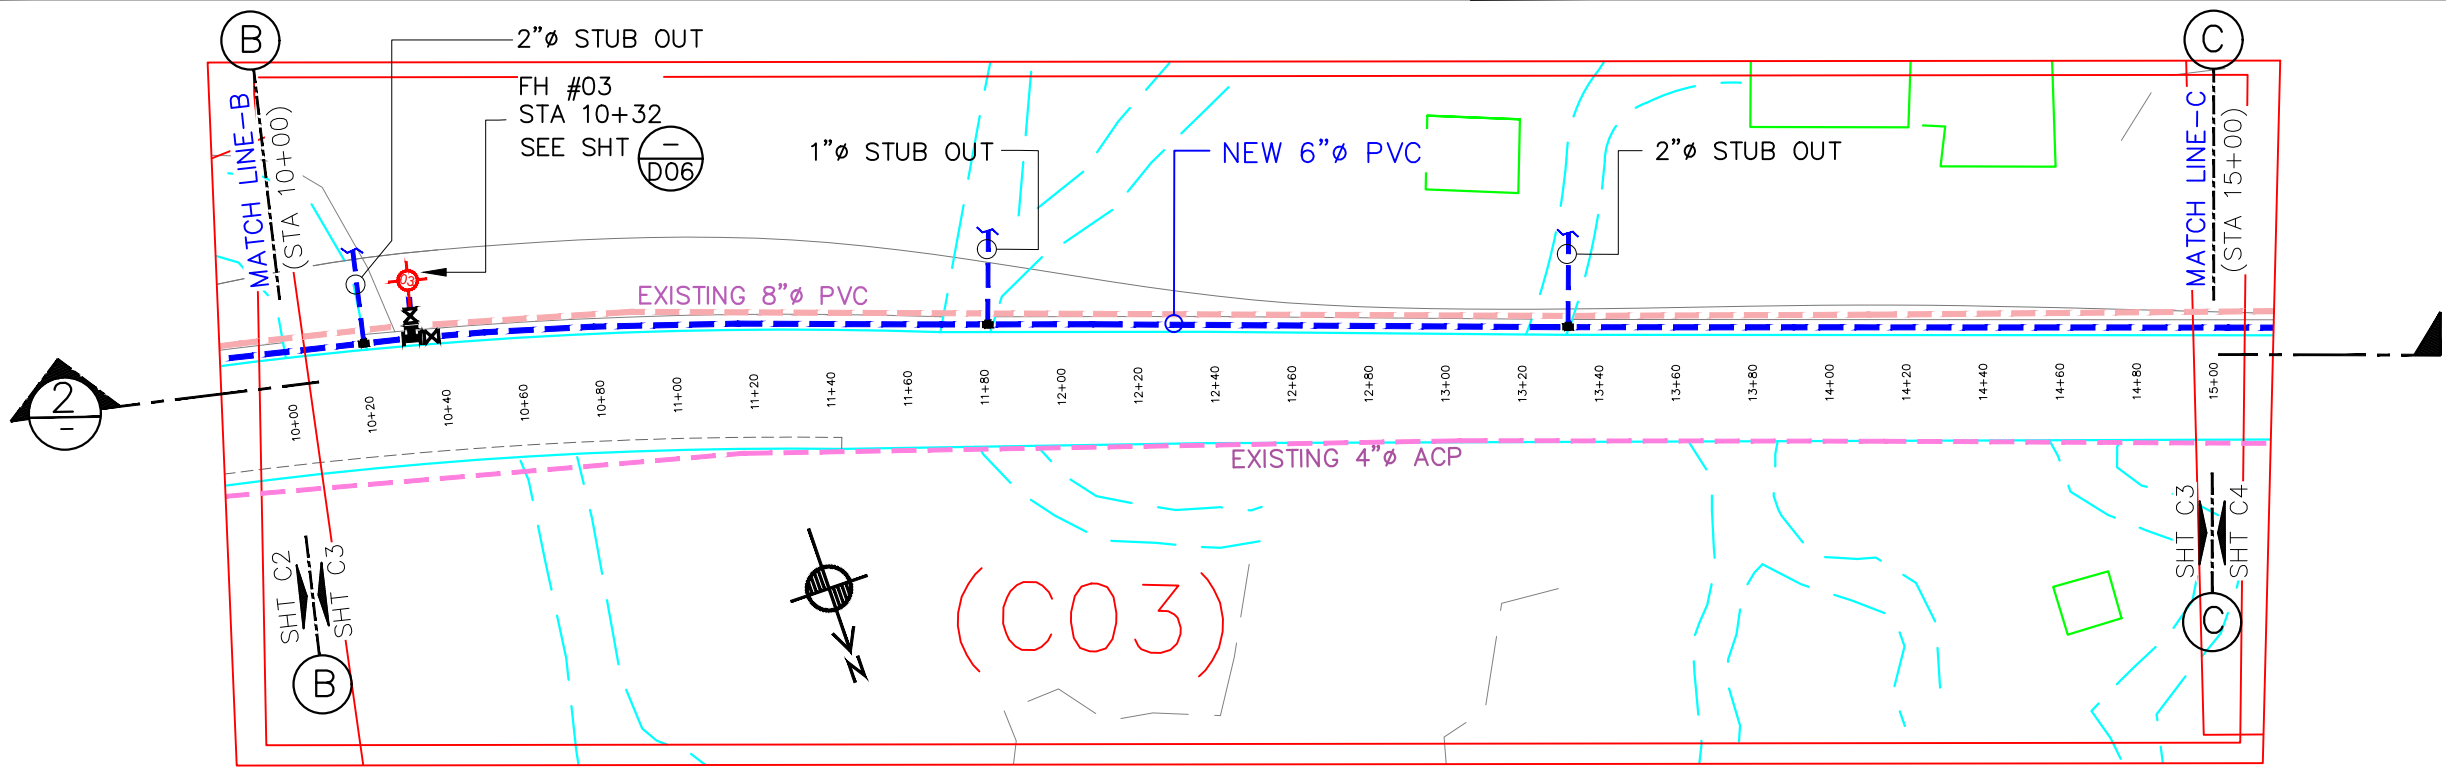


1 LOCATION PLAN
SCALE: AS SHOWN

LEGEND:	
EXISTING ACP WATER LINE:	
NEW 16"Ø PVC:	
SEWER SERVICE LINE:	
EXISTING MAIN SEWER LINE:	
EXISTING STORM DRAIN:	
TELEPHONE CONDUIT:	
ELBOWS: 11.25"=	
22.5"=	
45"=	
FIRE HYDRANT: EXISTING	
NEW	
POWER/TEL POLE:	
TREES:	
HEDGES:	
SERVICE METER:	
GATE VALVE:	
STUB-OUT:	
AIR RELIEVE VALVE:	
BAC-T SAMPLING STN:	
PRV / PSV :	
ROADS:	
DIRT ROADS:	

- GENERAL NOTE:
- CONSTRUCTION CONTRACTOR SHALL FIELD VERIFY ALL EXISTING UNDERGROUND INFRASTRUCTURE TO ENSURE SAFETY OF ITS WORKERS.
 - AVOID ANY DAMAGES TO EXISTING GOVERNMENT UTILITIES.
 - INSTALL 16"ØX16"ØX6: Ø SADDLE FOR FIRE HYDRANT CONNECTION. (OR SIMILAR CONNECTION)
 - INSTALL 2"ØX16"Ø SADDLE OR SIMILAR CONNECTION FOR NEW SERVICE CONNECTION @ EVERY 500 FEET.

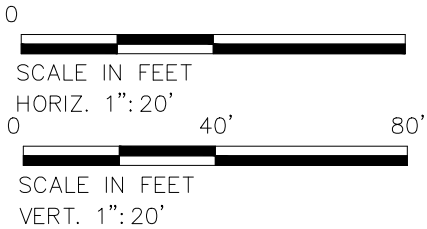

2 PROFILE
SCALE: AS SHOWN

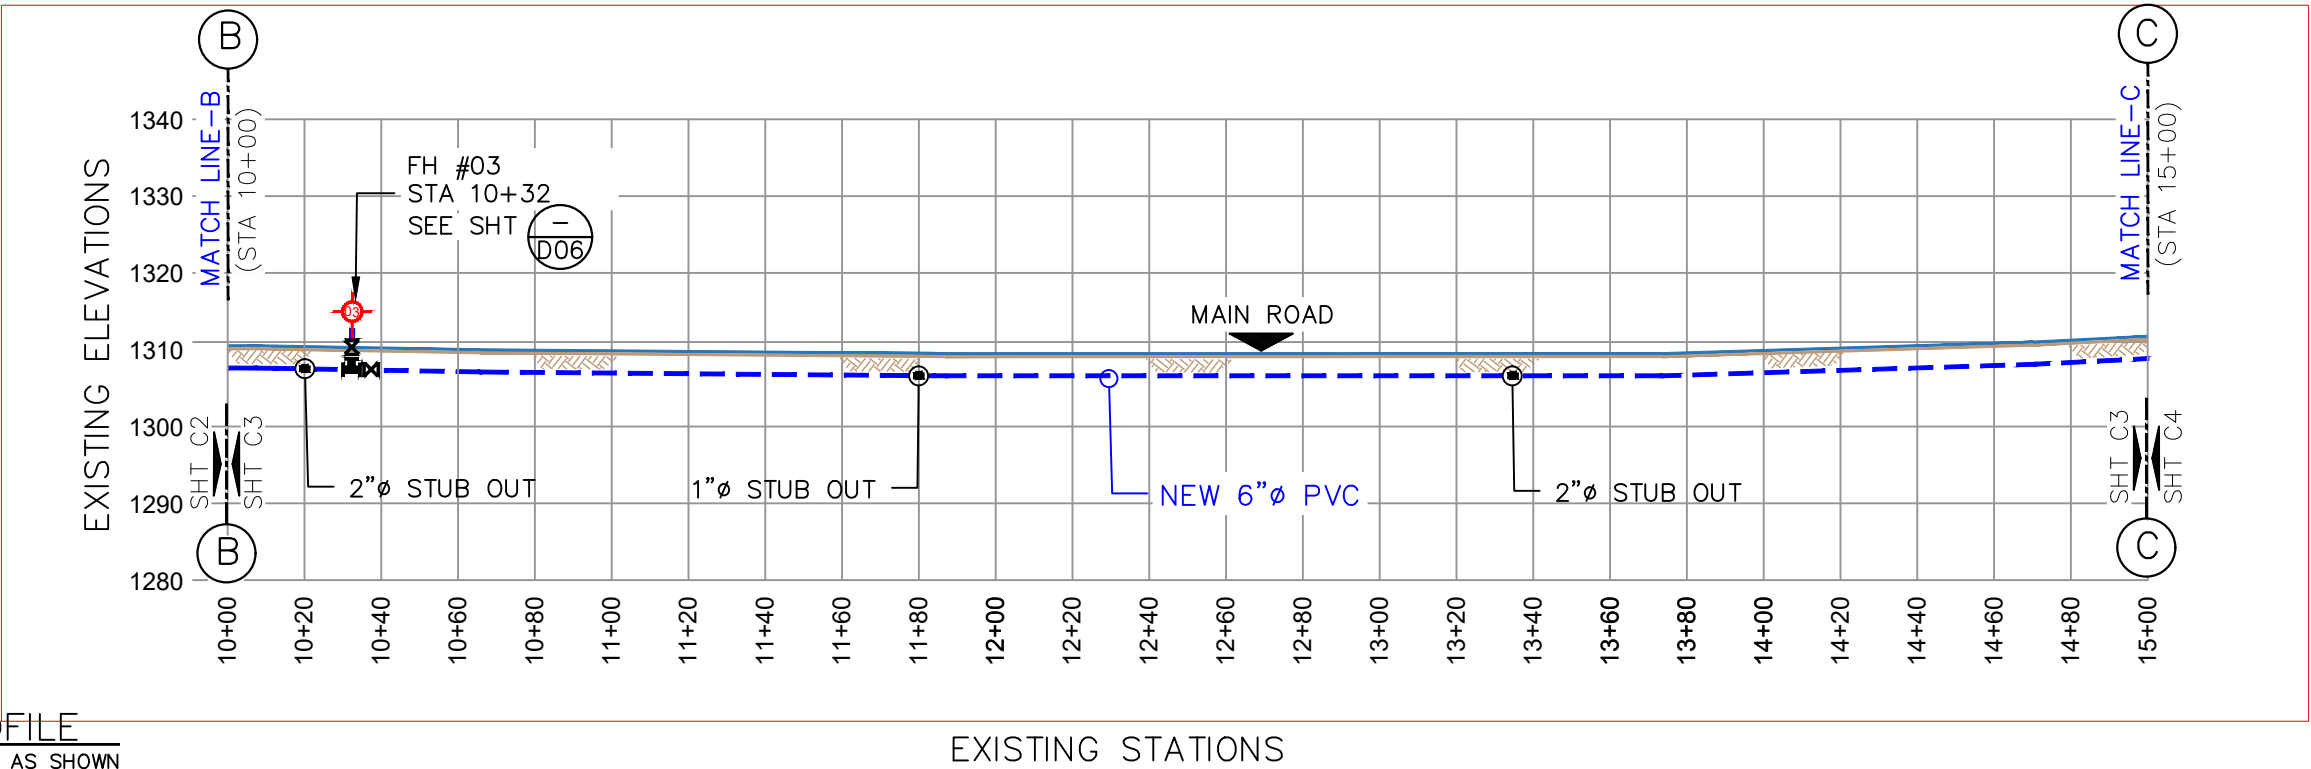

No.	Description	Date

REV. NO.:	
REVISION:	
CHECKED BY:	
APPROVED BY:	
DATE:	

PREPARED BY:	FToala
CHECKED BY:	LTyrell
APPROVED BY:	FAguila / LTyrell
ISSUE FOR:	Construction




AMERICAN SAMOA POWER AUTHORITY
ENGINEERING SERVICES DIVISION
P.O.BOX PPB, TAFUNA, PAGO PAGO, AS 96799


PROJECT NAME:	AOLOAU 6"Ø WATERLINE REPLACEMENT PROJECT
DRAWING TITLE:	SEGMENT 1 PROFILE & PLAN (STA.10+00 to 15+00)
PROJECT LOCATION:	AOLOAU VILLAGE, AMERICAN SAMOA

SCALE:	AS SHOWN
PROJECT NO:	1958785
DATE:	JULY 2023

SIGNATURE:	
DATE:	
SHEET NO.	C03

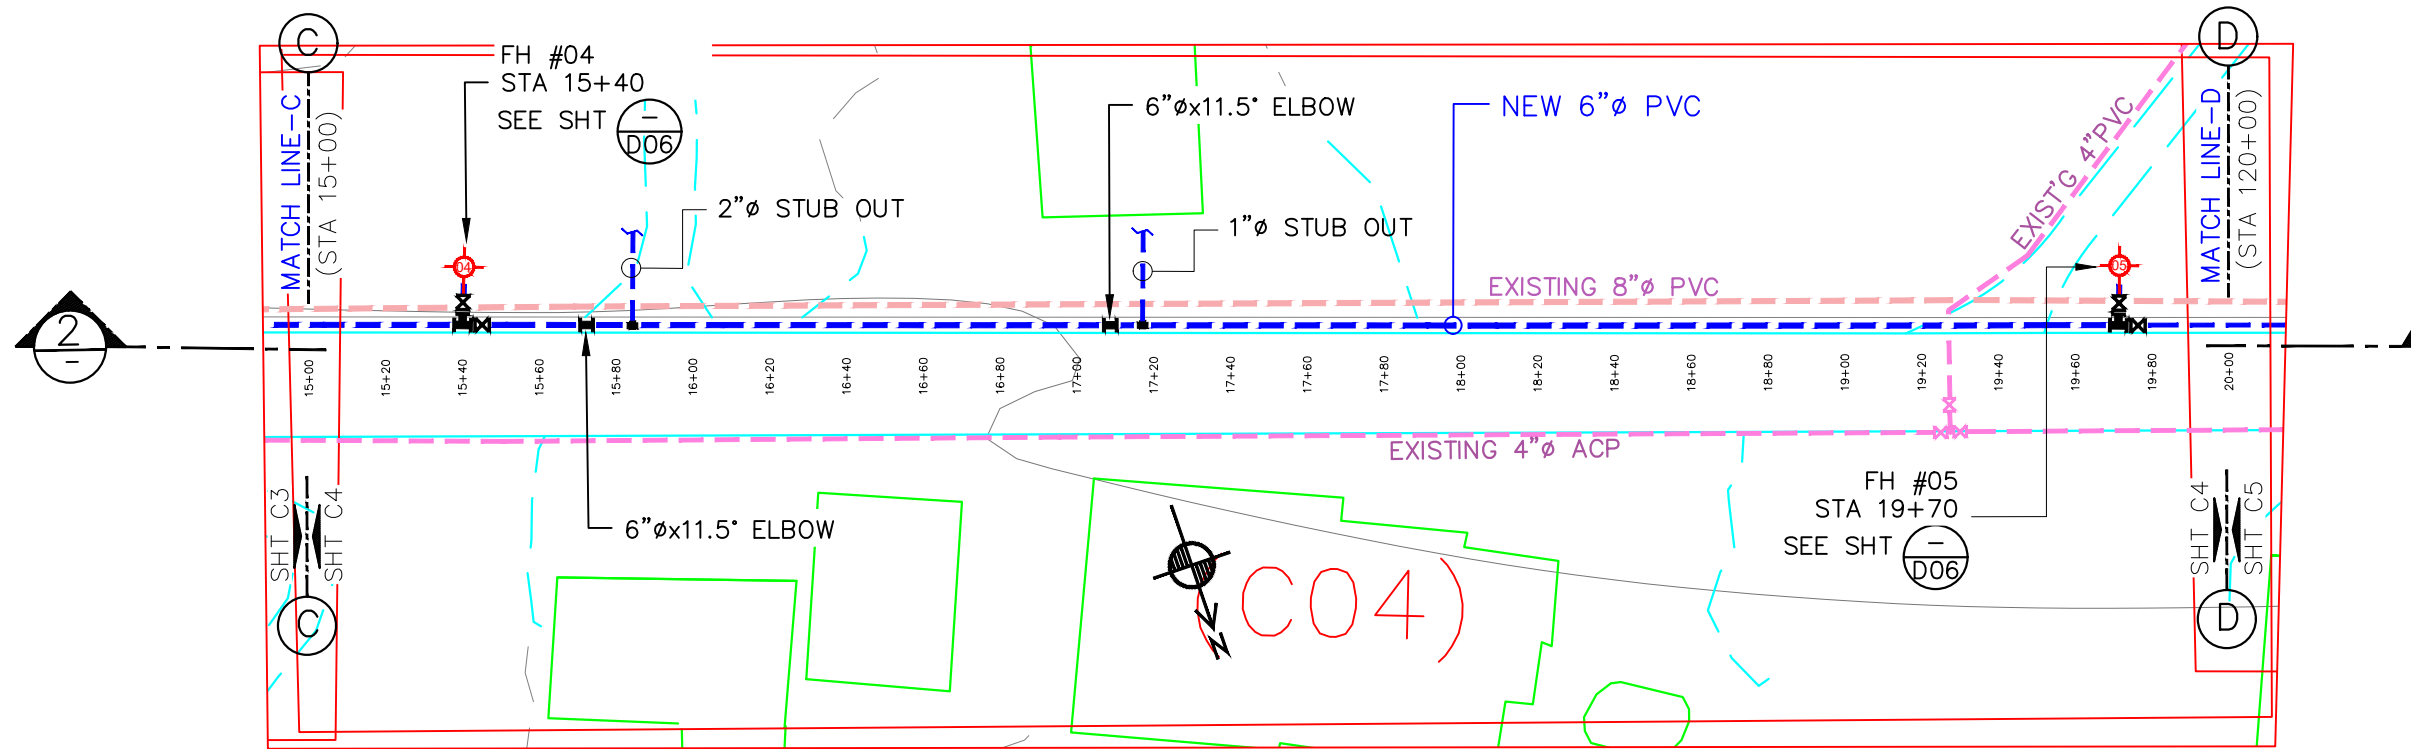


1 LOCATION PLAN
SCALE: AS SHOWN

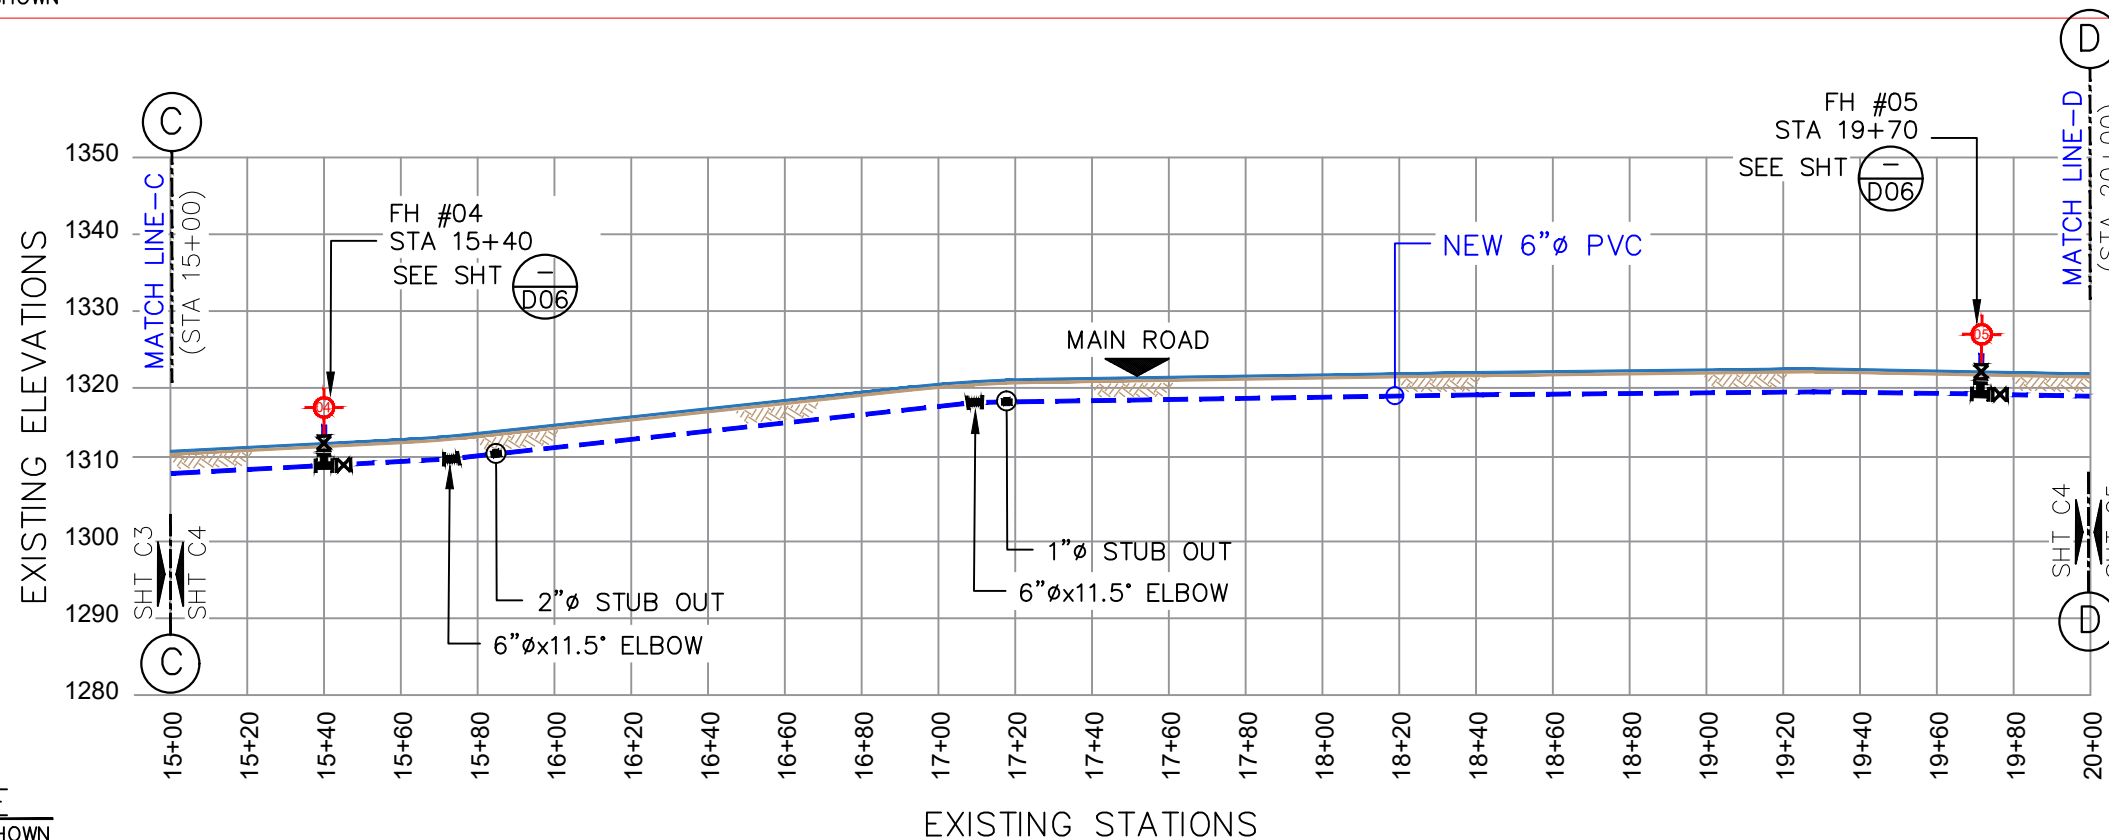

2 PROFILE
SCALE: AS SHOWN

LEGEND:	
EXISTING ACP WATER LINE:	
NEW 16"Ø PVC:	
SEWER SERVICE LINE:	
EXISTING MAIN SEWER LINE:	
EXISTING STORM DRAIN:	
TELEPHONE CONDUIT:	
ELBOWS: 11.25"=	
22.5"=	
45"=	
FIRE HYDRANT: EXISTING	
NEW	
POWER/TEL POLE:	
TREES:	
HEDGES:	
SERVICE METER:	
GATE VALVE:	
STUB-OUT:	
AIR RELIEVE VALVE:	
BAC-T SAMPLING STN:	
PRV / PSV :	
ROADS:	
DIRT ROADS:	

- GENERAL NOTE:
- CONSTRUCTION CONTRACTOR SHALL FIELD VERIFY ALL EXISTING UNDERGROUND INFRASTRUCTURE TO ENSURE SAFETY OF ITS WORKERS.
 - AVOID ANY DAMAGES TO EXISTING GOVERNMENT UTILITIES.
 - INSTALL 16"ØX16"ØX6:Ø SADDLE FOR FIRE HYDRANT CONNECTION. (OR SIMILAR CONNECTION)
 - INSTALL 2"ØX16"Ø SADDLE OR SIMILAR CONNECTION FOR NEW SERVICE CONNECTION @ EVERY 500 FEET.

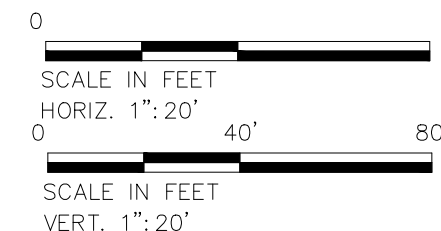

No.	Description	Date	REV. NO.:	PREPARED BY:
				FToala
			REVISION:	CHECKED BY:
				LTyrell
			CHECKED BY:	APPROVED BY:
				FAguila / LTyrell
			APPROVED BY:	ISSUE FOR:
				Construction
			DATE:	



AMERICAN SAMOA POWER AUTHORITY

AMERICAN SAMOA POWER AUTHORITY
ENGINEERING SERVICES DIVISION

P.O.BOX PPB, TAFUNA, PAGO PAGO, AS 96799

PROJECT NAME:
AOLOAU 6"Ø WATERLINE REPLACEMENT PROJECT

DRAWING TITLE:
SEGMENT 1
PROFILE & PLAN (STA.15+00 to 20+00)

PROJECT LOCATION:
AOLOAU VILLAGE, AMERICAN SAMOA

SCALE:
AS SHOWN


PROJECT NO:
1958785

DATE:
JULY 2023

SIGNATURE:
DATE:

SHEET NO.


C04

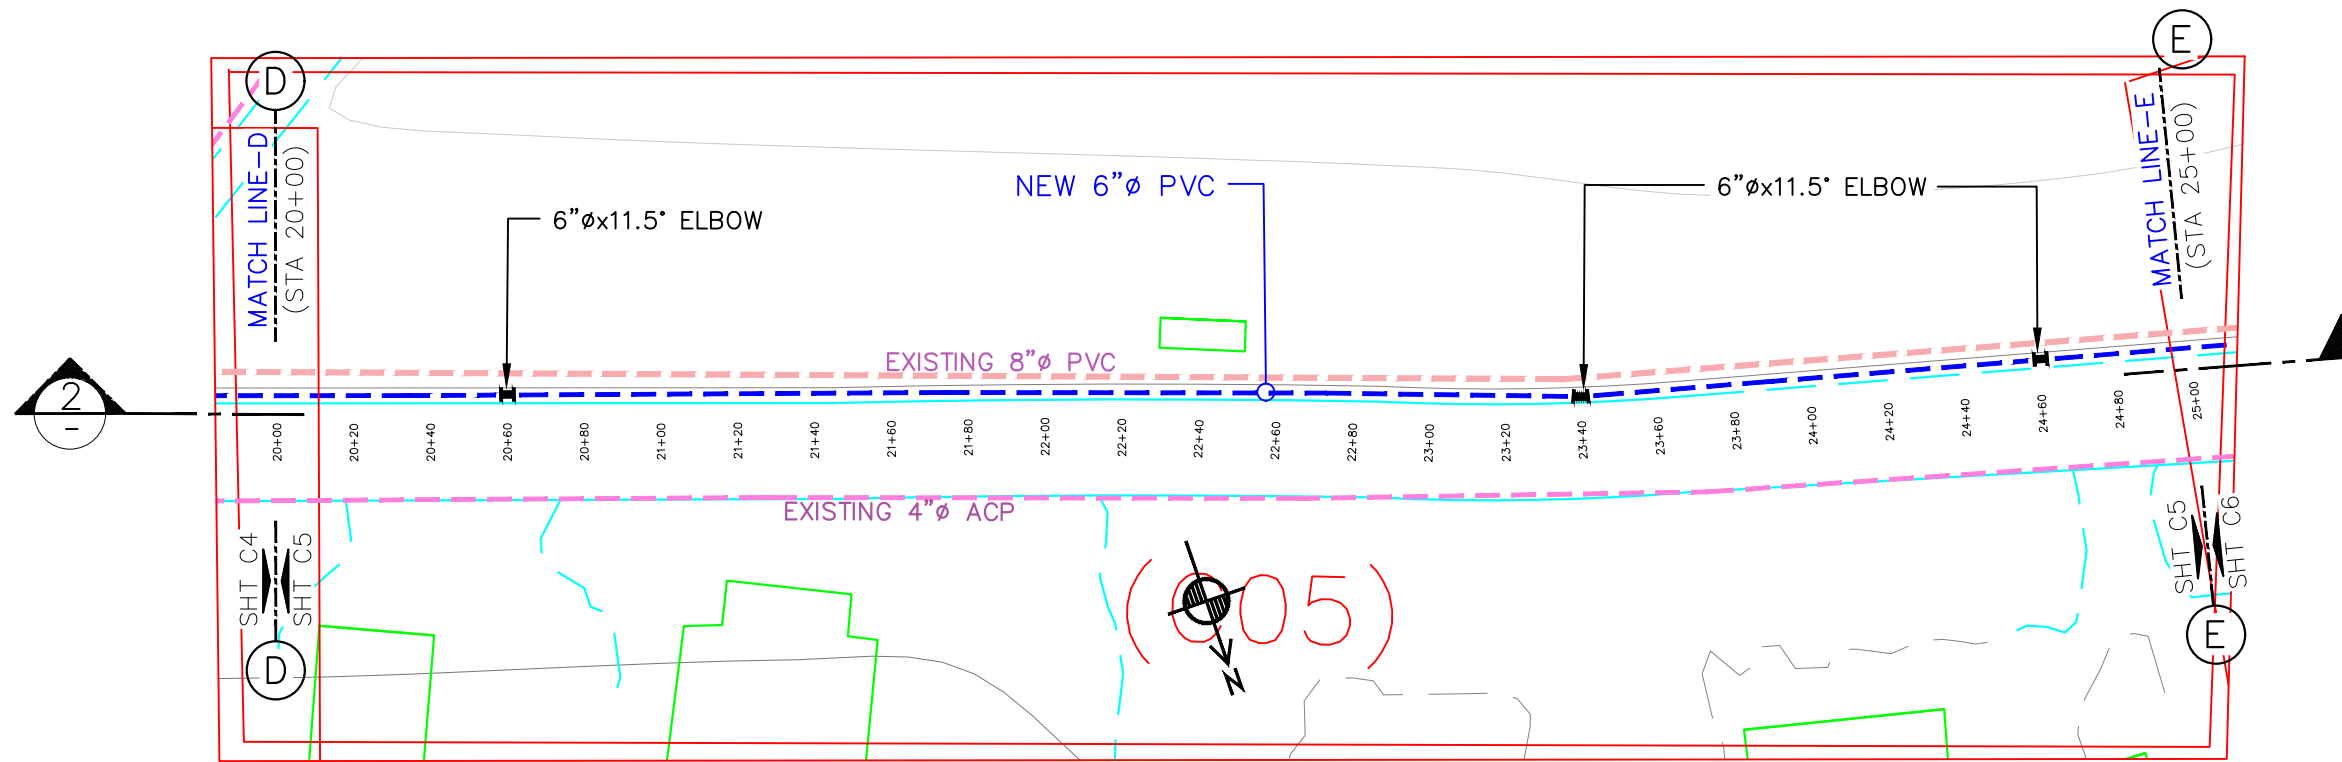


LEGEND:	
EXISTING ACP WATER LINE:	
NEW 16"Ø PVC:	
SEWER SERVICE LINE:	
EXISTING MAIN SEWER LINE:	
EXISTING STORM DRAIN:	
TELEPHONE CONDUIT:	
ELBOWS: 11.25"=	
22.5"=	
45"=	
FIRE HYDRANT: EXISTING	
NEW	
POWER/TEL POLE:	
TELEPHONE POLE	
ELECTRICITY POLE	
ALL IN 1 POLE	
TREES:	
HEDGES:	
SERVICE METER:	
GATE VALVE:	
STUB-OUT:	
AIR RELIEVE VALVE:	
BAC-T SAMPLING STN:	
PRV / PSV :	
ROADS:	
DIRT ROADS:	

GENERAL NOTE:

- CONSTRUCTION CONTRACTOR SHALL FIELD VERIFY ALL EXISTING UNDERGROUND INFRASTRUCTURE TO ENSURE SAFETY OF ITS WORKERS.
- AVOID ANY DAMAGES TO EXISTING GOVERNMENT UTILITIES.
- INSTALL 16"ØX16"ØX6: Ø SADDLE FOR FIRE HYDRANT CONNECTION. (OR SIMILAR CONNECTION)
- INSTALL 2"ØX16"Ø SADDLE OR SIMILAR CONNECTION FOR NEW SERVICE CONNECTION @ EVERY 500 FEET.

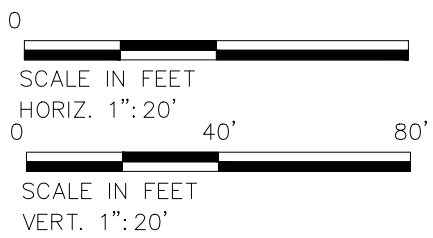


1 LOCATION PLAN
SCALE: AS SHOWN

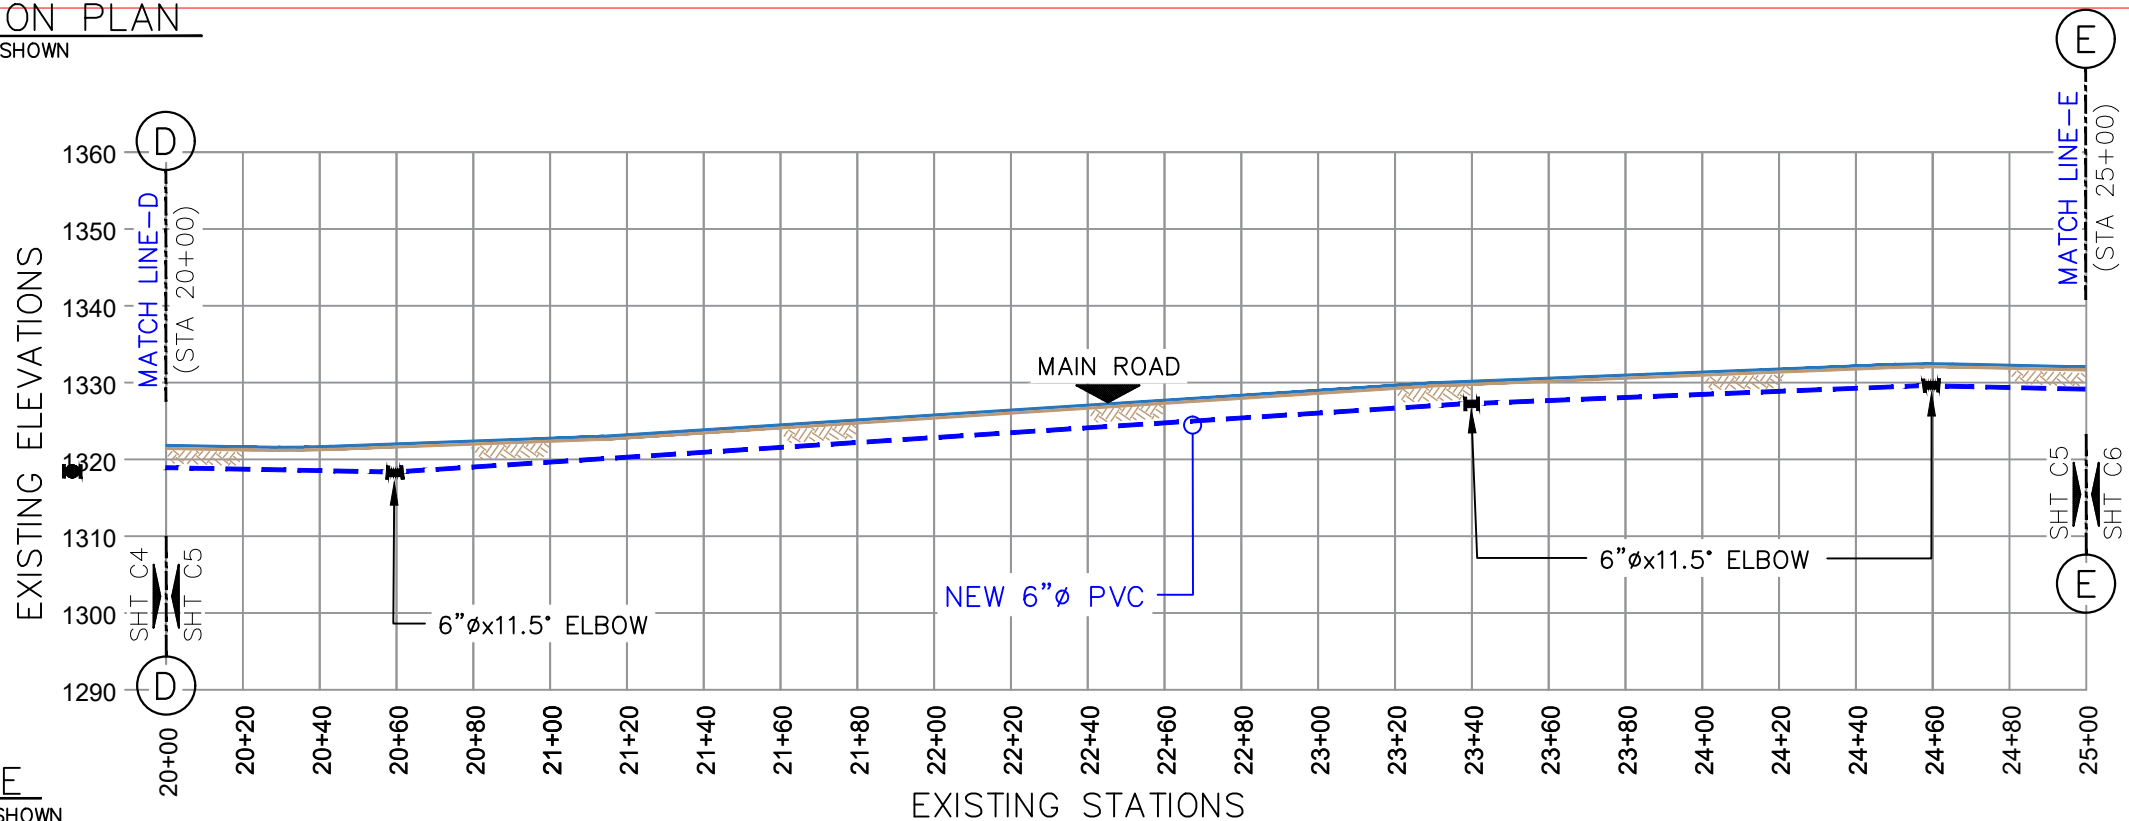

2 PROFILE
SCALE: AS SHOWN


No. Description Date			REV. NO.:	PREPARED BY:	ASPA AMERICAN SAMOA POWER AUTHORITY ENGINEERING SERVICES DIVISION P.O.BOX PPB, TAFUNA, PAGO PAGO, AS 96799 AMERICAN SAMOA POWER AUTHORITY	PROJECT NAME:	AOLOAU 6"Ø WATERLINE REPLACEMENT PROJECT	SCALE:	AS SHOWN	SIGNATURE:
			REVISION:	CHECKED BY:		DRAWING TITLE:		PROJECT NO:		DATE:
			CHECKED BY:	APPROVED BY:		PROJECT LOCATION:		DATE:		SHEET NO.
			APPROVED BY:	ISSUE FOR:						
			DATE:							

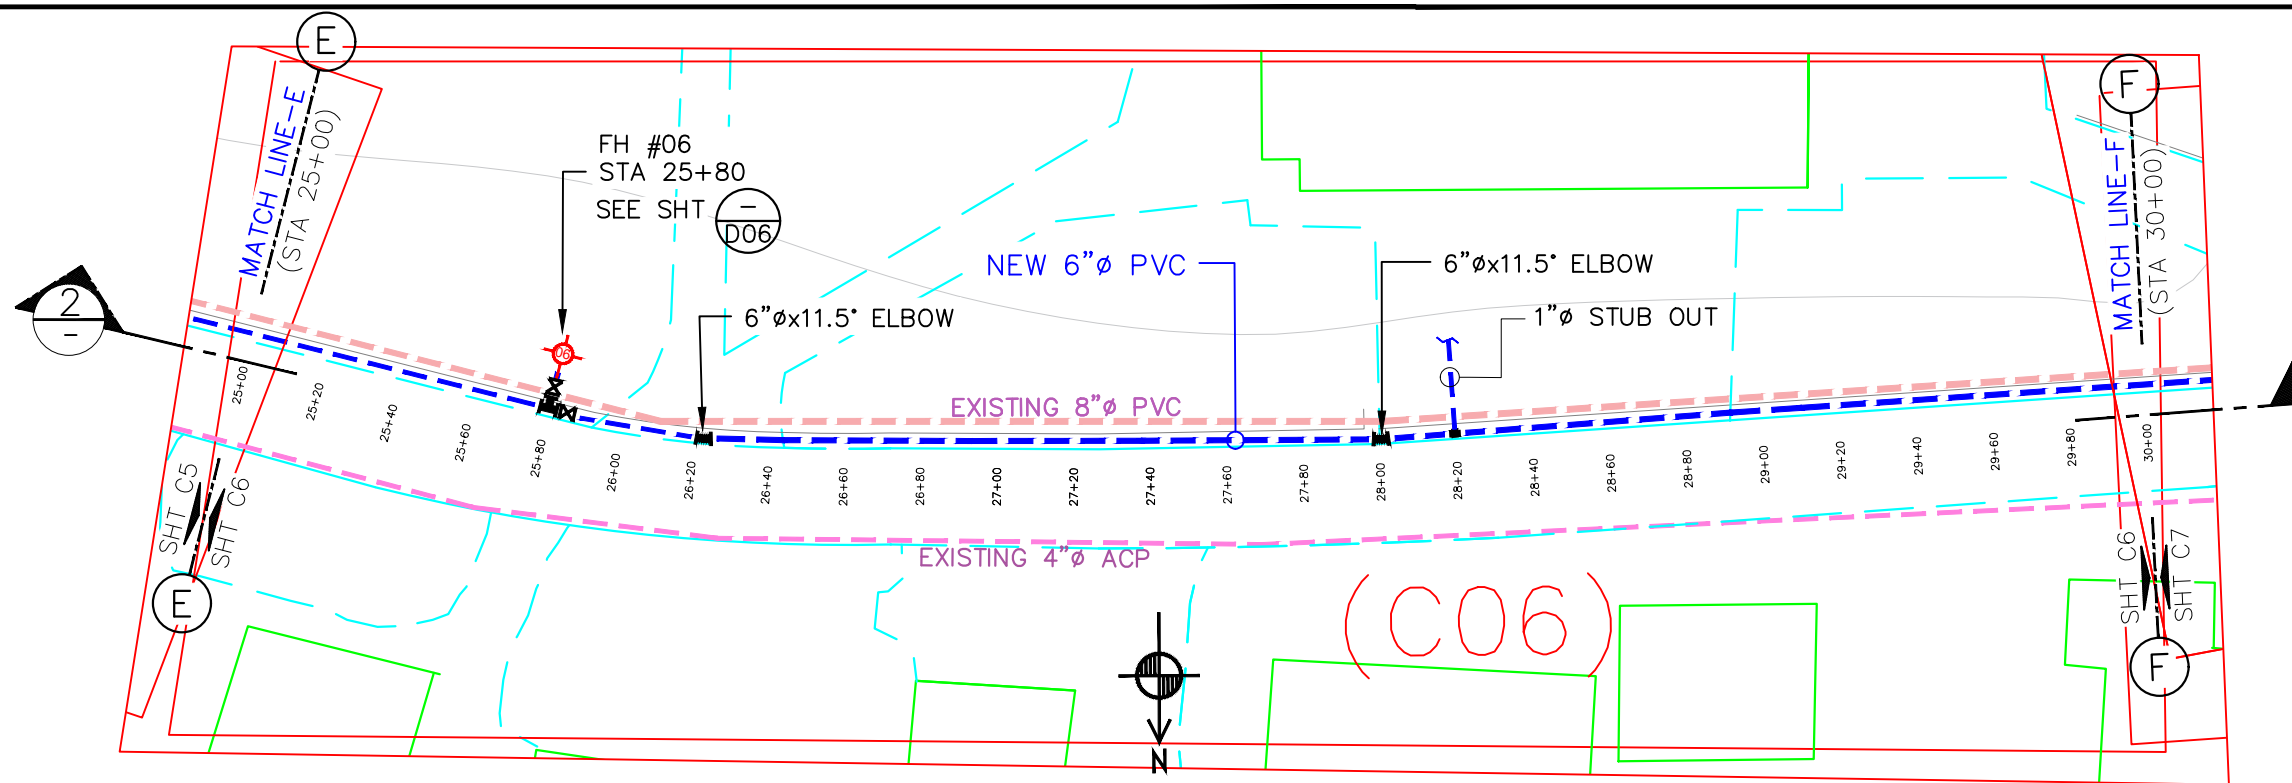

LEGEND:	
EXISTING ACP WATER LINE:	
NEW 16"Ø PVC:	
SEWER SERVICE LINE:	
EXISTING MAIN SEWER LINE:	
EXISTING STORM DRAIN:	
TELEPHONE CONDUIT:	
ELBOWS: 11.25"=	
22.5"=	
45"=	
FIRE HYDRANT: EXISTING	
NEW	
POWER/TEL POLE: TELEPHONE POLE	
ELECTRICITY POLE	
ALL IN 1 POLE	
TREES:	
HEDGES:	
SERVICE METER:	
GATE VALVE:	
STUB-OUT:	
AIR RELIEVE VALVE:	
BAC-T SAMPLING STN:	
PRV / PSV :	
ROADS:	
DIRT ROADS:	


GENERAL NOTE:

- CONSTRUCTION CONTRACTOR SHALL FIELD VERIFY ALL EXISTING UNDERGROUND INFRASTRUCTURE TO ENSURE SAFETY OF ITS WORKERS.
- AVOID ANY DAMAGES TO EXISTING GOVERNMENT UTILITIES.
- INSTALL 16"ØX16"ØX6: Ø SADDLE FOR FIRE HYDRANT CONNECTION. (OR SIMILAR CONNECTION)
- INSTALL 2"ØX16"Ø SADDLE OR SIMILAR CONNECTION FOR NEW SERVICE CONNECTION @ EVERY 500 FEET.

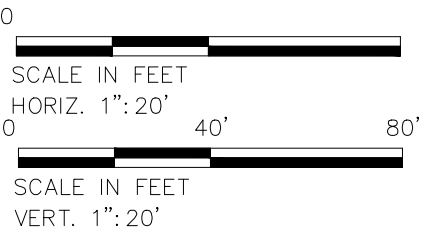


1 LOCATION PLAN
SCALE: AS SHOWN

2 PROFILE
SCALE: AS SHOWN


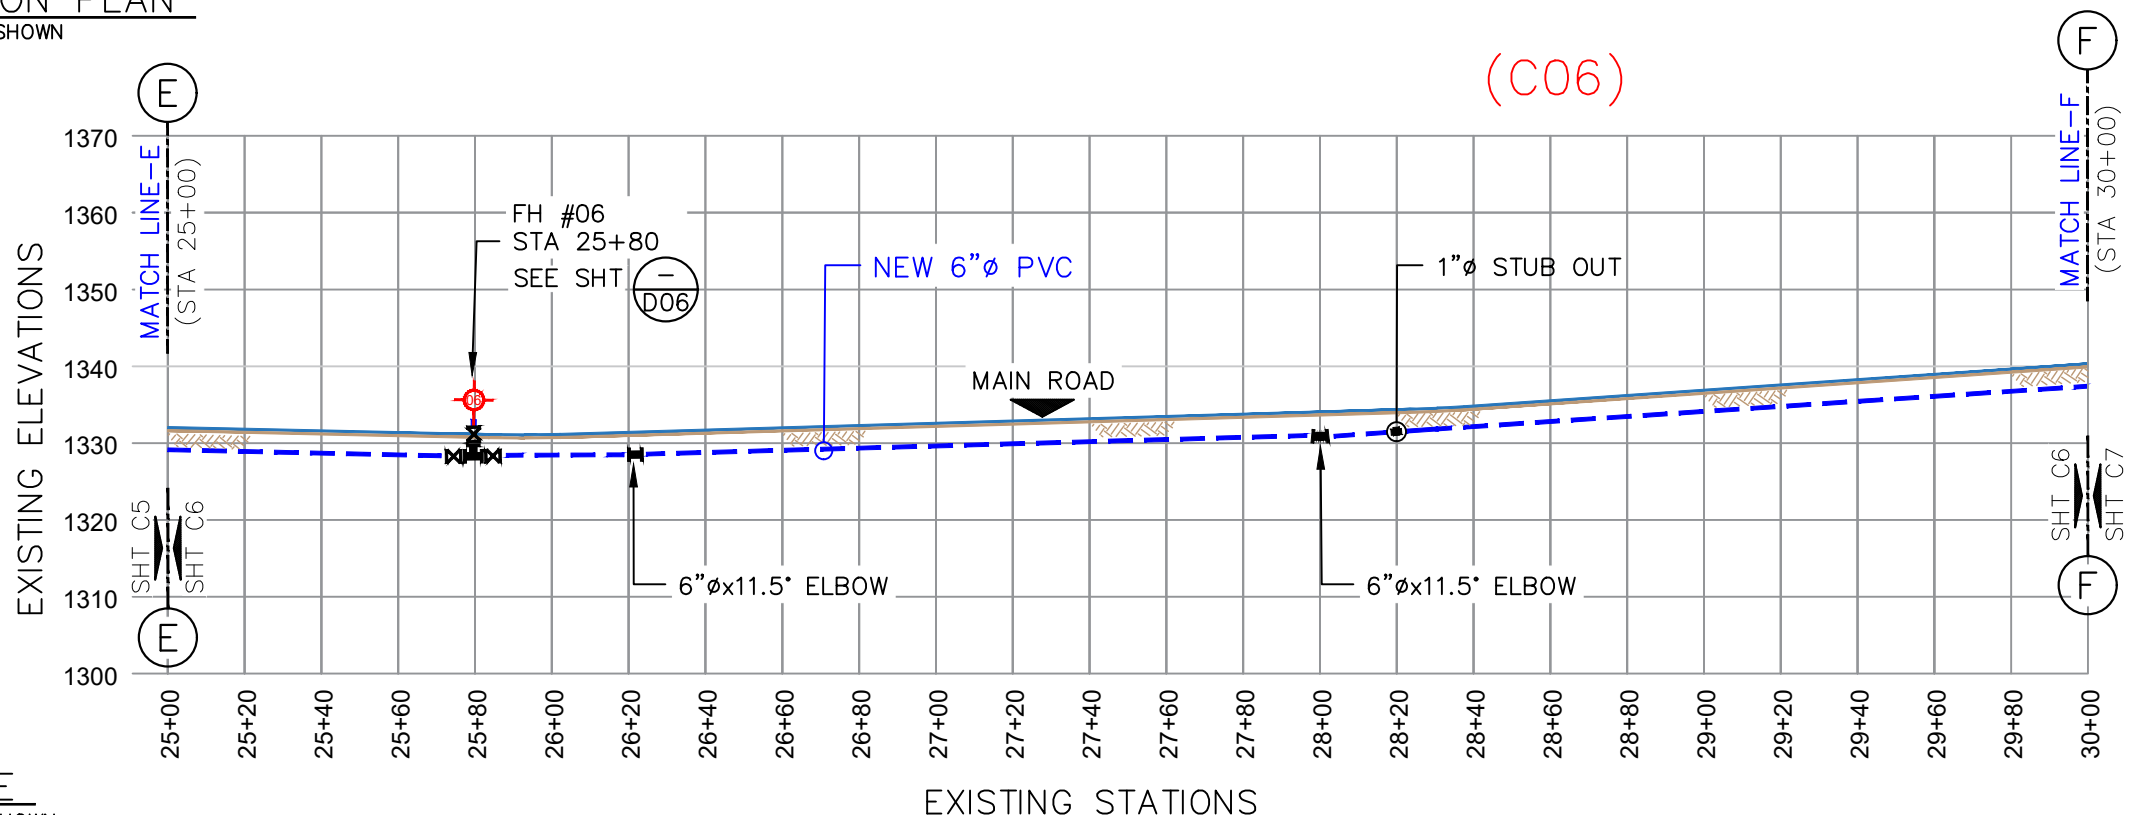


No. Description Date			REV. NO.:	PREPARED BY:	ASPA AMERICAN SAMOA POWER AUTHORITY ENGINEERING SERVICES DIVISION P.O.BOX PPB, TAFUNA, PAGO PAGO, AS 96799	PROJECT NAME:	AOLOAU 6"Ø WATERLINE REPLACEMENT PROJECT	SCALE:	AS SHOWN	SIGNATURE:
			REVISION:	CHECKED BY:		DRAWING TITLE:		PROJECT NO:		DATE:
			CHECKED BY:	APPROVED BY:		SEGMENT 1		1958785		
			APPROVED BY:	FAgui / LTyrell		PROFILE & PLAN (STA.25+00 to 30+00)				SHEET NO.
			DATE:	ISSUE FOR:		PROJECT LOCATION:		DATE:		C06
				Construction		AOLOAU VILLAGE, AMERICAN SAMOA		JULY 2023		

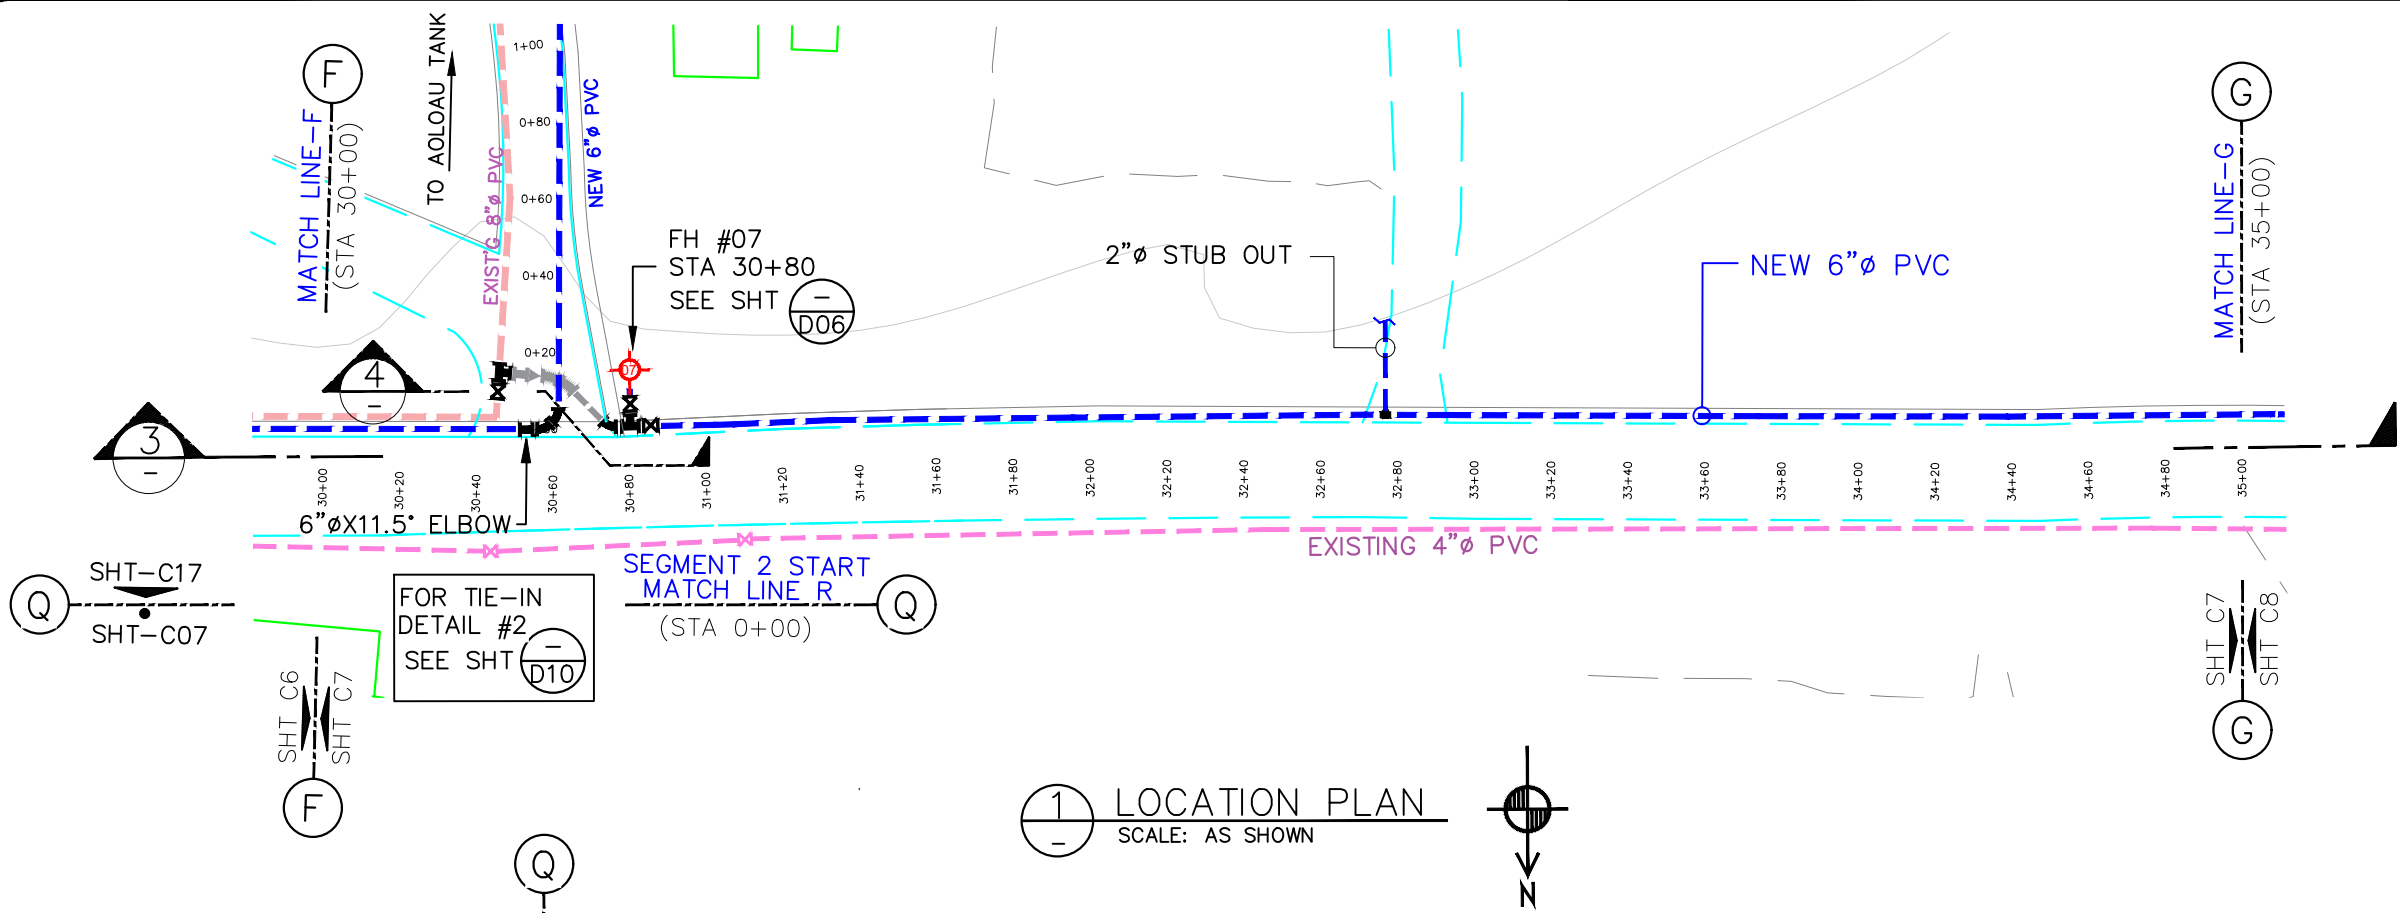

LEGEND:	
EXISTING ACP WATER LINE:	
NEW 16"Ø PVC:	
SEWER SERVICE LINE:	
EXISTING MAIN SEWER LINE:	
EXISTING STORM DRAIN:	
TELEPHONE CONDUIT:	
ELBOWS: 11.25"=	
22.5"=	
45"=	
FIRE HYDRANT: EXISTING	
NEW	
POWER/TEL POLE:	
TELEPHONE POLE	
ELECTRICITY POLE	
ALL IN 1 POLE	
TREES:	
HEDGES:	
SERVICE METER:	
GATE VALVE:	
STUB-OUT:	
AIR RELIEVE VALVE:	
BAC-T SAMPLING STN:	
PRV / PSV :	
ROADS:	
DIRT ROADS:	

- CONSTRUCTION CONTRACTOR SHALL FIELD VERIFY ALL EXISTING UNDERGROUND INFRASTRUCTURE TO ENSURE SAFETY OF ITS WORKERS.
- AVOID ANY DAMAGES TO EXISTING GOVERNMENT UTILITIES.
- INSTALL 16"ØX16"ØX6:Ø SADDLE FOR FIRE HYDRANT CONNECTION. (OR SIMILAR CONNECTION)
- INSTALL 2"ØX16"Ø SADDLE OR SIMILAR CONNECTION FOR NEW SERVICE CONNECTION @ EVERY 500 FEET.

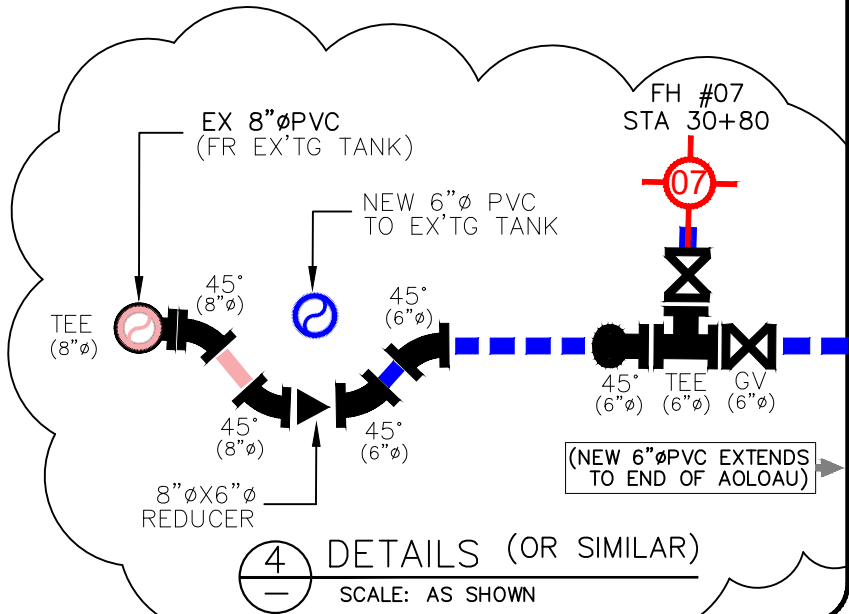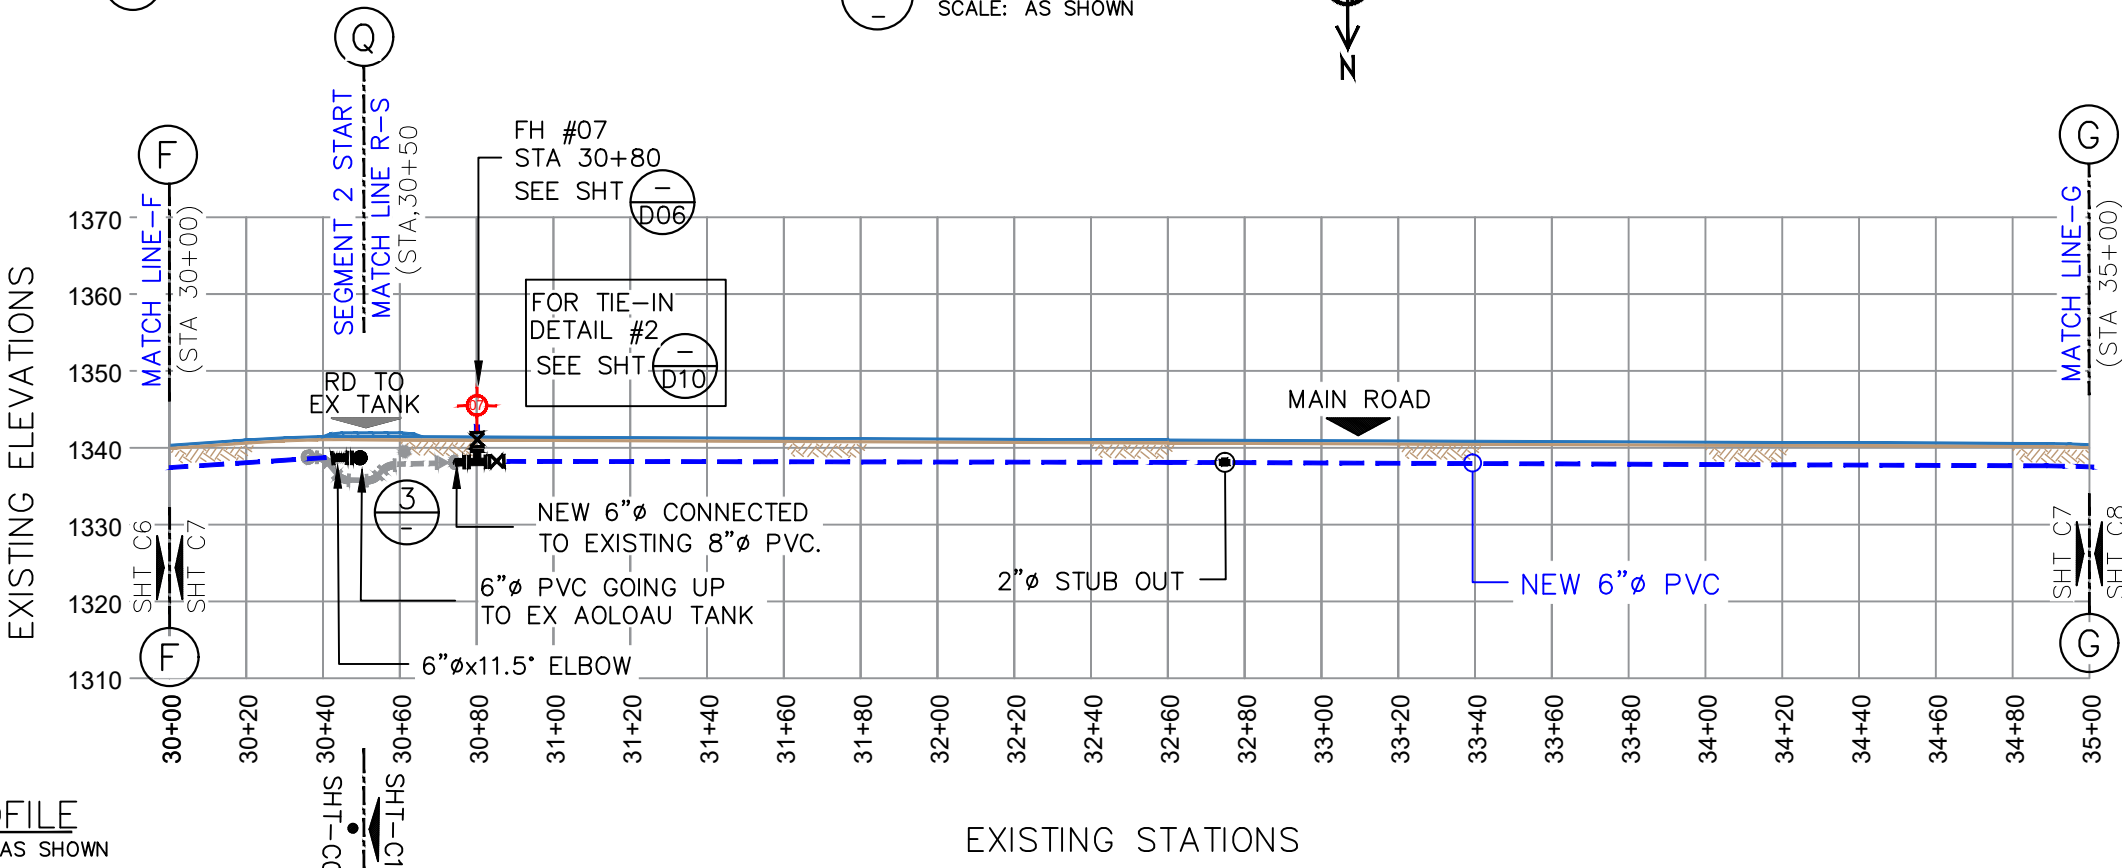

No.	Description	Date

REV. NO.:	PREPARED BY:
	FToala
REVISION:	CHECKED BY:
	LTyrell
CHECKED BY:	APPROVED BY:
	FAguila / LTyrell
APPROVED BY:	ISSUE FOR:
	Construction
DATE:	




AMERICAN SAMOA POWER AUTHORITY
ENGINEERING SERVICES DIVISION
P.O.BOX PPB, TAFUNA, PAGO PAGO, AS 96799

PROJECT NAME:
AOLOAU 6"Ø WATERLINE REPLACEMENT PROJECT
DRAWING TITLE:
SEGMENT 1 PROFILE & PLAN (STA.30+00 to 35+00)
PROJECT LOCATION:
AOLOAU VILLAGE, AMERICAN SAMOA

SCALE:
AS SHOWN
PROJECT NO:
1958785
DATE:
JULY 2023


SIGNATURE:
DATE:
SHEET NO.
C07

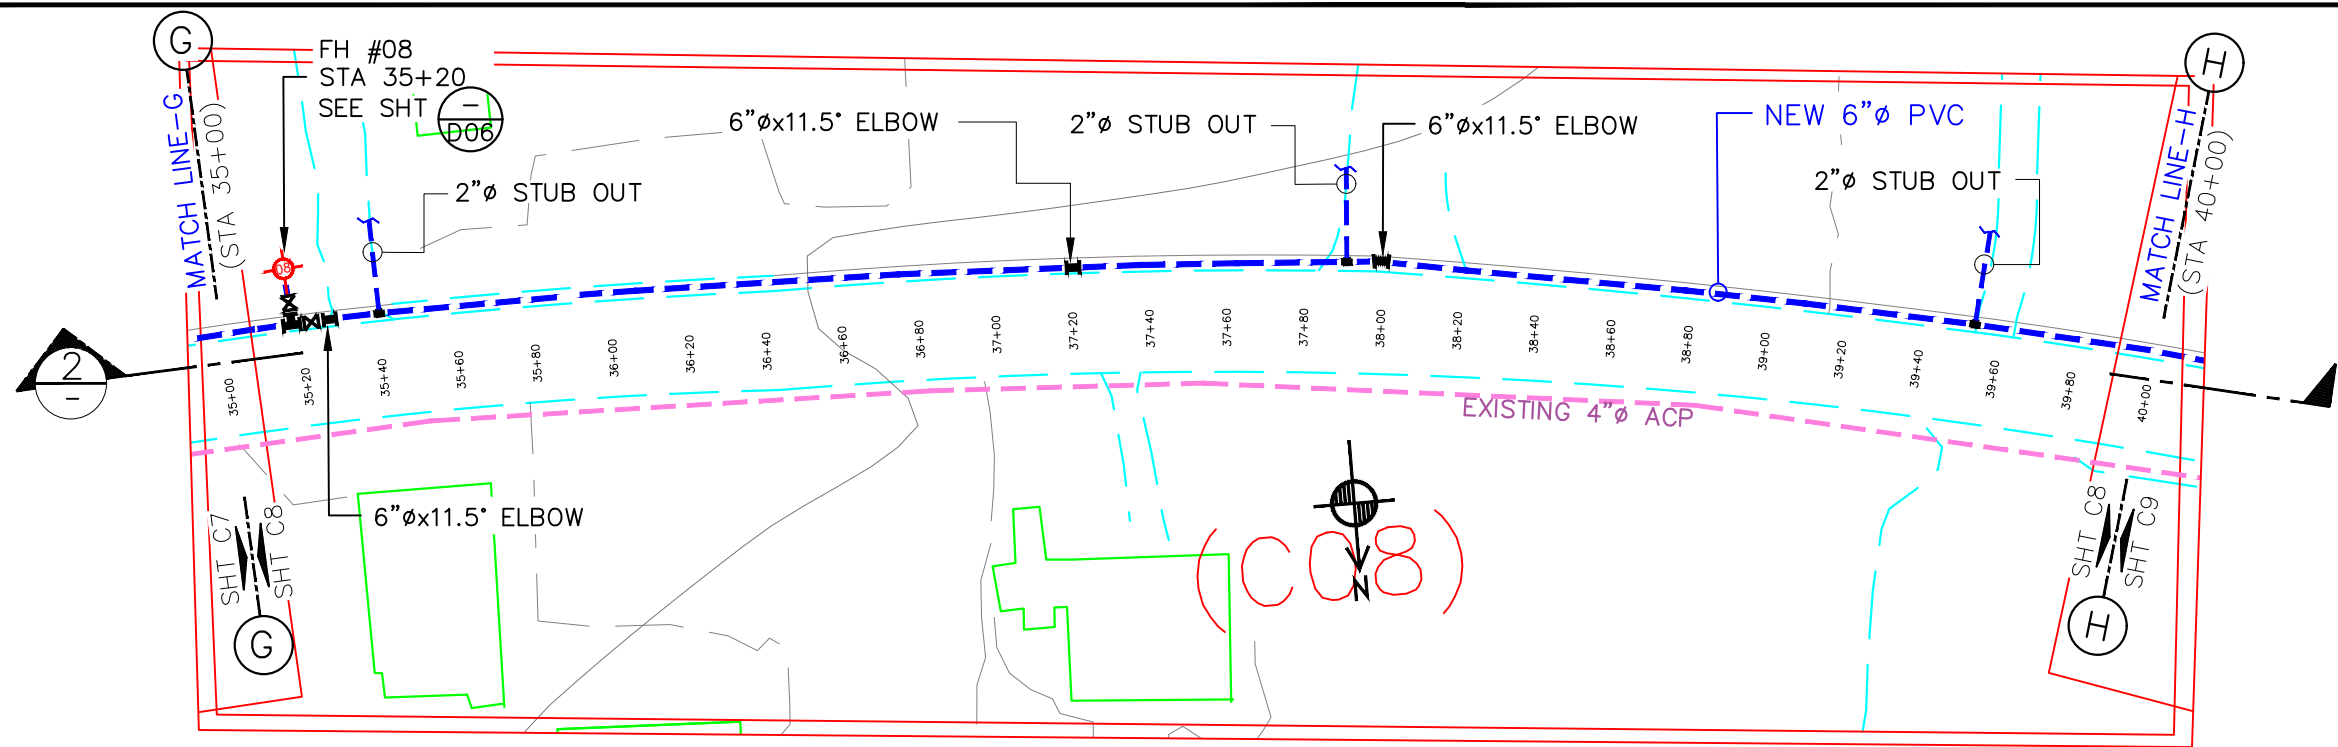


LEGEND:	
EXISTING ACP WATER LINE:	
NEW 16"Ø PVC:	
SEWER SERVICE LINE:	
EXISTING MAIN SEWER LINE:	
EXISTING STORM DRAIN:	
TELEPHONE CONDUIT:	
ELBOWS: 11.25°=	
22.5°=	
45°=	
FIRE HYDRANT: EXISTING	
NEW	
POWER/TEL POLE: TELEPHONE POLE	
ELECTRICITY POLE	
ALL IN 1 POLE	
TREES:	
HEDGES:	
SERVICE METER:	
GATE VALVE:	
STUB-OUT:	
AIR RELIEVE VALVE:	
BAC-T SAMPLING STN:	
PRV / PSV :	
ROADS:	
DIRT ROADS:	

GENERAL NOTE:

- CONSTRUCTION CONTRACTOR SHALL FIELD VERIFY ALL EXISTING UNDERGROUND INFRASTRUCTURE TO ENSURE SAFETY OF ITS WORKERS.
- AVOID ANY DAMAGES TO EXISTING GOVERNMENT UTILITIES.
- INSTALL 16"ØX16"ØX6: Ø SADDLE FOR FIRE HYDRANT CONNECTION. (OR SIMILAR CONNECTION)
- INSTALL 2"ØX16"Ø SADDLE OR SIMILAR CONNECTION FOR NEW SERVICE CONNECTION @ EVERY 500 FEET.

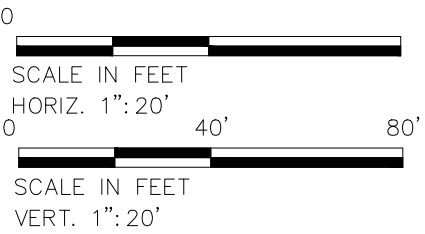


1 LOCATION PLAN
SCALE: AS SHOWN

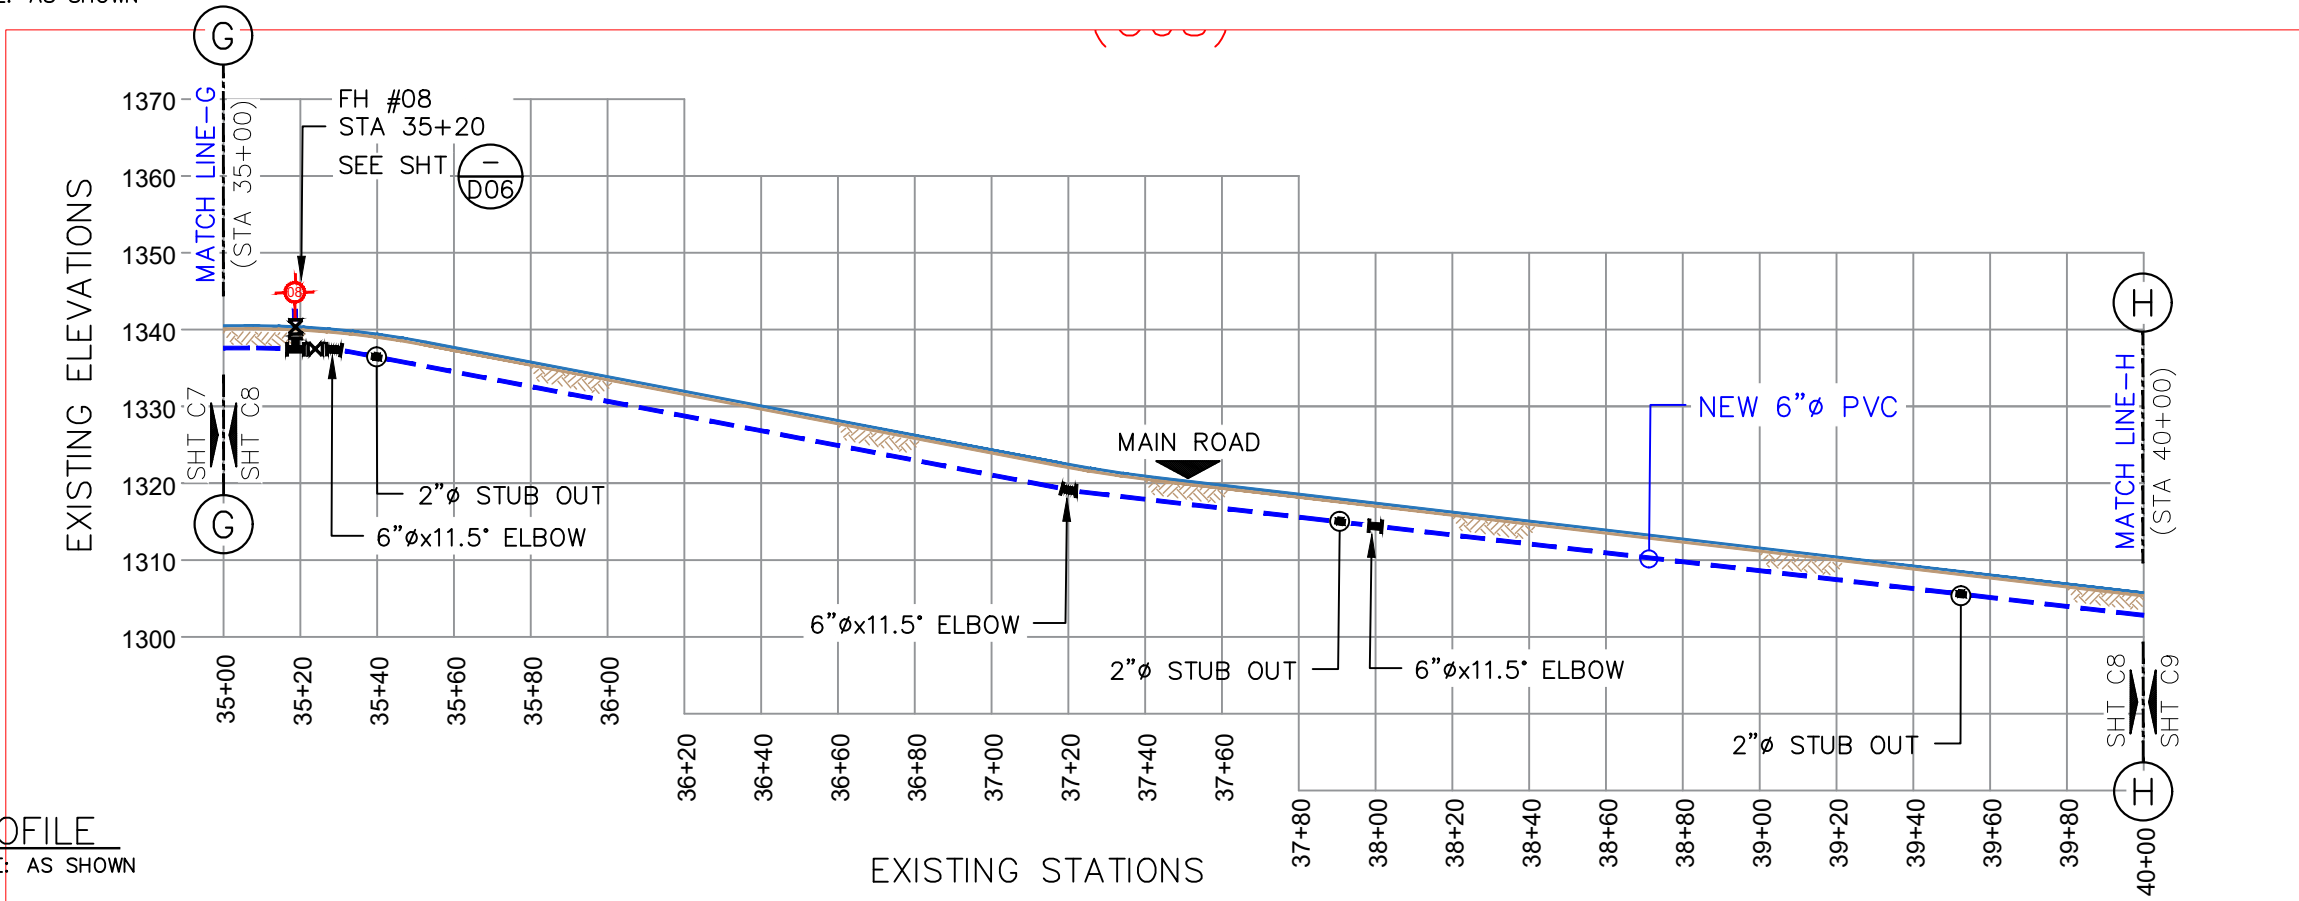

2 PROFILE
SCALE: AS SHOWN

No.	Description	Date	REV. NO.:	PREPARED BY:
				FToala
			REVISION:	CHECKED BY:
				LTyrell
			CHECKED BY:	APPROVED BY:
				FAguila / LTyrell
			APPROVED BY:	ISSUE FOR:
				Construction
			DATE:	

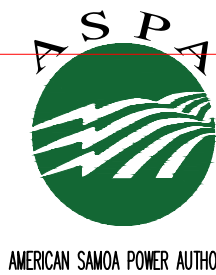


AMERICAN SAMOA POWER AUTHORITY
ENGINEERING SERVICES DIVISION
P.O.BOX PPB, TAFUNA, PAGO PAGO, AS 96799

PROJECT NAME:
AOLOAU 6"Ø WATERLINE REPLACEMENT PROJECT

DRAWING TITLE:
SEGMENT 1
PROFILE & PLAN (STA.35+00 to 40+00)

PROJECT LOCATION:
AOLOAU VILLAGE, AMERICAN SAMOA



SCALE: AS SHOWN	SIGNATURE:
PROJECT NO: 1958785	DATE:
DATE: JULY 2023	SHEET NO. C08

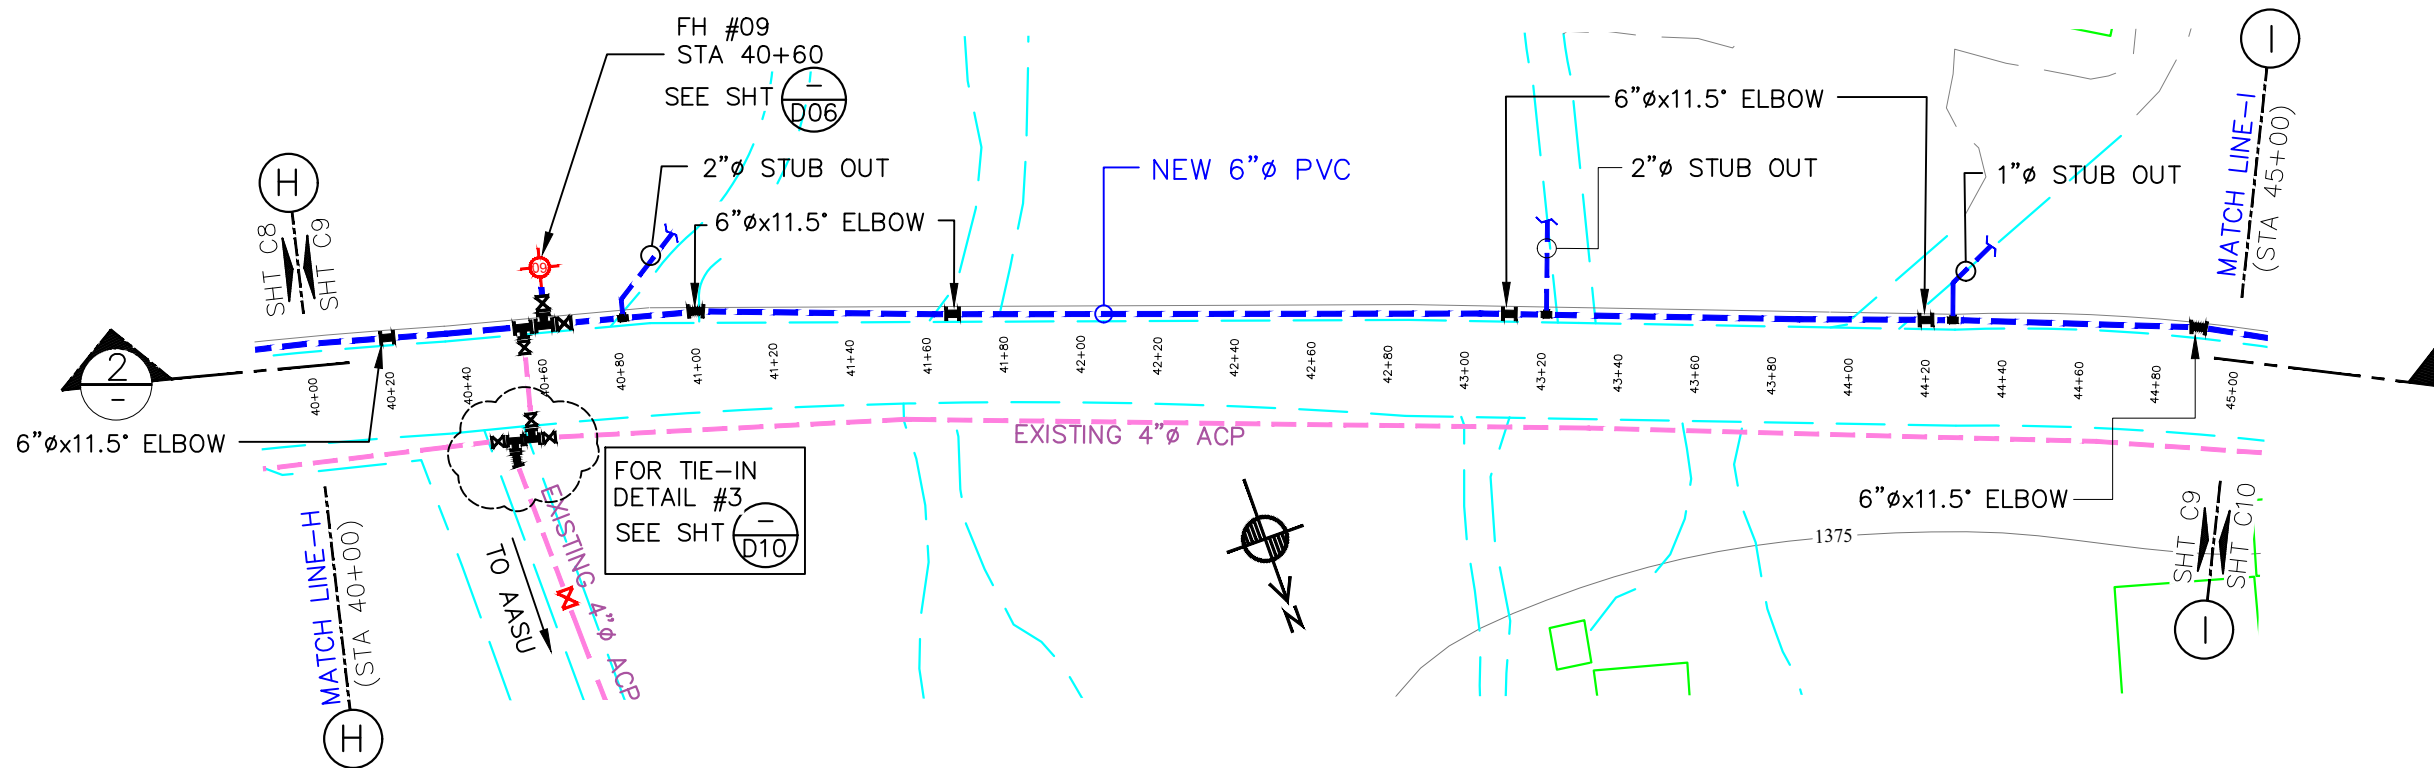

LEGEND:	
EXISTING ACP WATER LINE:	
NEW 16"Ø PVC:	
SEWER SERVICE LINE:	
EXISTING MAIN SEWER LINE:	
EXISTING STORM DRAIN:	
TELEPHONE CONDUIT:	
ELBOWS: 11.25"=	
22.5"=	
45"=	
FIRE HYDRANT:	EXISTING NEW
POWER/TEL POLE:	TELEPHONE POLE ELECTRICITY POLE ALL IN 1 POLE
TREES:	
HEDGES:	
SERVICE METER:	
GATE VALVE:	
STUB-OUT:	
AIR RELIEVE VALVE:	
BAC-T SAMPLING STN:	
PRV / PSV :	
ROADS:	
DIRT ROADS:	

- GENERAL NOTE:
- CONSTRUCTION CONTRACTOR SHALL FIELD VERIFY ALL EXISTING UNDERGROUND INFRASTRUCTURE TO ENSURE SAFETY OF ITS WORKERS.
 - AVOID ANY DAMAGES TO EXISTING GOVERNMENT UTILITIES.
 - INSTALL 16"ØX16"ØX6:Ø SADDLE FOR FIRE HYDRANT CONNECTION. (OR SIMILAR CONNECTION)
 - INSTALL 2"ØX16"Ø SADDLE OR SIMILAR CONNECTION FOR NEW SERVICE CONNECTION @ EVERY 500 FEET.

1 LOCATION PLAN
SCALE: AS SHOWN

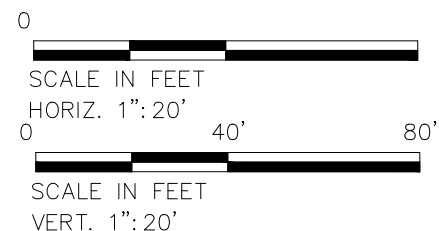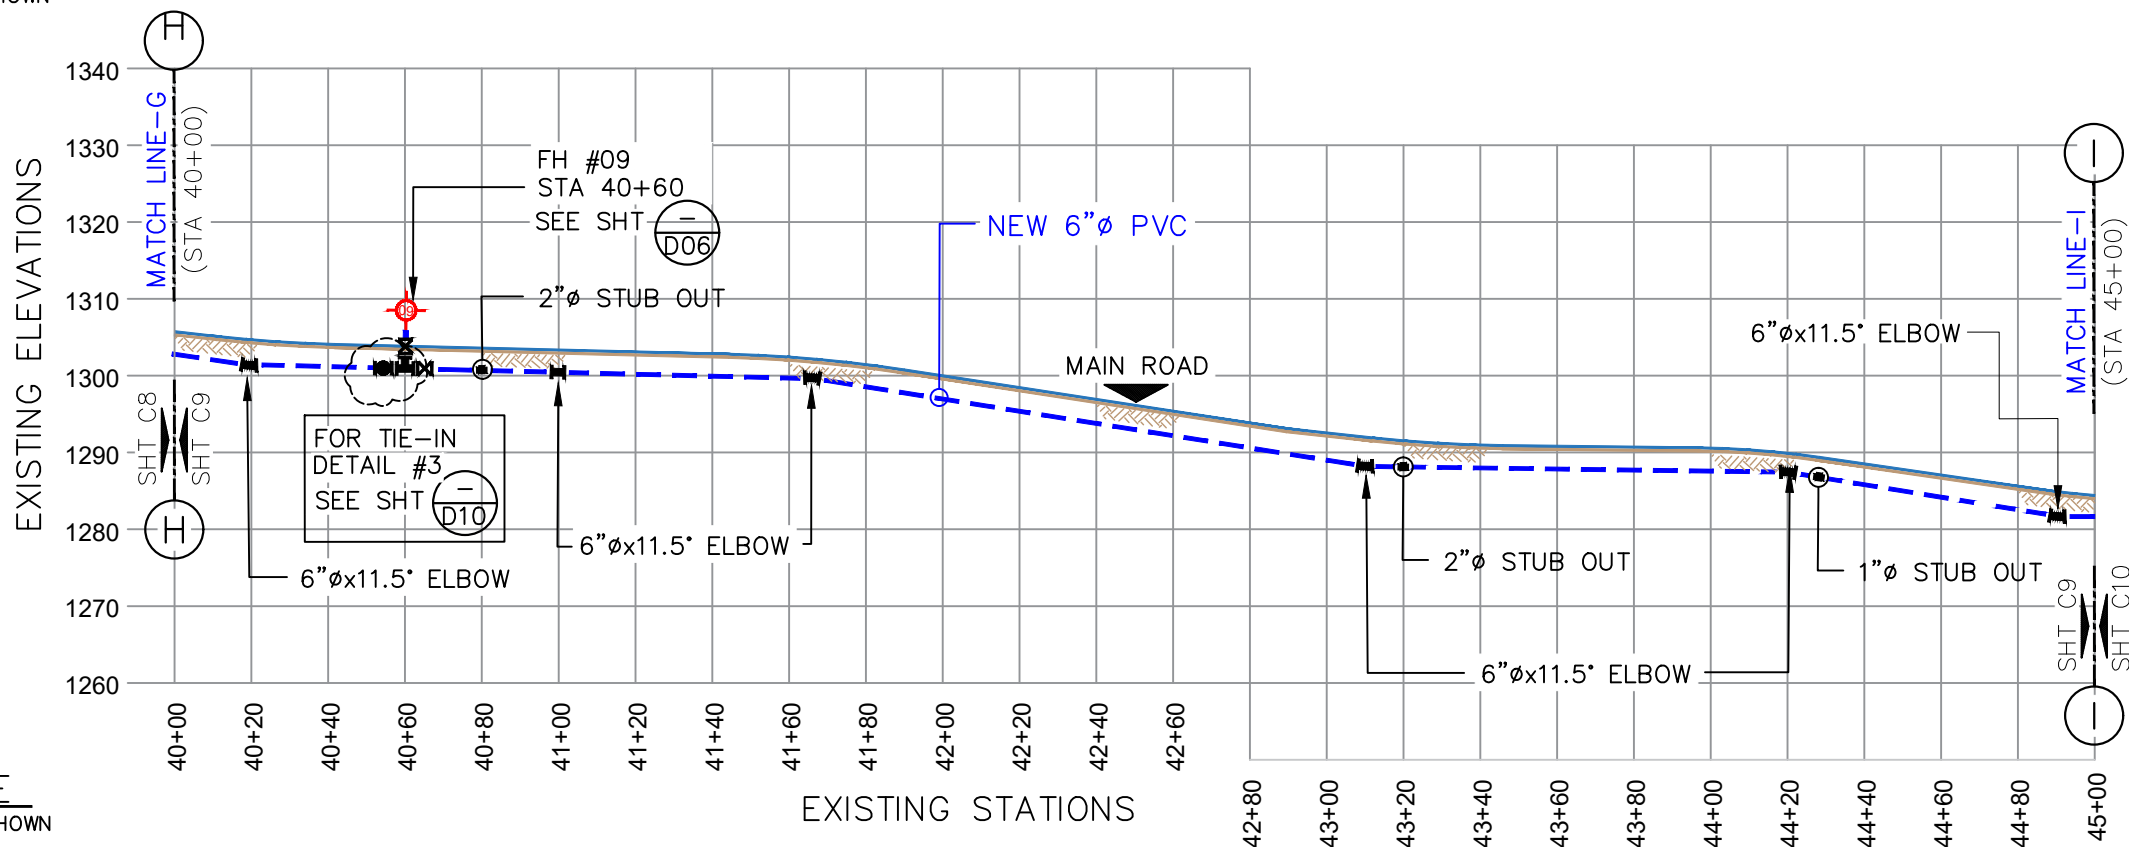

2 PROFILE
SCALE: AS SHOWN

No.	Description	Date	REV. NO.:	PREPARED BY:
				FToala
			REVISION:	CHECKED BY:
				LTyrell
			CHECKED BY:	APPROVED BY:
				FAguila / LTyrell
			APPROVED BY:	ISSUE FOR:
				Construction
			DATE:	



AMERICAN SAMOA POWER AUTHORITY
ENGINEERING SERVICES DIVISION

P.O.BOX PPB, TAFUNA, PAGO PAGO, AS 96799

PROJECT NAME:
AOLOAU 6"Ø WATERLINE REPLACEMENT PROJECT

DRAWING TITLE:
SEGMENT 1
PROFILE & PLAN (STA.40+00 to 45+00)

PROJECT LOCATION:
AOLOAU VILLAGE, AMERICAN SAMOA

SCALE:
AS SHOWN


PROJECT NO:
1958785

DATE:
JULY 2023


SIGNATURE:
DATE:

SHEET NO.

C09

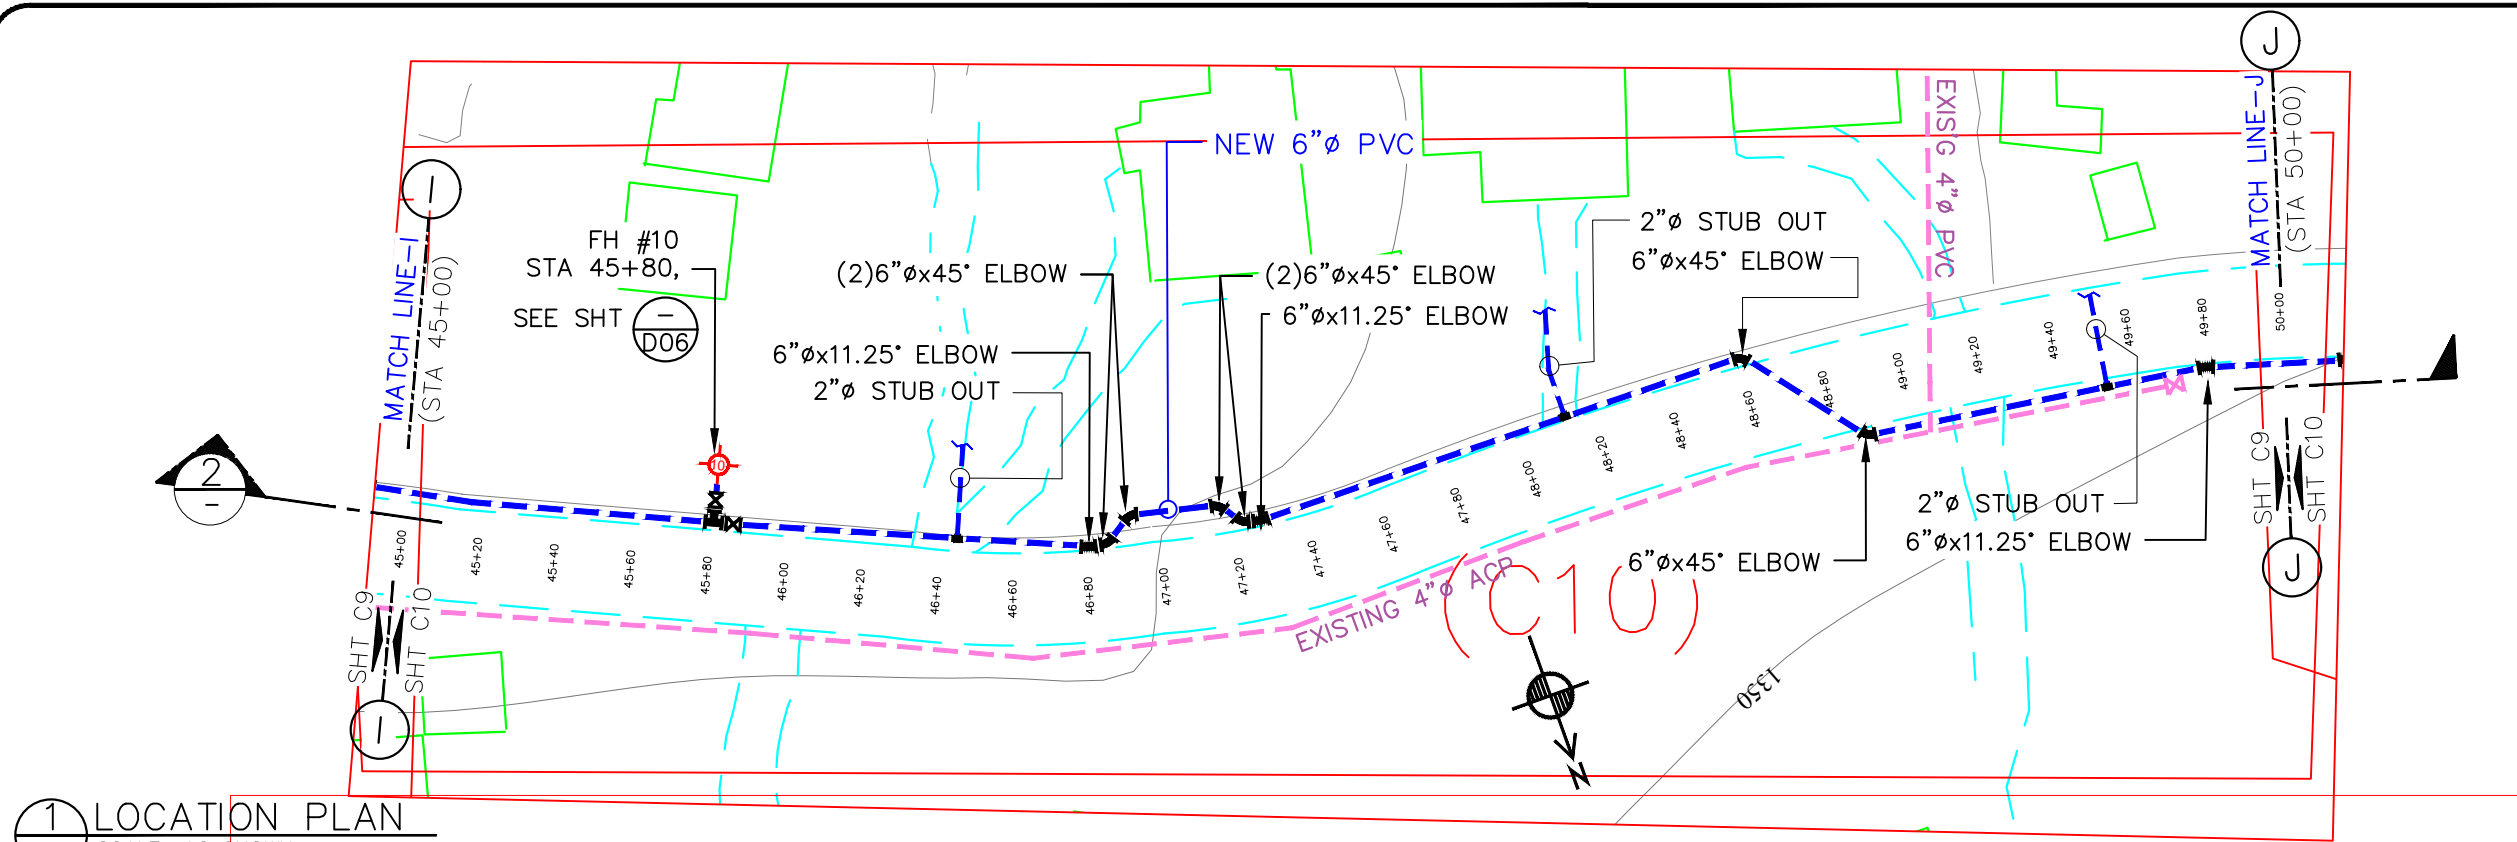


1 LOCATION PLAN
SCALE: AS SHOWN

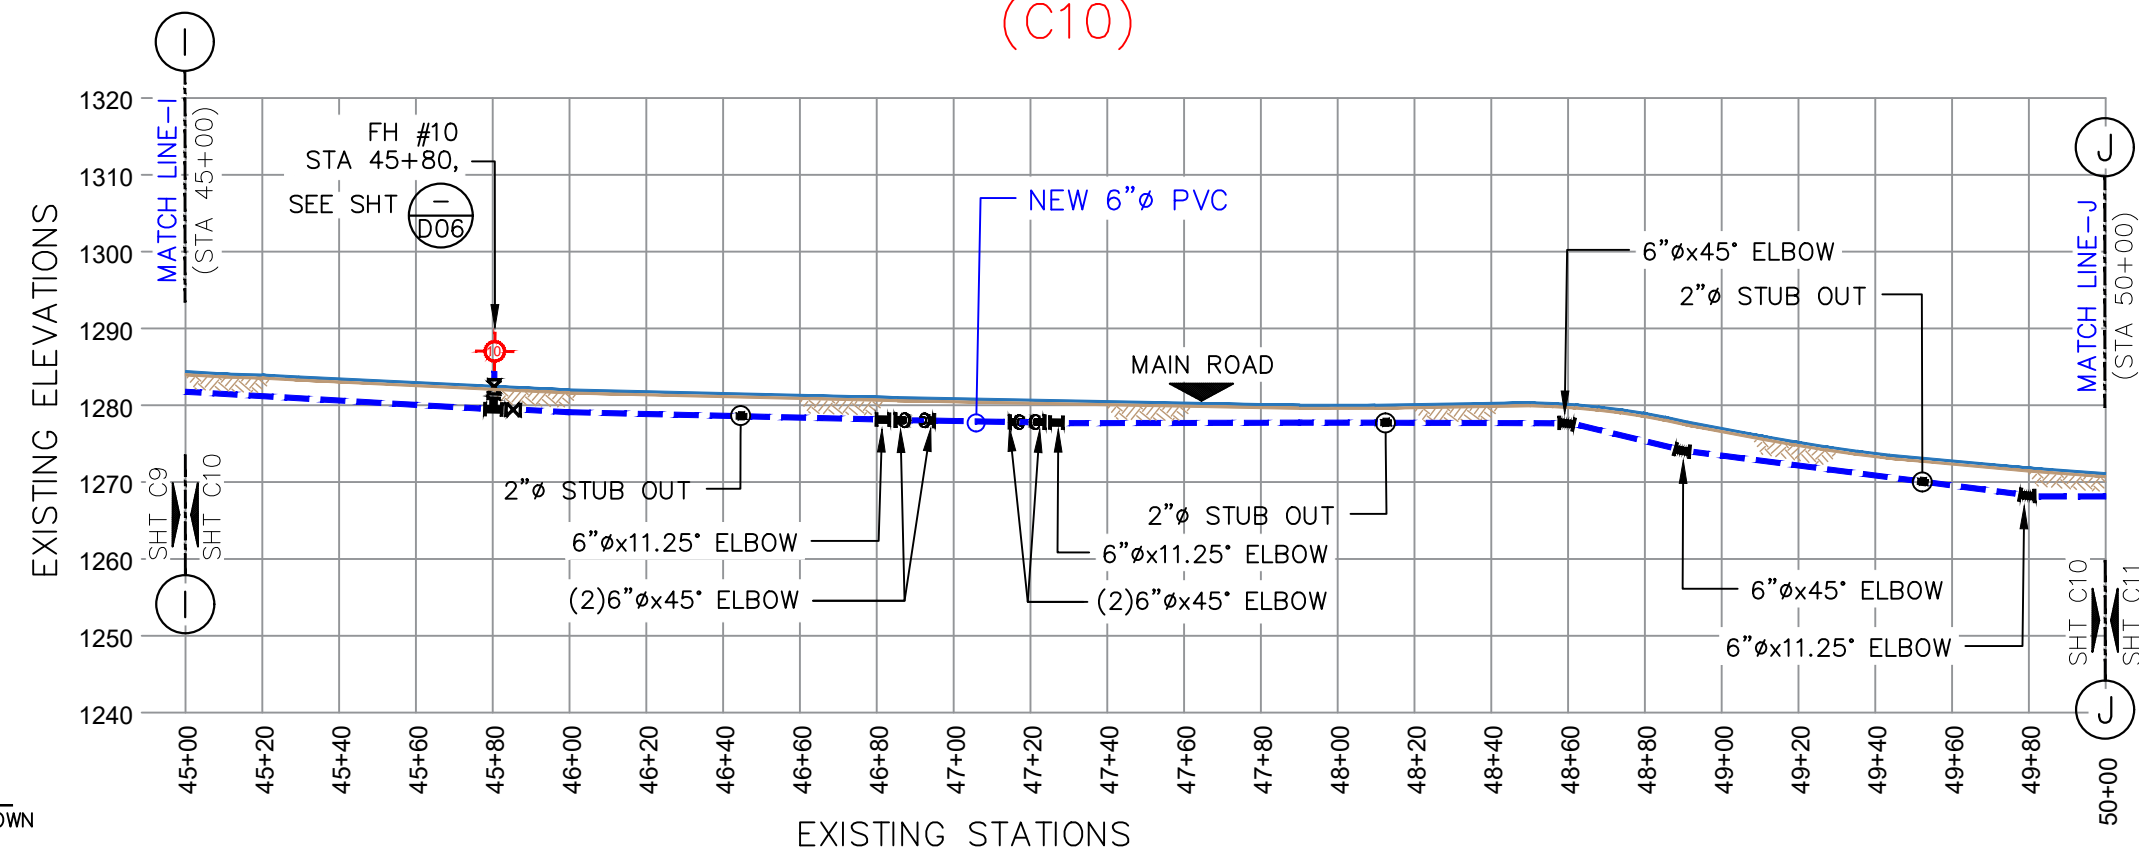

2 PROFILE
SCALE: AS SHOWN

LEGEND:	
EXISTING ACP WATER LINE:	
NEW 16"Ø PVC:	
SEWER SERVICE LINE:	
EXISTING MAIN SEWER LINE:	
EXISTING STORM DRAIN:	
TELEPHONE CONDUIT:	
ELBOWS: 11.25"= 22.5"= 45"=	
FIRE HYDRANT: EXISTING NEW	
POWER/TEL POLE: TELEPHONE POLE ELECTRICITY POLE ALL IN 1 POLE	
TREES: HEDGES:	
SERVICE METER:	
GATE VALVE:	
STUB-OUT:	
AIR RELIEVE VALVE:	
BAC-T SAMPLING STN:	
PRV / PSV :	
ROADS: DIRT ROADS:	

- GENERAL NOTE:
- CONSTRUCTION CONTRACTOR SHALL FIELD VERIFY ALL EXISTING UNDERGROUND INFRASTRUCTURE TO ENSURE SAFETY OF ITS WORKERS.
 - AVOID ANY DAMAGES TO EXISTING GOVERNMENT UTILITIES.
 - INSTALL 16"ØX16"ØX6:Ø SADDLE FOR FIRE HYDRANT CONNECTION. (OR SIMILAR CONNECTION)
 - INSTALL 2"ØX16"Ø SADDLE OR SIMILAR CONNECTION FOR NEW SERVICE CONNECTION @ EVERY 500 FEET.

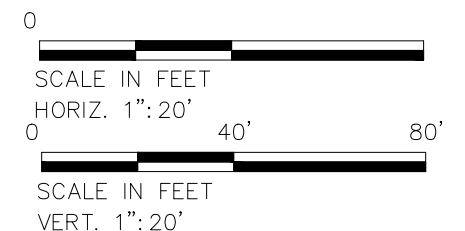

No.	Description	Date	REV. NO.:	PREPARED BY:
				FToala
			REVISION:	CHECKED BY:
				LTyrell
			CHECKED BY:	APPROVED BY:
				FAguila / LTyrell
			APPROVED BY:	ISSUE FOR:
				Construction
			DATE:	



AMERICAN SAMOA POWER AUTHORITY

AMERICAN SAMOA POWER AUTHORITY
ENGINEERING SERVICES DIVISION

P.O.BOX PPB, TAFUNA, PAGO PAGO, AS 96799

PROJECT NAME:
AOLOAU 6"Ø WATERLINE REPLACEMENT PROJECT

DRAWING TITLE:
SEGMENT 1
PROFILE & PLAN (STA.45+00 to 50+00)

PROJECT LOCATION:
AOLOAU VILLAGE, AMERICAN SAMOA

SCALE:
AS SHOWN


PROJECT NO:
1958785

DATE:
JULY 2023

SIGNATURE:

DATE:


SHEET NO.
C10

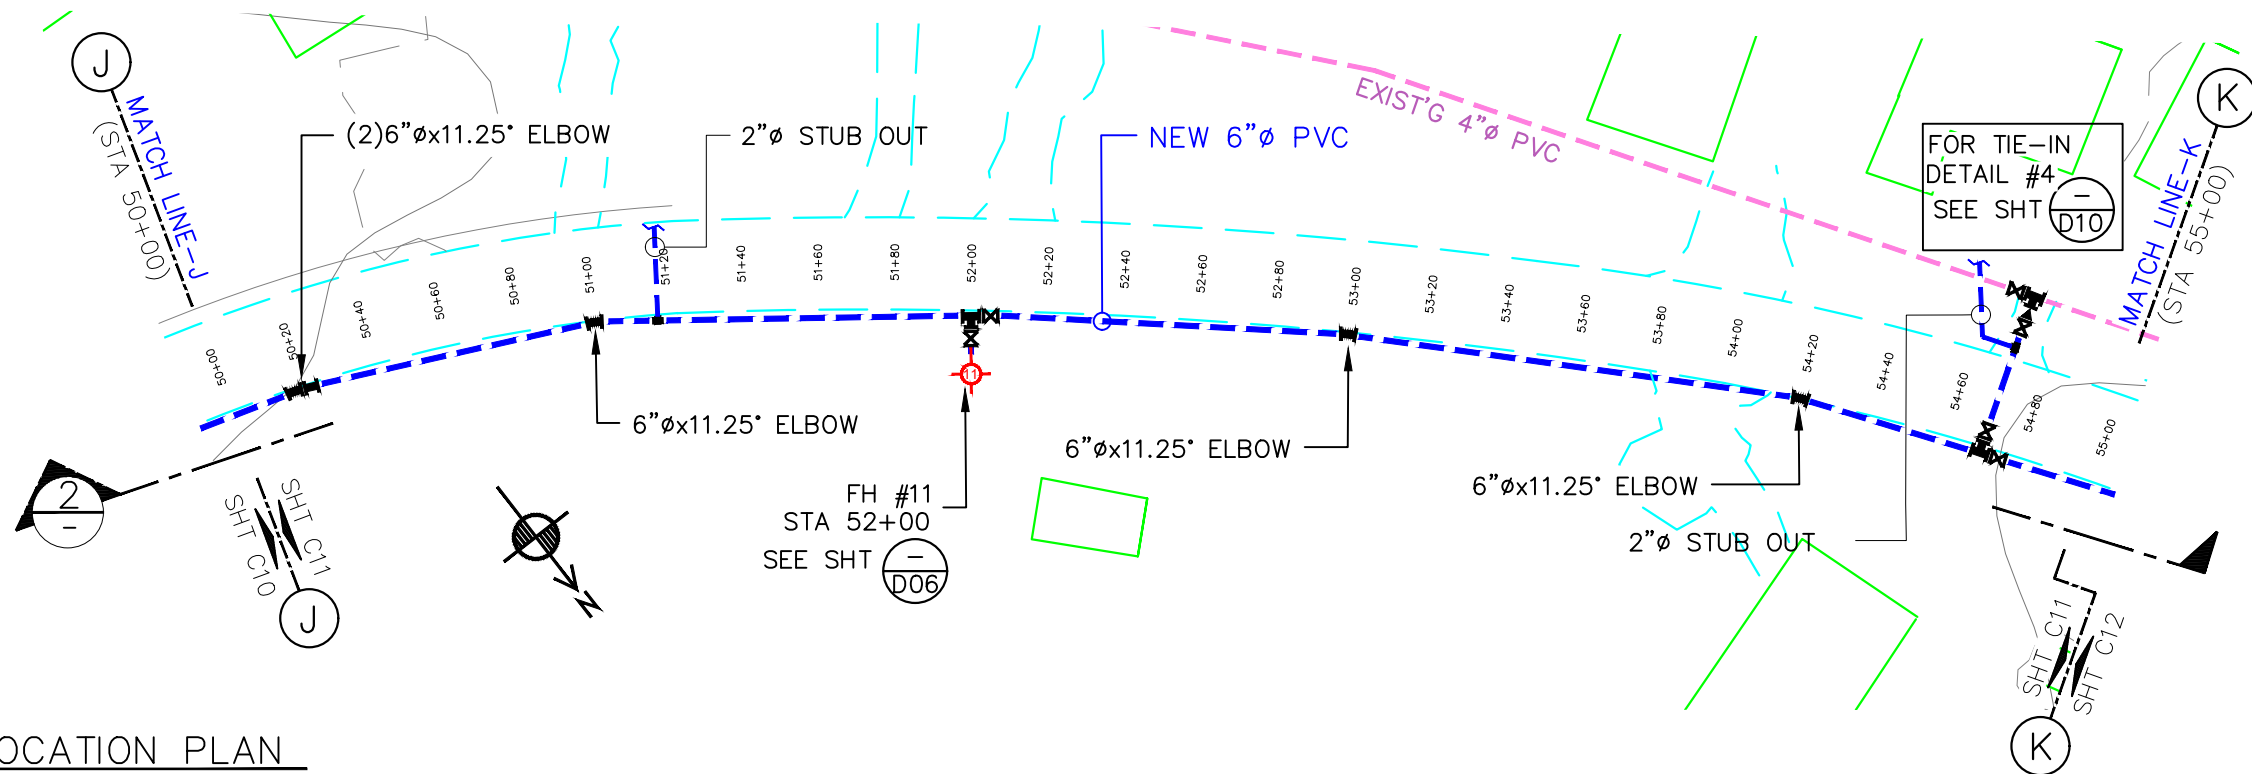


LEGEND:	
EXISTING ACP WATER LINE:	
NEW 16"Ø PVC:	
SEWER SERVICE LINE:	
EXISTING MAIN SEWER LINE:	
EXISTING STORM DRAIN:	
TELEPHONE CONDUIT:	
ELBOWS: 11.25'=	
22.5'=	
45'=	
FIRE HYDRANT: EXISTING	
NEW	
POWER/TEL POLE:	
TELEPHONE POLE	
ELECTRICITY POLE	
ALL IN 1 POLE	
TREES:	
HEDGES:	
SERVICE METER:	
GATE VALVE:	
STUB-OUT:	
AIR RELIEVE VALVE:	
BAC-T SAMPLING STN:	
PRV / PSV :	
ROADS:	
DIRT ROADS:	

GENERAL NOTE:

- CONSTRUCTION CONTRACTOR SHALL FIELD VERIFY ALL EXISTING UNDERGROUND INFRASTRUCTURE TO ENSURE SAFETY OF ITS WORKERS.
- AVOID ANY DAMAGES TO EXISTING GOVERNMENT UTILITIES.
- INSTALL 16"ØX16"ØX6:Ø SADDLE FOR FIRE HYDRANT CONNECTION. (OR SIMILAR CONNECTION)
- INSTALL 2"ØX16"Ø SADDLE OR SIMILAR CONNECTION FOR NEW SERVICE CONNECTION @ EVERY 500 FEET.

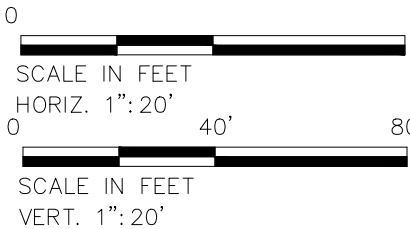

1 LOCATION PLAN
SCALE: AS SHOWN

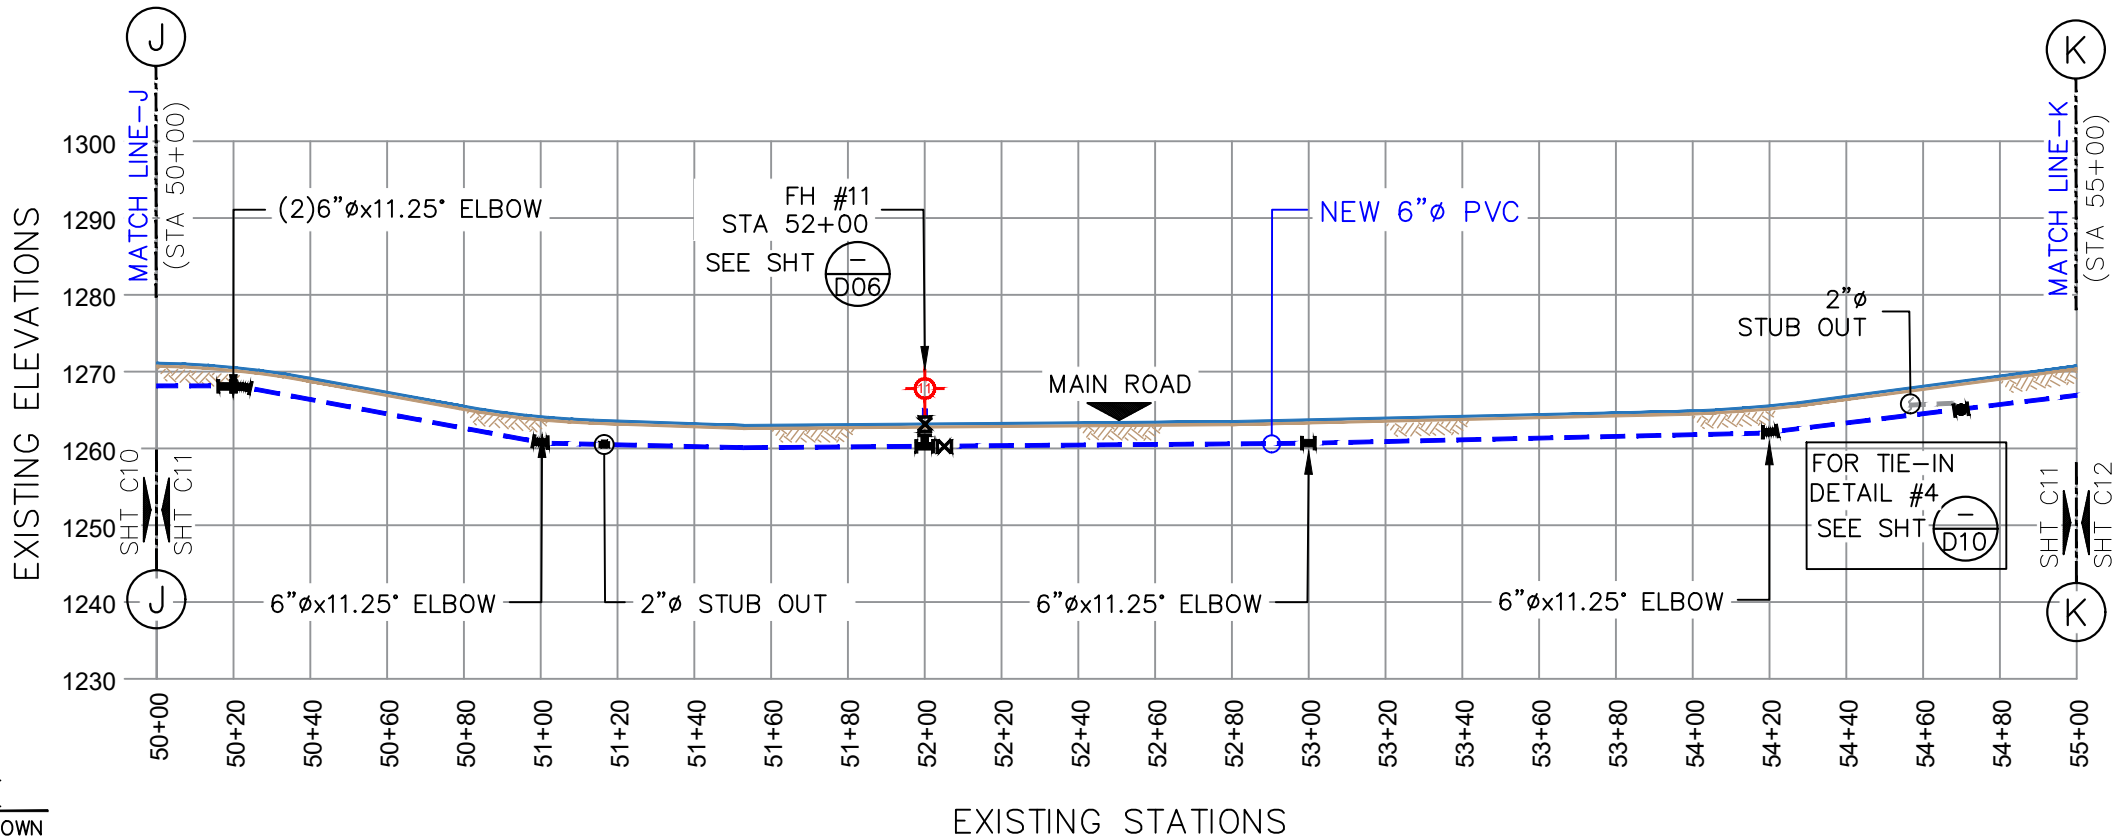

2 PROFILE
SCALE: AS SHOWN

No.	Description	Date	REV. NO.:	PREPARED BY:
				FToala
			REVISION:	CHECKED BY:
				LTyrell
			CHECKED BY:	APPROVED BY:
				FAguila / LTyrell
			APPROVED BY:	ISSUE FOR:
				Construction
			DATE:	



AMERICAN SAMOA POWER AUTHORITY
ENGINEERING SERVICES DIVISION

P.O.BOX PPB, TAFUNA, PAGO PAGO, AS 96799

PROJECT NAME:
AOLOAU 6"Ø WATERLINE REPLACEMENT PROJECT

DRAWING TITLE:
SEGMENT 1
PROFILE & PLAN (STA.50+00 to 55+00)

PROJECT LOCATION:
AOLOAU VILLAGE, AMERICAN SAMOA

SCALE:
AS SHOWN


PROJECT NO:
1958785

DATE:
JULY 2023


SIGNATURE:

DATE:

SHEET NO.
C11

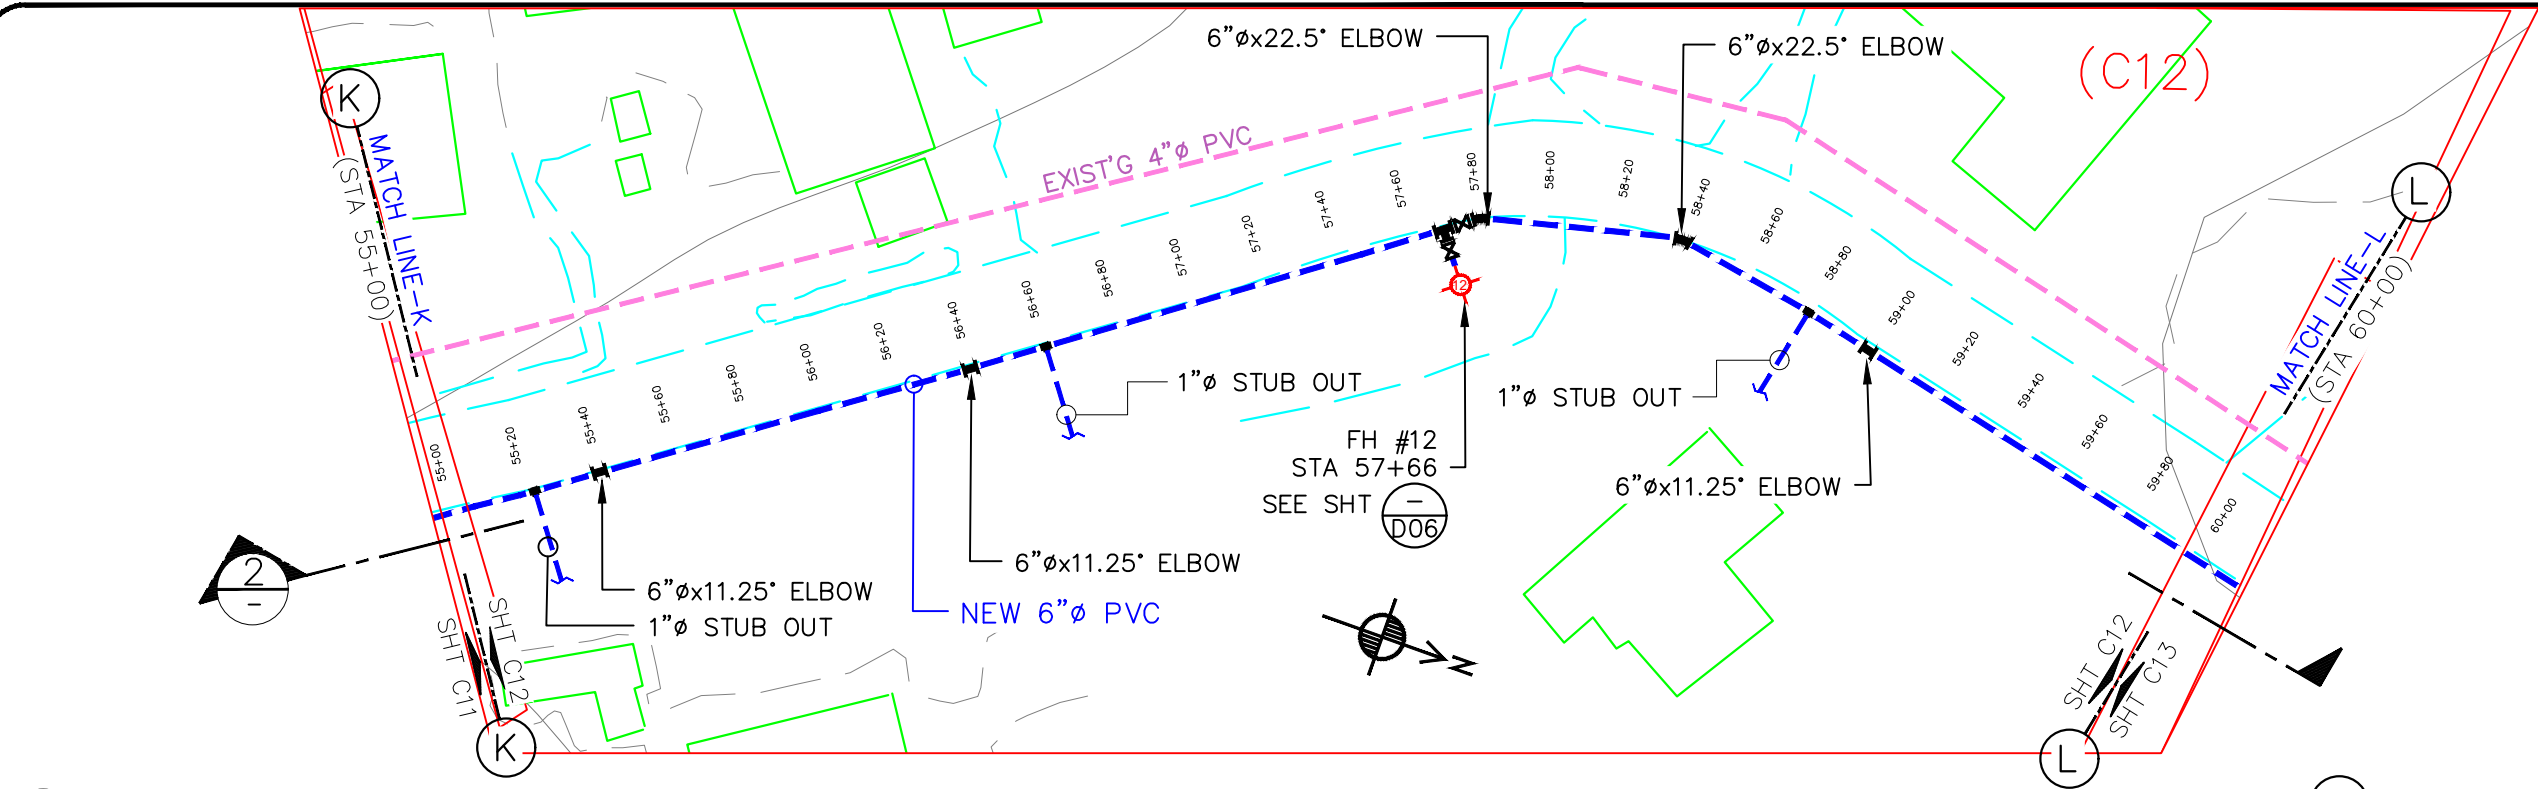


1 LOCATION PLAN
SCALE: AS SHOWN

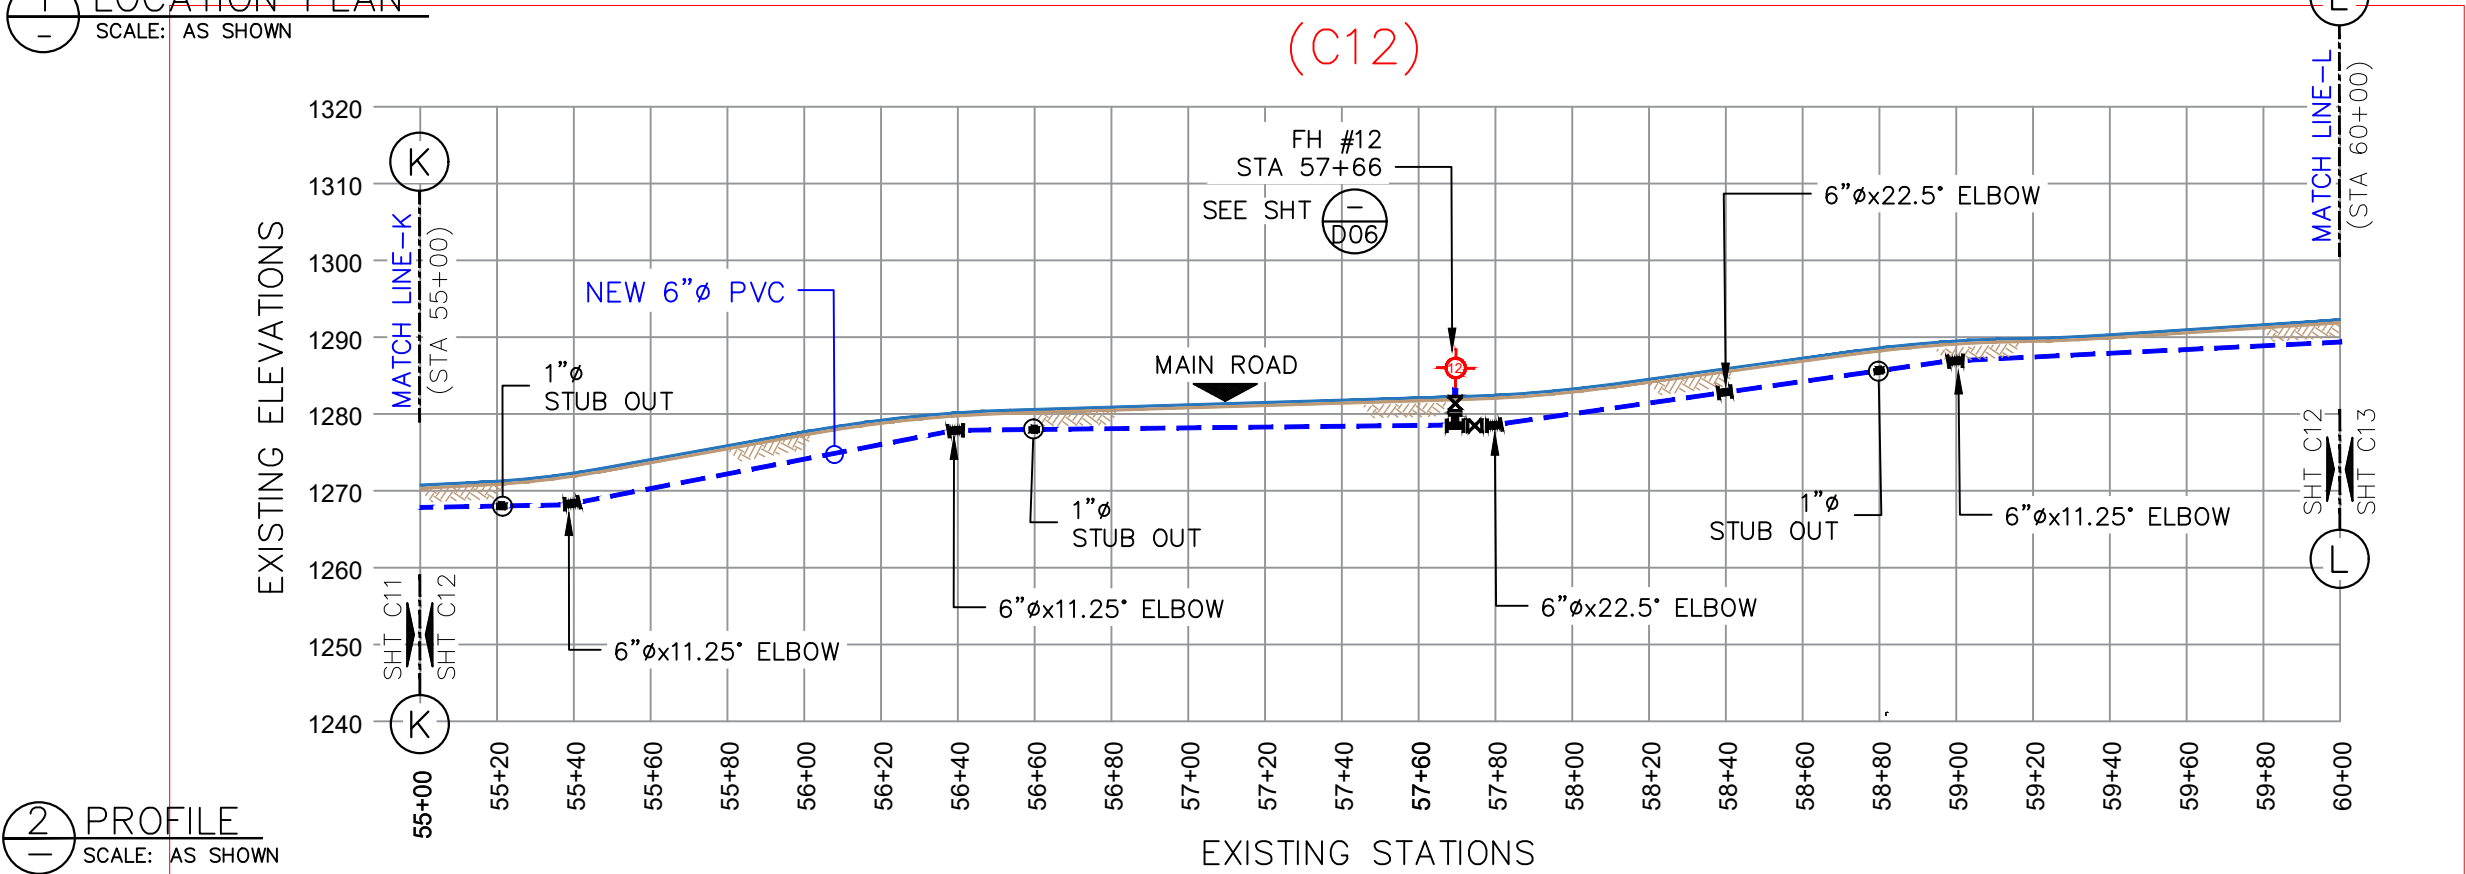

2 PROFILE
SCALE: AS SHOWN

LEGEND:	
EXISTING ACP WATER LINE:	
NEW 16"Ø PVC:	
SEWER SERVICE LINE:	
EXISTING MAIN SEWER LINE:	
EXISTING STORM DRAIN:	
TELEPHONE CONDUIT:	
ELBOWS: 11.25"=	22.5"= 45"=
FIRE HYDRANT: EXISTING	NEW
POWER/TEL POLE: TELEPHONE POLE	ELECTRICITY POLE
TREES:	HEDGES:
SERVICE METER:	
GATE VALVE:	
STUB-OUT:	
AIR RELIEVE VALVE:	
BAC-T SAMPLING STN:	
PRV / PSV :	
ROADS:	DIRT ROADS:

- GENERAL NOTE:
- CONSTRUCTION CONTRACTOR SHALL FIELD VERIFY ALL EXISTING UNDERGROUND INFRASTRUCTURE TO ENSURE SAFETY OF ITS WORKERS.
 - AVOID ANY DAMAGES TO EXISTING GOVERNMENT UTILITIES.
 - INSTALL 16"ØX16"ØX6: Ø SADDLE FOR FIRE HYDRANT CONNECTION. (OR SIMILAR CONNECTION)
 - INSTALL 2"ØX16"Ø SADDLE OR SIMILAR CONNECTION FOR NEW SERVICE CONNECTION @ EVERY 500 FEET.

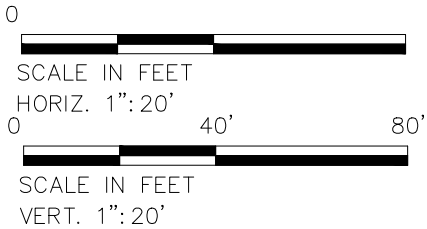

No.	Description	Date	REV. NO.:	PREPARED BY:
				FToala
			REVISION:	CHECKED BY:
				LTyrell
			CHECKED BY:	APPROVED BY:
				FAguila / LTyrell
			APPROVED BY:	ISSUE FOR:
				Construction
			DATE:	



AMERICAN SAMOA POWER AUTHORITY
ENGINEERING SERVICES DIVISION


P.O.BOX PPB, TAFUNA, PAGO PAGO, AS 96799

PROJECT NAME:
AOLOAU 6"Ø WATERLINE REPLACEMENT PROJECT


DRAWING TITLE:
SEGMENT 1
PROFILE & PLAN (STA.55+00 to 60+00)

PROJECT LOCATION:
AOLOAU VILLAGE, AMERICAN SAMOA

SCALE: AS SHOWN	SIGNATURE:
PROJECT NO: 1958785	DATE:
DATE: JULY 2023	SHEET NO. C12

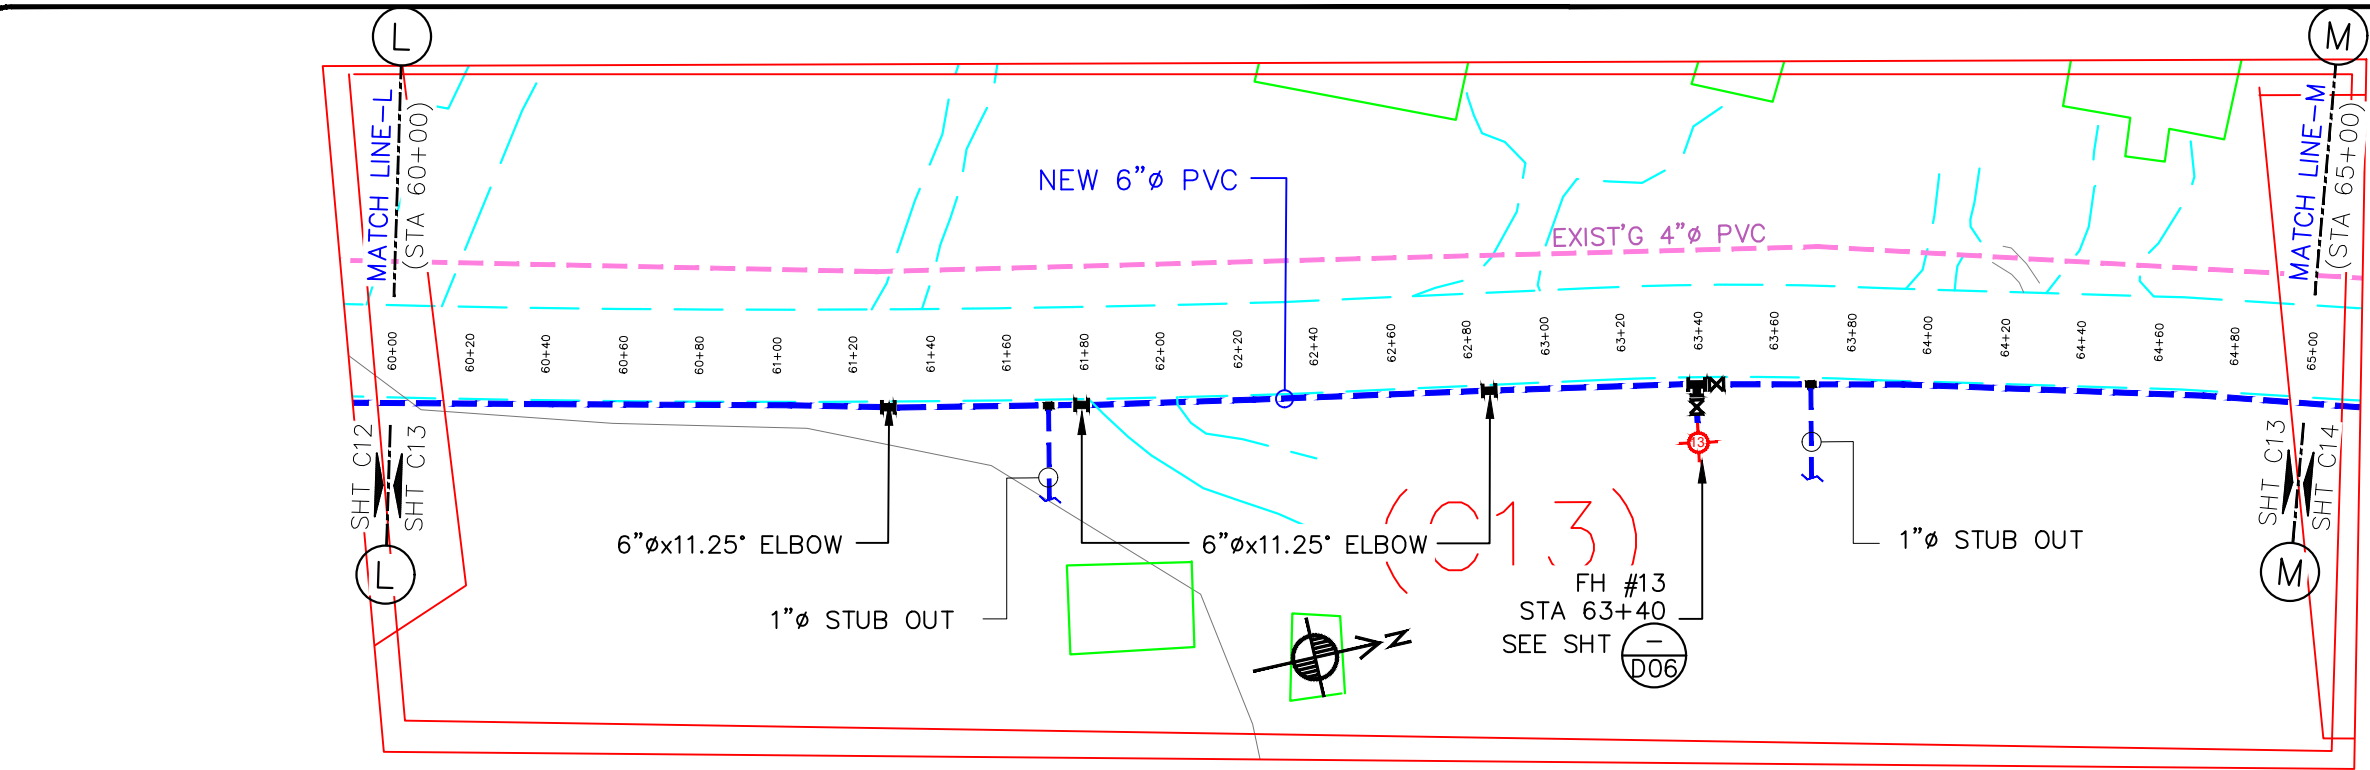

1 LOCATION PLAN
SCALE: AS SHOWN

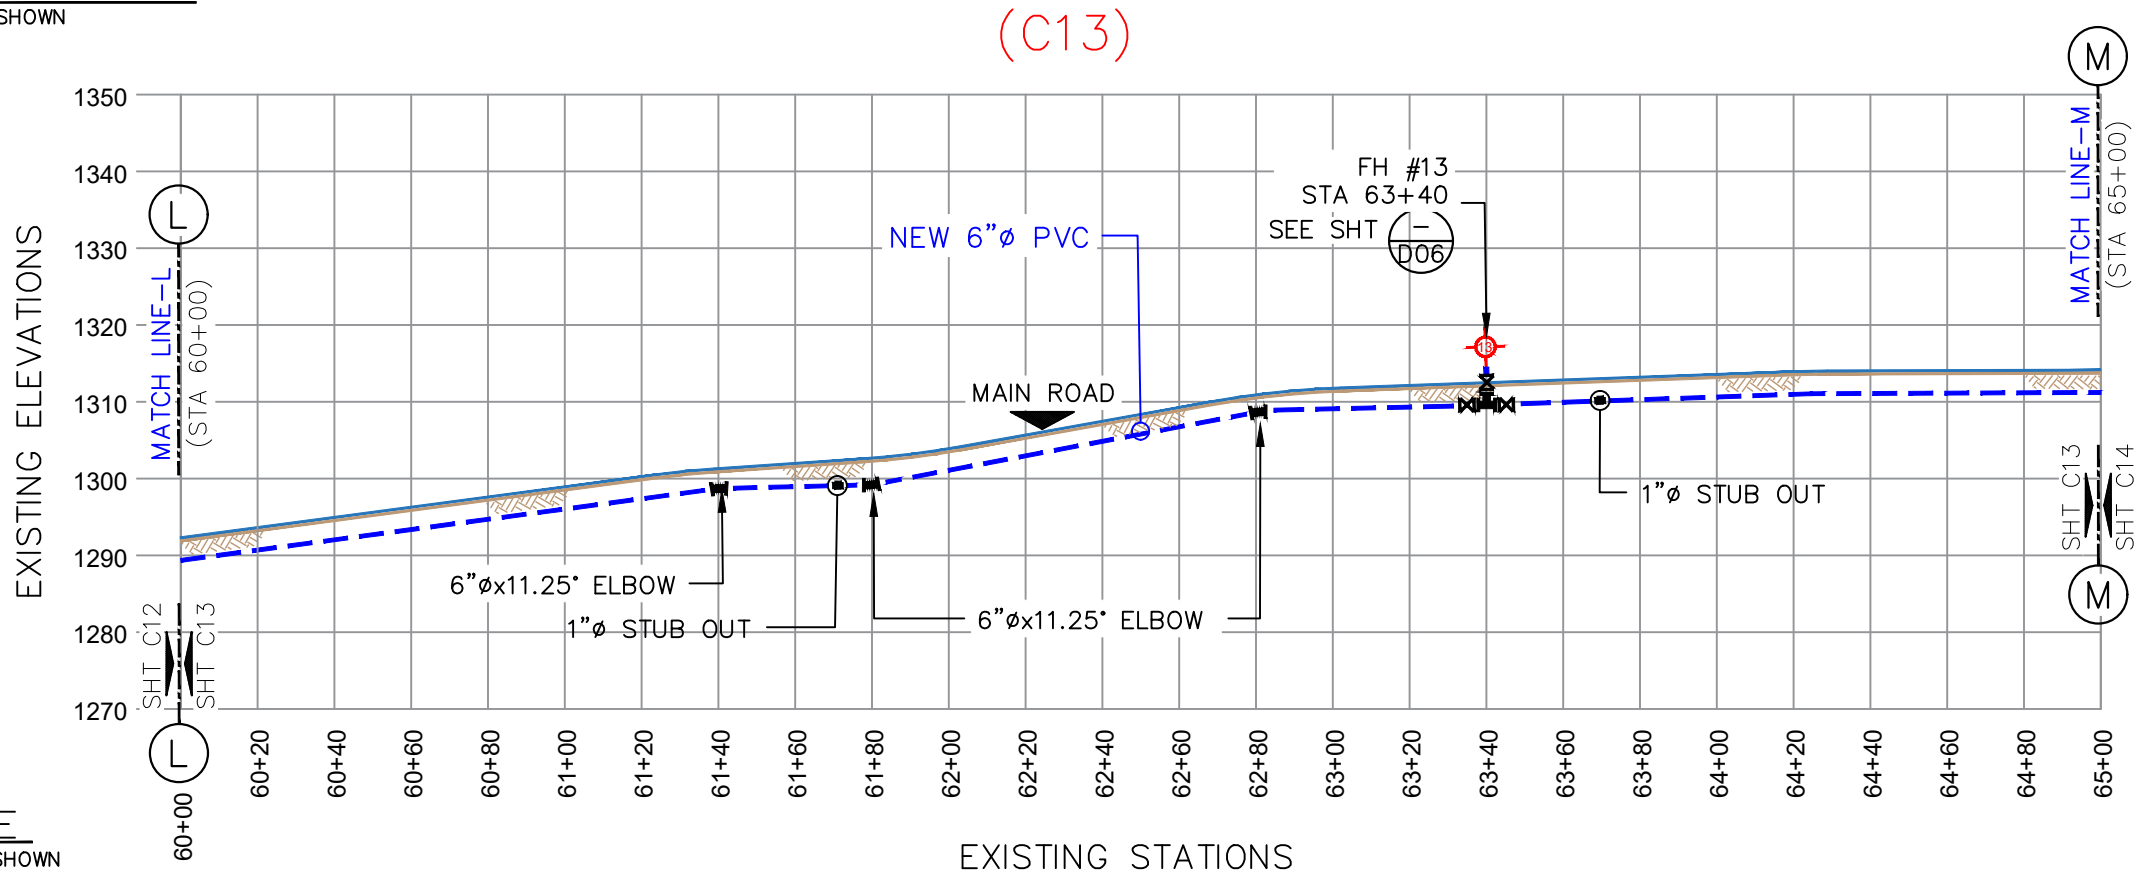


2 PROFILE
SCALE: AS SHOWN

LEGEND:	
EXISTING ACP WATER LINE:	
NEW 16"Ø PVC:	
SEWER SERVICE LINE:	
EXISTING MAIN SEWER LINE:	
EXISTING STORM DRAIN:	
TELEPHONE CONDUIT:	
ELBOWS: 11.25"= 22.5"= 45"=	
FIRE HYDRANT: EXISTING NEW	
POWER/TEL POLE: TELEPHONE POLE ELECTRICITY POLE ALL IN 1 POLE	
TREES: HEDGES:	
SERVICE METER:	
GATE VALVE:	
STUB-OUT:	
AIR RELIEVE VALVE:	
BAC-T SAMPLING STN:	
PRV / PSV :	
ROADS: DIRT ROADS:	


GENERAL NOTE:

- CONSTRUCTION CONTRACTOR SHALL FIELD VERIFY ALL EXISTING UNDERGROUND INFRASTRUCTURE TO ENSURE SAFETY OF ITS WORKERS.
- AVOID ANY DAMAGES TO EXISTING GOVERNMENT UTILITIES.
- INSTALL 16"ØX16"ØX6: Ø SADDLE FOR FIRE HYDRANT CONNECTION. (OR SIMILAR CONNECTION)
- INSTALL 2"ØX16"Ø SADDLE OR SIMILAR CONNECTION FOR NEW SERVICE CONNECTION @ EVERY 500 FEET.

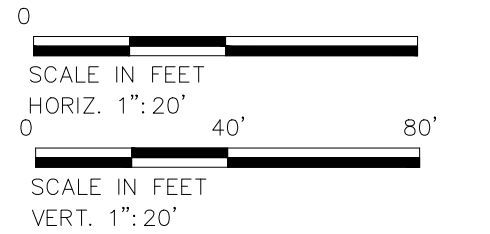


No.	Description	Date	REV. NO.:	PREPARED BY:	PROJECT NAME:	SCALE:	SIGNATURE:
				FToala	AOLOAU 6"Ø WATERLINE REPLACEMENT PROJECT	AS SHOWN	
			REVISION:	CHECKED BY:	DRAWING TITLE:	PROJECT NO:	DATE:
				LTyrell	SEGMENT 1	1958785	
			CHECKED BY:	APPROVED BY:	PROFILE & PLAN (STA.60+00 to 65+00)		SHEET NO.
				FAguija / LTyrell	PROJECT LOCATION:	DATE:	
			APPROVED BY:	ISSUE FOR:	AOLOAU VILLAGE, AMERICAN SAMOA	JULY 2023	C13
			DATE:	Construction			

1 LOCATION PLAN
SCALE: AS SHOWN

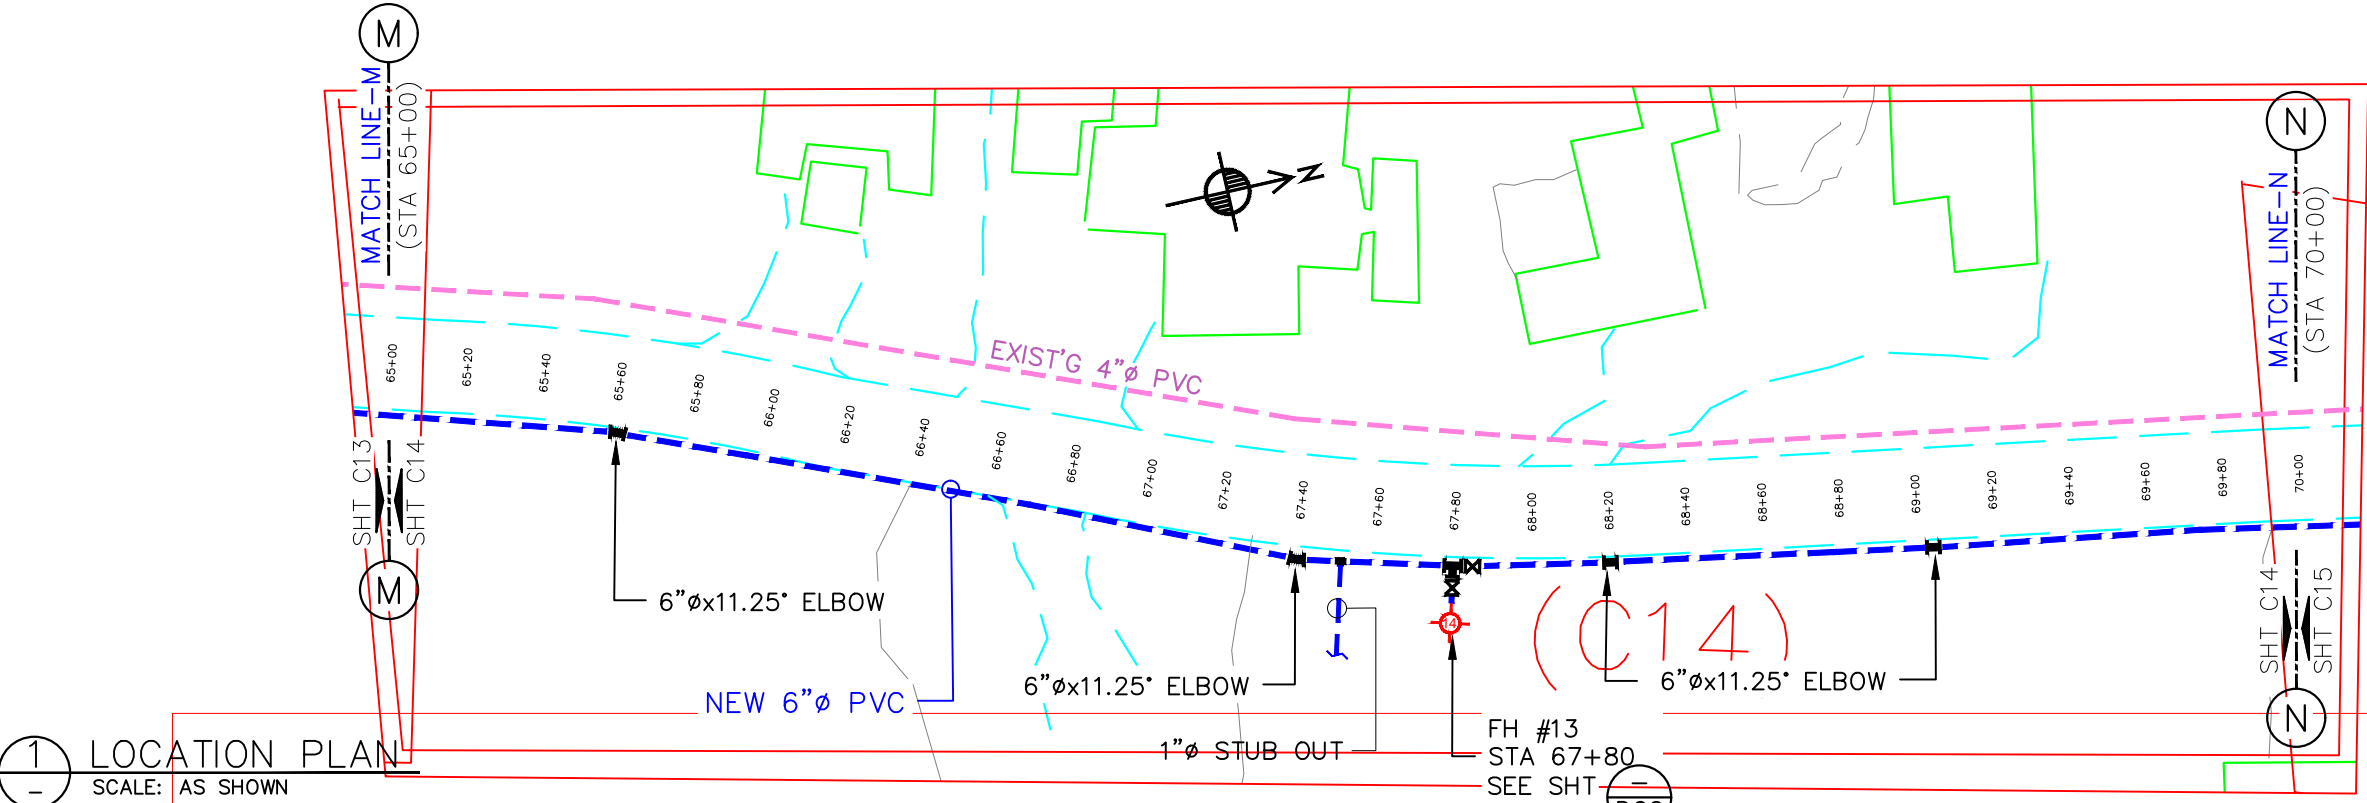


2 PROFILE
SCALE: AS SHOWN

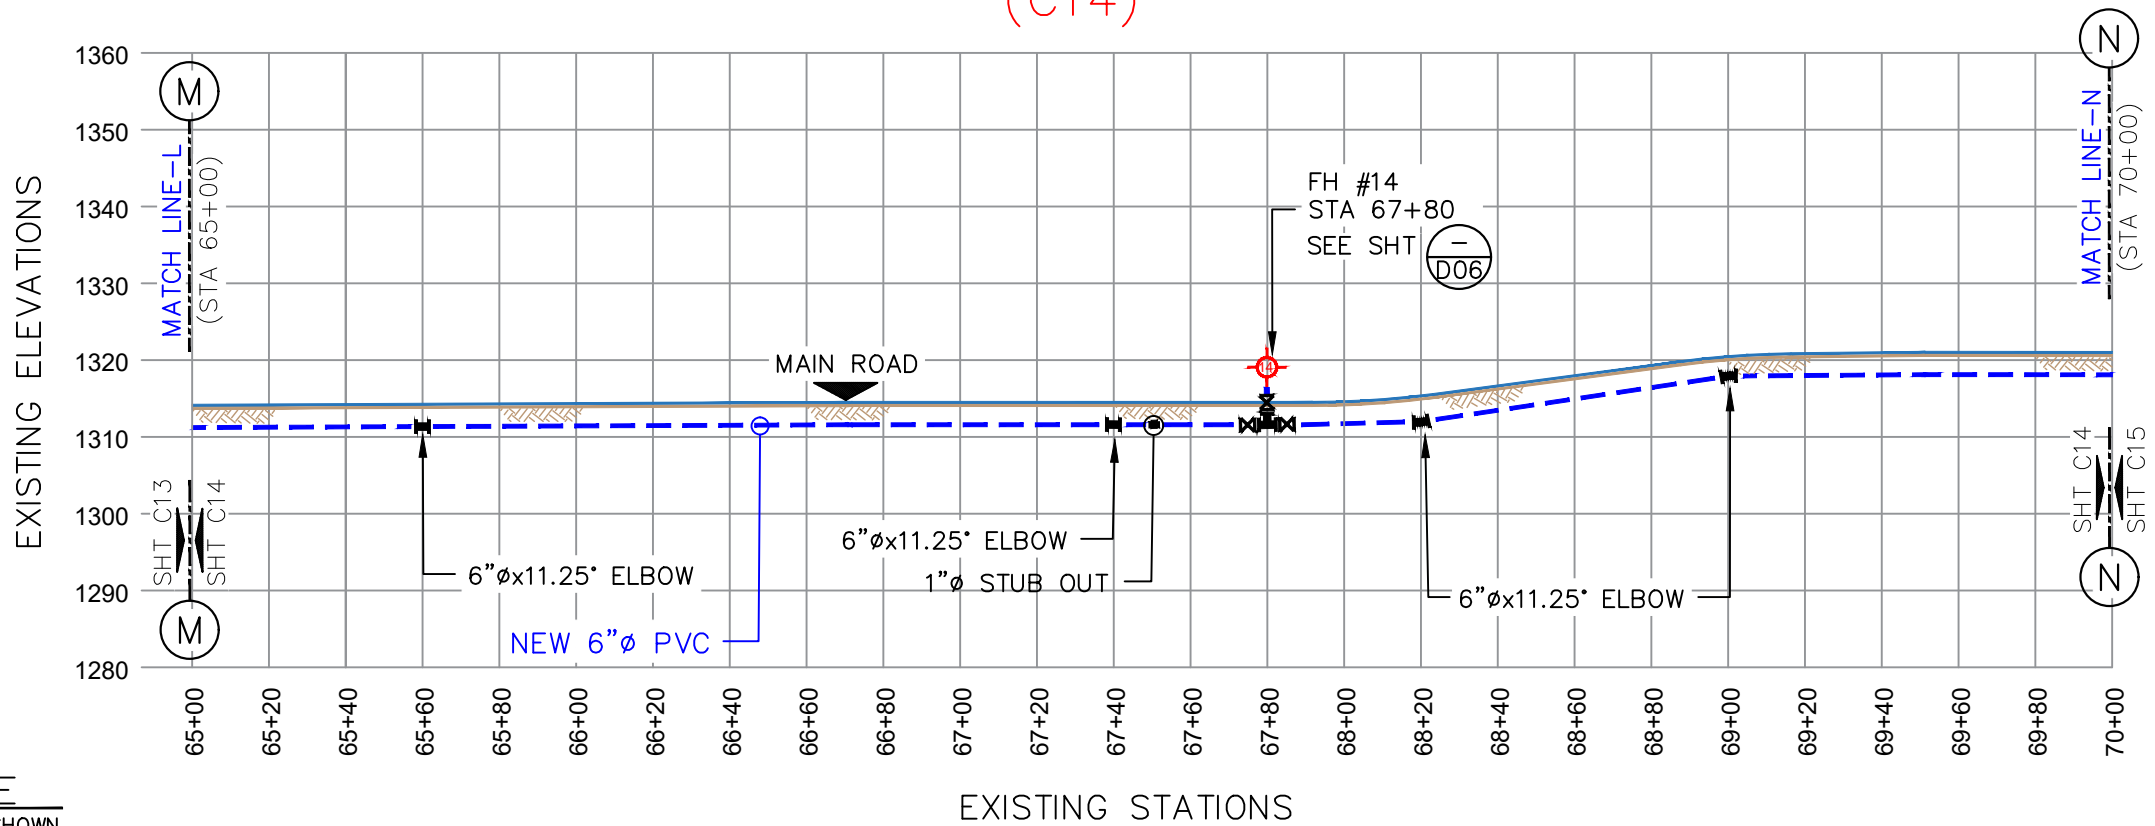

LEGEND:	
EXISTING ACP WATER LINE:	
NEW 16"Ø PVC:	
SEWER SERVICE LINE:	
EXISTING MAIN SEWER LINE:	
EXISTING STORM DRAIN:	
TELEPHONE CONDUIT:	
ELBOWS: 11.25"=	
22.5"=	
45"=	
FIRE HYDRANT: EXISTING	
NEW	
POWER/TEL POLE: TELEPHONE POLE	
ELECTRICITY POLE	
ALL IN 1 POLE	
TREES:	
HEDGES:	
SERVICE METER:	
GATE VALVE:	
STUB-OUT:	
AIR RELIEVE VALVE:	
BAC-T SAMPLING STN:	
PRV / PSV :	
ROADS:	
DIRT ROADS:	

GENERAL NOTE:

- CONSTRUCTION CONTRACTOR SHALL FIELD VERIFY ALL EXISTING UNDERGROUND INFRASTRUCTURE TO ENSURE SAFETY OF ITS WORKERS.
- AVOID ANY DAMAGES TO EXISTING GOVERNMENT UTILITIES.
- INSTALL 16"ØX16"ØX6:Ø SADDLE FOR FIRE HYDRANT CONNECTION. (OR SIMILAR CONNECTION)
- INSTALL 2"ØX16"Ø SADDLE OR SIMILAR CONNECTION FOR NEW SERVICE CONNECTION @ EVERY 500 FEET.

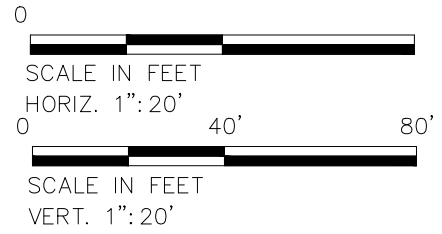

No.	Description	Date

REV. NO.:	PREPARED BY:
	FToala
REVISION:	CHECKED BY:
	FLTyrell
CHECKED BY:	APPROVED BY:
	FAguija / LTyrell
APPROVED BY:	ISSUE FOR:
	Construction
DATE:	




AMERICAN SAMOA POWER AUTHORITY
ENGINEERING SERVICES DIVISION
P.O.BOX PPB, TAFUNA, PAGO PAGO, AS 96799


PROJECT NAME:
AOLOAU 6"Ø WATERLINE REPLACEMENT PROJECT
DRAWING TITLE:
SEGMENT 1 PROFILE & PLAN (STA.65+00 to 70+00)
PROJECT LOCATION:
AOLOAU VILLAGE, AMERICAN SAMOA

SCALE:
AS SHOWN
PROJECT NO:
1958785
DATE:
JULY 2023

SIGNATURE:
DATE:
SHEET NO.
C14

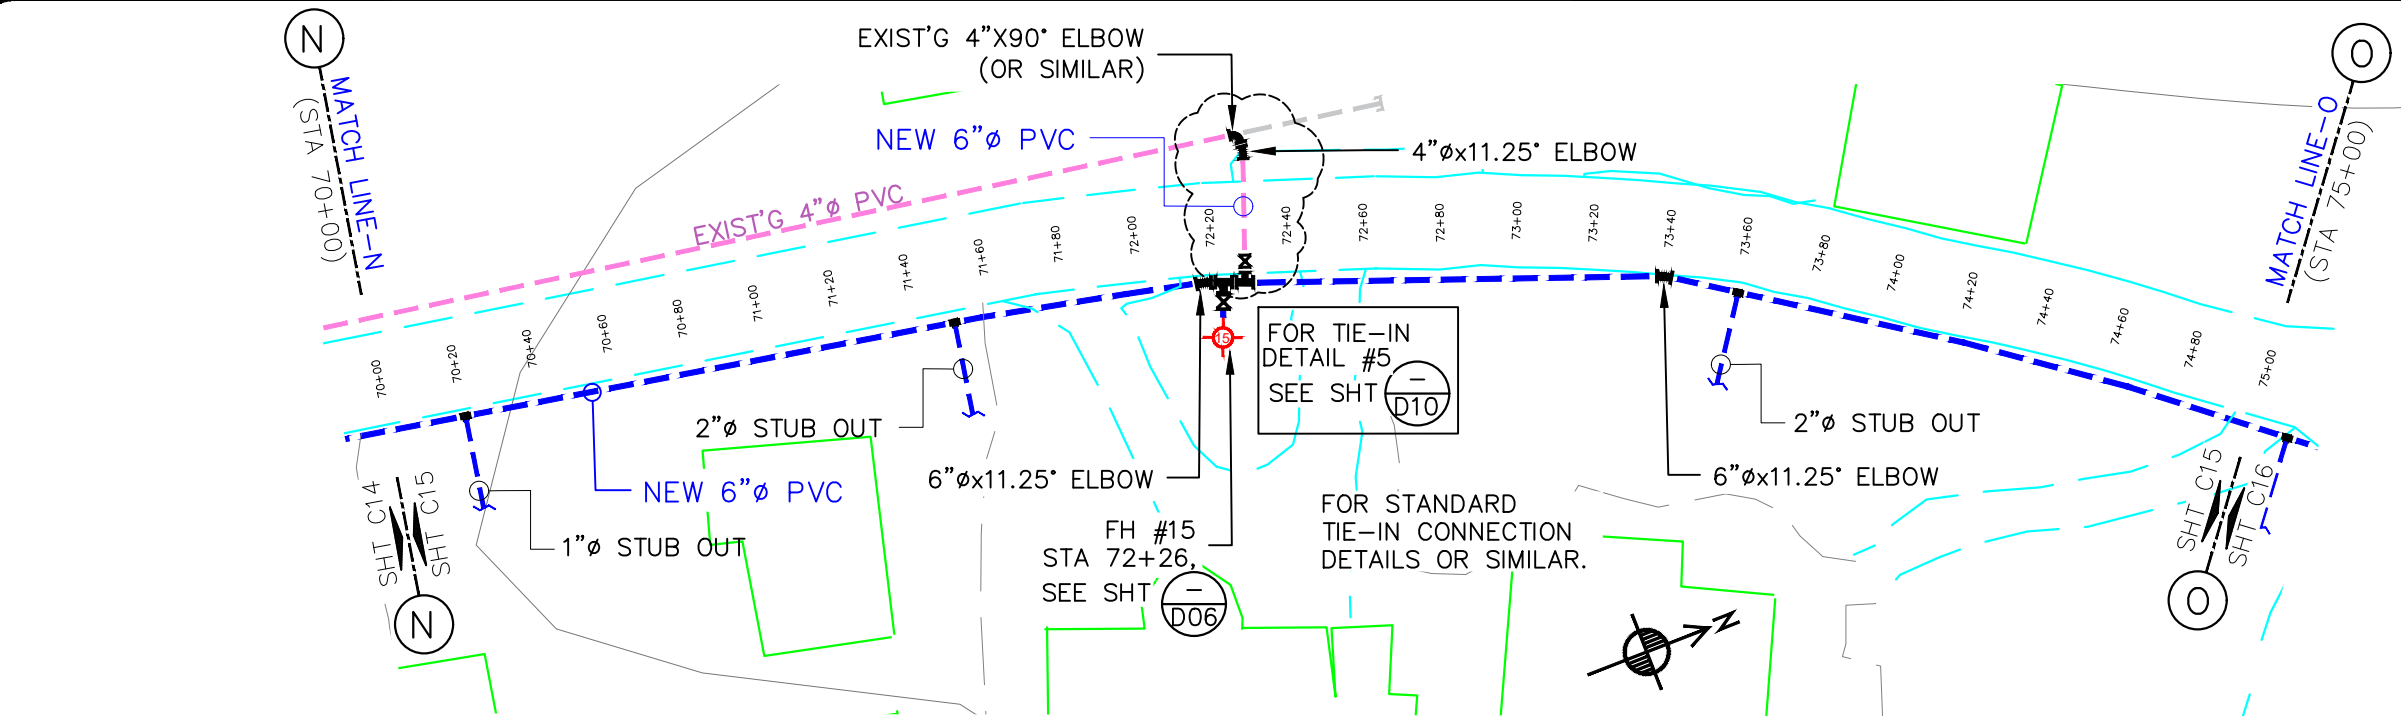


1 LOCATION PLAN
SCALE: AS SHOWN

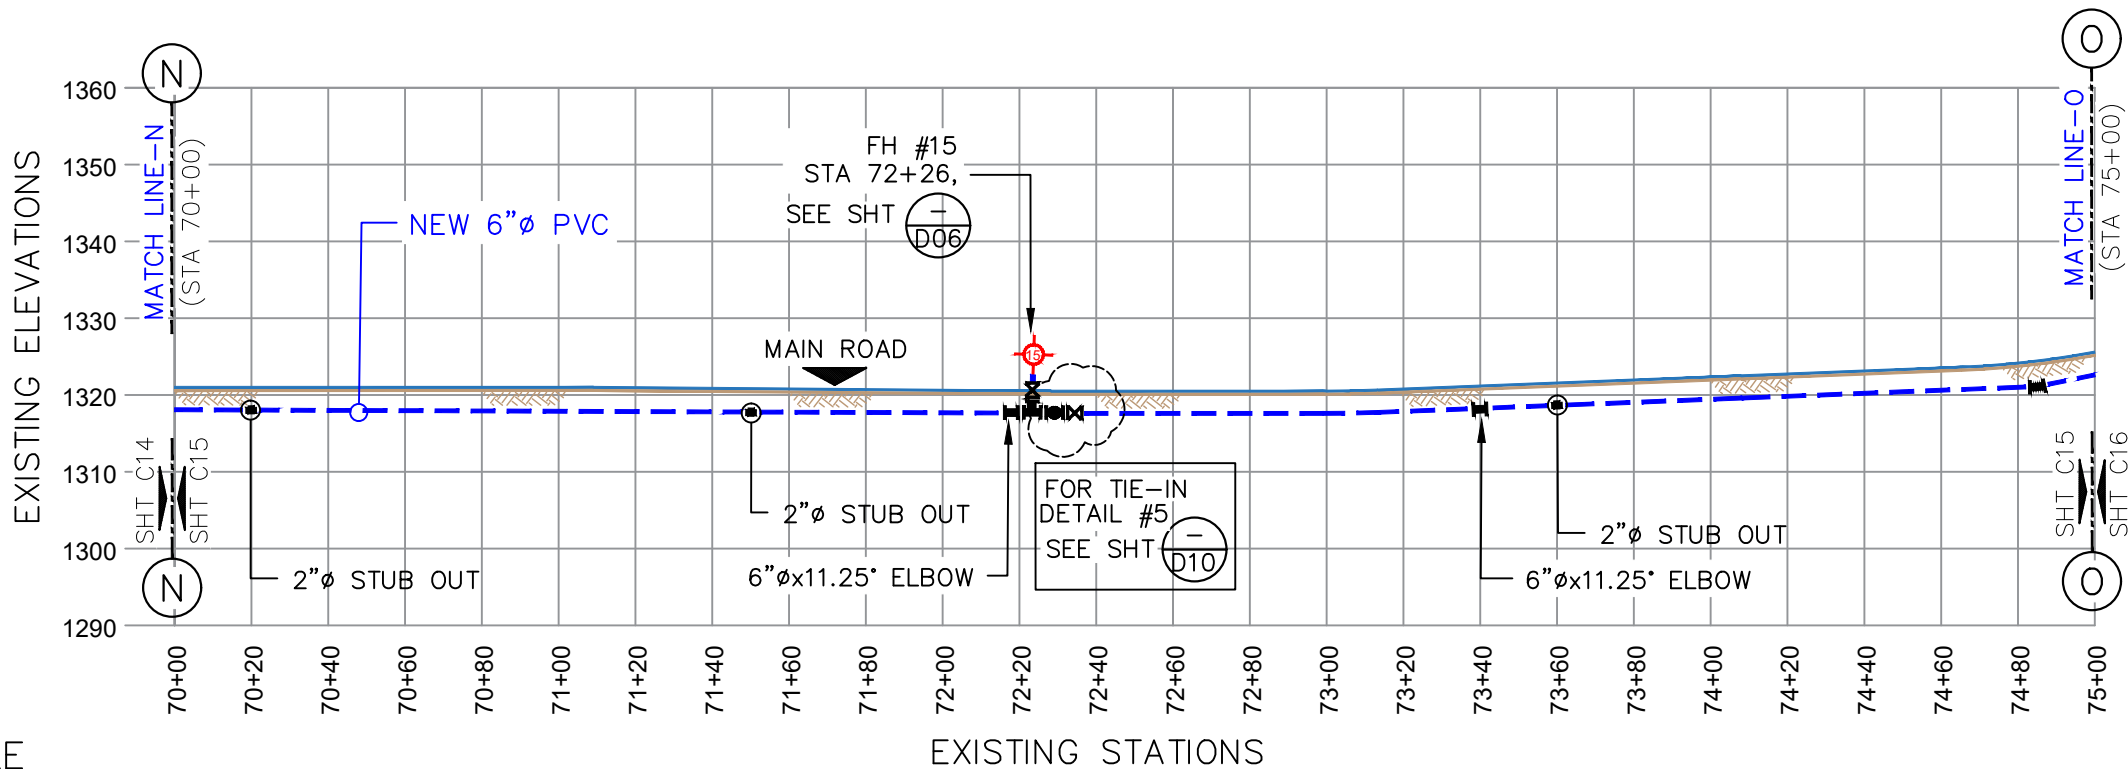

2 PROFILE
SCALE: AS SHOWN

LEGEND:	
EXISTING ACP WATER LINE:	
NEW 16"Ø PVC:	
SEWER SERVICE LINE:	
EXISTING MAIN SEWER LINE:	
EXISTING STORM DRAIN:	
TELEPHONE CONDUIT:	
ELBOWS: 11.25"=	22.5"= 45"=
FIRE HYDRANT: EXISTING	NEW
POWER/TEL POLE:	TELEPHONE POLE ELECTRICITY POLE ALL IN 1 POLE
TREES:	HEDGES:
SERVICE METER:	
GATE VALVE:	
STUB-OUT:	
AIR RELIEVE VALVE:	
BAC-T SAMPLING STN:	
PRV / PSV :	
ROADS:	DIRT ROADS:

- GENERAL NOTE:
- CONSTRUCTION CONTRACTOR SHALL FIELD VERIFY ALL EXISTING UNDERGROUND INFRASTRUCTURE TO ENSURE SAFETY OF ITS WORKERS.
 - AVOID ANY DAMAGES TO EXISTING GOVERNMENT UTILITIES.
 - INSTALL 16"ØX16"ØX6:Ø SADDLE FOR FIRE HYDRANT CONNECTION. (OR SIMILAR CONNECTION)
 - INSTALL 2"Øx16"Ø SADDLE OR SIMILAR CONNECTION FOR NEW SERVICE CONNECTION @ EVERY 500 FEET.

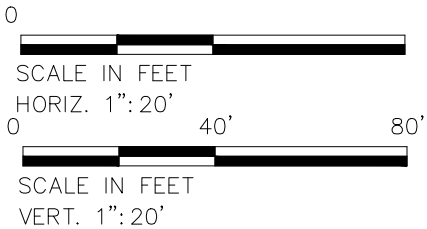

No.	Description	Date

REV. NO.:	PREPARED BY: FToala
REVISION:	CHECKED BY: LTyrell
CHECKED BY:	APPROVED BY: FAguila / LTyrell
APPROVED BY:	ISSUE FOR: Construction
DATE:	



AMERICAN SAMOA POWER AUTHORITY

AMERICAN SAMOA POWER AUTHORITY
ENGINEERING SERVICES DIVISION

P.O.BOX PPB, TAFUNA, PAGO PAGO, AS 96799

PROJECT NAME:
AOLOAU 6"Ø WATERLINE REPLACEMENT PROJECT

DRAWING TITLE:
SEGMENT 1
PROFILE & PLAN (STA.70+00 to 75+00)

PROJECT LOCATION:
AOLOAU VILLAGE, AMERICAN SAMOA

SCALE:
AS SHOWN

PROJECT NO:
1958785


DATE:
JULY 2023

SIGNATURE:
DATE:


SHEET NO.

C15

1 LOCATION PLAN
SCALE: AS SHOWN

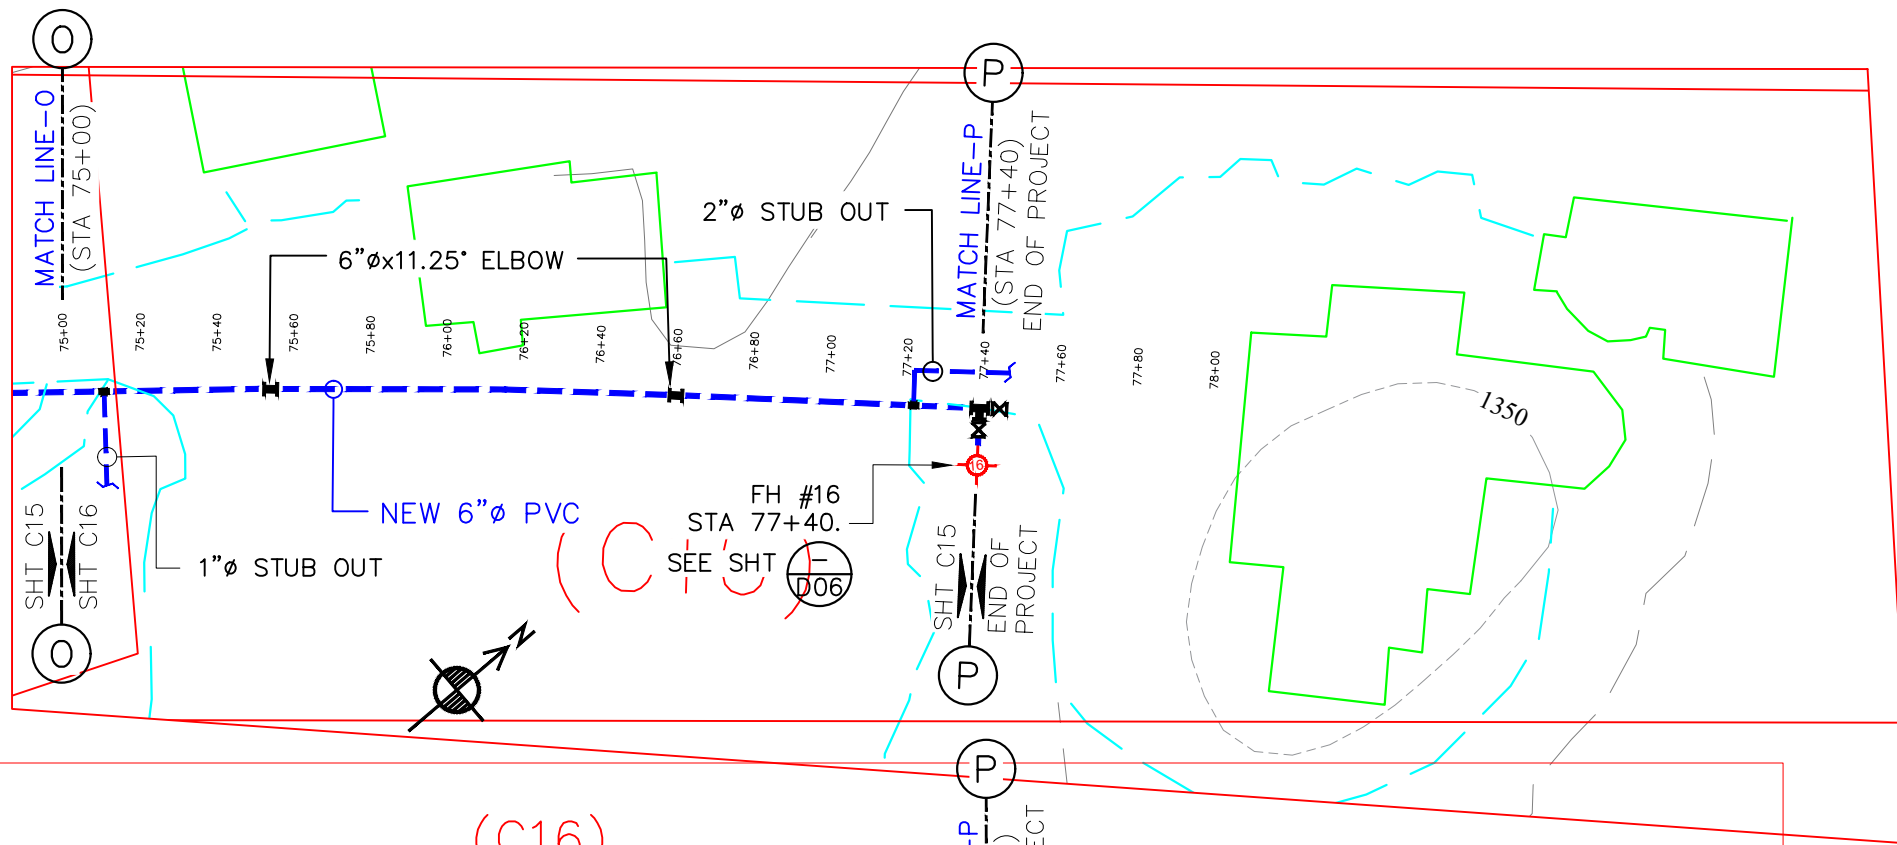


2 PROFILE
SCALE: AS SHOWN

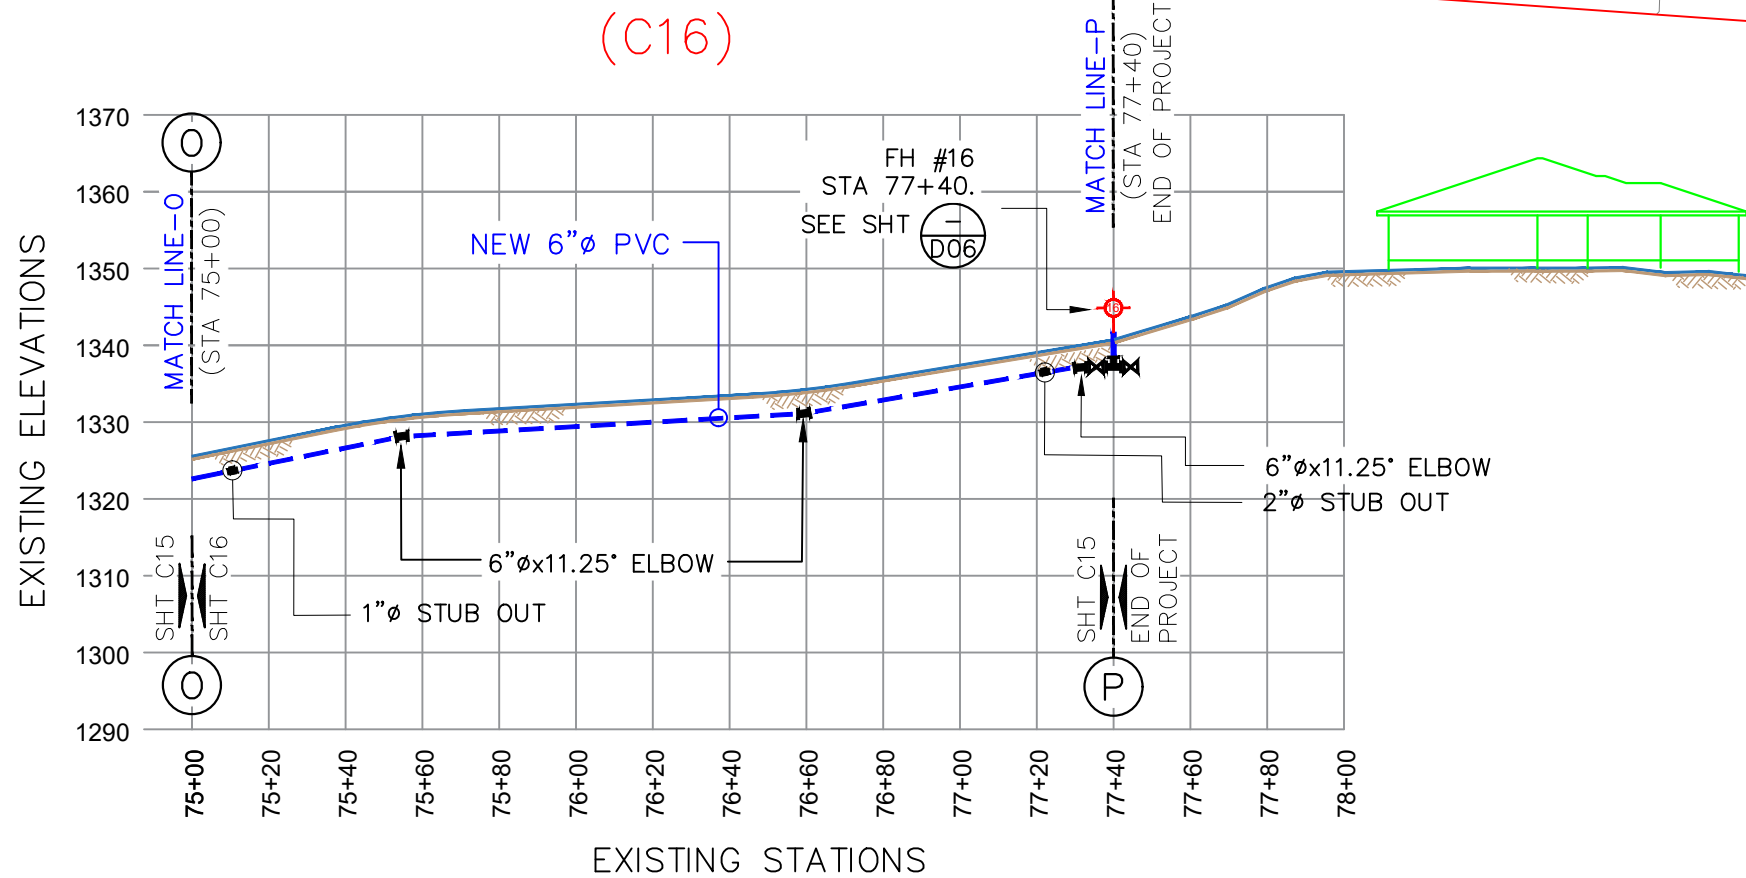

LEGEND:	
EXISTING ACP WATER LINE:	
NEW 16"Ø PVC:	
SEWER SERVICE LINE:	
EXISTING MAIN SEWER LINE:	
EXISTING STORM DRAIN:	
TELEPHONE CONDUIT:	
ELBOWS: 11.25"= 22.5"= 45"=	
FIRE HYDRANT: EXISTING NEW	
POWER/TEL POLE: TELEPHONE POLE ELECTRICITY POLE ALL IN 1 POLE	
TREES: HEDGES:	
SERVICE METER:	
GATE VALVE:	
STUB-OUT:	
AIR RELIEVE VALVE:	
BAC-T SAMPLING STN:	
PRV / PSV :	
ROADS: DIRT ROADS:	

- GENERAL NOTE:
- CONSTRUCTION CONTRACTOR SHALL FIELD VERIFY ALL EXISTING UNDERGROUND INFRASTRUCTURE TO ENSURE SAFETY OF ITS WORKERS.
 - AVOID ANY DAMAGES TO EXISTING GOVERNMENT UTILITIES.
 - INSTALL 16"ØX16"ØX6:Ø SADDLE FOR FIRE HYDRANT CONNECTION. (OR SIMILAR CONNECTION)
 - INSTALL 2"ØX16"Ø SADDLE OR SIMILAR CONNECTION FOR NEW SERVICE CONNECTION @ EVERY 500 FEET.

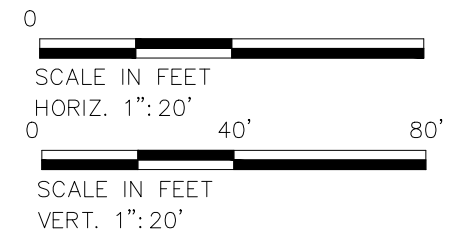

No.	Description	Date

REV. NO.:	PREPARED BY: FToala
REVISION:	CHECKED BY: LTyrell
CHECKED BY:	APPROVED BY: FAguila / LTyrell
APPROVED BY:	ISSUE FOR: Construction
DATE:	



AMERICAN SAMOA POWER AUTHORITY


AMERICAN SAMOA POWER AUTHORITY
ENGINEERING SERVICES DIVISION

P.O.BOX PPB, TAFUNA, PAGO PAGO, AS 96799


PROJECT NAME: AOLOAU 6"Ø WATERLINE REPLACEMENT PROJECT
DRAWING TITLE: END OF SEGMENT 1 PROFILE & PLAN (STA.75+00 to 78+00)
PROJECT LOCATION: AOLOAU VILLAGE, AMERICAN SAMOA

SCALE: AS SHOWN	SIGNATURE: DATE:
PROJECT NO: 1958785	SHEET NO. C16
DATE: JULY 2023	

1 LOCATION PLAN
SCALE: AS SHOWN

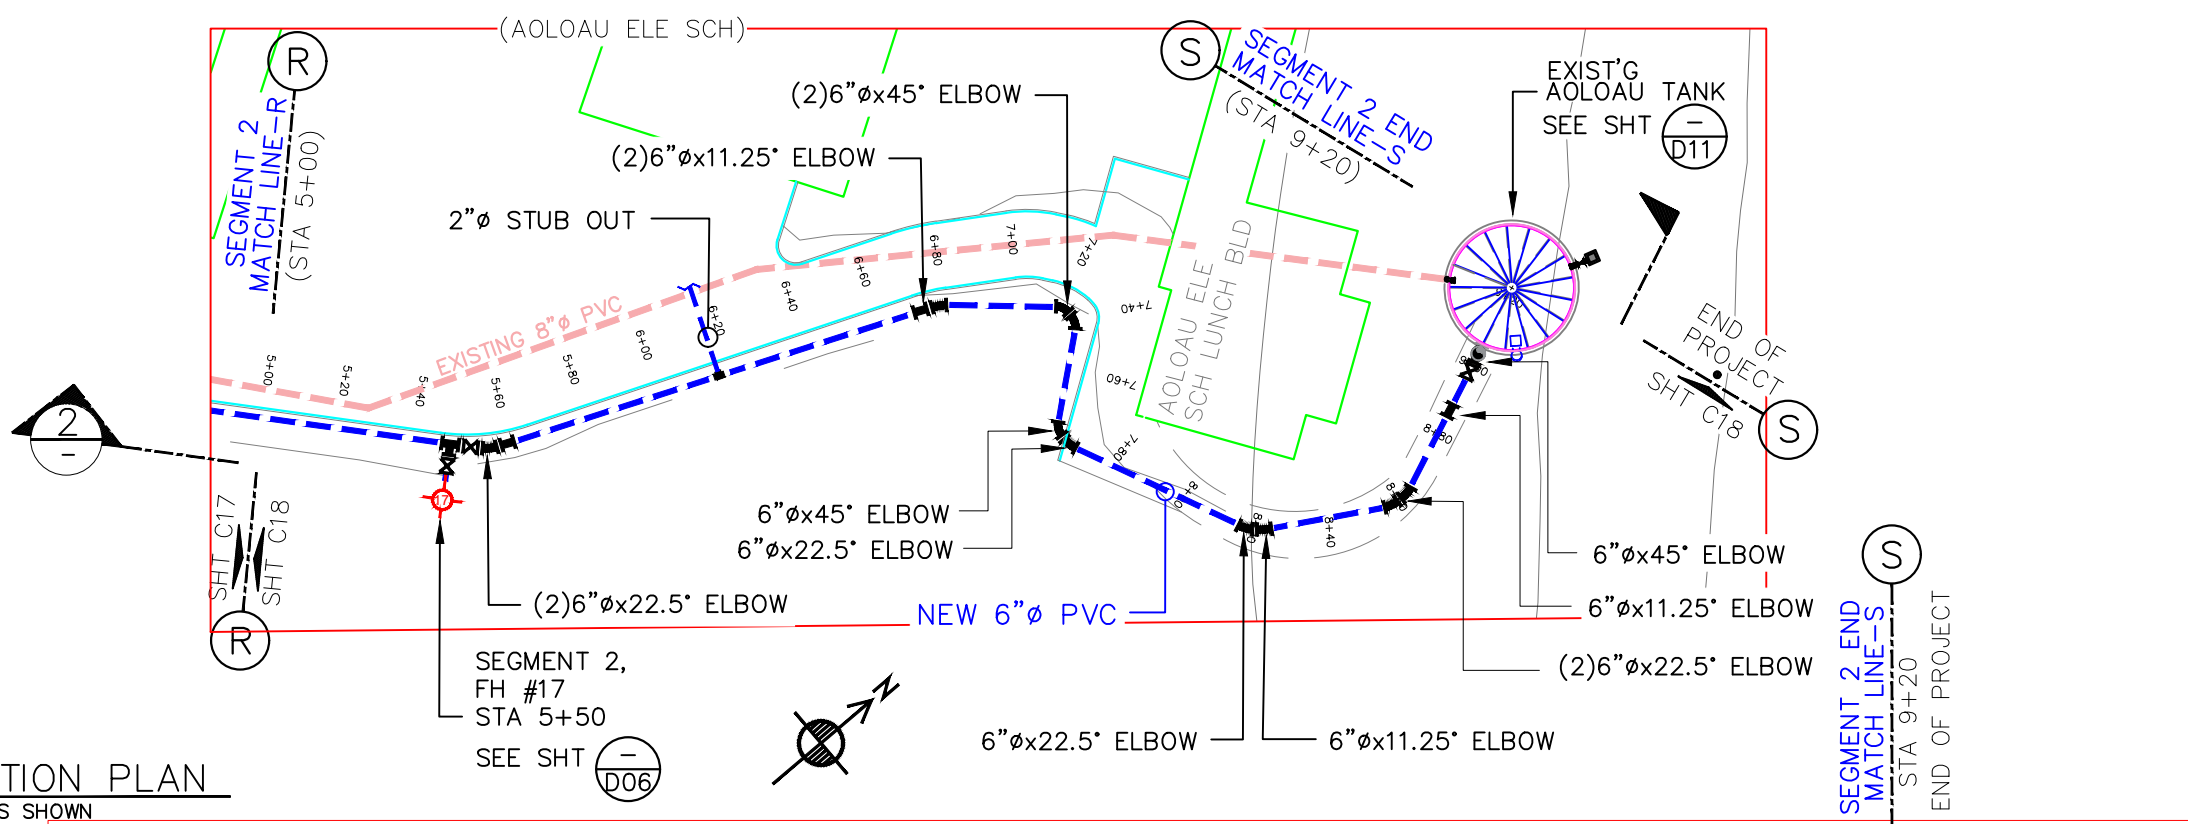


2 PROFILE
SCALE: AS SHOWN

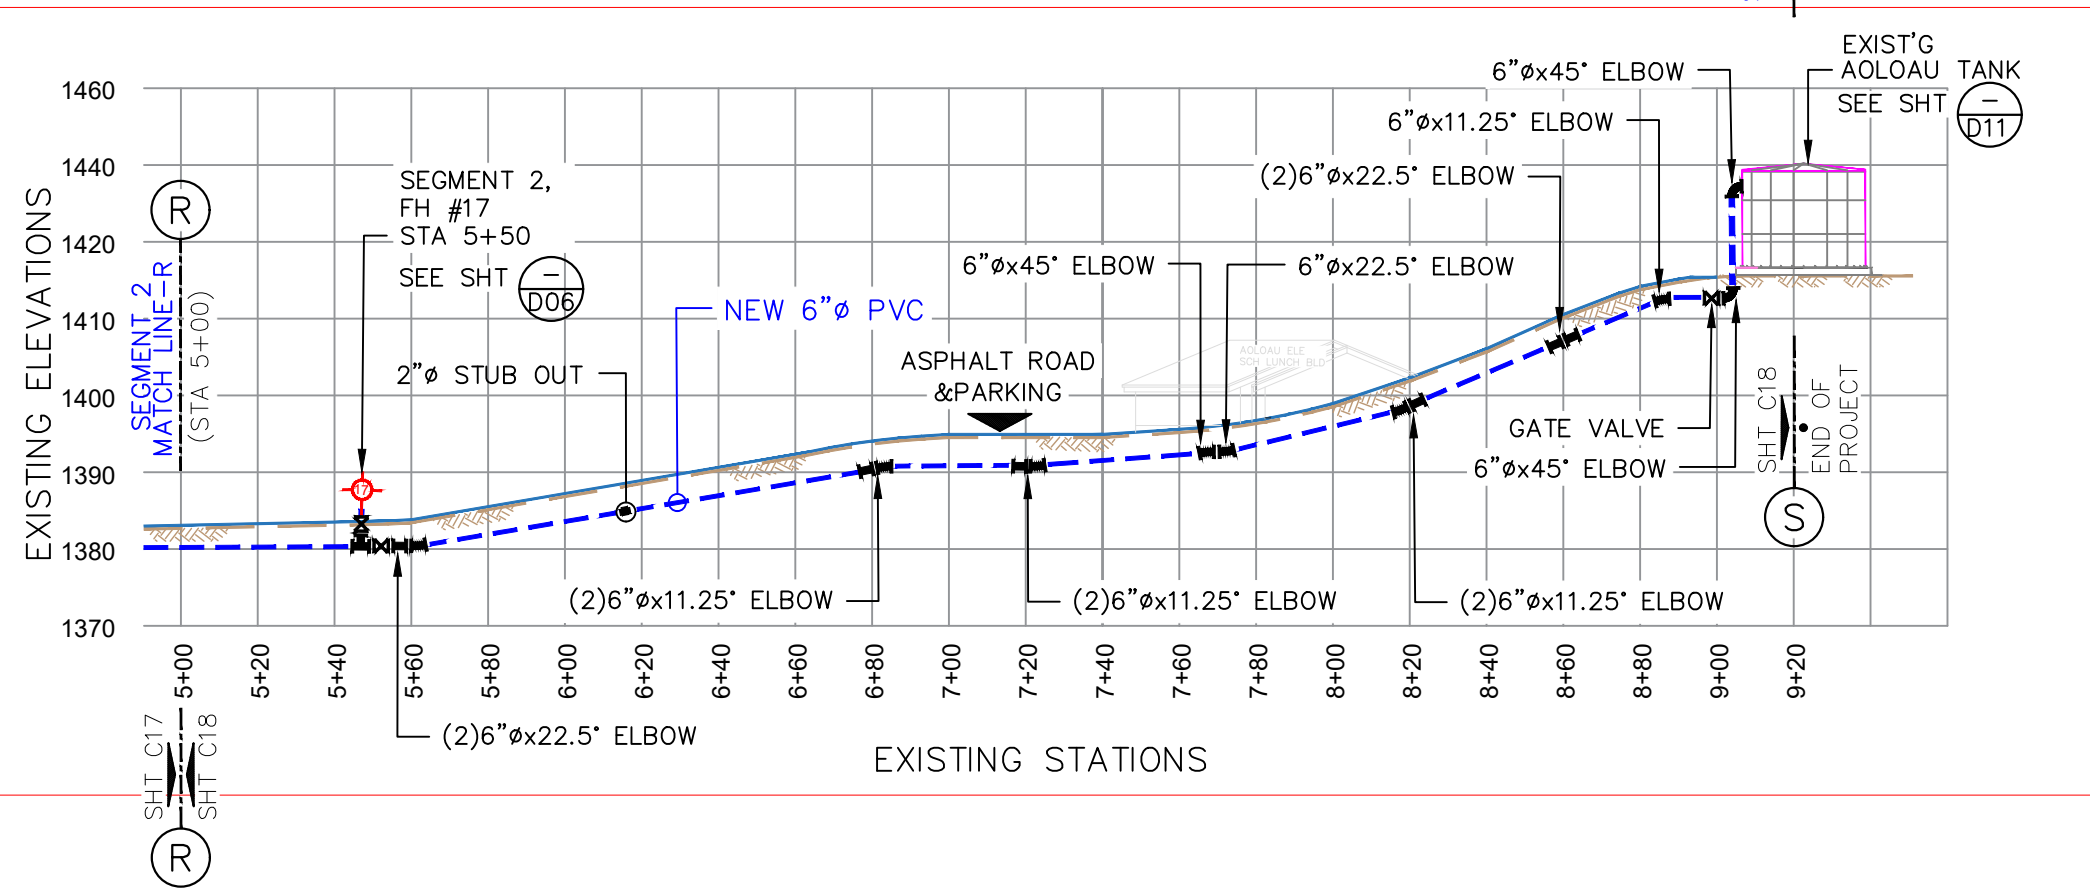

LEGEND:	
EXISTING ACP WATER LINE:	
NEW 16"Ø PVC:	
SEWER SERVICE LINE:	
EXISTING MAIN SEWER LINE:	
EXISTING STORM DRAIN:	
TELEPHONE CONDUIT:	
ELBOWS: 11.25"=	
22.5"=	
45"=	
FIRE HYDRANT: EXISTING	
NEW	
POWER/TEL POLE: TELEPHONE POLE	
ELECTRICITY POLE	
ALL IN 1 POLE	
TREES:	
HEDGES:	
SERVICE METER:	
GATE VALVE:	
STUB-OUT:	
AIR RELIEVE VALVE:	
BAC-T SAMPLING STN:	
PRV / PSV :	
ROADS:	
DIRT ROADS:	

GENERAL NOTE:

- CONSTRUCTION CONTRACTOR SHALL FIELD VERIFY ALL EXISTING UNDERGROUND INFRASTRUCTURE TO ENSURE SAFETY OF ITS WORKERS.
- AVOID ANY DAMAGES TO EXISTING GOVERNMENT UTILITIES.
- INSTALL 16"ØX16"ØX6:Ø SADDLE FOR FIRE HYDRANT CONNECTION. (OR SIMILAR CONNECTION)
- INSTALL 2"ØX16"Ø SADDLE OR SIMILAR CONNECTION FOR NEW SERVICE CONNECTION @ EVERY 500 FEET.

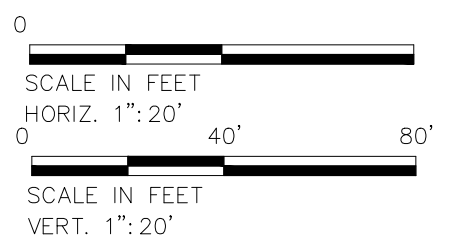

No.	Description	Date


REV. NO.:	PREPARED BY:
	FToala
REVISION:	CHECKED BY:
	LTyrell
CHECKED BY:	APPROVED BY:
	FAguija / LTyrell
APPROVED BY:	ISSUE FOR:
	Construction
DATE:	



AMERICAN SAMOA POWER AUTHORITY
ENGINEERING SERVICES DIVISION
P.O.BOX PPB, TAFUNA, PAGO PAGO, AS 96799

PROJECT NAME:
AOLOAU 6"Ø WATERLINE REPLACEMENT PROJECT
DRAWING TITLE:
SEGMENT 2 END PROFILE & PLAN (STA.5+00 to 9+20)
PROJECT LOCATION:
AOLOAU VILLAGE, AMERICAN SAMOA

SCALE:	SIGNATURE:
AS SHOWN	
PROJECT NO:	DATE:
1958785	
DATE:	SHEET NO.
JULY 2023	C18

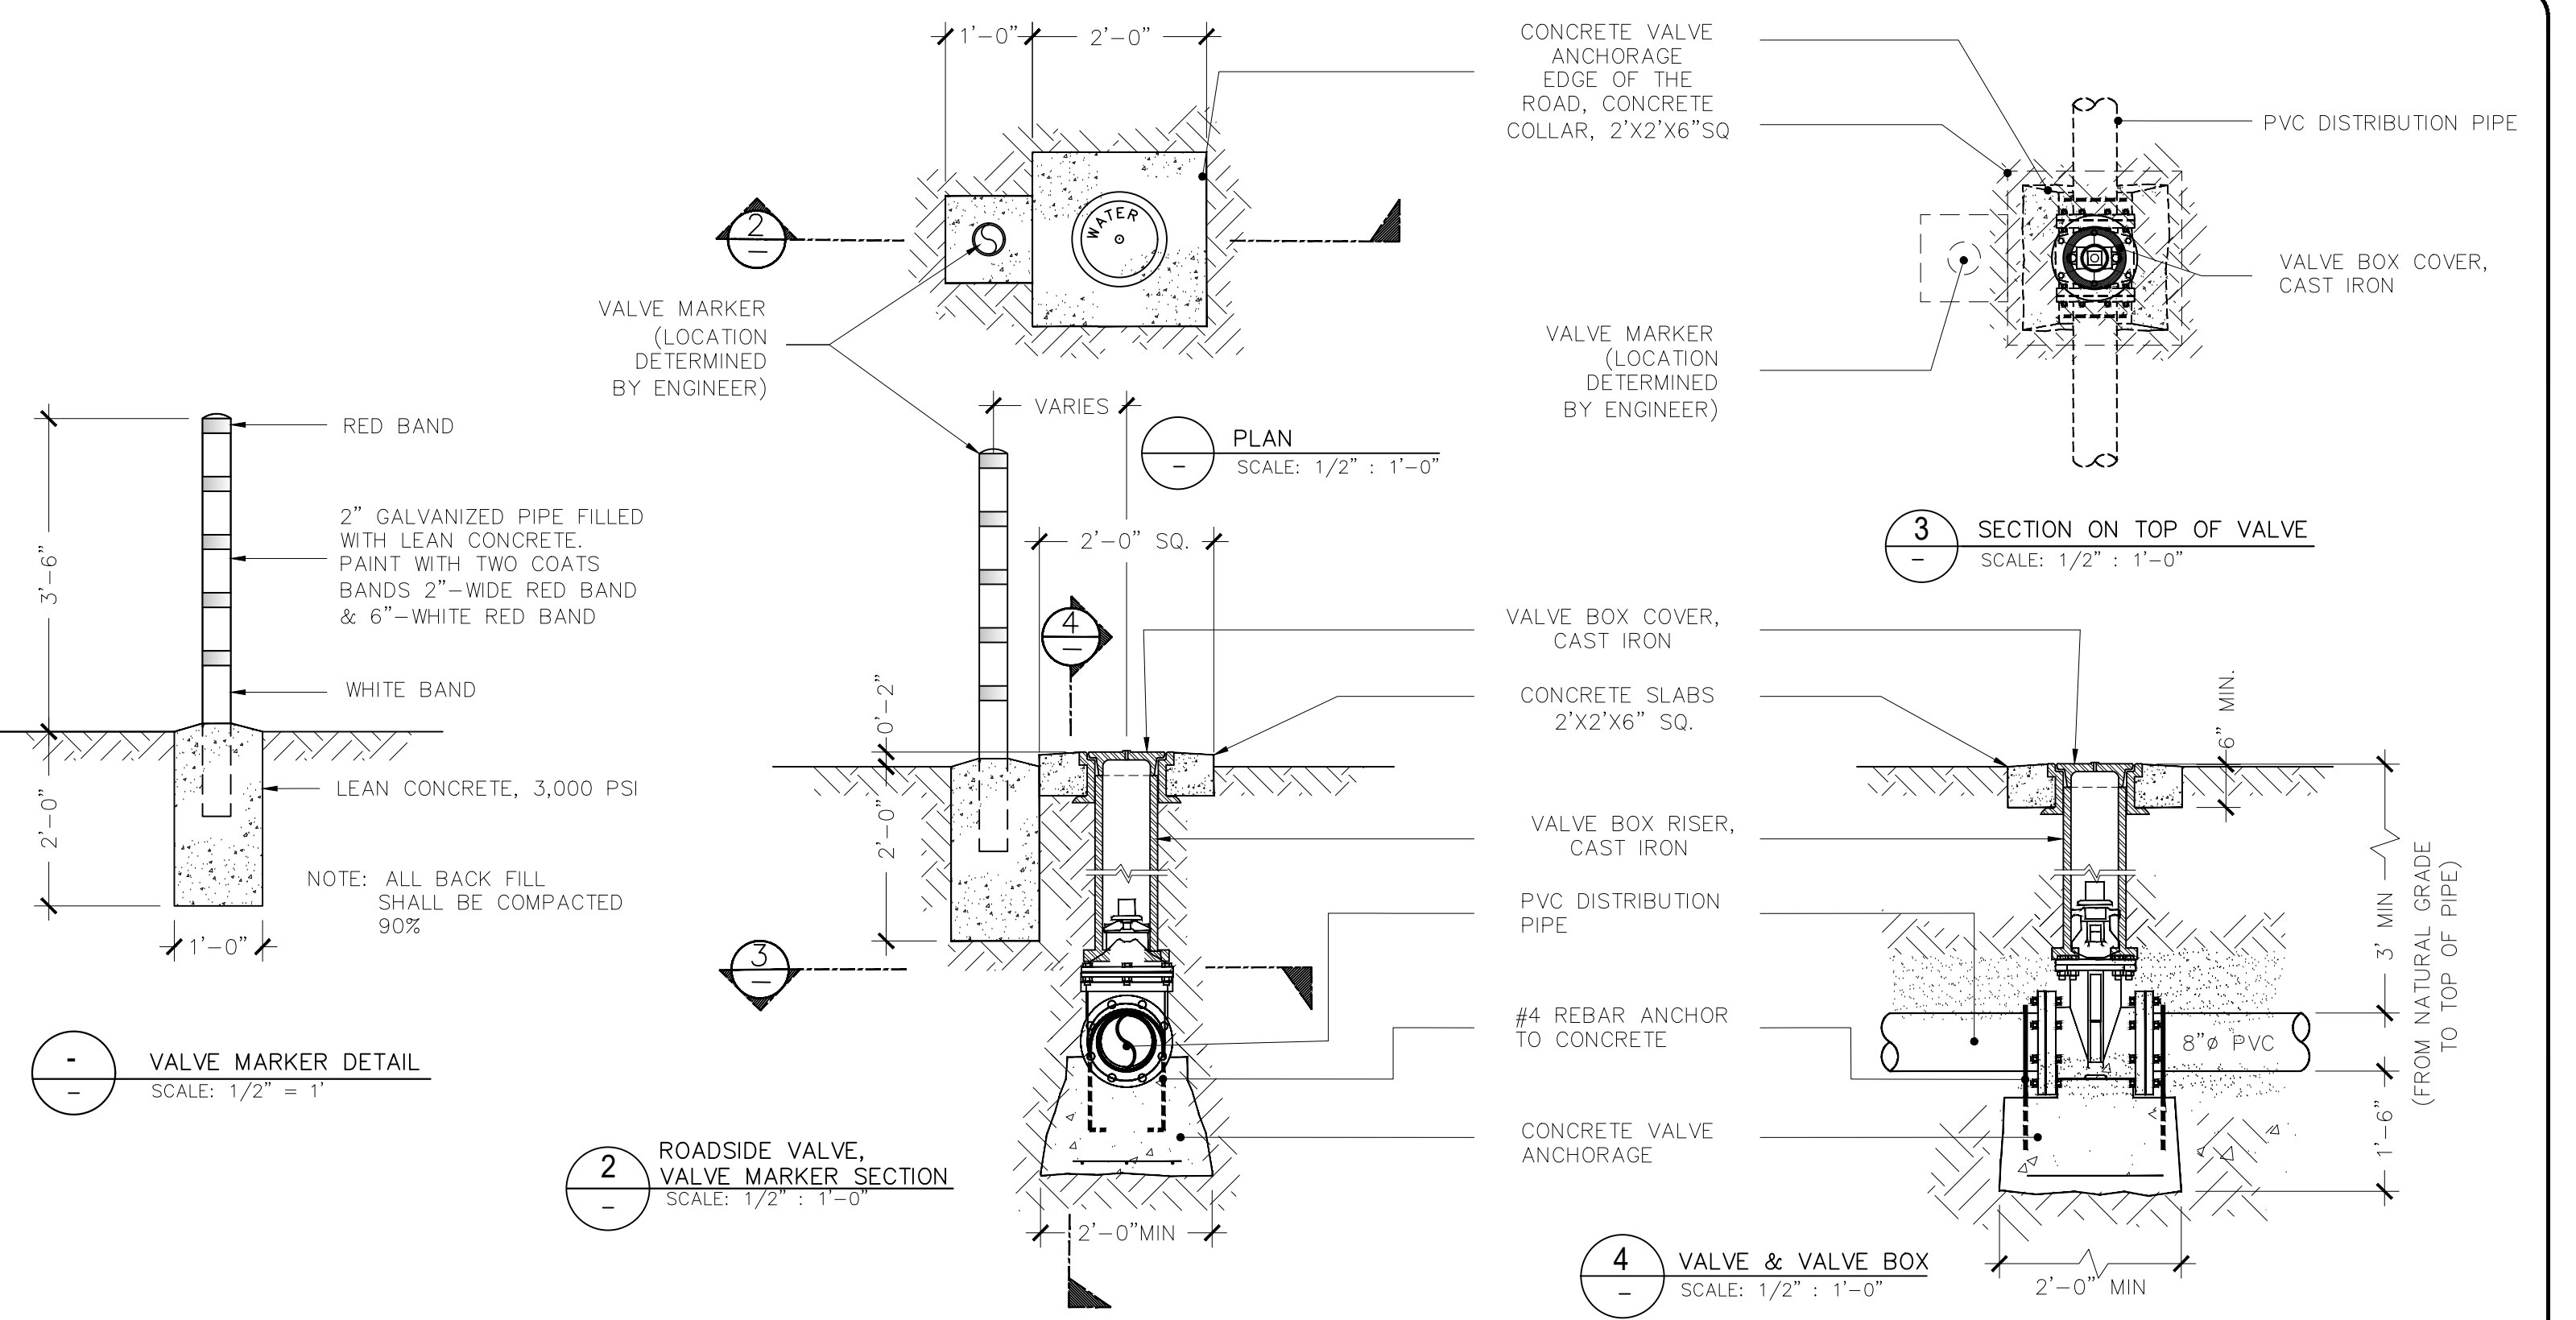

No.	Description	Date

REV. NO.:
REVISION:
CHECKED BY:
APPROVED BY:
DATE:

DESIGNED BY: FToala
CHECKED BY: LTyrell
APPROVED BY: FAguila / LTyrell
ISSUE FOR: Construction



AMERICAN SAMOA POWER AUTHORITY
ENGINEERING SERVICES DIVISION
P.O.BOX PPB, TAFUNA, PAGO PAGO, AS 96799

PROJECT NAME: AOLOAU 6"Ø WATERLINE REPLACEMENT PROJECT
DRAWING TITLE: GATE VALVE, GATE VALVE BOX DETAILS.
PROJECT LOCATION: AOLOAU VILLAGE, AMERICAN SAMOA

SCALE: AS SHOWN
PROJECT NO: 1958785
DATE: APRIL 2023

SIGNATURE:
DATE:
SHEET NO. D01

VENT-GUARD FLITOP FIBERGLASS
AIR VALVE ENCLOSURE MODEL
LV018018024 BY "HOTBOX" OR
ASPA APPROVED EQUAL

1"Ø AIR RELIEF/AIR VACUUM
VALVE, PLAST-O-MATIC
MODEL ARV100EPT-PV "OR"
ASPA APPROVED EQUAL.

1"Ø COPPER PIPE SHORT
PIECE, MIPxPE.

1"Ø BALL VALVE CURB STOPS W/
BRASS COUPLING BOTH SIDES
(B22-444) "OR" ASPA
APPROVED EQUAL

3' MIN
SEE TRENCH DETAIL

4" THICK CONCRETE
PAD W/ #665 WWF

1"Ø COPPER PIPE

1"Ø BRASS PACK JOINT
COUPLING (C24-44) "OR"
ASPA APPROVED EQUAL

6"X 1"Ø SERVICE SADDLE,
(ROMAC 202S -7.5-1" IP)
"OR" ASPA APPROVED EQUAL

6" MIN.

1'-2" MIN.

FINISHED GRADE OR
EXISTING GROUND

(2) 45° ELBOW

1"Ø PVC PIPE

1"Ø CORP. STOP
W/ PACK JOINT
FOR PE PIPE


PVC MAIN

NATURAL GRADE

3'-0" MIN
(OR AS DETERMINED
BY ENGINEER)

0'-6" MIN

ARV VALVE SECTION DETAILS
SCALE: 3/4" = 1'

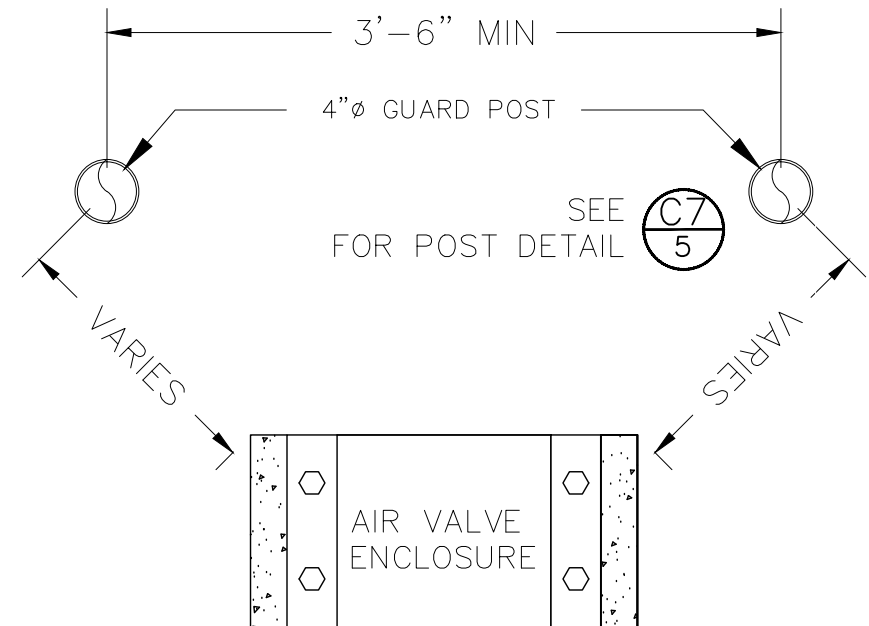

2 PLAN VIEW SHOWING
ARV GUARD POST LOCATION
NOT TO SCALE

NOTE:
GUARD POST LOCATION
DETERMINED BY ENGINEER

No.	Description	Date

REV. NO.:
REVISION:
CHECKED BY:
APPROVED BY:
DATE:

DESIGNED BY: FToala
CHECKED BY: LTyrell
APPROVED BY: FAguila / LTyrell
ISSUE FOR: Construction



AMERICAN SAMOA POWER AUTHORITY

AMERICAN SAMOA POWER AUTHORITY
ENGINEERING SERVICES DIVISION

P.O.BOX PPB, TAFUNA, PAGO PAGO, AS 96799

PROJECT NAME: AOLOAU 6"Ø WATERLINE REPLACEMENT PROJECT
DRAWING TITLE: AIR RELIEF VALVE & DETAILS
PROJECT LOCATION: AOLOAU VILLAGE, AMERICAN SAMOA

SCALE: AS SHOWN
PROJECT NO: 1958785
DATE: APRIL 2023

SIGNATURE:
DATE:
SHEET NO. D02




GENERAL NOTES:

- 1. TABLE IS BASED ON 2000#/SQ. FT. SOIL. IF CONDITIONS ARE FOUND TO INDICATE SOIL BEARING IS LESS, THE AREAS SHALL BE INCREASED ACCORDINGLY.
- 2. AREAS FOR PIPE LARGER THAN 18" SHALL BE CALCULATED.
- 3. CONCRETE SHALL HAVE A MINIMUM COMPRESSION STRENGTH OF 2500 PSI.
- 4. THRUST BLOCK IS TO EXTEND TO UNDISTURBED SOIL.
- 5. SIZE MAY BE DECREASED FOR LESSER DEGREE BENDS AS DETERMINED BY ENGINEER.
- 6. KEEP CONCRETE CLEAR OF M.J. OR BELL AND SPIGOT JOINTS.
- 7. BLOCK IN A SIMILAR MANNER AT TEES, HYDRANTS, PLUG OR OTHER LOCATIONS AS REQUIRED.
- 8. WHEN NECESSARY ADDITIONAL THRUST RESTRAINT METHODS MAY BE USED, SUCH AS MECHANICAL JOINT RESTRAINTS, TIE-RODS (INSTALLED PER MANUFACTURERS' RECOMMENDATIONS) OR OTHER APPROVED METHODS.

CONSTRUCTION KEY NOTES:


- A. LENGTH "Y & W" AS REQUIRED TO OBTAIN BEARING AREA AGAINST UNDISTURBED SOIL.
- B. ADDITIONAL EXCAVATION IF NECESSARY TO OBTAIN REQUIRED BEARING AREA.
- C. MINIMUM THRUST BLOCK AREA REQUIREMENTS FOR (Y & W) AS FOLLOWS:

PIPE SIZE	WATER PIPE	
	TEE, DEAD END 90° BEND	45° AND 22 1/2° BENDS
4" & LESS	3 SQ. FEET	3 SQ. FEET
6"	4 SQ. FEET	3 SQ. FEET
8"	6 SQ. FEET	3 SQ. FEET
10"	9 SQ. FEET	5 SQ. FEET
12"	13 SQ. FEET	7 SQ. FEET
16"	23 SQ. FEET	12 SQ. FEET
18"	29 SQ. FEET	15 SQ. FEET

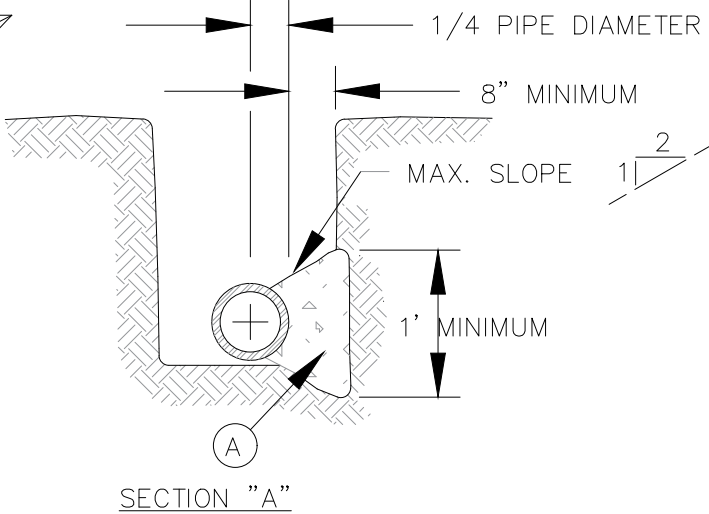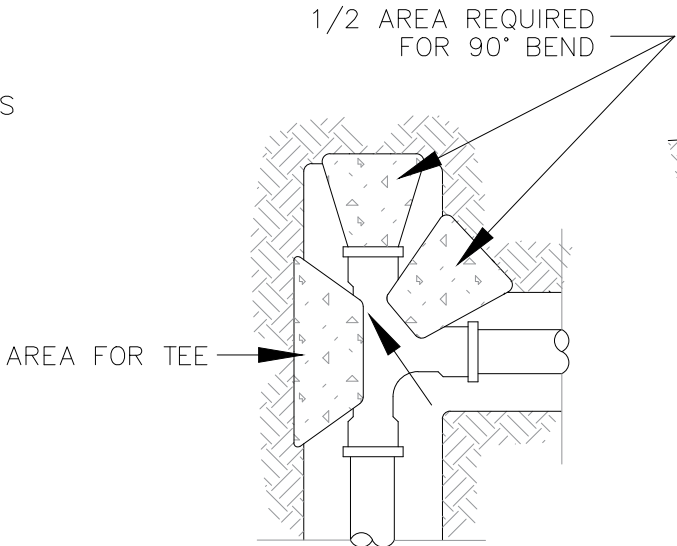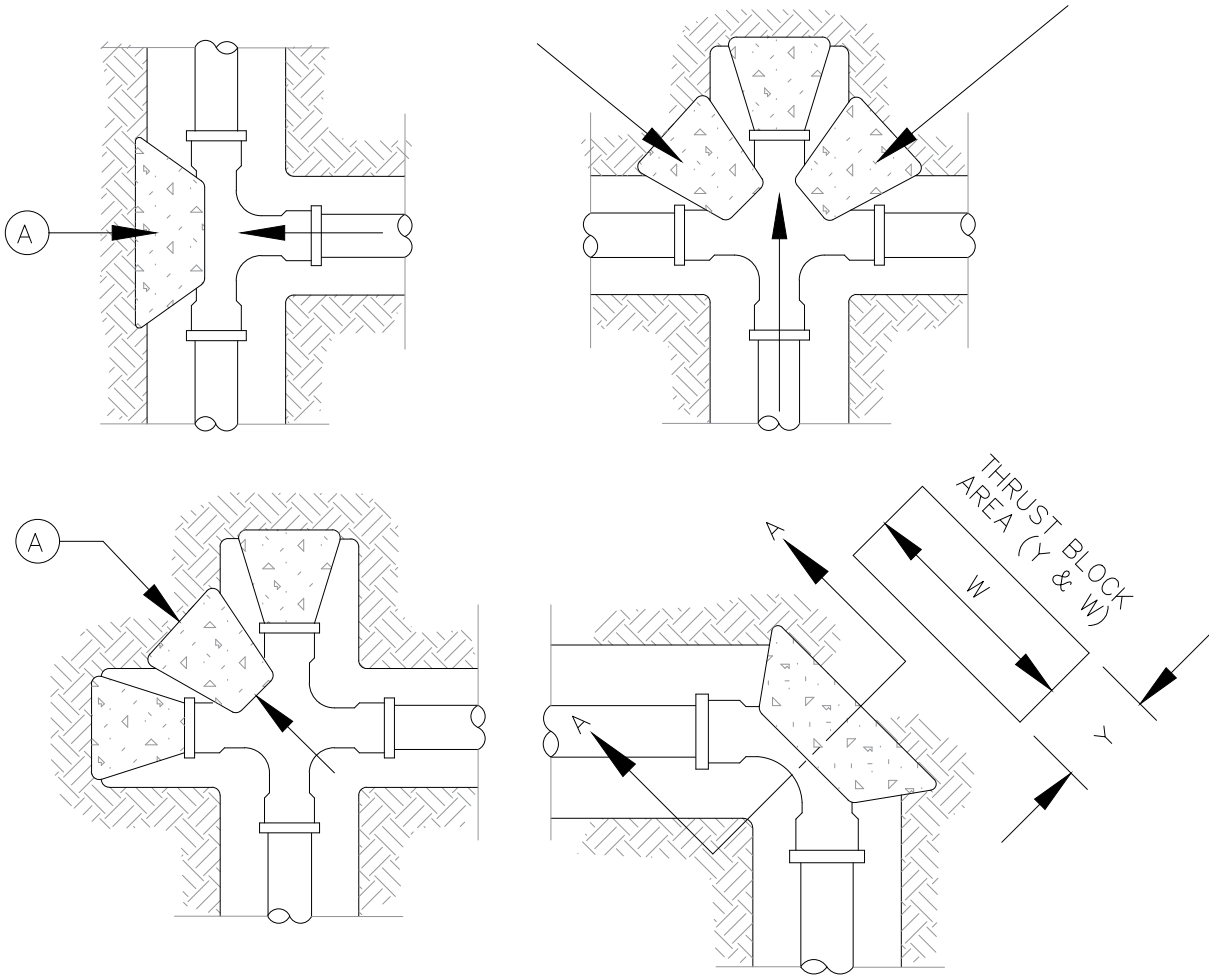


NOTES:

- 1. ALL ANCHOR RODS ARE TO BE COVERED WITH 80MILS OF BITUMASTIC COMPOUND.
- 2. WRAP EXTERIOR OF VALVE, ACTUATOR AND REBAR WITH 8 MIL POLYETHYLENE SHEETING AND TAPE.

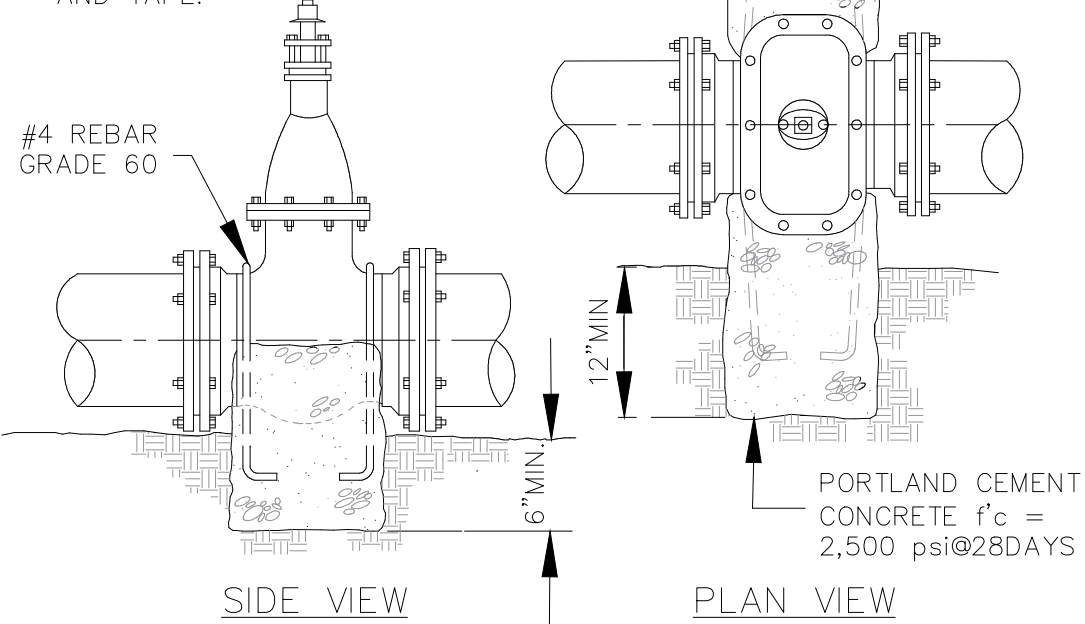


1 TYP. ANCHORING DETAILS Scale: NTS

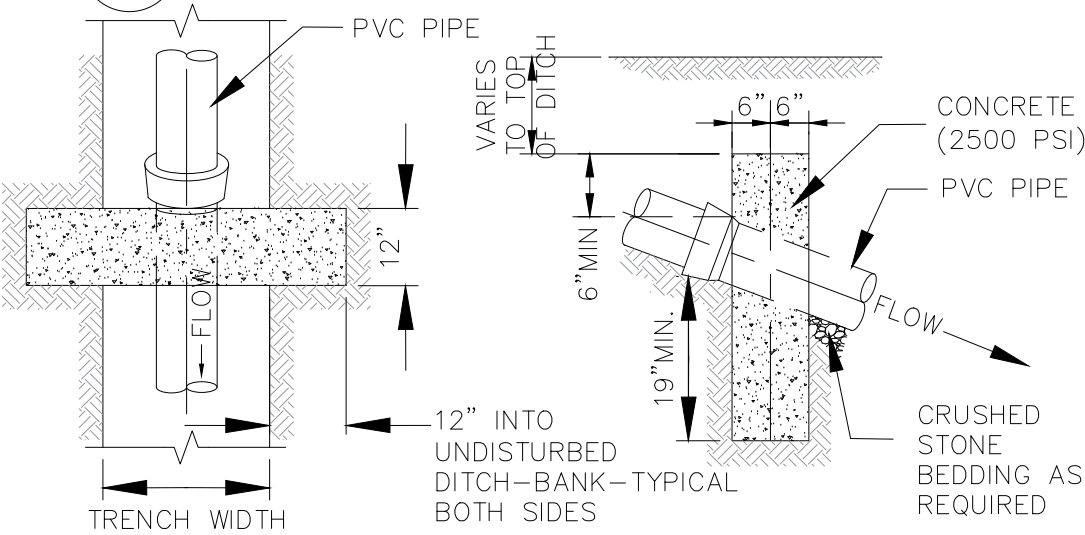


2 ANCHOR ON STEEP SLOPES Scale: NTS

No.	Description	Date	REV. NO.:	DESIGNED BY: FToala	 AMERICAN SAMOA POWER AUTHORITY ENGINEERING SERVICES DIVISION P.O.BOX PPB, TAFUNA, PAGO PAGO, AS 96799	PROJECT NAME: AOLOAU 6" Ø WATERLINE REPLACEMENT PROJECT	SCALE: AS SHOWN	SIGNATURE:
			REVISION:	CHECKED BY: LTyrell		DRAWING TITLE: CONCRETE THRUST BLOCKING DETAILS	PROJECT NO: #1958785	DATE:
			CHECKED BY:	APPROVED BY: FAguila / LTyrell		PROJECT LOCATION: AOLOAU VILLAGE, AMERICAN SAMOA	DATE: APRIL 2023	SHEET NO.
			APPROVED BY:	ISSUE FOR: Construction				D03
			DATE:					

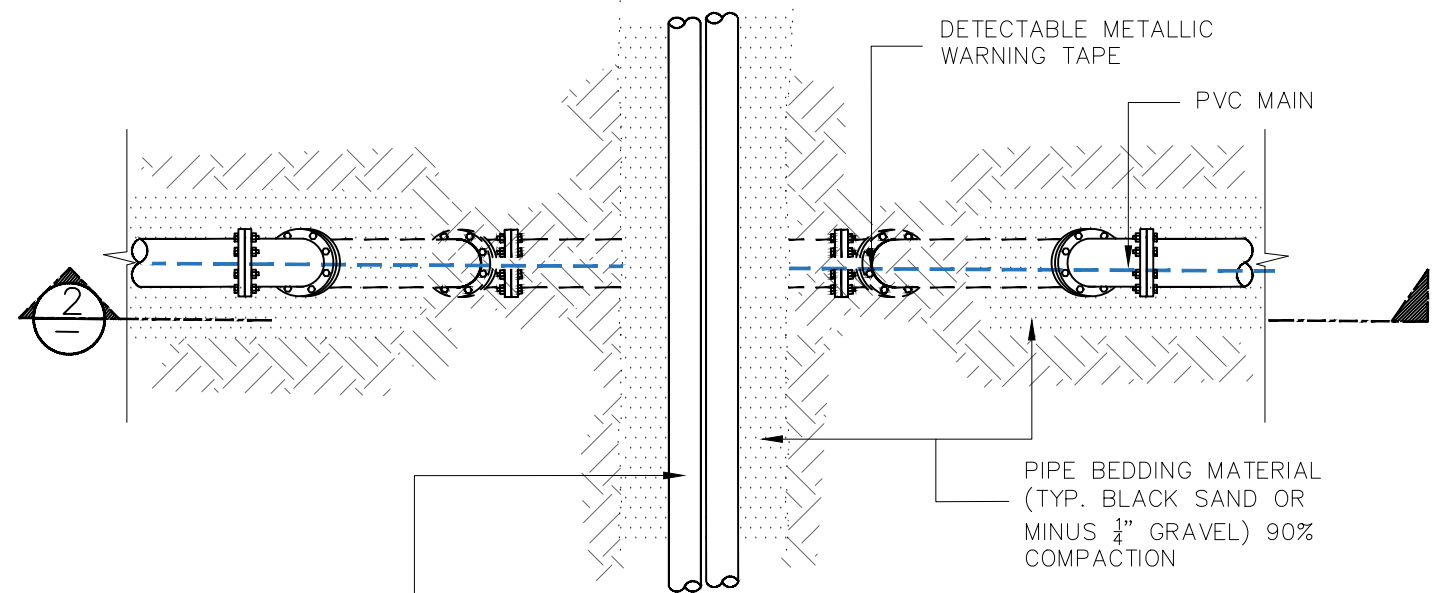


1 PIPE TRENCH PLAN (SECTION ELEVATION)
SCALE: 1/2" = 1'


TRENCH TABLE	
PIPE SIZE	PAYMENT TRENCH
1"	16"
4", 6", 8" OR 10"	24"
12"	30"
16"	34"
20"	38"
24"	42"

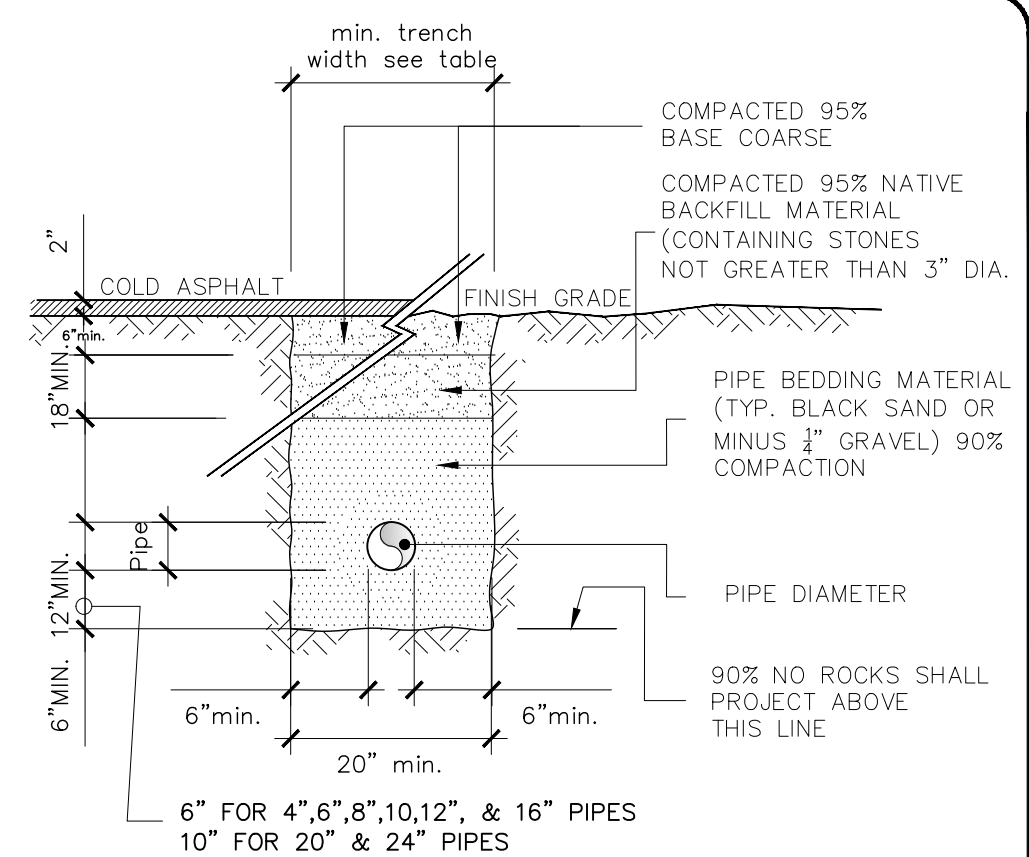

4 TYPICAL TRENCH SECTION
SCALE: 1/2" = 1'

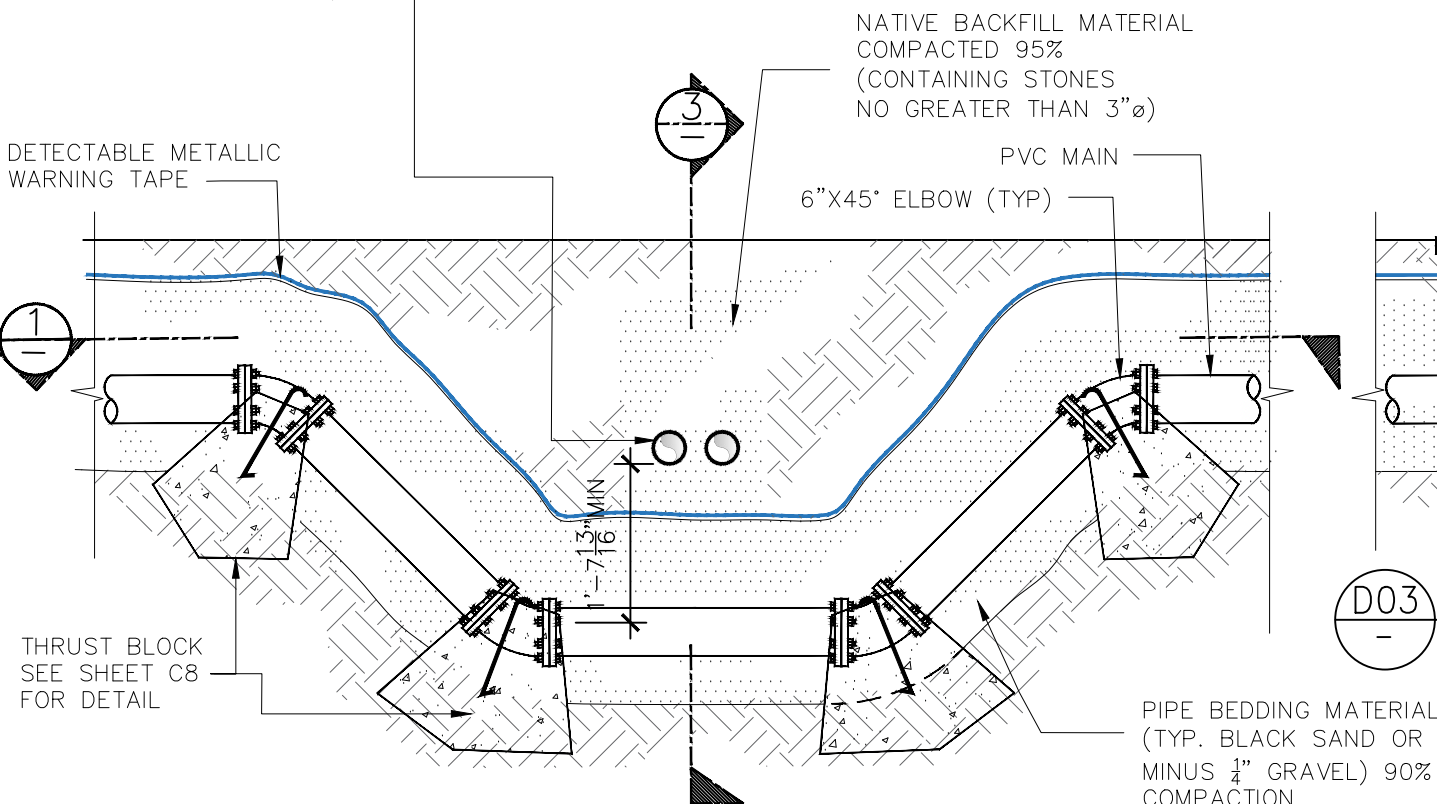

2 TYPICAL UTILITY CROSSING SECTION ELEVATION
SCALE: 1/2" = 1'

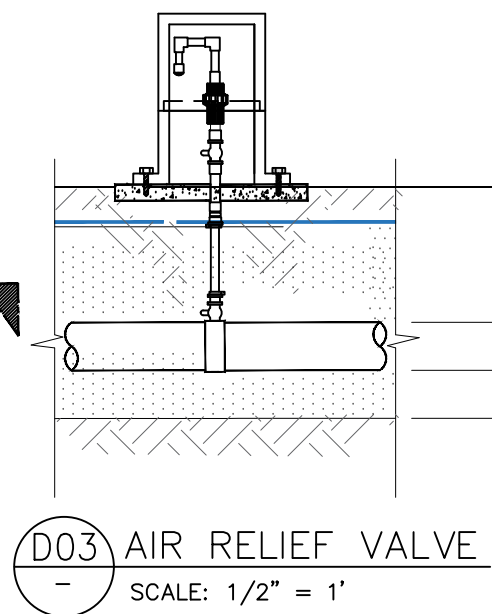

3 TYPICAL UTILITY CROSSING SECTION ELEVATION
SCALE: 1/2" = 1'

No.	Description	Date

REV. NO.:	DESIGNED BY:
REVISION:	CHECKED BY:
CHECKED BY:	APPROVED BY:
APPROVED BY:	ISSUE FOR:
DATE:	

AMERICAN SAMOA POWER AUTHORITY


ENGINEERING SERVICES DIVISION

P.O.BOX PPB, TAFUNA, PAGO PAGO, AS 96799

PROJECT NAME:	PROJECT LOCATION:
DRAWING TITLE:	

SCALE:	SIGNATURE:
PROJECT NO.:	DATE:
DATE:	


D04

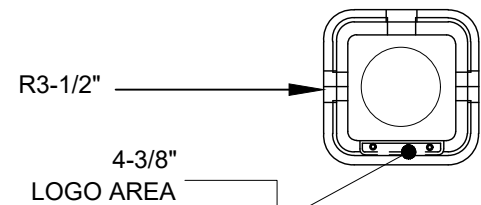


1 PLAN
NOT TO SCALE

NOTE:
GUARD POST LOCATION
DETERMINED BY ENGINEER

2 GUARD POST LOCATION
(3 POST) NOT TO SCALE

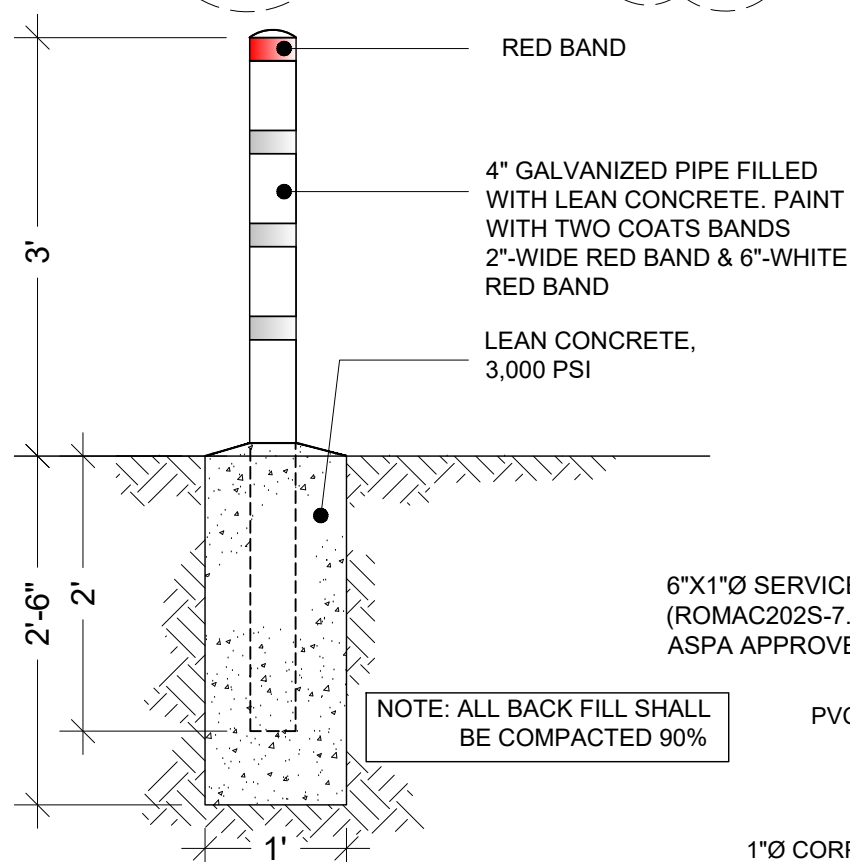

2a GUARD POST FOR BACTERIOLOGICAL
SAMPLING STATION, (2 FEET IN FRONT)
NOT TO SCALE (SEE GUARD POST LOCATION ON MAP ABOVE)

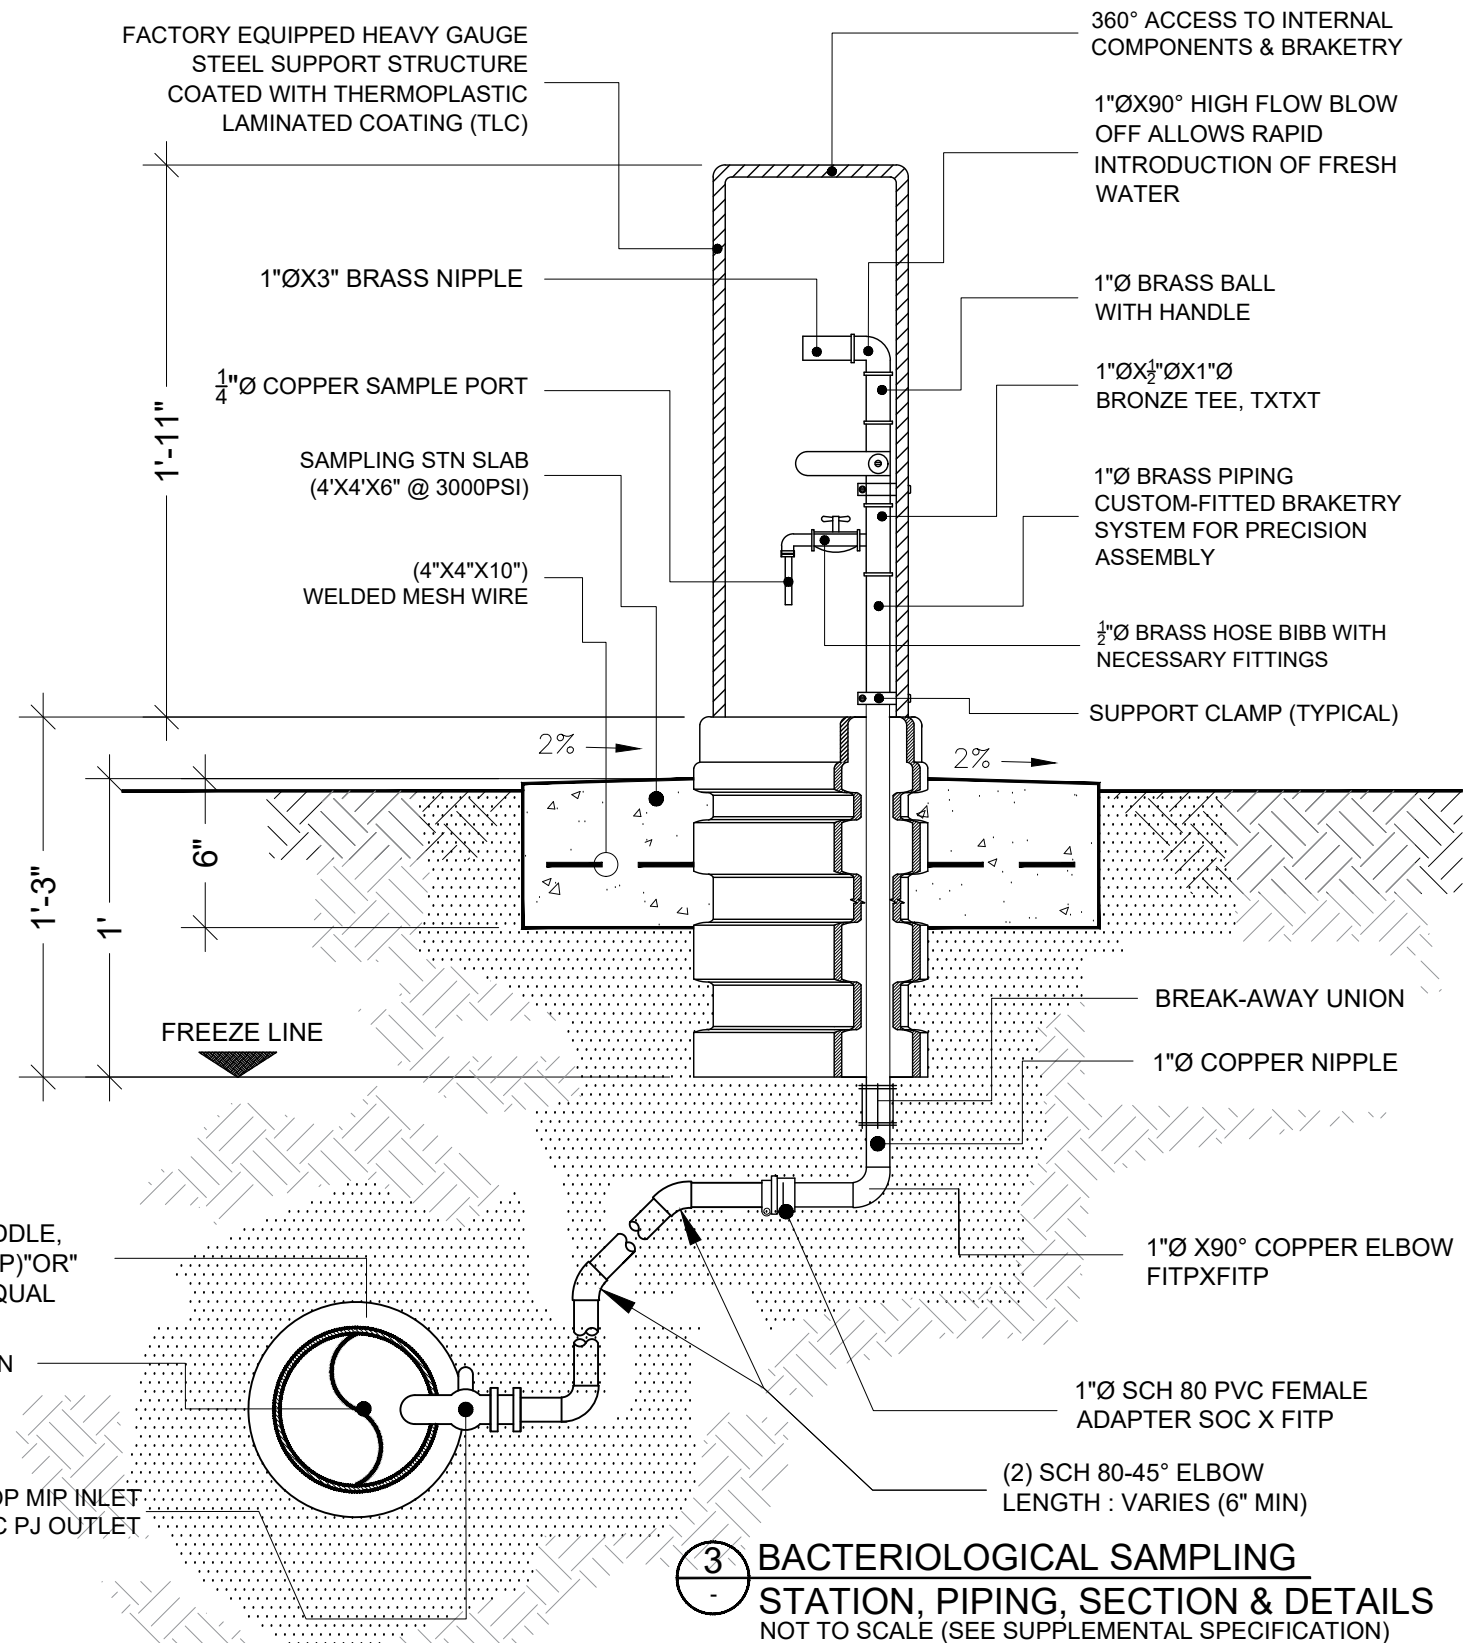

3 BACTERIOLOGICAL SAMPLING
STATION, PIPING, SECTION & DETAILS
NOT TO SCALE (SEE SUPPLEMENTAL SPECIFICATION)

1a SAFETY GUARD BACTERIOLOGICAL
SAMPLING STATION ELEVATION
NOT TO SCALE (SEE SUPPLEMENTAL SPECIFICATION)

No.	Description	Date	REV. NO.:	DESIGNED BY:
				FToala
			REVISION:	CHECKED BY:
				LTyrell
			CHECKED BY:	APPROVED BY:
				FAguila / LTyrell
			APPROVED BY:	ISSUE FOR:
				Construction
			DATE:	




AMERICAN SAMOA POWER AUTHORITY

AMERICAN SAMOA POWER AUTHORITY
ENGINEERING SERVICES DIVISION

P.O.BOX PPB, TAFUNA, PAGO PAGO, AS 96799

PROJECT NAME:	SCALE:	SIGNATURE:
AOLOAU 6"Ø WATERLINE REPLACEMENT PROJECT	AS SHOWN	DATE:
DRAWING TITLE:	PROJECT NO:	
BACTERIOLOGICAL SAMPLING STATION & DETAILS	#1958785	
PROJECT LOCATION:	DATE:	SHEET NO.
AOLOAU VILLAGE, AMERICAN SAMOA	APRIL 2023	D05

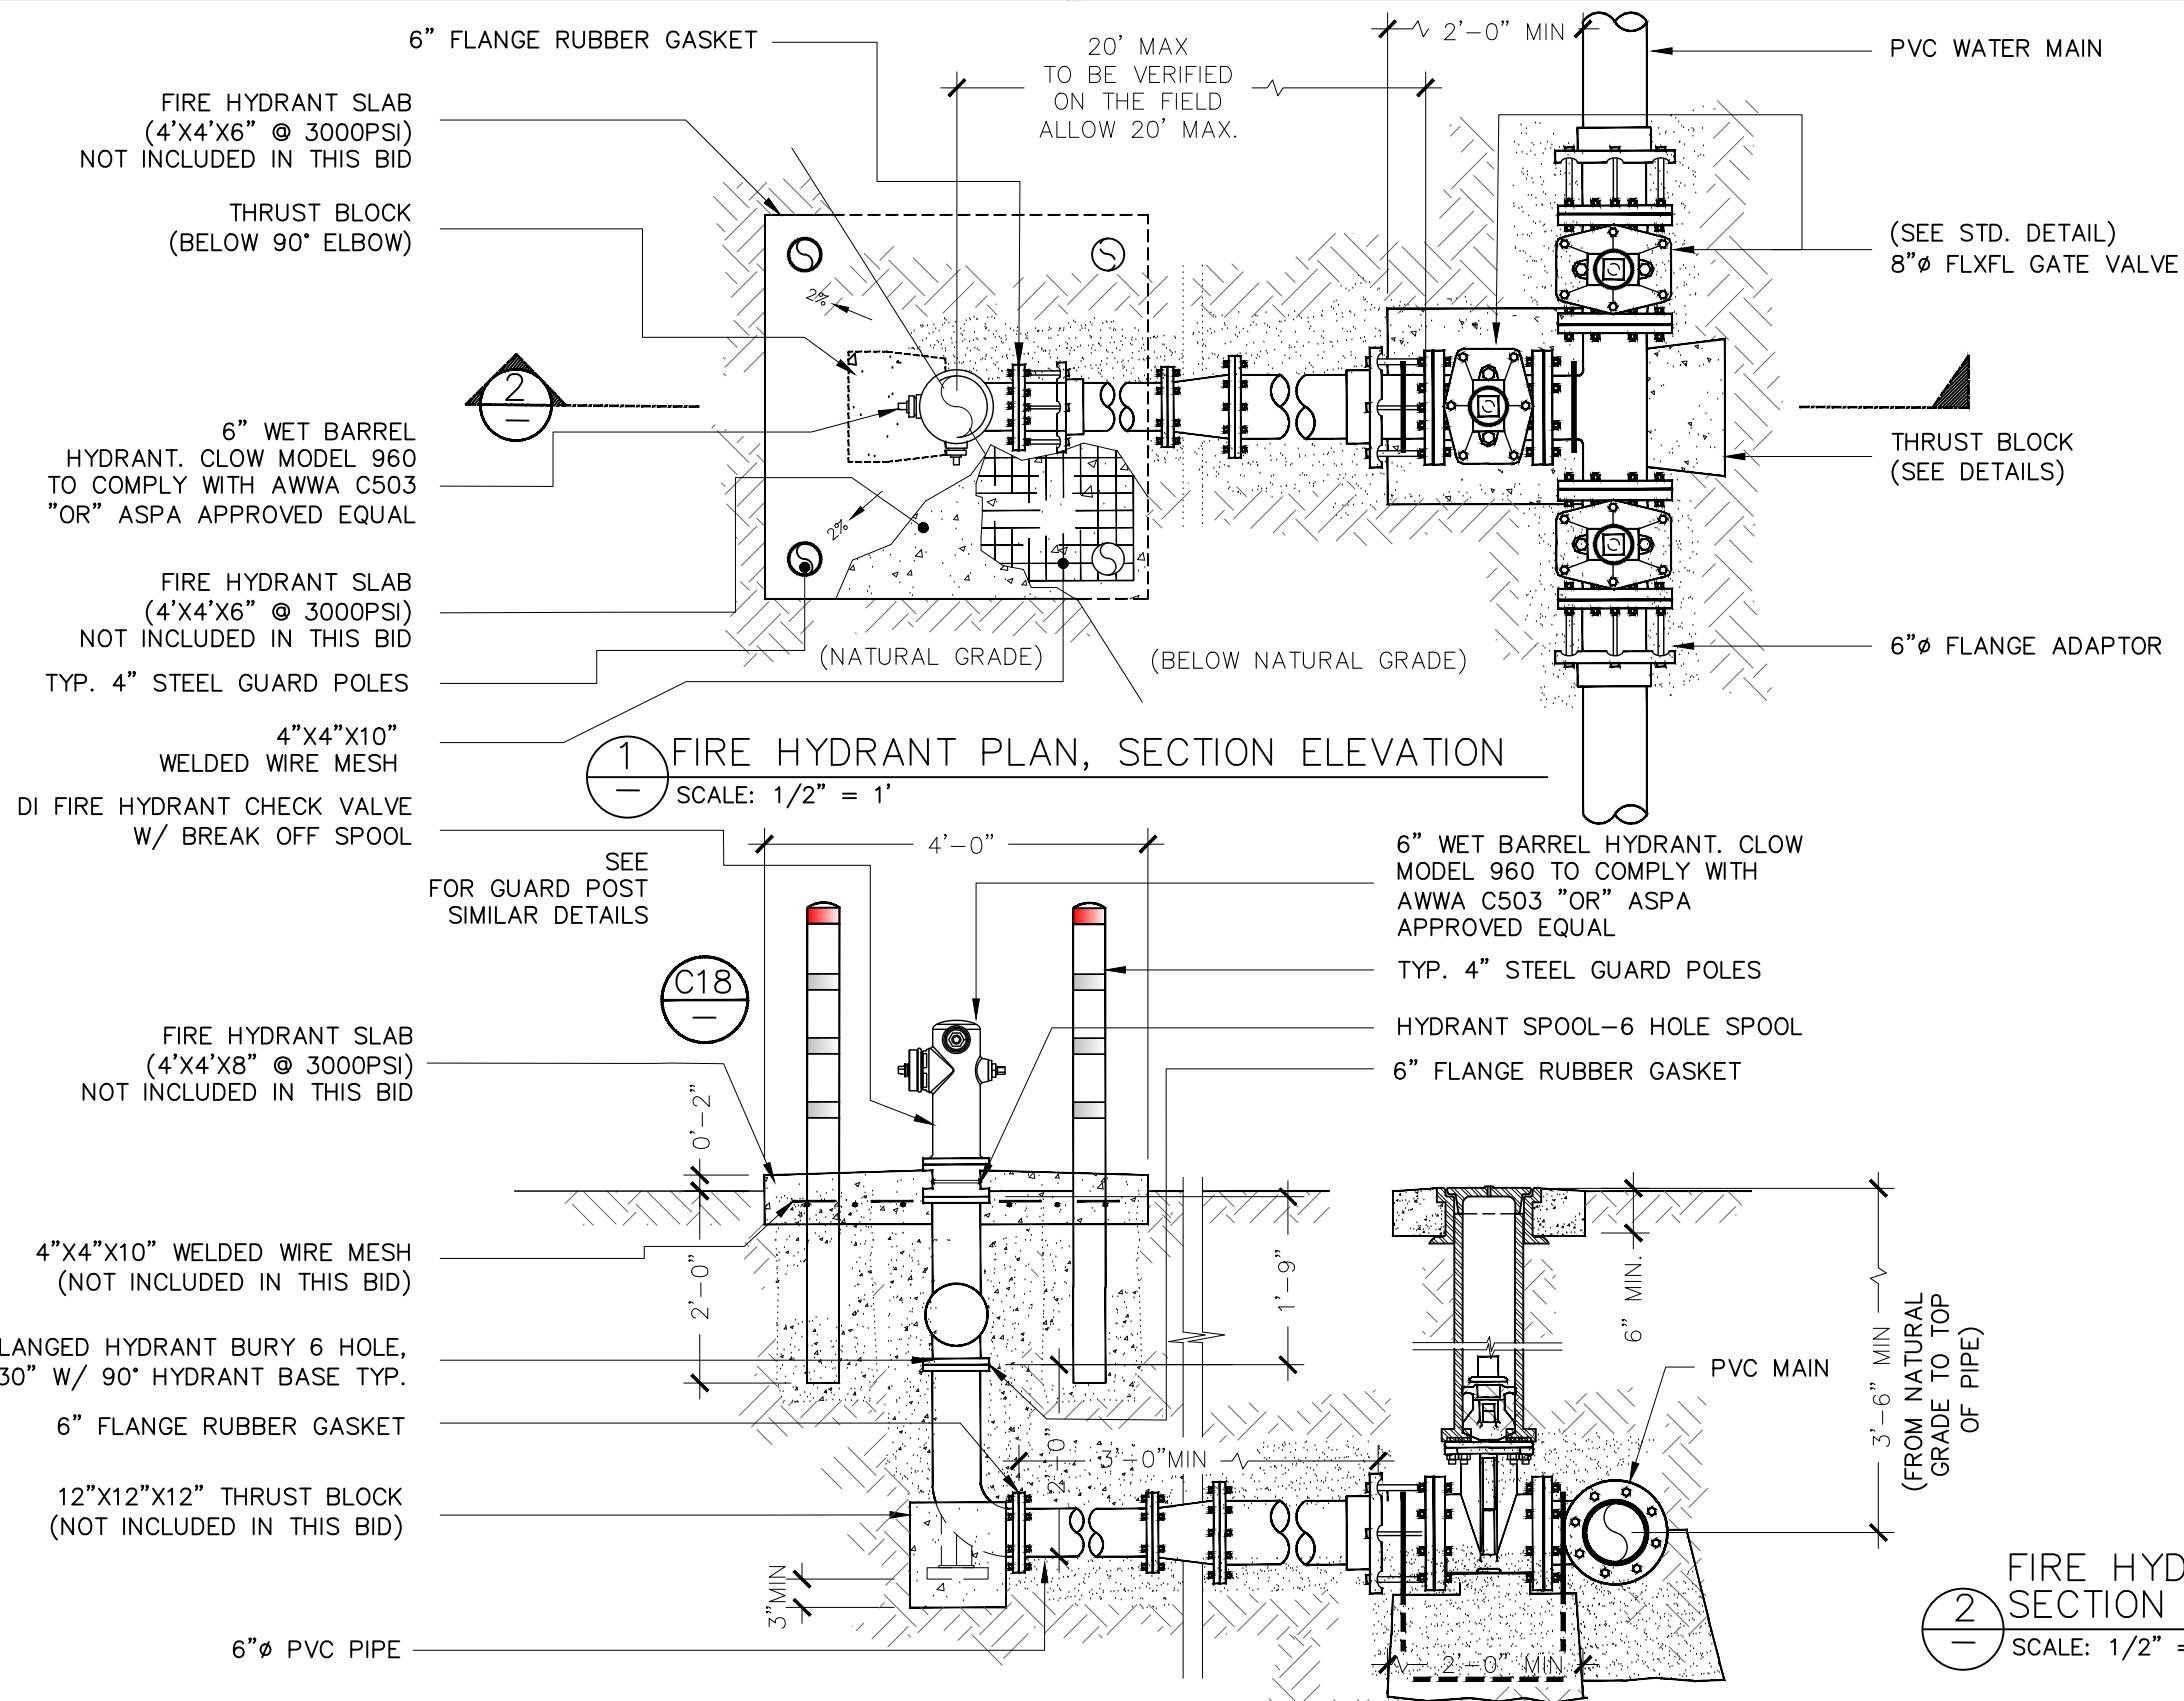






No.	Description	Date	REV. NO.:	DESIGNED BY:	PROJECT NAME:	SCALE:	SIGNATURE:
				FToala	AOLOAU 6"Ø WATERLINE REPLACEMENT PROJECT	AS SHOWN	DATE:
			REVISION:	CHECKED BY:	DRAWING TITLE:	PROJECT NO:	
				LTyrell	FIRE HYDRANT PIPING & DETAILS	#1958785	
			CHECKED BY:	APPROVED BY:	PROJECT LOCATION:	DATE:	SHEET NO.
				Faguila / LTyrell	AOLOAU VILLAGE, AMERICAN SAMOA	APRIL 2023	D06
			APPROVED BY:	ISSUE FOR:			
			DATE:	Construction			



AMERICAN SAMOA POWER AUTHORITY
ENGINEERING SERVICES DIVISION

P.O.BOX PPB, TAFUNA, PAGO PAGO, AS 96799

AMERICAN SAMOA POWER AUTHORITY

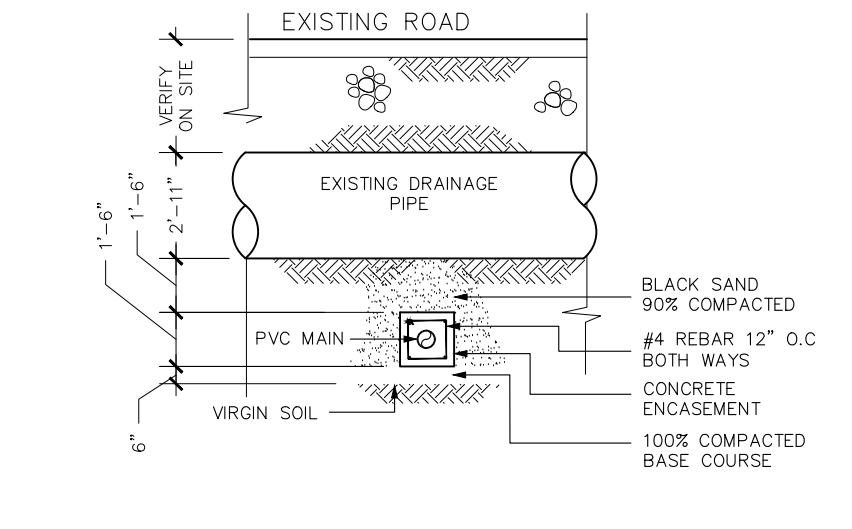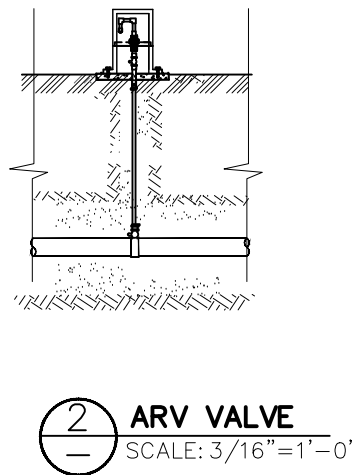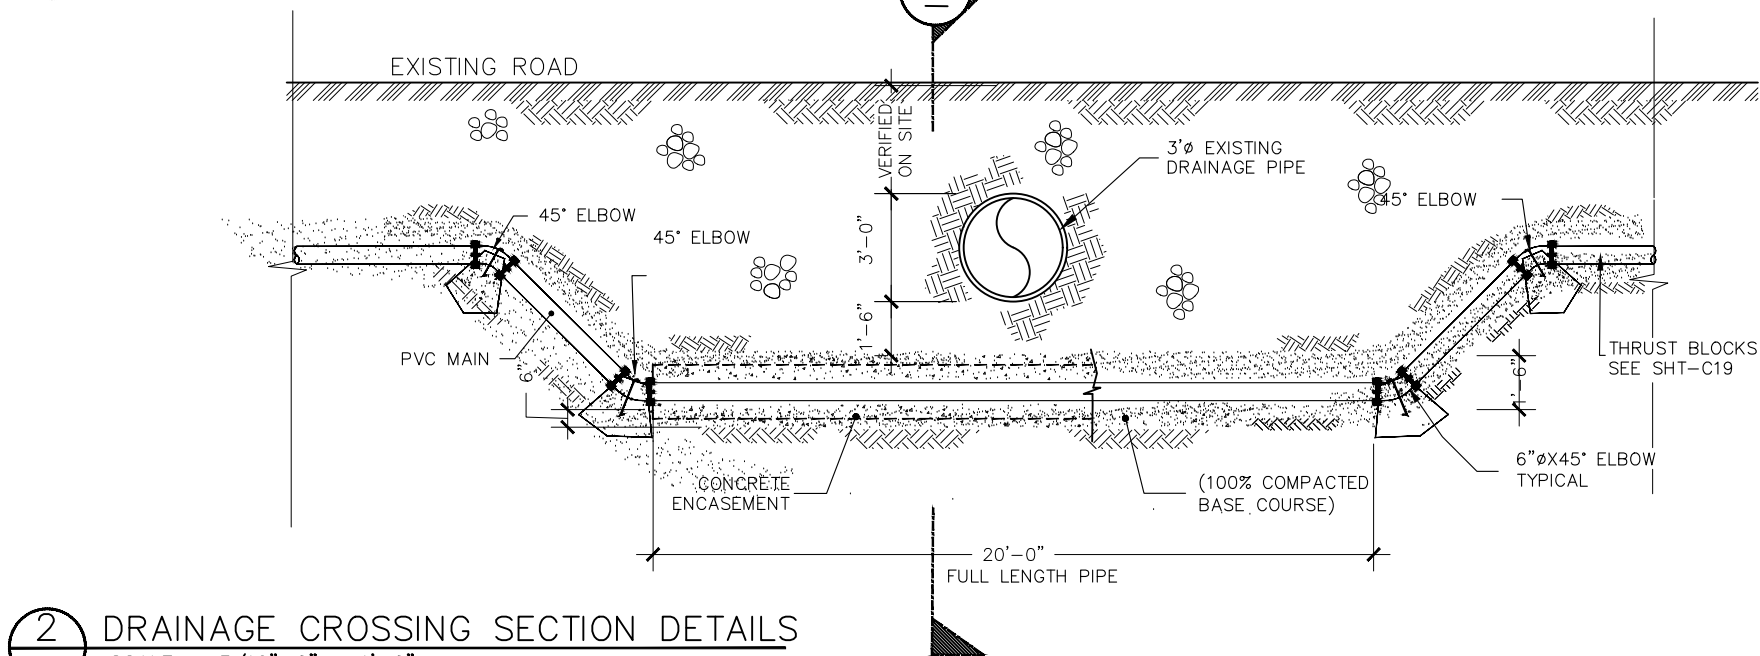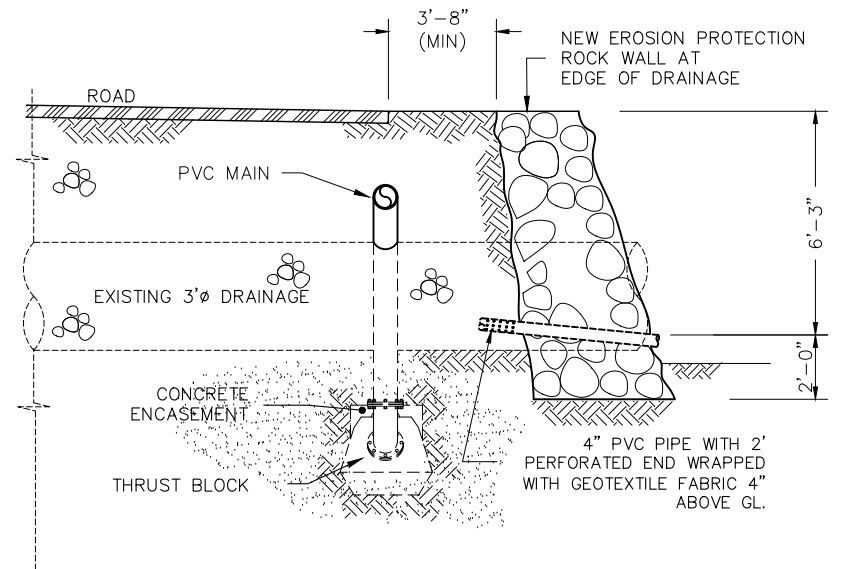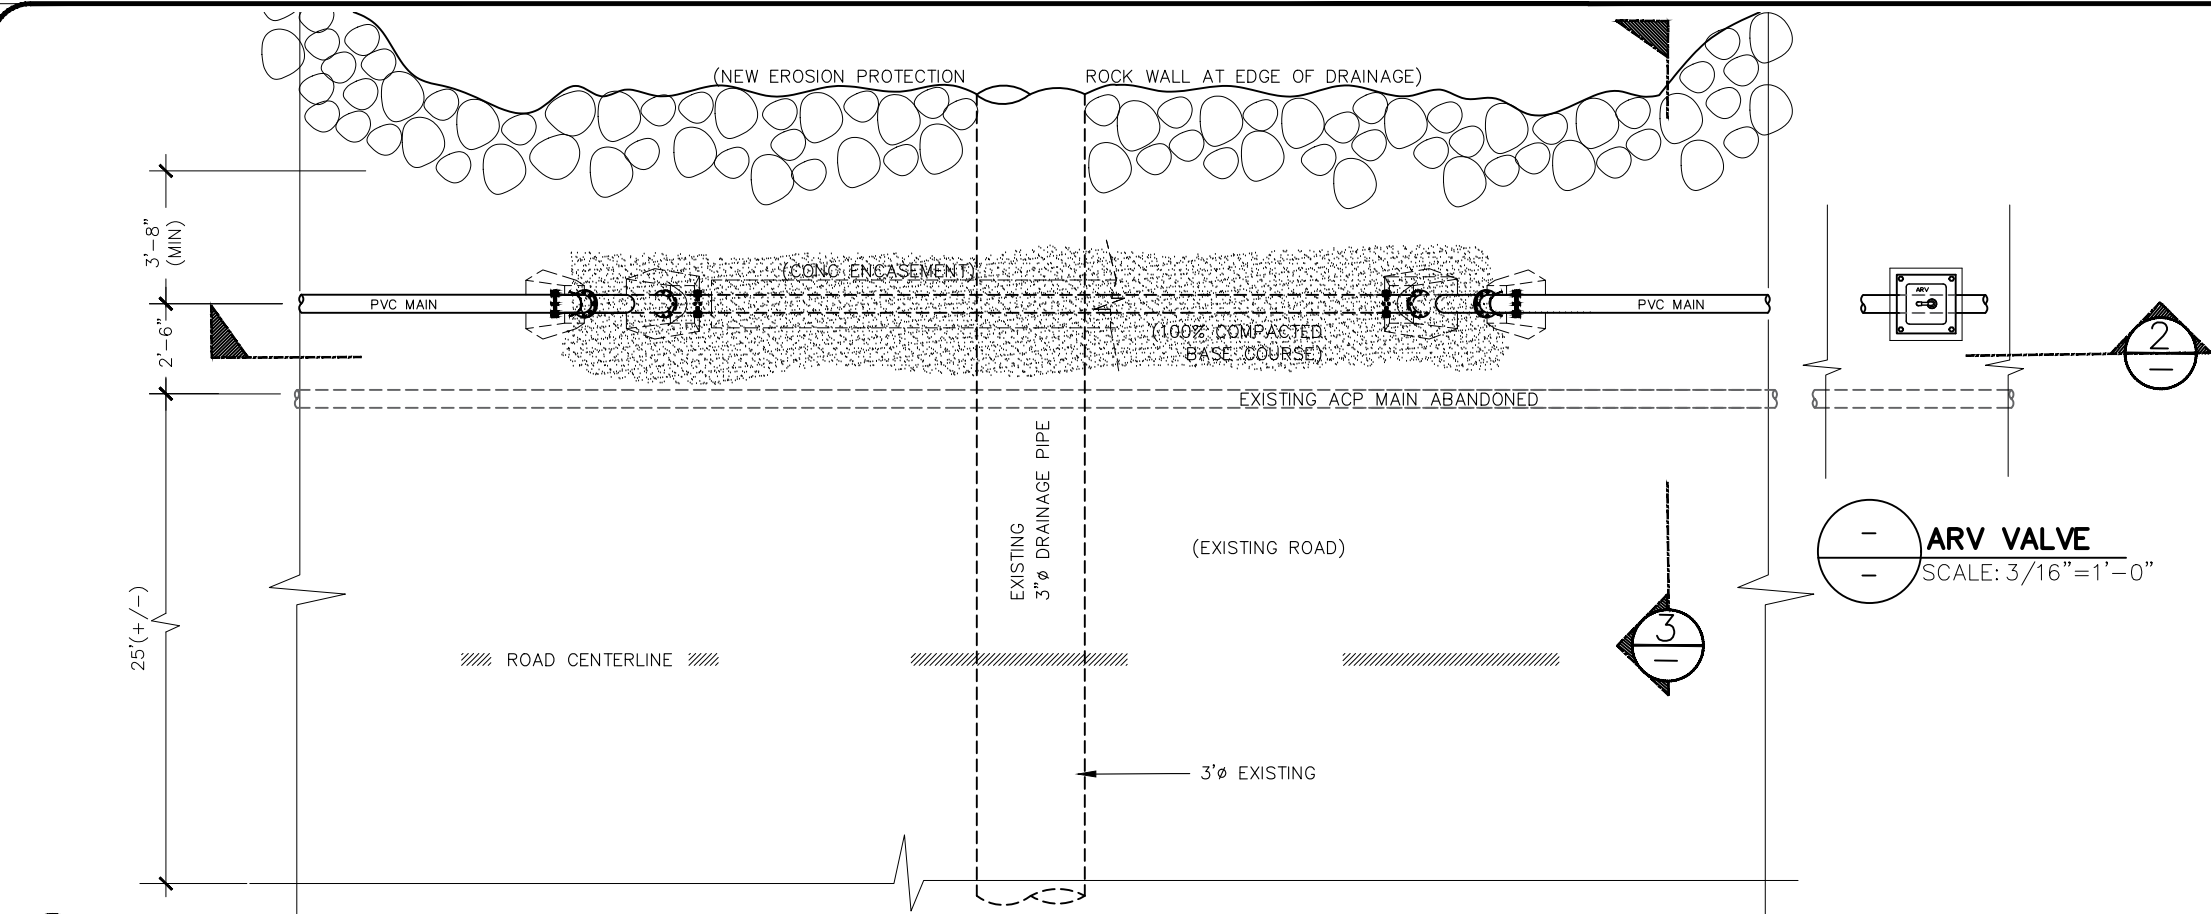

No.	Description	Date	REV. NO.:	DESIGNED BY:
				FToala
			REVISION:	CHECKED BY:
				LTyrell
			CHECKED BY:	APPROVED BY:
				FAguila / LTyrell
			APPROVED BY:	ISSUE FOR:
				Construction
			DATE:	



AMERICAN SAMOA POWER AUTHORITY

AMERICAN SAMOA POWER AUTHORITY
ENGINEERING SERVICES DIVISION

P.O.BOX PPB, TAFUNA, PAGO PAGO, AS 96799

PROJECT NAME:
AOLOAU 6"Ø WATERLINE REPLACEMENT PROJECT

DRAWING TITLE:
TYPICAL MAIN ROAD DRAINAGE CROSSING SECTIONS & DETAILS

PROJECT LOCATION:
AOLOAU VILLAGE, AMERICAN SAMOA


SCALE:
AS SHOWN

PROJECT NO:
#1958785


DATE:
APRIL 2023

SIGNATURE:
DATE:

SHEET NO.
D07

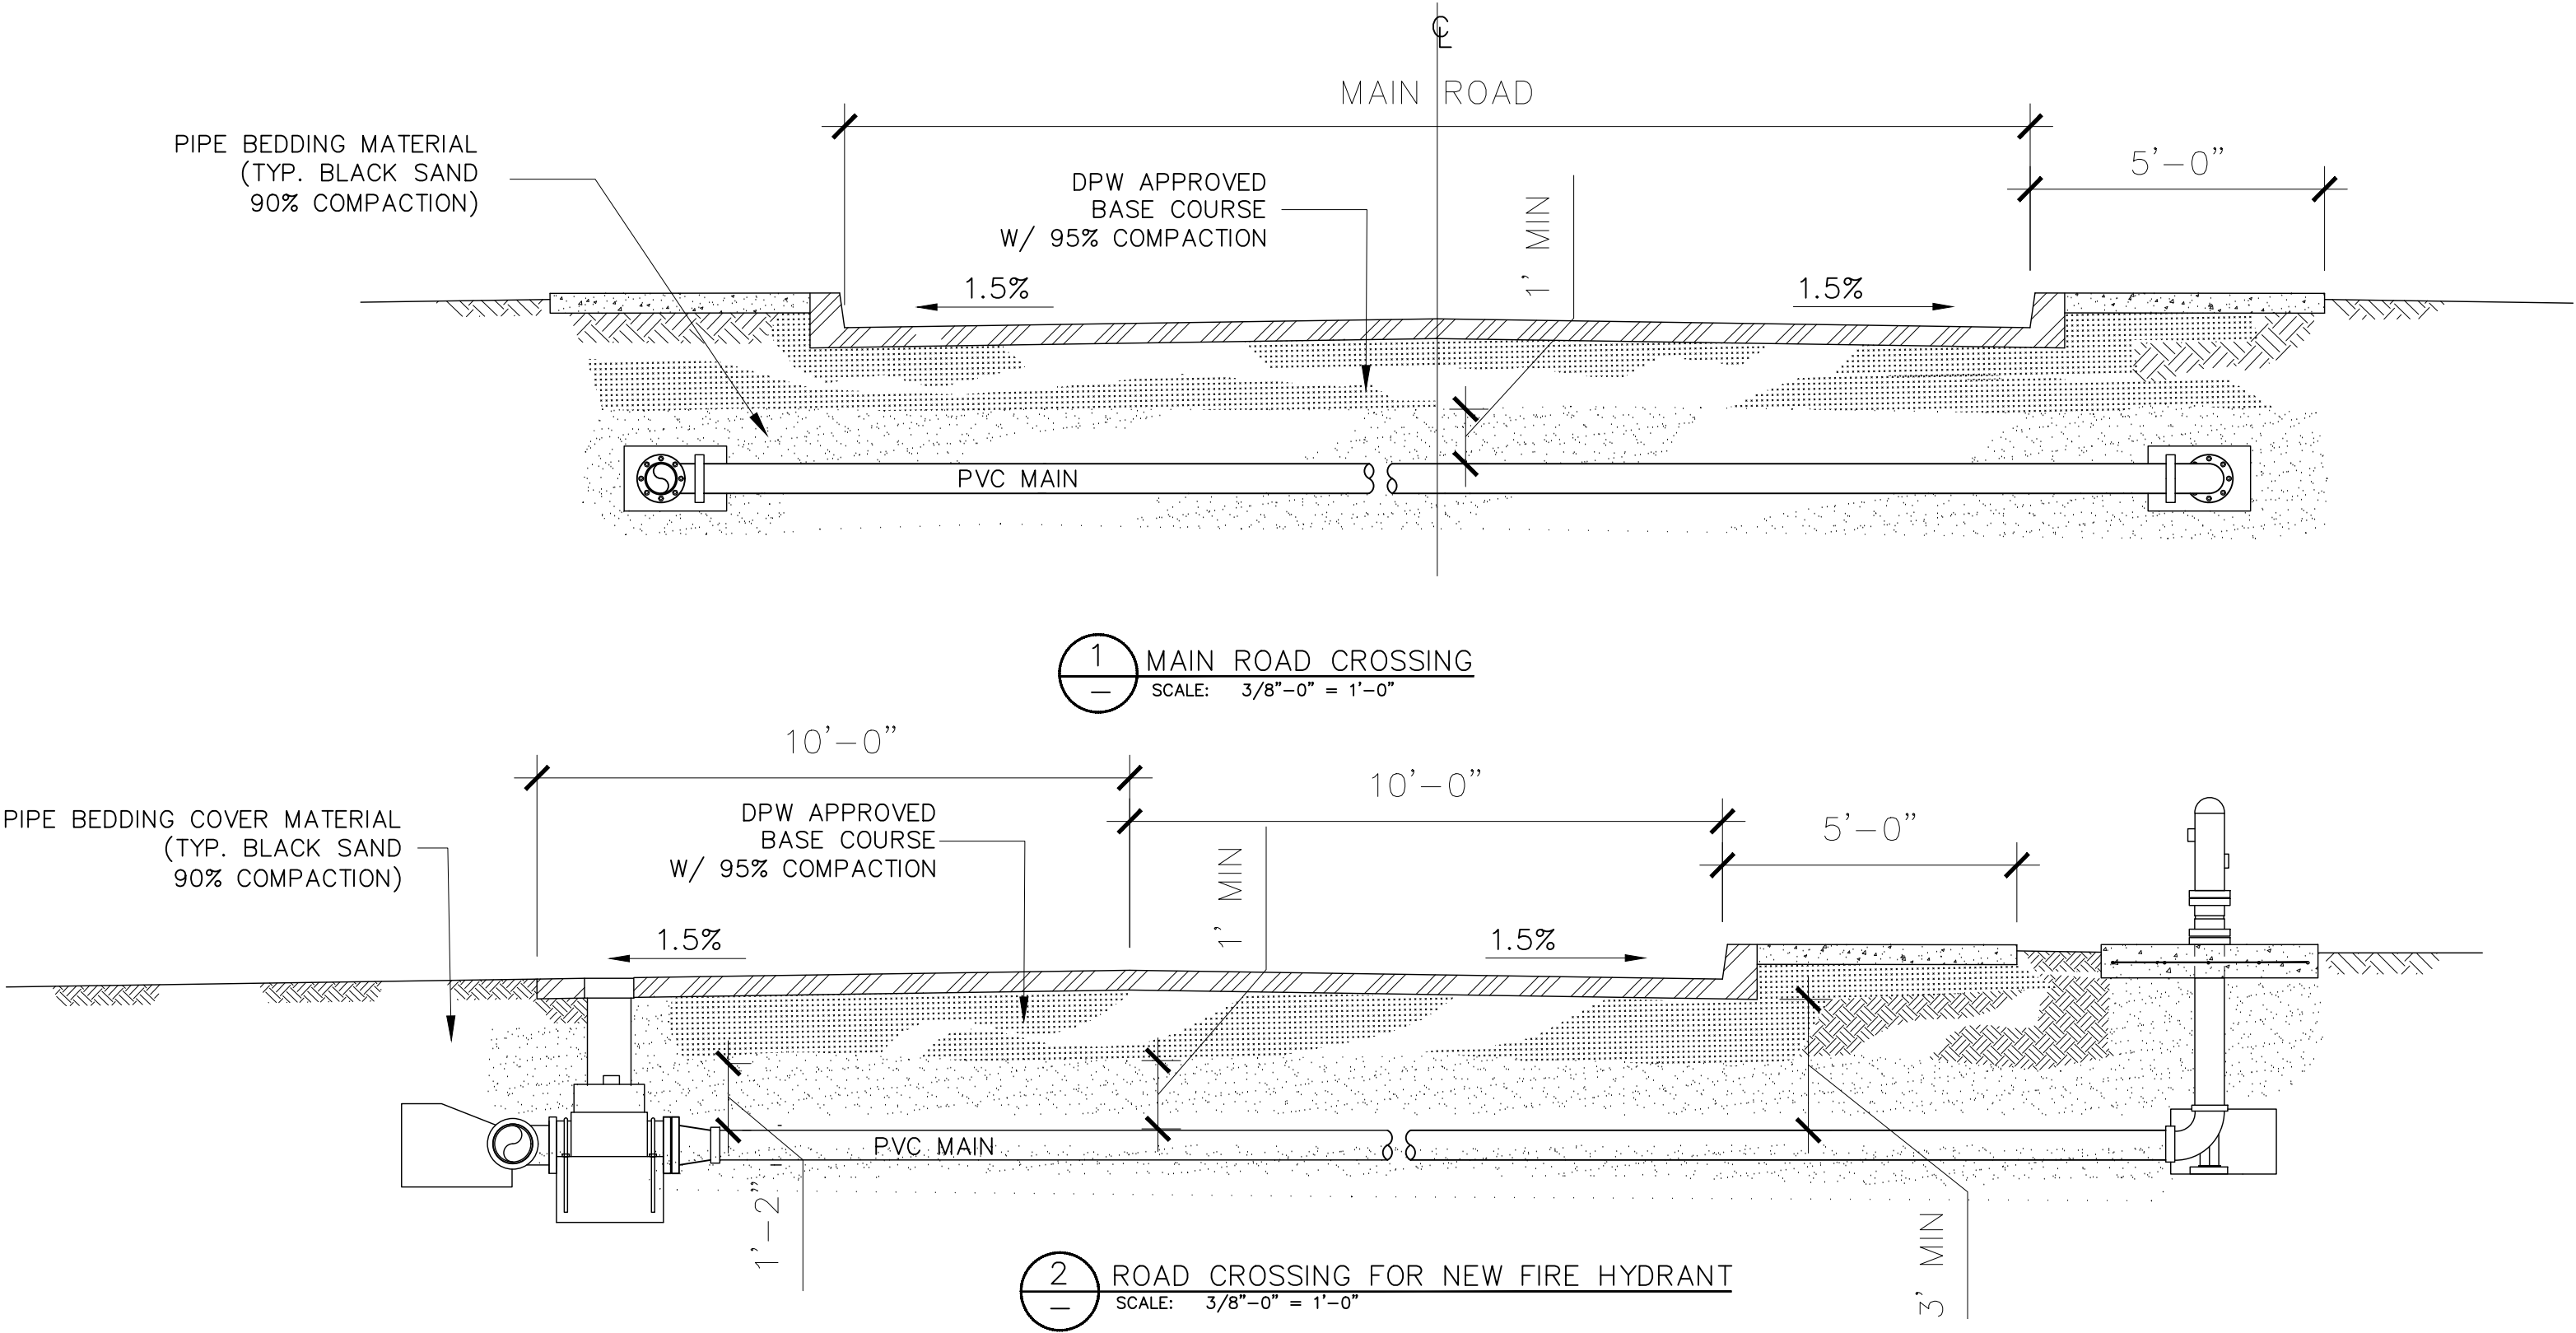

<table><tr><th>No.</th><th>Description</th><th>Date</th></tr><tr><td></td><td></td><td></td></tr><tr><td></td><td></td><td></td></tr><tr><td></td><td></td><td></td></tr><tr><td></td><td></td><td></td></tr><tr><td></td><td></td><td></td></tr></table>	No.	Description	Date																REV. NO.:	DESIGNED BY:	ASPA AMERICAN SAMOA POWER AUTHORITY ENGINEERING SERVICES DIVISION P.O.BOX PPB, TAFUNA, PAGO PAGO, AS 96799 AMERICAN SAMOA POWER AUTHORITY	PROJECT NAME:	SCALE:	SIGNATURE:
	No.	Description	Date																					
REVISION:	CHECKED BY:	AOLOAU 6"Ø WATERLINE REPLACEMENT PROJECT	AS SHOWN	DATE:																				
CHECKED BY:	APPROVED BY:	DRAWING TITLE:	PROJECT NO:	SHEET NO.																				
APPROVED BY:	ISSUE FOR:	TYPICAL MAIN ROAD CROSSING SECTION & DETAILS FOR NEW FIRE HYDRANT.	#1958785																					
DATE:	Construction	PROJECT LOCATION:	DATE:																					
		AOLOAU VILLAGE, AMERICAN SAMOA	APRIL 2023	D08																				

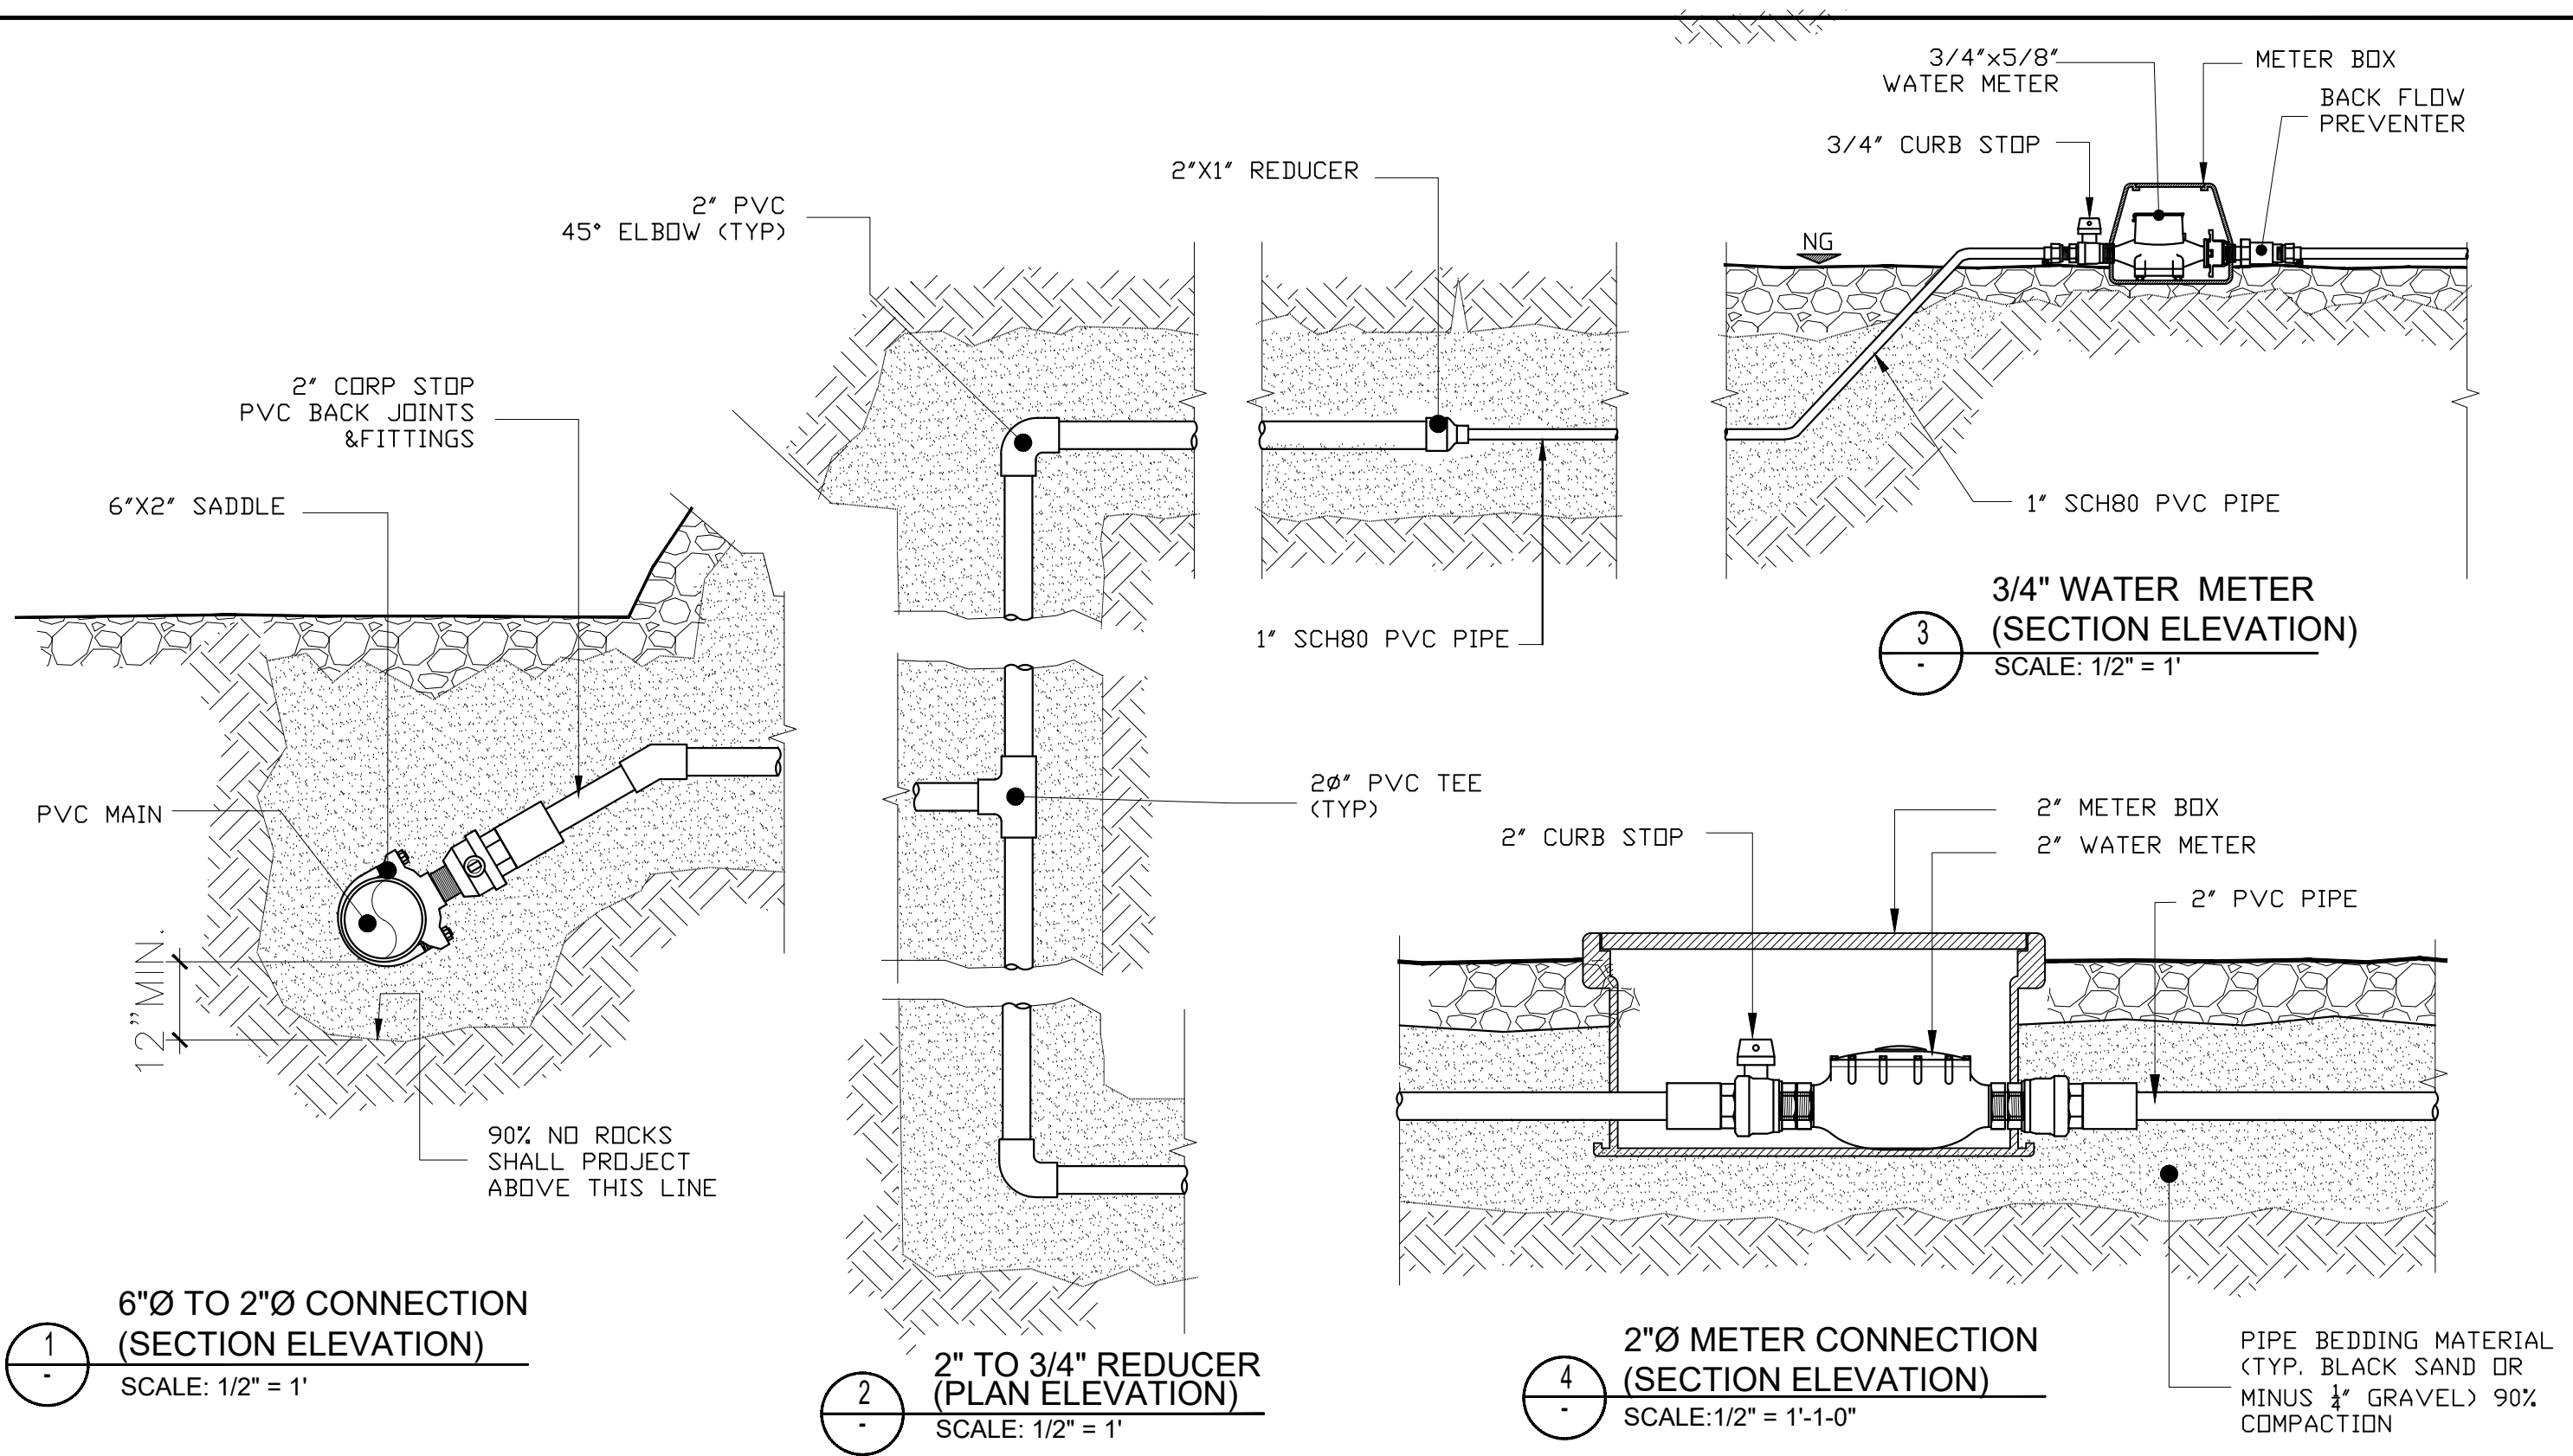

No.	Description	Date	REV. NO.	DESIGNED BY:	PROJECT NAME:	SCALE:	SIGNATURE:
				FToala	AOLOAU 6"Ø WATERLINE REPLACEMENT PROJECT	AS SHOWN	DATE:
			REVISION:	CHECKED BY:	DRAWING TITLE:	PROJECT NO:	
				LTyrell	TYPICAL PVC PIPE SERVICE LINE LAYOUT & CONNECTION DETAILS	#1958785	
			CHECKED BY:	APPROVED BY:	PROJECT LOCATION:	DATE:	SHEET NO.
				FAguila / LTyrell	AOLOAU VILLAGE, AMERICAN SAMOA	APRIL 2023	D09
			APPROVED BY:	ISSUE FOR:			
				Construction			
			DATE:				




AMERICAN SAMOA POWER AUTHORITY


AMERICAN SAMOA POWER AUTHORITY

ENGINEERING SERVICES DIVISION


P.O.BOX PPB, TAFUNA, PAGO PAGO, AS 96799

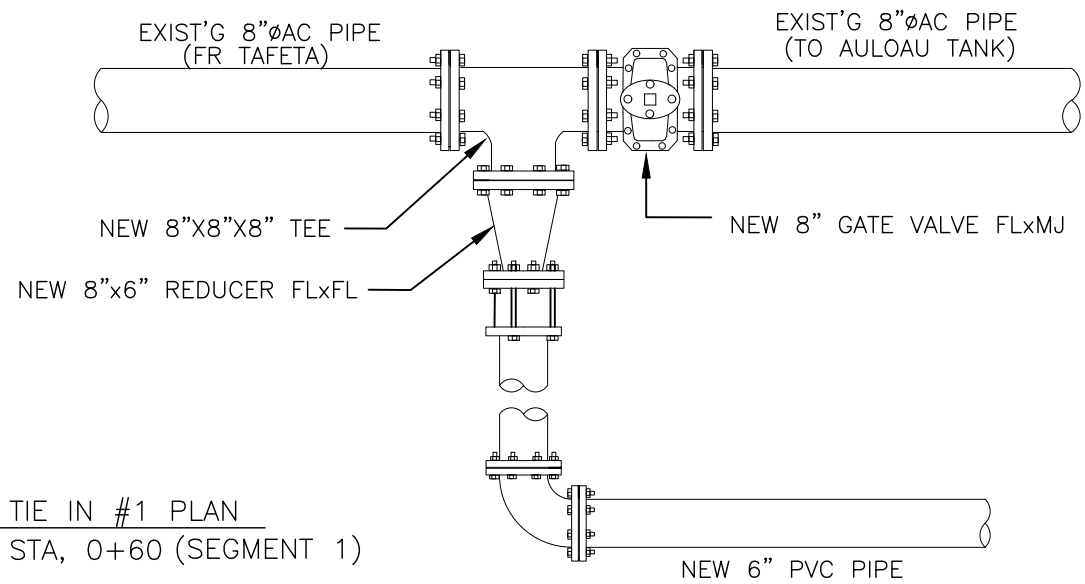


- TIE IN #1 PLAN
 C01 STA, 0+60 (SEGMENT 1)

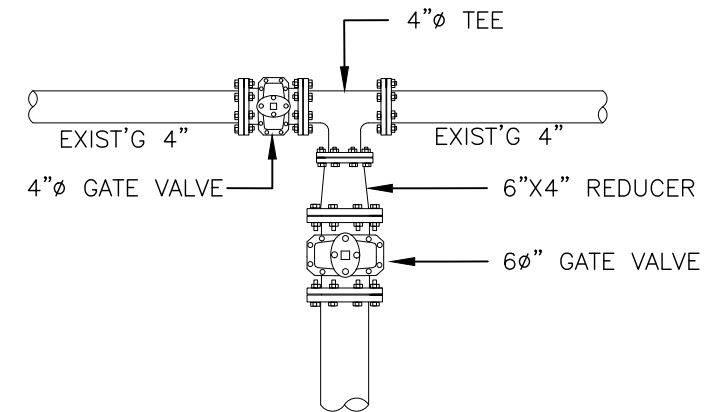

- TIE IN #4 PLAN
 C11 STA, 54+70 (SEGMENT 1)

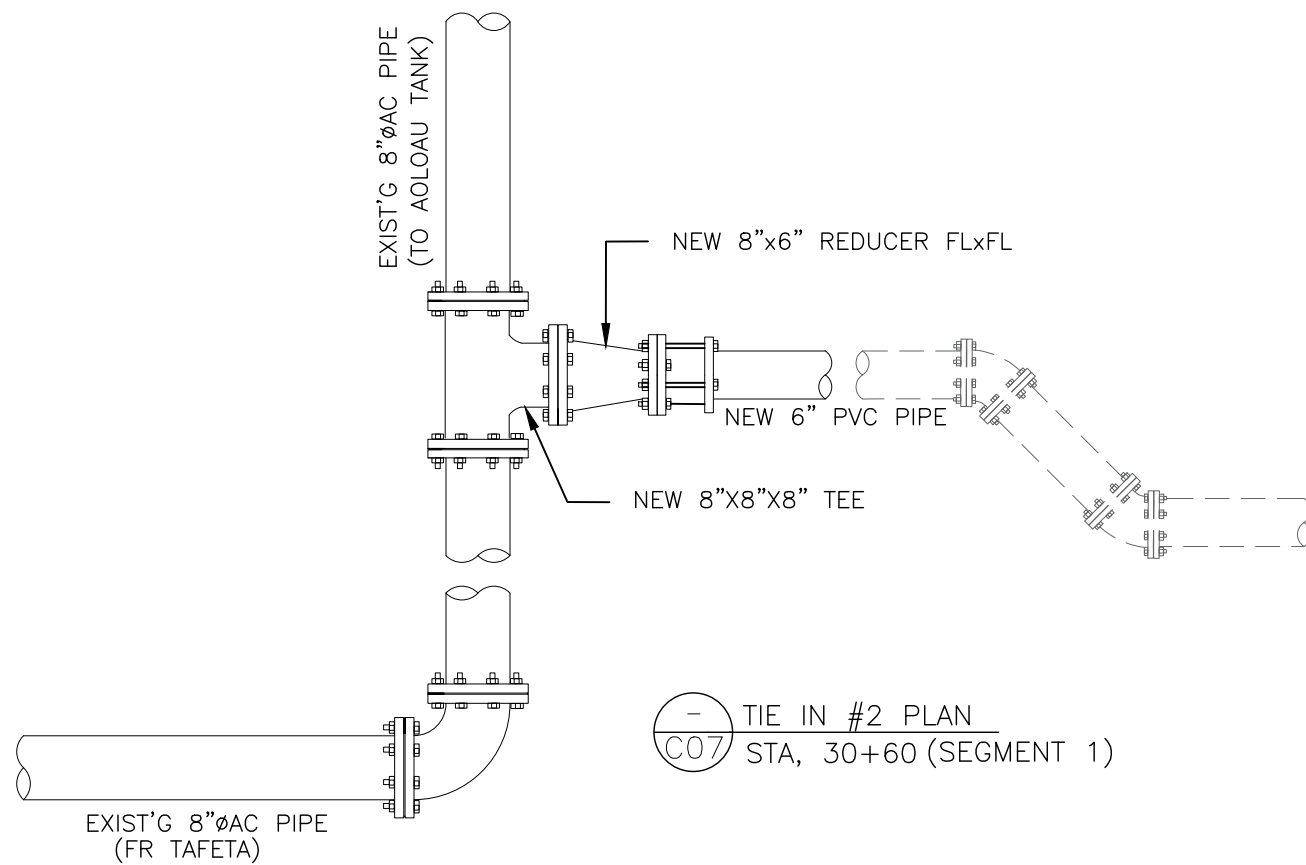

- TIE IN #2 PLAN
 C07 STA, 30+60 (SEGMENT 1)


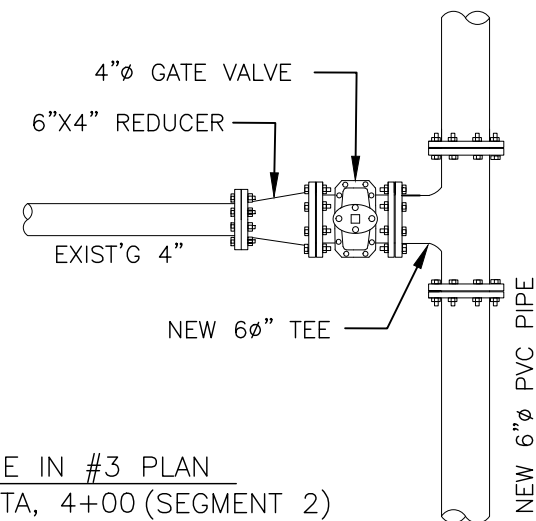


- TIE IN #3 PLAN
 C17 STA, 4+00 (SEGMENT 2)

No.	Description	Date	REV. NO.	DESIGNED BY:	PROJECT NAME:	SCALE:	SIGNATURE:
				FToala	AOLOAU 6"Ø WATERLINE REPLACEMENT PROJECT	AS SHOWN	DATE:
			REVISION:	CHECKED BY:	DRAWING TITLE:	PROJECT NO:	
				LTyrell	TIE-IN TO MAIN WATER SUPPLY WITH WITH ADDITIONAL STANDARD DETAILS.	1958785	SHEET NO.
			CHECKED BY:	APPROVED BY:	PROJECT LOCATION:	DATE:	
				FAguila / LTyrell	AOLOAU VILLAGE, AMERICAN SAMOA	APRIL 2023	D10
			APPROVED BY:	ISSUE FOR:			
				Construction			
			DATE:				



AMERICAN SAMOA POWER AUTHORITY
ENGINEERING SERVICES DIVISION
 P.O.BOX PPB, TAFUNA, PAGO PAGO, AS 96799

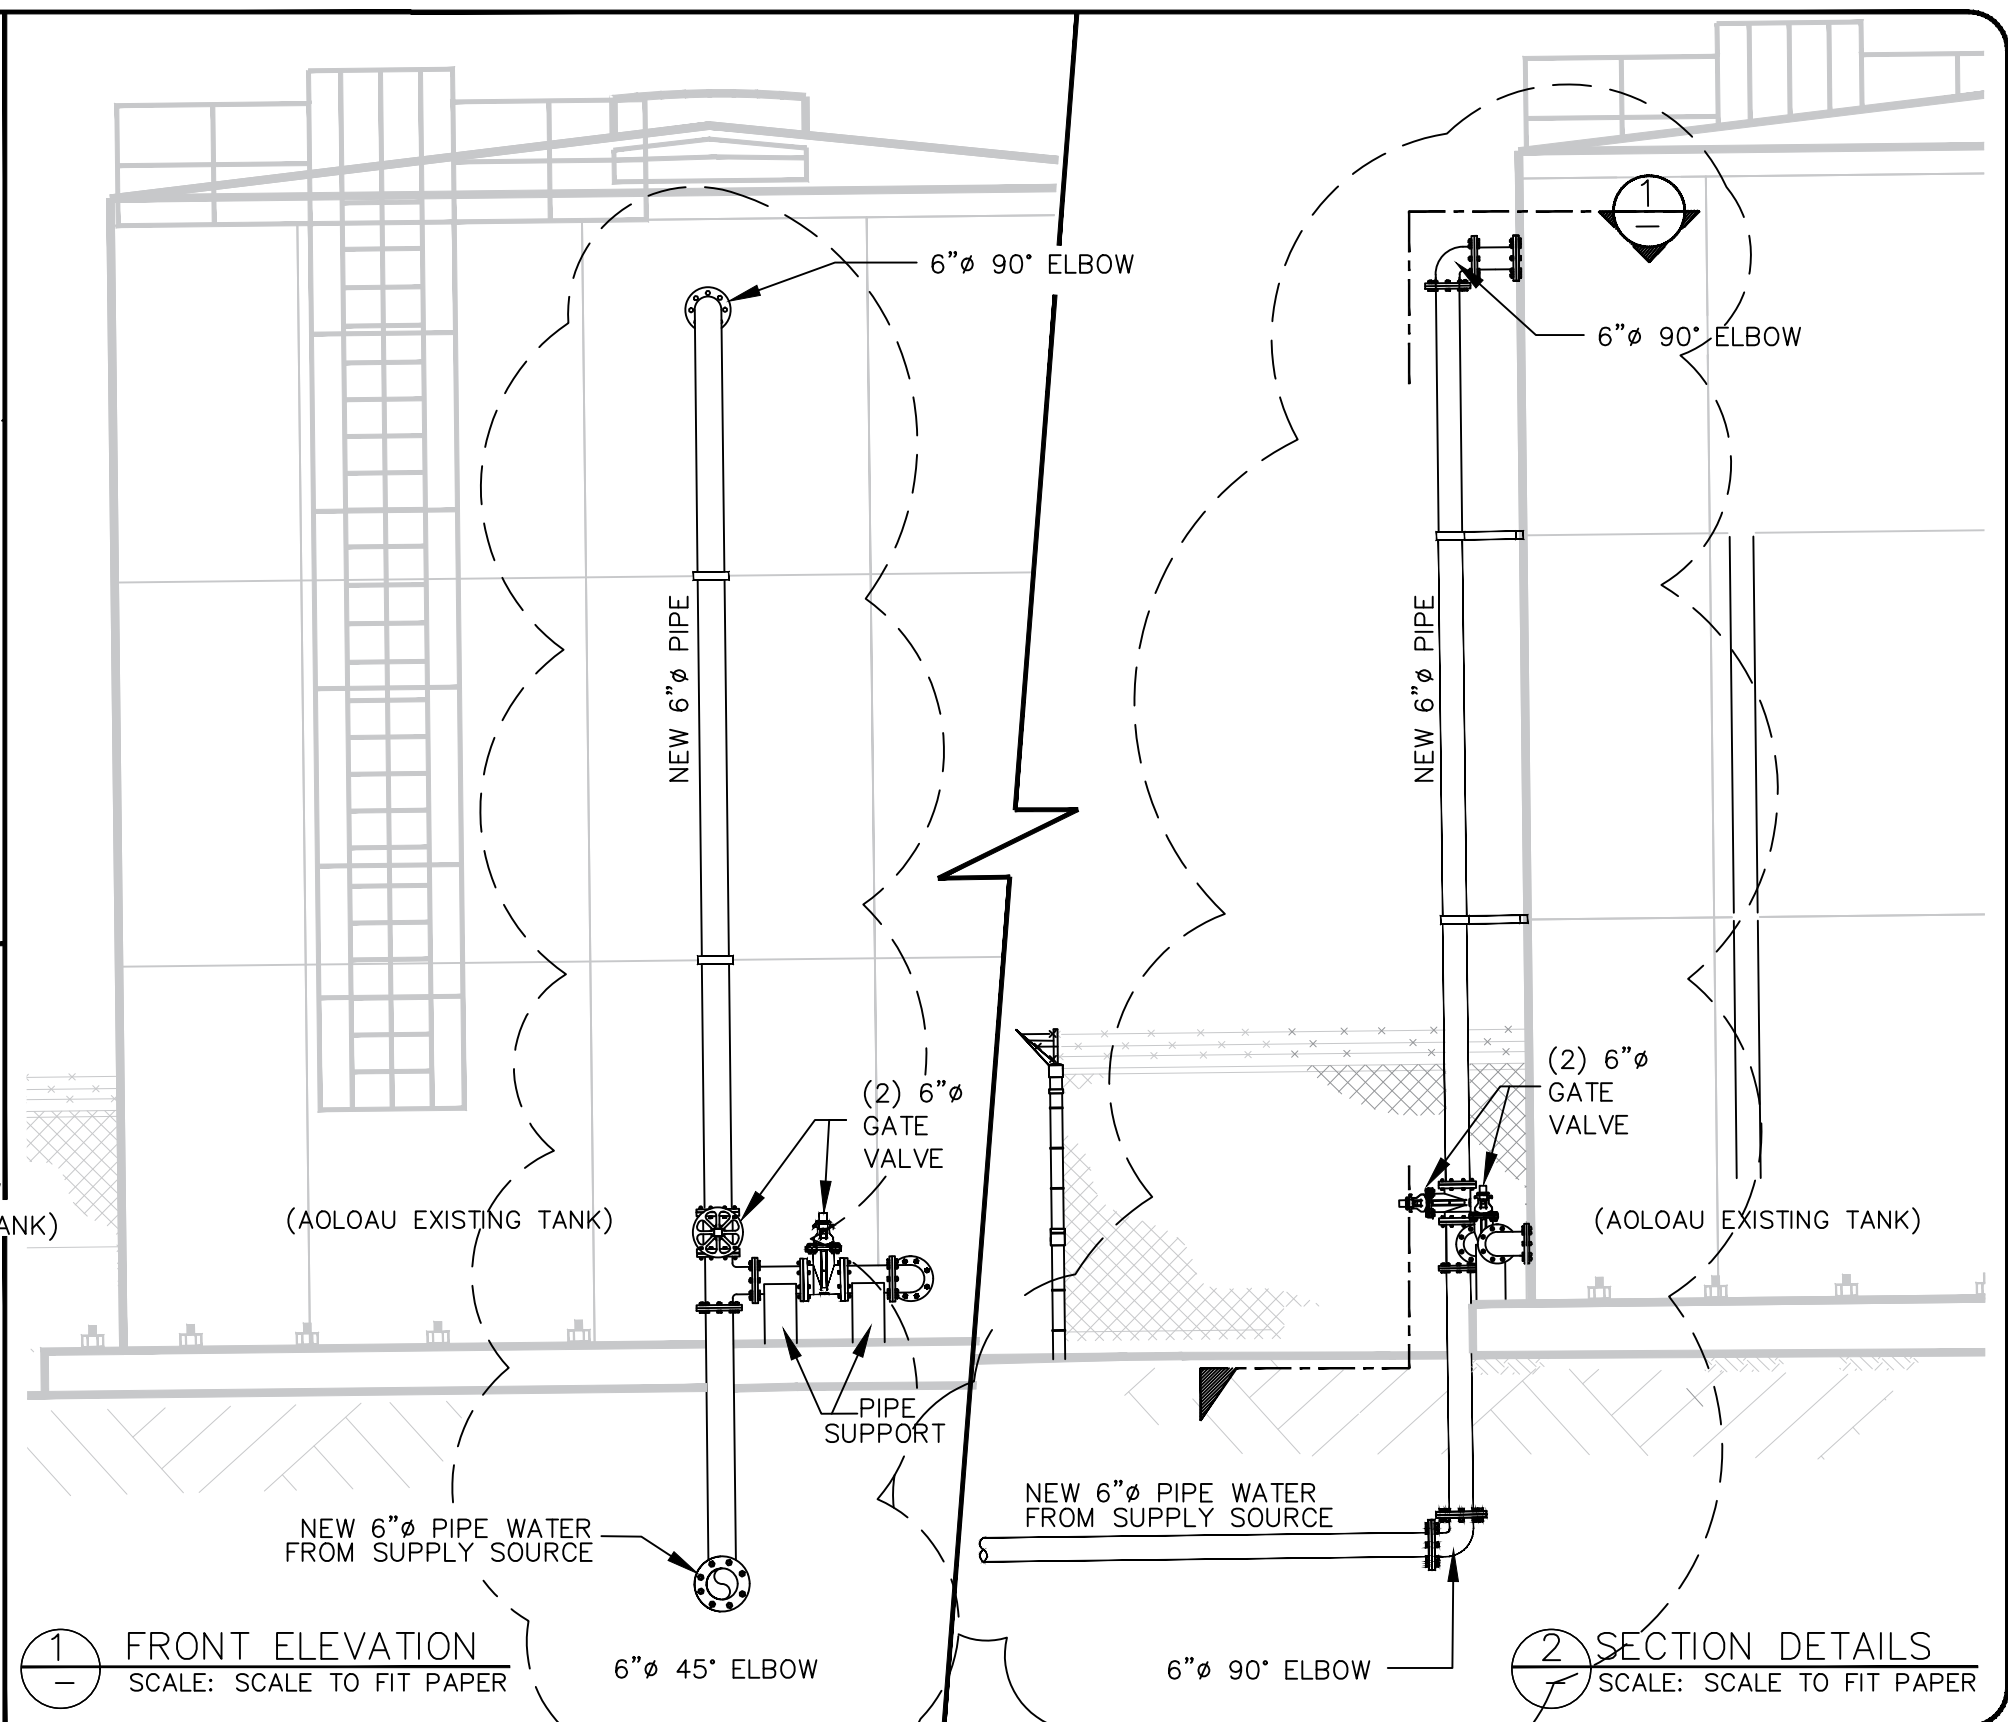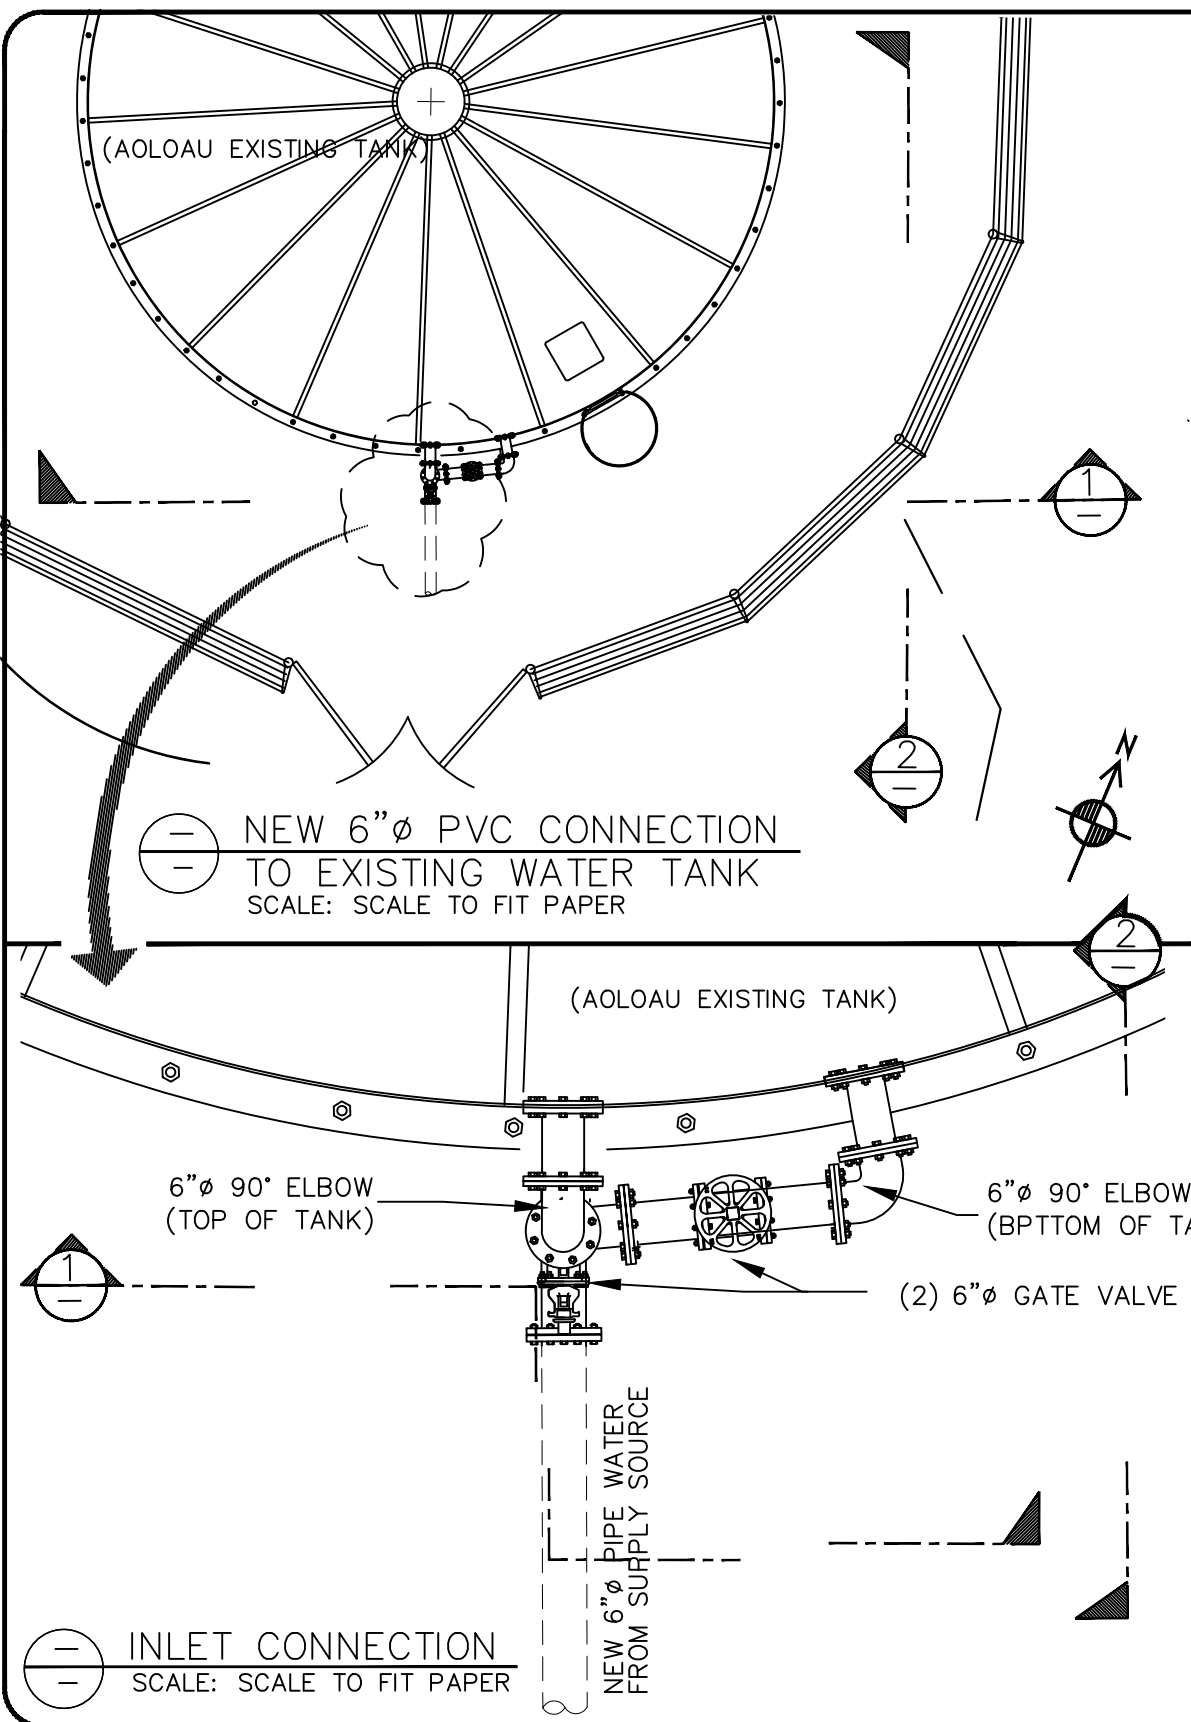

No.	Description	Date	REV. NO.:	PREPARED BY:
				FToala
			REVISION:	CHECKED BY:
				LTyrell
			CHECKED BY:	APPROVED BY:
				FAguila / LTyrell
			APPROVED BY:	ISSUE FOR:
				Construction
			DATE:	



AMERICAN SAMOA POWER AUTHORITY

AMERICAN SAMOA POWER AUTHORITY
ENGINEERING SERVICES DIVISION

P.O.BOX PPB, TAFUNA, PAGO PAGO, AS 96799

PROJECT NAME:
AOLOAU 6"Ø WATERLINE REPLACEMENT PROJECT

DRAWING TITLE:
NEW 6"Ø PVC LINE TO EXISTING TANK PIPE CONNECTION
(@ STA. 9+20)

PROJECT LOCATION:
AOLOAU VILLAGE, AMERICAN SAMOA

SCALE:
AS SHOWN

PROJECT NO:
1958785

DATE:
JULY 2024

SIGNATURE:

DATE:

SHEET NO.
D11

EROSION AND TEMPORARY DUST CONTROL




- 1. DURING CONSTRUCTION, PREVENTIVE MAINTENANCE MEASURES SHALL BE USED TO CONTROL FORESEEABLE DUST, EROSION OR SEDIMENTATION PROBLEMS WHICH MAY ARISE AS THE JOB PROGRESSES.
- 2. FUGITIVE DUST AND SOLID WASTE DISPOSAL DURING GRUBBING ACTIVITIES SHALL MEET REQUIREMENTS OF ADMINISTRATIVE RULES, TITLE II, CHAPTER 60, AIR POLLUTION CONTROL AND CHAPTER 58, SOLID WASTE MANAGEMENT CONTROL.
- 3. THE CONTRACTOR AT HIS OWN EXPENSE, SHALL KEEP THE PROJECT AREA AND SURROUNDING AREA FREE FROM DUST NUISANCE. THE WORK SHALL BE IN CONFORMANCE WITH THE AIR POLLUTION CONTROL STANDARDS AND REGULATIONS OF THE STATE DEPARTMENT OF HEALTH.
- 4. WHERE CONSTRUCTION ACTIVITY ON A PORTION OF THE SITE IS TEMPORARILY CEASED, AND EARTH DISTURBING ACTIVITIES WILL BE RESUMED WITHIN 14 DAYS, TEMPORARILY STABILIZATION MEASURES DO NOT HAVE TO BE INITIATED ON THAT PORTION OF THE SITE. ALL EXPOSED AREAS TO BE LEFT EXPOSED FOR LONGER THAN FOURTEEN (14) DAYS SHALL BE HYDROMULCH SEEDED WITH RYE GRASS.
- 5. ALL SLOPES AND EXPOSED AREAS SHALL BE SODDED OR PLANTED AS SOON AS FINAL GRADES HAVE BEEN ESTABLISHED. PLANTING SHALL NOT BE DELAYED UNTIL ALL GRADING WORKS HAS BEEN COMPLETED. GRADING TO FINAL GRADE SHALL BE CONTINUOUS, AND ANY AREA WITHIN WHICH WORK HAS BEEN INTERRUPTED OR DELAYED SHALL BE PLANTED.

BEST MANAGEMENT PRACTICE NOTES

- 1. MEASURES TO CONTROL EROSION AND OTHER POLLUTANTS SHALL BE IN PLACE BEFORE ANY WORK IS INITIATED. THESE MEASURES SHALL BE PROPERLY CONSTRUCTED AND MAINTAINED THROUGHOUT THE CONSTRUCTION PERIOD.
- 2. ALL TEMPORARY EROSION CONTROL MEASURES SHALL BE CHECKED AND REPAIRED AS NECESSARY.
- 3. GRASSING OR MULCHING OF EXPOSED AREAS TO BE DONE AS FINISH GRADES ARE ESTABLISHED.
- 4. DIVERSION OF STORM RUNOFF AWAY FROM THE FILL SLOPES UNTIL GRASSING ON THE FILL SLOPES ARE ESTABLISHED.
- 5. PROVIDE STABILIZED CONSTRUCTION ENTRANCE.

NOTES:

- 1. STABILIZED CONSTRUCTION ENTRANCE SHALL BE MAINTAINED AT THE EGRESS AND INGRESS TO THE SITE. TIRE WASH MAY BE USED IN LIEU OF STABILIZED CONSTRUCTION ENTRANCE. CONTRACTOR IS RESPONSIBLE TO KEEP ROADWAYS CLEAN FROM SOIL AND CONSTRUCTION DEBRIS.
- 2. DUST CONTROL SHOULD BE APPLIED TO REDUCE DUST EMISSIONS. WATER THE AREA DURING CONSTRUCTION TO CONTROL DUST.
- 3. ALL STORM DRAIN INLETS ON SITE AND THOSE OFF SITE WHICH MAY RECEIVE RUN OFF FROM THE SITE SHALL USE AN INLET PROTECTION DEVICE.

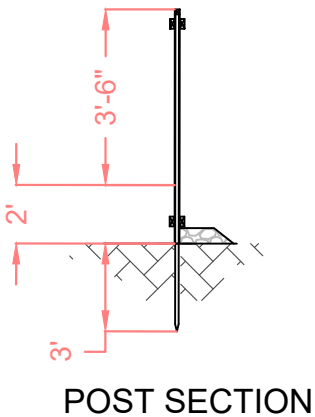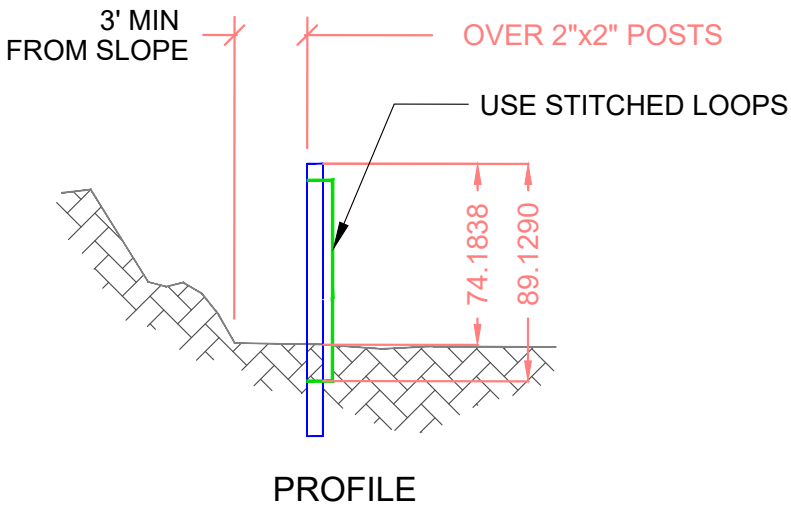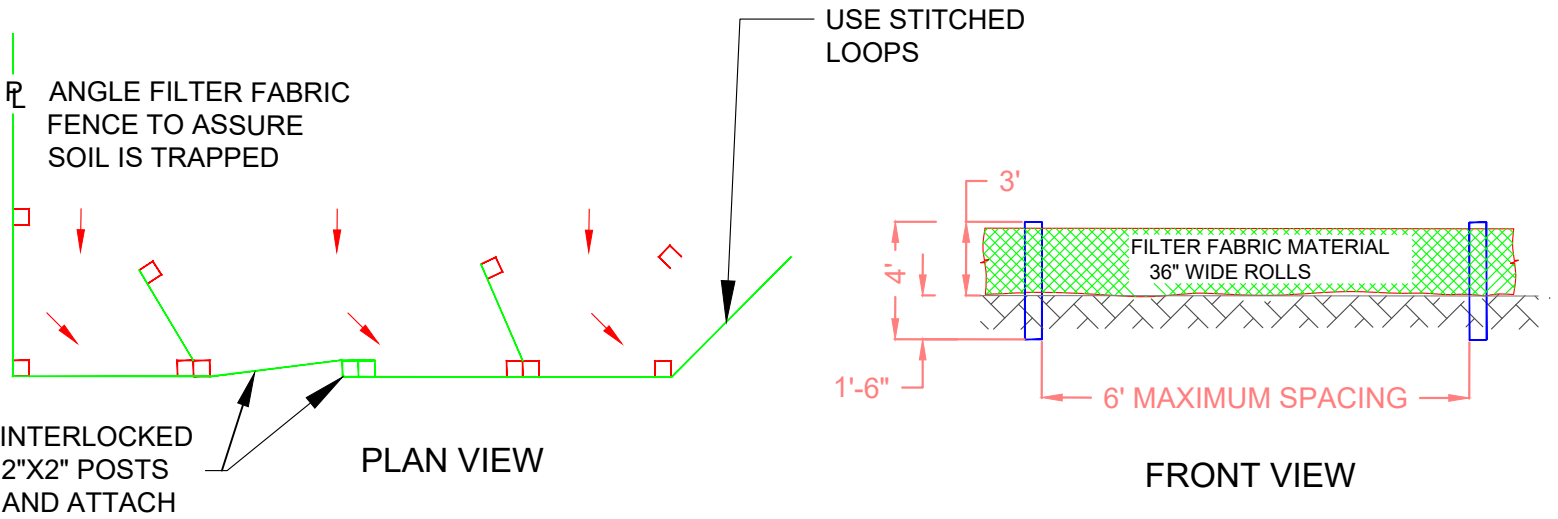

- NOTES:
- 1. BURY BOTTOM OF FILTER FABRIC 6" VERTICALLY BELOW FINISHED GRADE.
 - 2. 2"x2" FIR, PINE OR STEEL FENCE POSTS.
 - 3. POSTS TO BE INSTALLED ON UPHILL SIDE OF SLOPE.
 - 4. COMPACT BOTH SIDES OF FILTER FABRIC TRENCH.
 - 5. PANELS MUST BE PLACED ACCORDING TO SPACING ON DETAIL NO.940

No.	Description	Date

REV. NO.:	PREPARED BY: FToala
REVISION:	CHECKED BY: LTyrell
CHECKED BY:	APPROVED BY: FAguila / LTyrell
APPROVED BY:	ISSUE FOR: Construction
DATE:	




AMERICAN SAMOA POWER AUTHORITY
ENGINEERING SERVICES DIVISION
P.O.BOX PPB, TAFUNA, PAGO PAGO, AS 96799


PROJECT NAME:	AOLOAU WATERLINE REPLACEMENT PROJECT	
DRAWING TITLE:	EROSION AND SEDIMENTATION CONTROL	
DRAWING DETAILS:	GENERAL NOTES	PROTECTIVE FABRIC DETAILS
PROJECT LOCATION:	AOLOAU VILLAGE, AMERICAN SAMOA	

SCALE:	AS SHOWN
PROJECT NO:	1972803
DATE:	APRIL 2023


SIGNATURE:	
DATE:	
SHEET NO.	ESC0

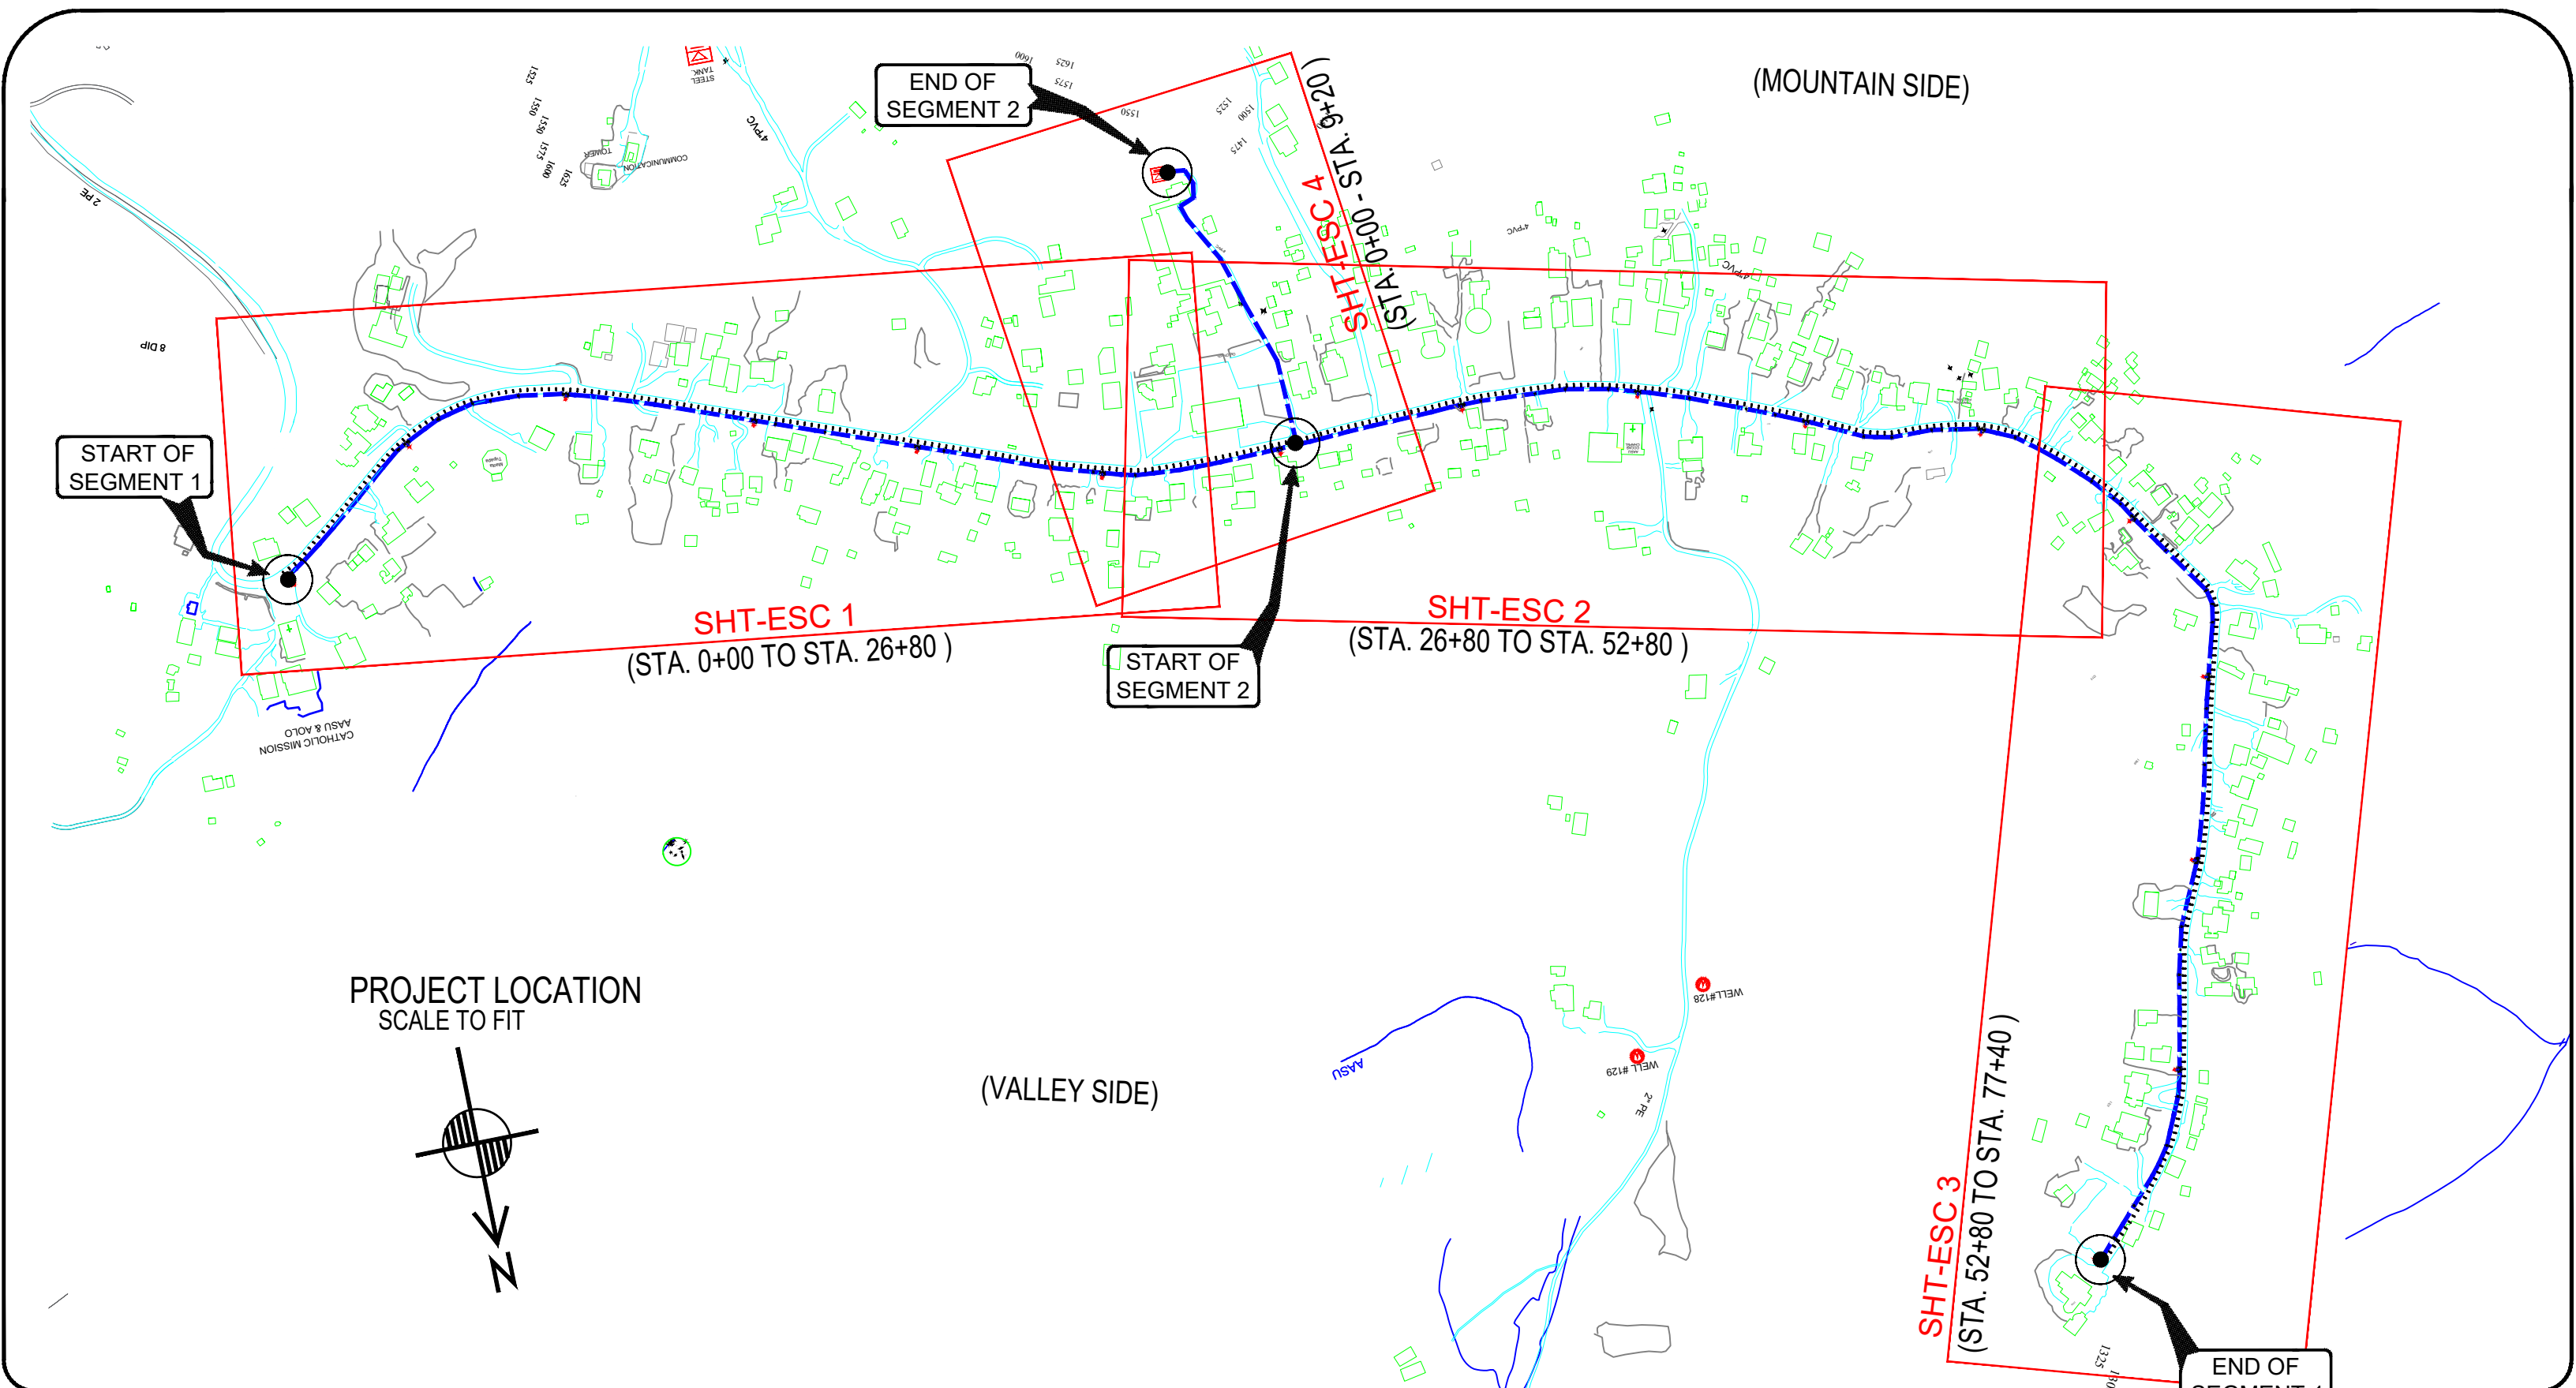


No. Description Date			REV. NO.:	PREPARED BY:	ASPA AMERICAN SAMOA POWER AUTHORITY ENGINEERING SERVICES DIVISION P.O.BOX PPB, TAFUNA, PAGO PAGO, AS 96799 AMERICAN SAMOA POWER AUTHORITY	PROJECT NAME:	AOLOAU WATERLINE REPLACEMENT PROJECT		SCALE:	SIGNATURE:
			REVISION:	CHECKED BY:		DRAWING TITLE:	EROSION AND SEDIMENTATION CONTROL		AS SHOWN	DATE:
			CHECKED BY:	APPROVED BY:		DRAWING DETAILS:	VICINITY MAP	SHEETS LOCATIONS	PROJECT NO:	
			APPROVED BY:	ISSUE FOR:		PROJECT LOCATION:	AOLOAU VILLAGE, AMERICAN SAMOA		1972803	SHEET NO.
			DATE:	Construction					DATE:	ESC1
									APRIL 2023	

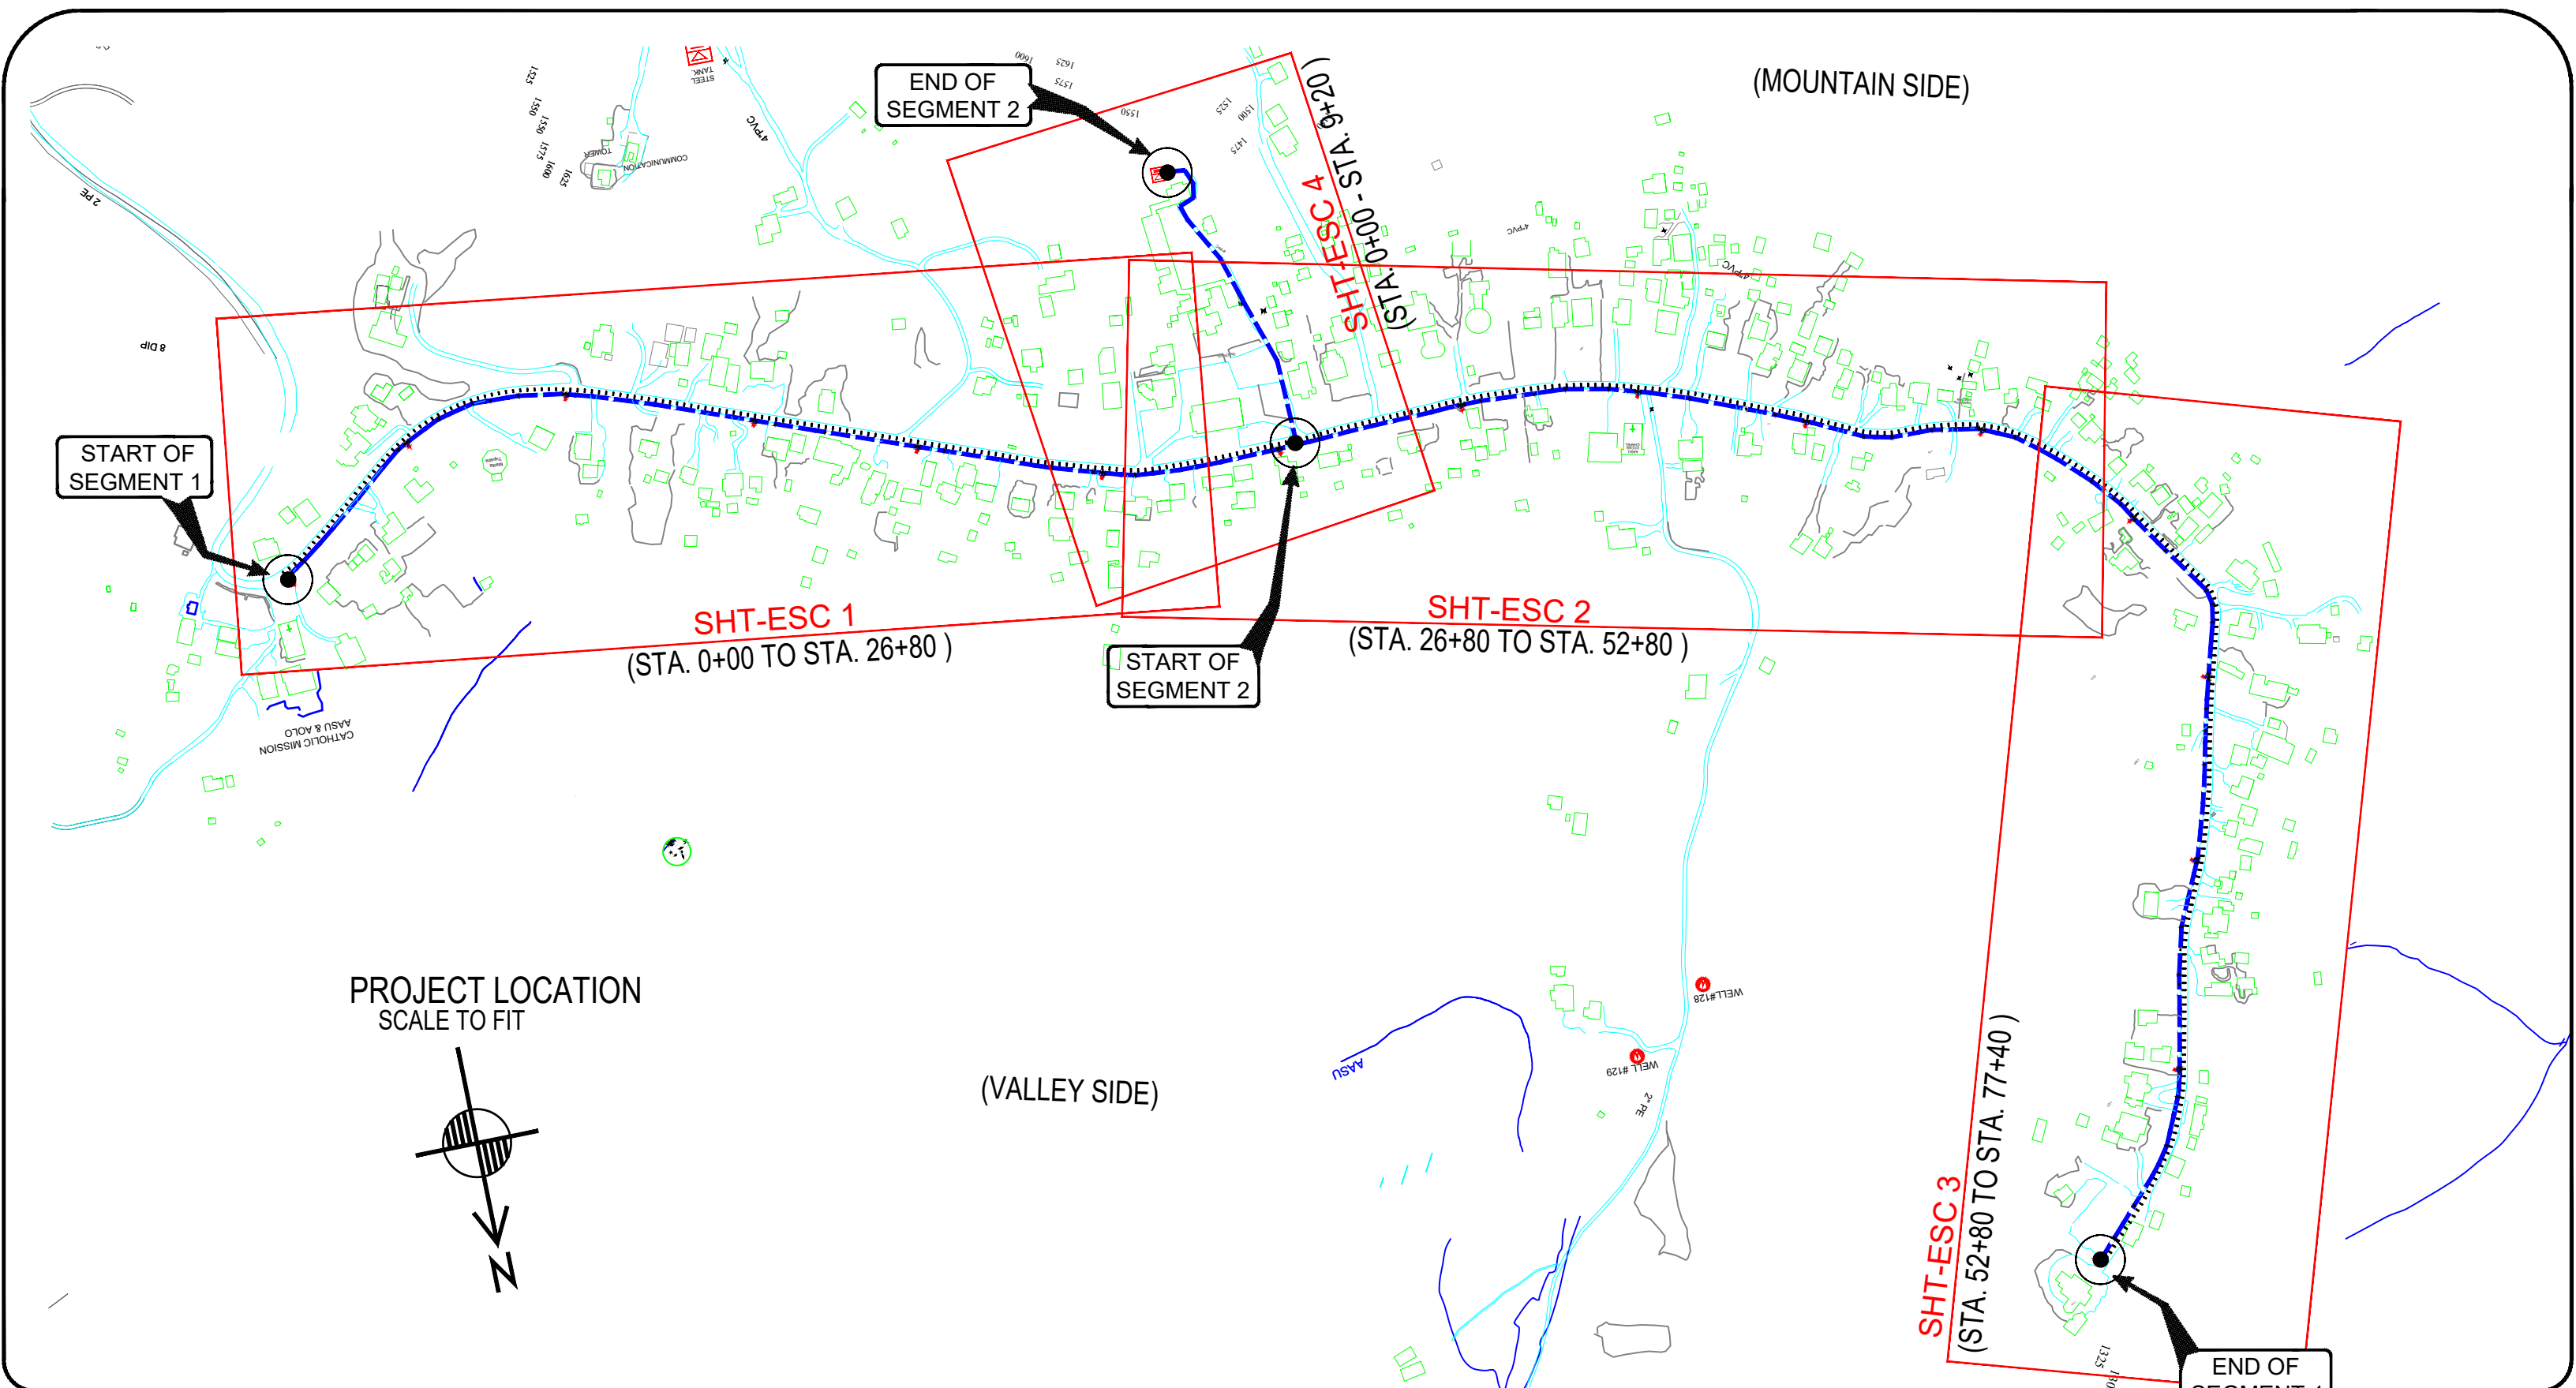

<table><tr><td>No.</td><td>Description</td><td>Date</td></tr><tr><td> </td><td> </td><td> </td></tr><tr><td> </td><td> </td><td> </td></tr><tr><td> </td><td> </td><td> </td></tr><tr><td> </td><td> </td><td> </td></tr><tr><td> </td><td> </td><td> </td></tr><tr><td> </td><td> </td><td> </td></tr><tr><td> </td><td> </td><td> </td></tr><tr><td> </td><td> </td><td> </td></tr><tr><td> </td><td> </td><td> </td></tr><tr><td> </td><td> </td><td> </td></tr><tr><td> </td><td> </td><td> </td></tr></table>			No.	Description	Date																																		<table><tr><td>REV. NO.:</td><td>PREPARED BY:</td></tr><tr><td> </td><td>FToala</td></tr><tr><td>REVISION:</td><td>CHECKED BY:</td></tr><tr><td> </td><td>LTyrell</td></tr><tr><td>CHECKED BY:</td><td>APPROVED BY:</td></tr><tr><td> </td><td>FAguila / LTyrell</td></tr><tr><td>APPROVED BY:</td><td>ISSUE FOR:</td></tr><tr><td> </td><td>Construction</td></tr><tr><td>DATE:</td><td> </td></tr></table>	REV. NO.:	PREPARED BY:		FToala	REVISION:	CHECKED BY:		LTyrell	CHECKED BY:	APPROVED BY:		FAguila / LTyrell	APPROVED BY:	ISSUE FOR:		Construction	DATE:		 AMERICAN SAMOA POWER AUTHORITY ENGINEERING SERVICES DIVISION P.O.BOX PPB, TAFUNA, PAGO PAGO, AS 96799	<table><tr><td colspan="2">PROJECT NAME: AOLOAU WATERLINE REPLACEMENT PROJECT</td><td rowspan="2">SCALE: AS SHOWN</td><td rowspan="2">SIGNATURE: DATE:</td></tr><tr><td colspan="2">DRAWING TITLE: EROSION AND SEDIMENTATION CONTROL</td></tr><tr><td colspan="2">DRAWING DETAILS: VICINITY MAP SHEETS LOCATIONS</td><td>PROJECT NO: 1972803</td><td rowspan="2">SHEET NO. ESC1</td></tr><tr><td colspan="2">PROJECT LOCATION: AOLOAU VILLAGE, AMERICAN SAMOA</td><td>DATE: APRIL 2023</td></tr></table>	PROJECT NAME: AOLOAU WATERLINE REPLACEMENT PROJECT		SCALE: AS SHOWN	SIGNATURE: DATE:	DRAWING TITLE: EROSION AND SEDIMENTATION CONTROL		DRAWING DETAILS: VICINITY MAP SHEETS LOCATIONS		PROJECT NO: 1972803	SHEET NO. ESC1	PROJECT LOCATION: AOLOAU VILLAGE, AMERICAN SAMOA		DATE: APRIL 2023
No.	Description	Date																																																																						
REV. NO.:	PREPARED BY:																																																																							
	FToala																																																																							
REVISION:	CHECKED BY:																																																																							
	LTyrell																																																																							
CHECKED BY:	APPROVED BY:																																																																							
	FAguila / LTyrell																																																																							
APPROVED BY:	ISSUE FOR:																																																																							
	Construction																																																																							
DATE:																																																																								
PROJECT NAME: AOLOAU WATERLINE REPLACEMENT PROJECT		SCALE: AS SHOWN	SIGNATURE: DATE:																																																																					
DRAWING TITLE: EROSION AND SEDIMENTATION CONTROL																																																																								
DRAWING DETAILS: VICINITY MAP SHEETS LOCATIONS		PROJECT NO: 1972803	SHEET NO. ESC1																																																																					
PROJECT LOCATION: AOLOAU VILLAGE, AMERICAN SAMOA		DATE: APRIL 2023																																																																						


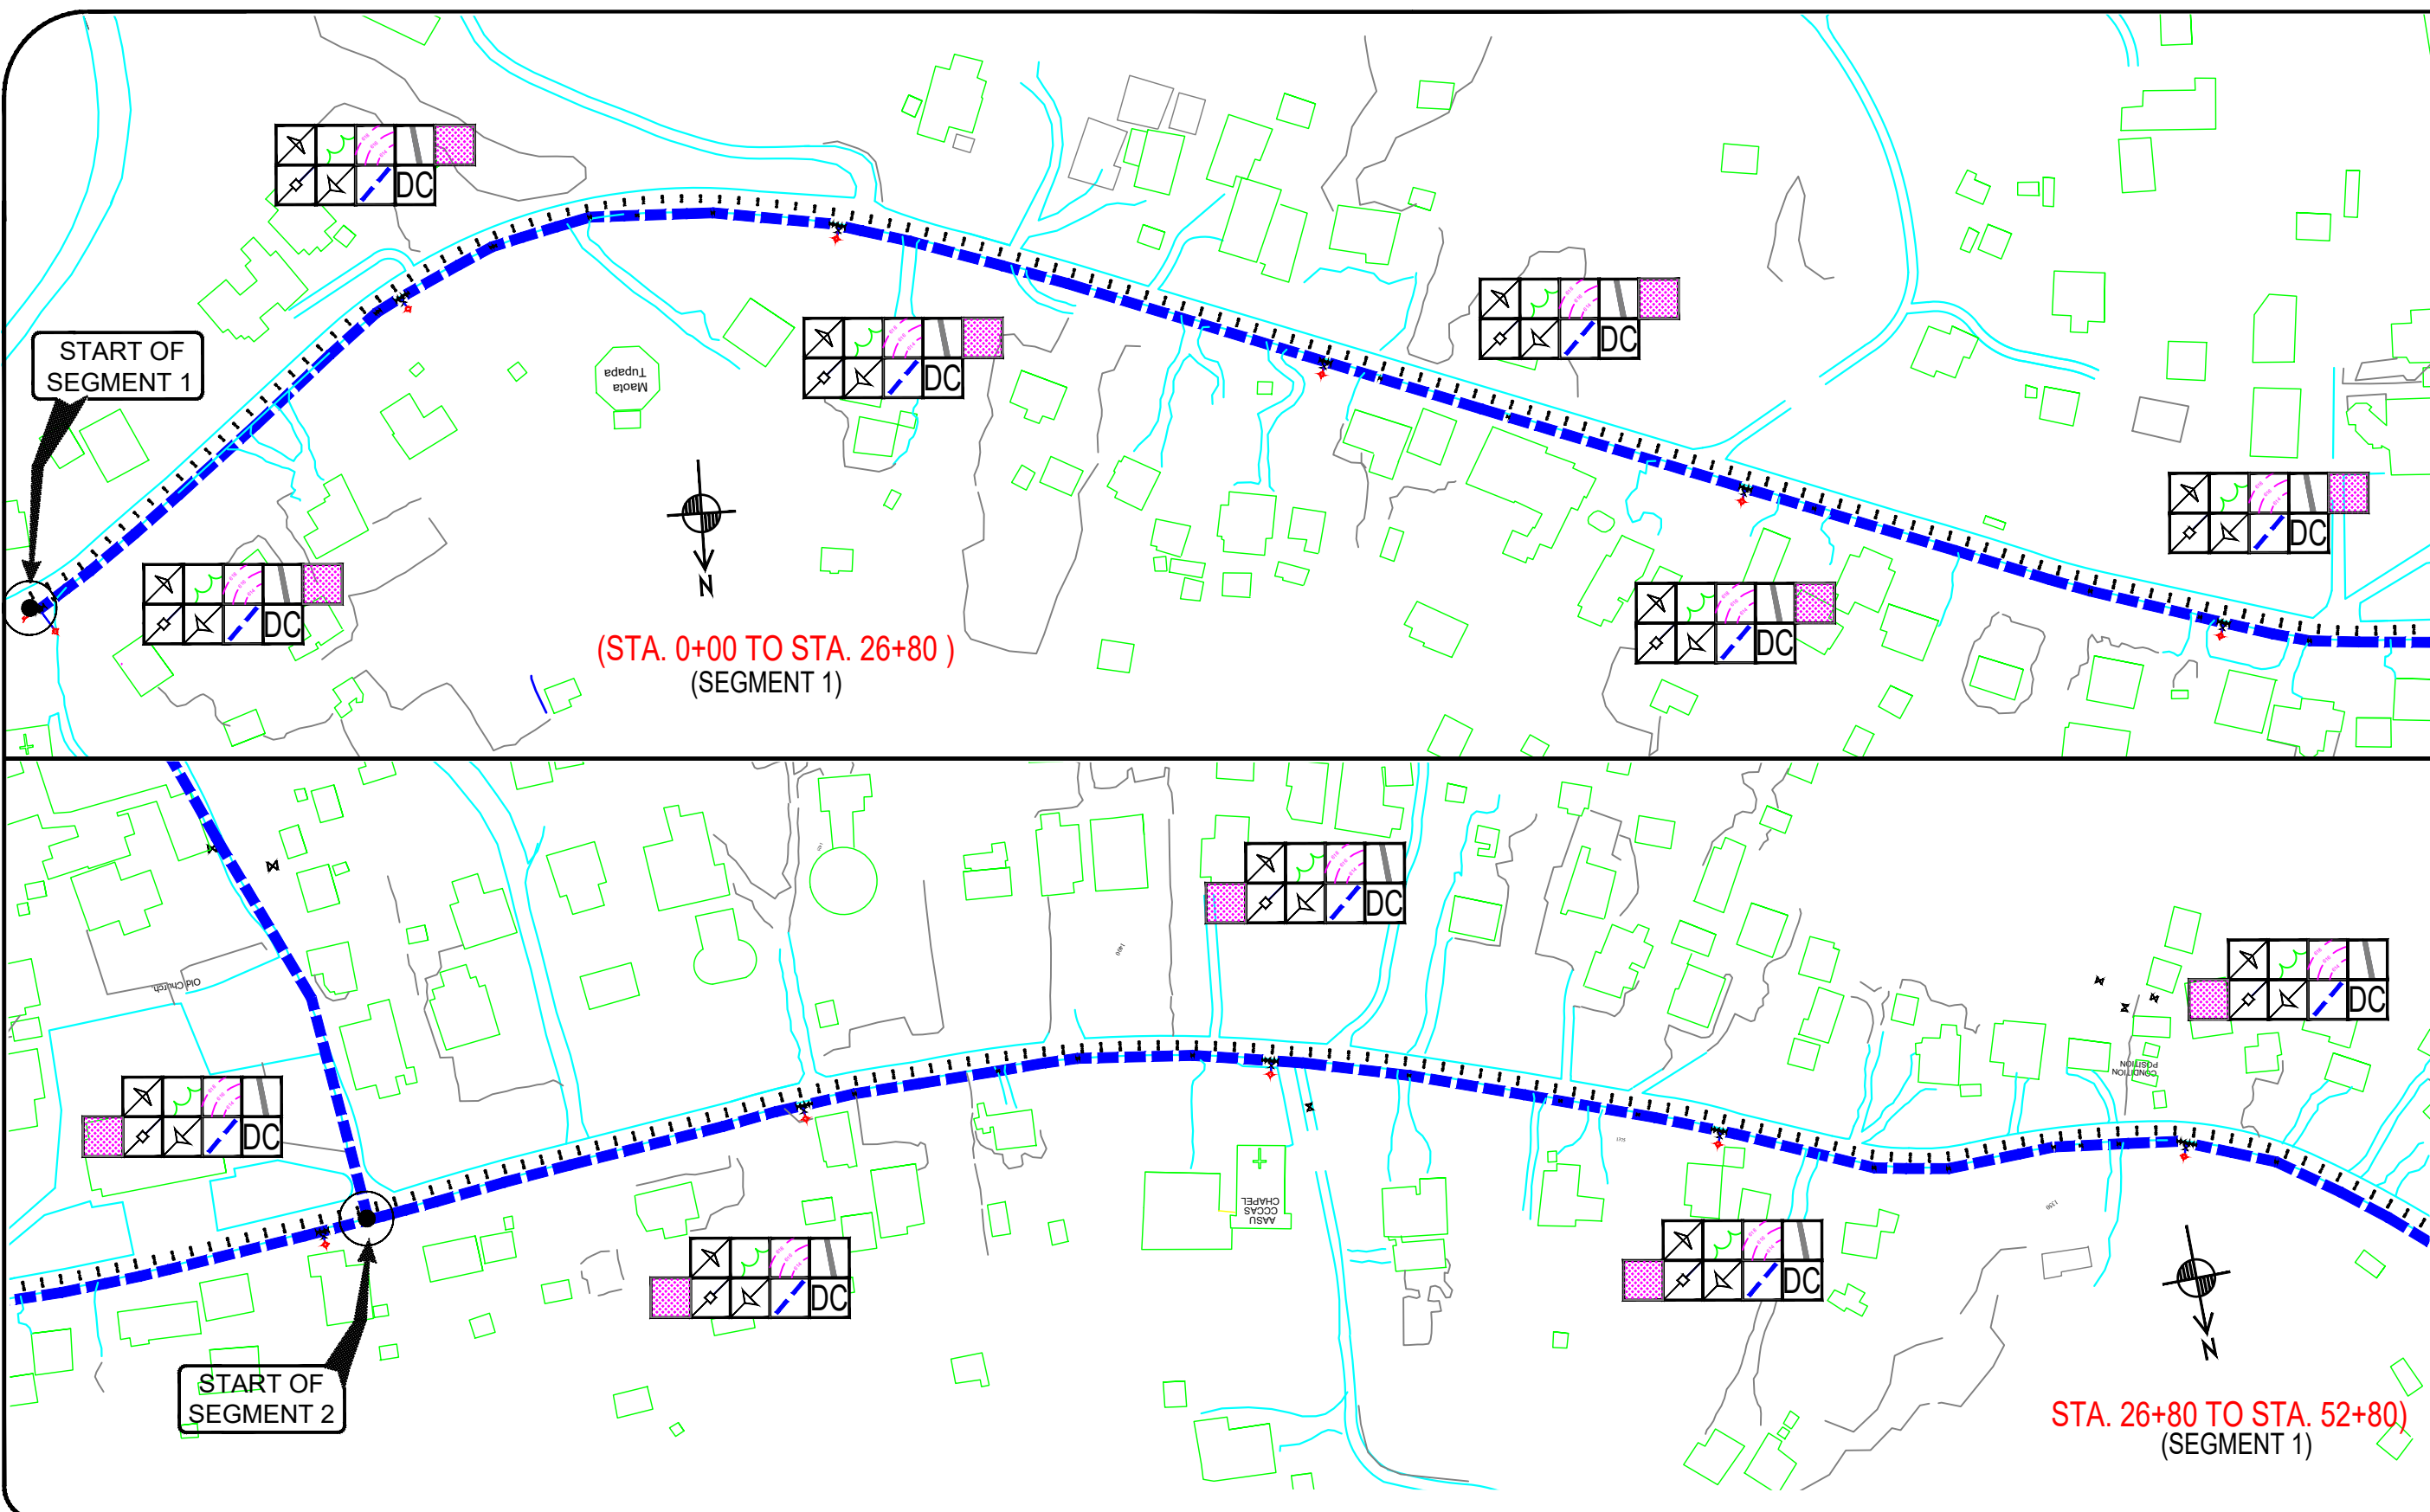


<table><tr><td>No.</td><td>Description</td><td>Date</td></tr><tr><td> </td><td> </td><td> </td></tr><tr><td> </td><td> </td><td> </td></tr><tr><td> </td><td> </td><td> </td></tr><tr><td> </td><td> </td><td> </td></tr><tr><td> </td><td> </td><td> </td></tr><tr><td> </td><td> </td><td> </td></tr><tr><td> </td><td> </td><td> </td></tr><tr><td> </td><td> </td><td> </td></tr><tr><td> </td><td> </td><td> </td></tr></table>			No.	Description	Date																												<table><tr><td>REV. NO.:</td><td>PREPARED BY:</td></tr><tr><td> </td><td>FToala</td></tr><tr><td>REVISION:</td><td>CHECKED BY:</td></tr><tr><td> </td><td>LTyrell</td></tr><tr><td>CHECKED BY:</td><td>APPROVED BY:</td></tr><tr><td> </td><td>FAguila / LTyrell</td></tr><tr><td>APPROVED BY:</td><td>ISSUE FOR:</td></tr><tr><td> </td><td>Construction</td></tr><tr><td>DATE:</td><td> </td></tr></table>		REV. NO.:	PREPARED BY:		FToala	REVISION:	CHECKED BY:		LTyrell	CHECKED BY:	APPROVED BY:		FAguila / LTyrell	APPROVED BY:	ISSUE FOR:		Construction	DATE:		 AMERICAN SAMOA POWER AUTHORITY ENGINEERING SERVICES DIVISION P.O.BOX PPB, TAFUNA, PAGO PAGO, AS 96799		<table><tr><td colspan="2">PROJECT NAME:</td></tr><tr><td colspan="2">AOLOAU WATERLINE REPLACEMENT PROJECT</td></tr><tr><td colspan="2">DRAWING TITLE:</td></tr><tr><td colspan="2">EROSION AND SEDIMENTATION CONTROL</td></tr><tr><td>DRAWING DETAILS:</td><td> </td></tr><tr><td>(STA. 0+00 TO STA. 26+80)</td><td>(STA. 26+80 TO STA. 52+80)</td></tr><tr><td colspan="2">PROJECT LOCATION:</td></tr><tr><td colspan="2">AOLOAU VILLAGE, AMERICAN SAMOA</td></tr></table>		PROJECT NAME:		AOLOAU WATERLINE REPLACEMENT PROJECT		DRAWING TITLE:		EROSION AND SEDIMENTATION CONTROL		DRAWING DETAILS:		(STA. 0+00 TO STA. 26+80)	(STA. 26+80 TO STA. 52+80)	PROJECT LOCATION:		AOLOAU VILLAGE, AMERICAN SAMOA		<table><tr><td>SCALE:</td><td>SIGNATURE:</td></tr><tr><td>AS SHOWN</td><td> </td></tr><tr><td>PROJECT NO:</td><td>DATE:</td></tr><tr><td>1972803</td><td> </td></tr><tr><td>DATE:</td><td>SHEET NO.</td></tr><tr><td>APRIL 2023</td><td>ESC2</td></tr></table>		SCALE:	SIGNATURE:	AS SHOWN		PROJECT NO:	DATE:	1972803		DATE:	SHEET NO.	APRIL 2023	ESC2
No.	Description	Date																																																																																				
REV. NO.:	PREPARED BY:																																																																																					
	FToala																																																																																					
REVISION:	CHECKED BY:																																																																																					
	LTyrell																																																																																					
CHECKED BY:	APPROVED BY:																																																																																					
	FAguila / LTyrell																																																																																					
APPROVED BY:	ISSUE FOR:																																																																																					
	Construction																																																																																					
DATE:																																																																																						
PROJECT NAME:																																																																																						
AOLOAU WATERLINE REPLACEMENT PROJECT																																																																																						
DRAWING TITLE:																																																																																						
EROSION AND SEDIMENTATION CONTROL																																																																																						
DRAWING DETAILS:																																																																																						
(STA. 0+00 TO STA. 26+80)	(STA. 26+80 TO STA. 52+80)																																																																																					
PROJECT LOCATION:																																																																																						
AOLOAU VILLAGE, AMERICAN SAMOA																																																																																						
SCALE:	SIGNATURE:																																																																																					
AS SHOWN																																																																																						
PROJECT NO:	DATE:																																																																																					
1972803																																																																																						
DATE:	SHEET NO.																																																																																					
APRIL 2023	ESC2																																																																																					

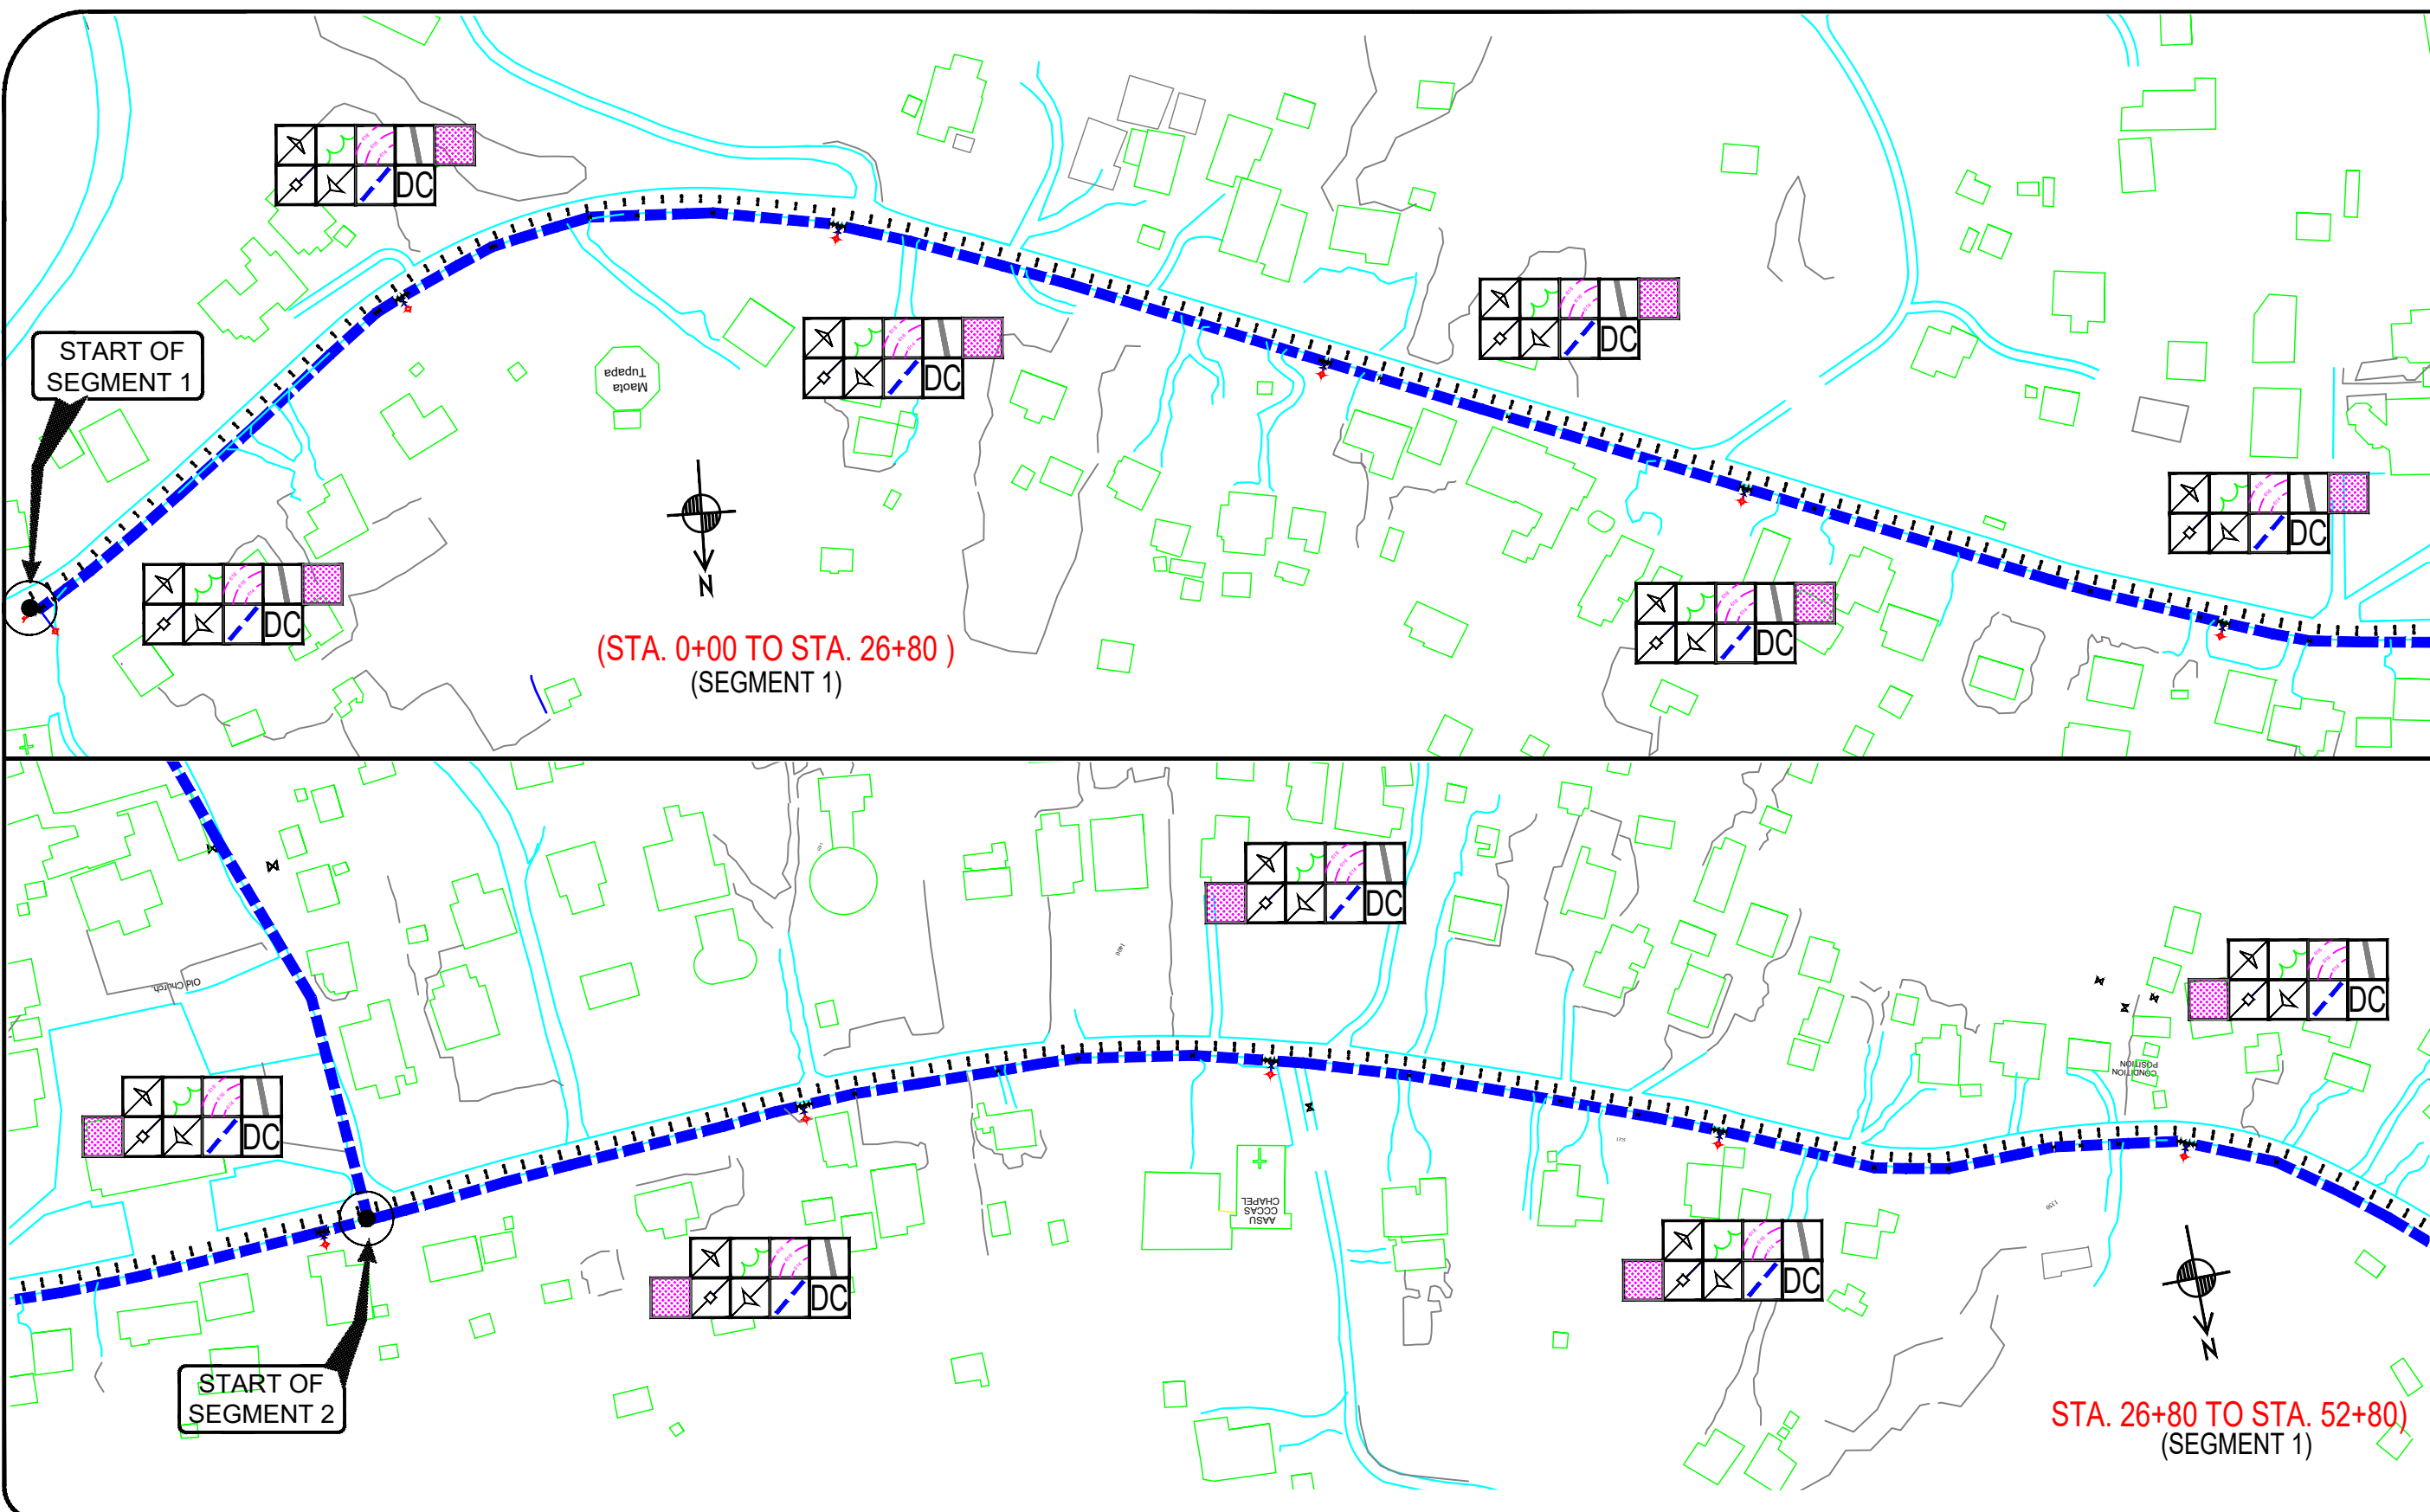



	CONSTRUCTION ENTRANCE	(CE)
	SILT FENCE	(SF)
	DIVERSION DIKE	(DD)
	RIGHT-OF-WAY DIVERSION	(RWD)
	TEMPORARY LEVEL SPREADER	(LS)
	TEMPORARY LEVEL DIVERSION	(LD)
	TEMPORARY FILL DIVERSION	(TFD)
	INLET PROTECTION	(IP)
	EC-2 MATTING	(B/M)
	EC-3 MATTING	(B/M)
	EXISTING TREELINE	
	EXISTING WATERS	
	EXISTING 100' STREAM BUFFER	
	PROPOSED TREELINE	
	PROPOSED GRADING	
	SEDIMENT BASIN DRAINAGE AREA	
	PEA GRAVEL LEVEL SPREADER	
	PEA GRAVEL LEVEL SPREADER	
	LIMIT OF DISTURBANCE	
	NOTE: DUST CONTROL MEASURES ARE TO BE USED ONSITE AS NECESSARY THROUGHOUT THE CONSTRUCTION ACTIVITY	

<table><tr><td>No.</td><td>Description</td><td>Date</td></tr><tr><td></td><td></td><td></td></tr><tr><td></td><td></td><td></td></tr><tr><td></td><td></td><td></td></tr><tr><td></td><td></td><td></td></tr><tr><td></td><td></td><td></td></tr></table>	No.	Description	Date																REV. NO.:	PREPARED BY:	A S P A  AMERICAN SAMOA POWER AUTHORITY ENGINEERING SERVICES DIVISION P.O.BOX PPB, TAFUNA, PAGO PAGO, AS 96799 AMERICAN SAMOA POWER AUTHORITY	PROJECT NAME:		SCALE:	SIGNATURE:
	No.	Description	Date																						
		FToala	AOLOAU WATERLINE REPLACEMENT PROJECT		AS SHOWN																				
	REVISION:	CHECKED BY:	DRAWING TITLE:		PROJECT NO:	DATE:																			
		LTyrell	EROSION AND SEDIMENTATION CONTROL		1972803																				
	CHECKED BY:	APPROVED BY:	DRAWING DETAILS:		DATE:	SHEET NO.																			
		FAguila / LTyrell	(STA. 0+00 TO STA. 26+80) (STA. 26+80 TO STA. 52+80)																						
	APPROVED BY:	ISSUE FOR:	PROJECT LOCATION:		APRIL 2023	ESC2																			
		Construction	AOLOAU VILLAGE, AMERICAN SAMOA																						
	DATE:																								
</																									

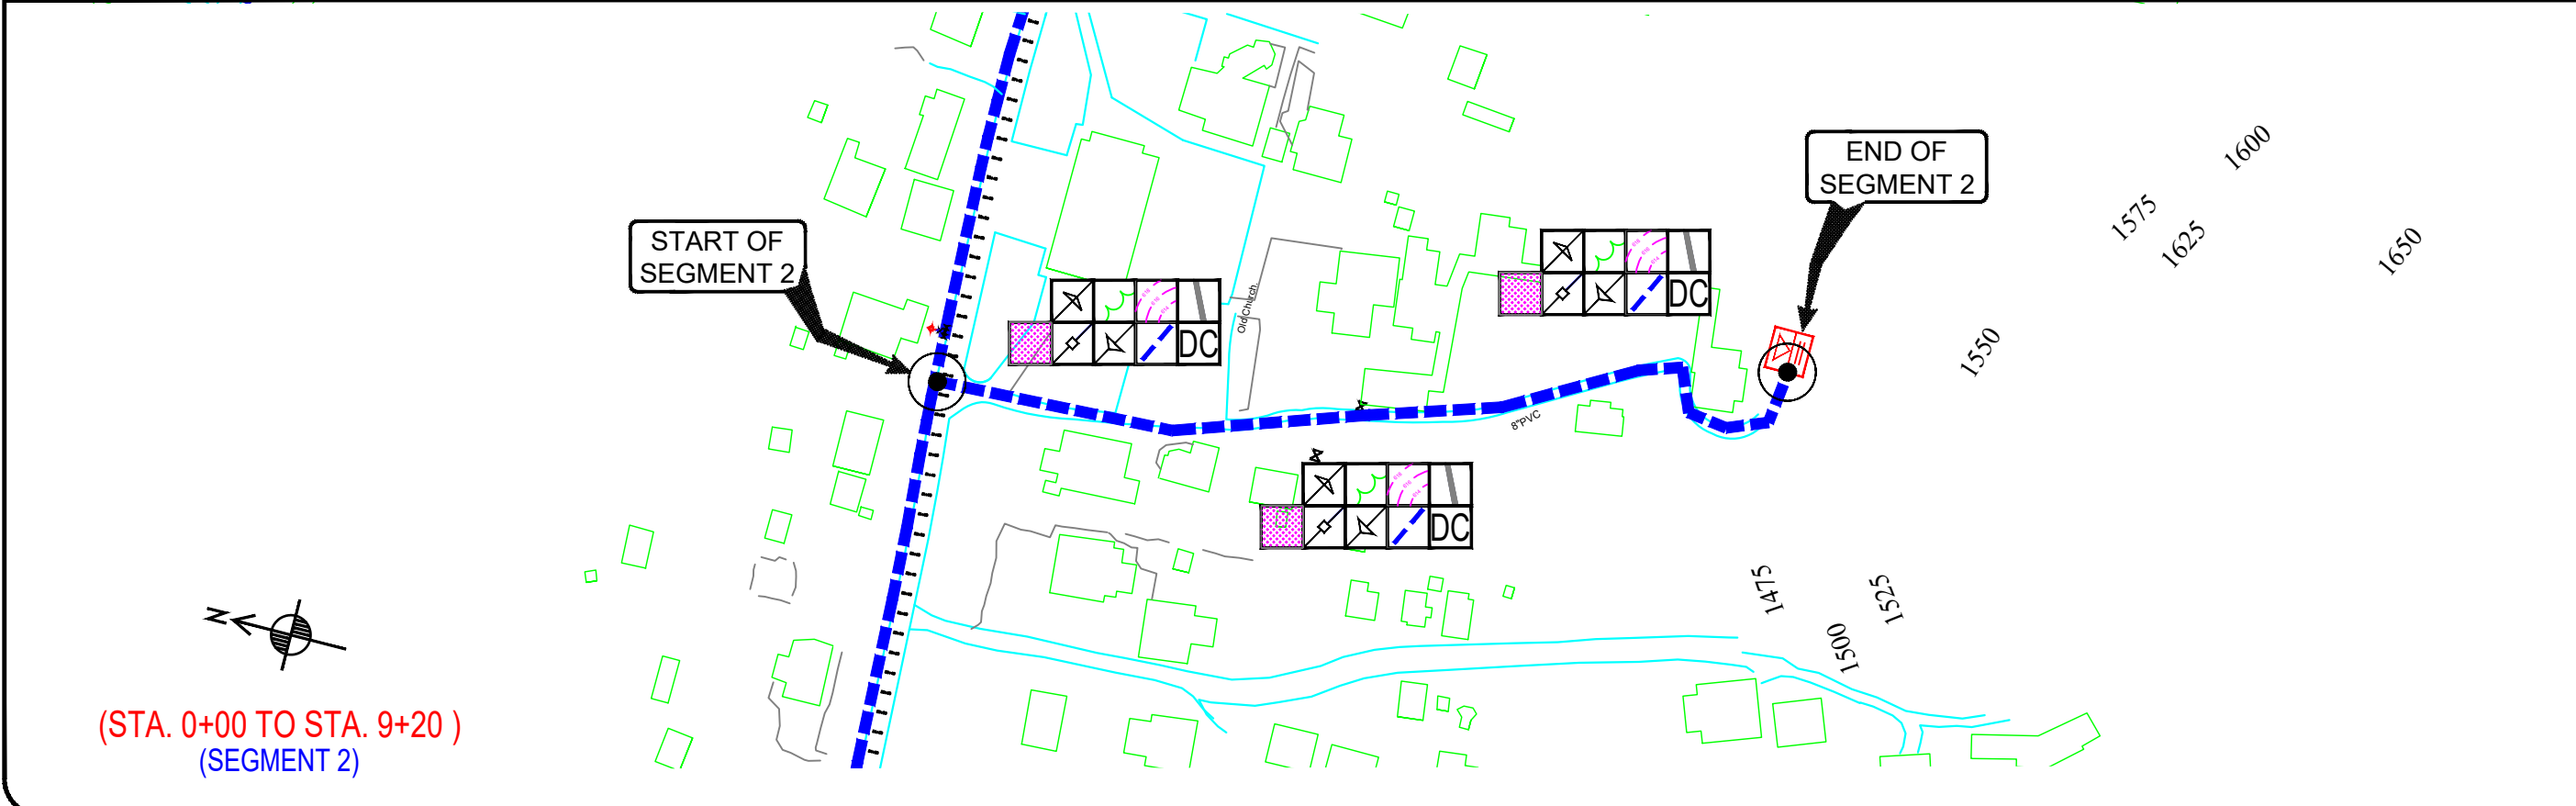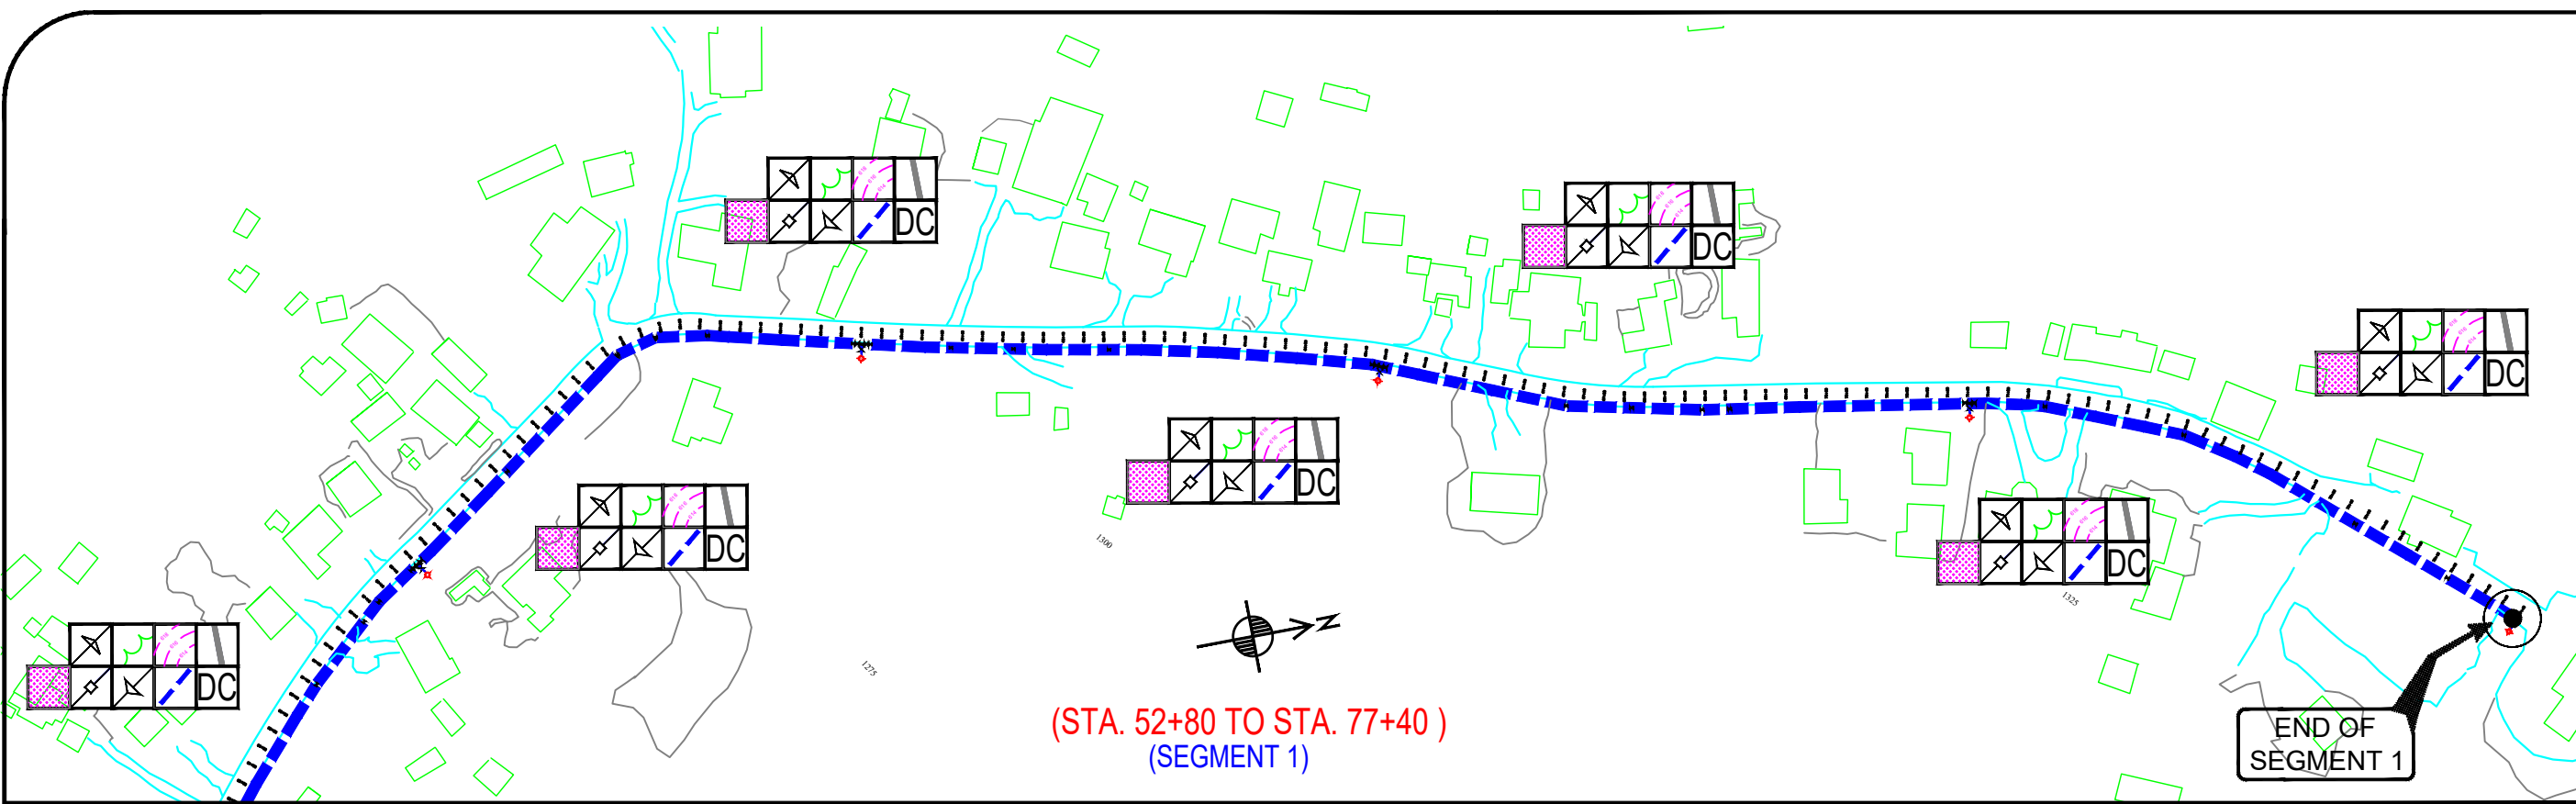

	CONSTRUCTION ENTRANCE	(CE)
	SILT FENCE	(SF)
	DIVERSION DIKE	(DD)
	RIGHT-OF-WAY DIVERSION	(RWD)
	TEMPORARY LEVEL SPREADER	(LS)
	TEMPORARY LEVEL DIVERSION	(LD)
	TEMPORARY FILL DIVERSION	(TFD)
	INLET PROTECTION	(IP)
	EC-2 MATTING	(B/M)
	EC-3 MATTING	(B/M)
	EXISTING TREELINE	
	EXISTING WATERS	
	EXISTING 100' STREAM BUFFER	
	PROPOSED TREELINE	
	PROPOSED GRADING	
	SEDIMENT BASIN DRAINAGE AREA	
	PEA GRAVEL LEVEL SPREADER	
	PEA GRAVEL LEVEL SPREADER	
	LIMIT OF DISTURBANCE	
	NOTE: DUST CONTROL MEASURES ARE TO BE USED ONSITE AS NECESSARY THROUGHOUT THE CONSTRUCTION ACTIVITY	

No.	Description	Date	REV. NO.:	PREPARED BY:	ASPA AMERICAN SAMOA POWER AUTHORITY ENGINEERING SERVICES DIVISION P.O.BOX PPB, TAFUNA, PAGO PAGO, AS 96799 AMERICAN SAMOA POWER AUTHORITY	PROJECT NAME:		SCALE:	SIGNATURE:
				FToala		AOLOAU WATERLINE REPLACEMENT PROJECT			
			REVISION:	CHECKED BY:		DRAWING TITLE:		PROJECT NO:	
				LTyrell		EROSION AND SEDIMENTATION CONTROL		1972803	
			CHECKED BY:	APPROVED BY:		DRAWING DETAILS:		DATE:	SHEET NO.
				Faguila / LTyrell		(STA. 52+80 TO STA. 77+40) (STA. 0+00 TO STA. 9+20)			
			APPROVED BY:	ISSUE FOR:	AMERICAN SAMOA POWER AUTHORITY	PROJECT LOCATION:		APRIL 2023	ESC3
				Construction		AOLOAU VILLAGE, AMERICAN SAMOA			
			DATE:						

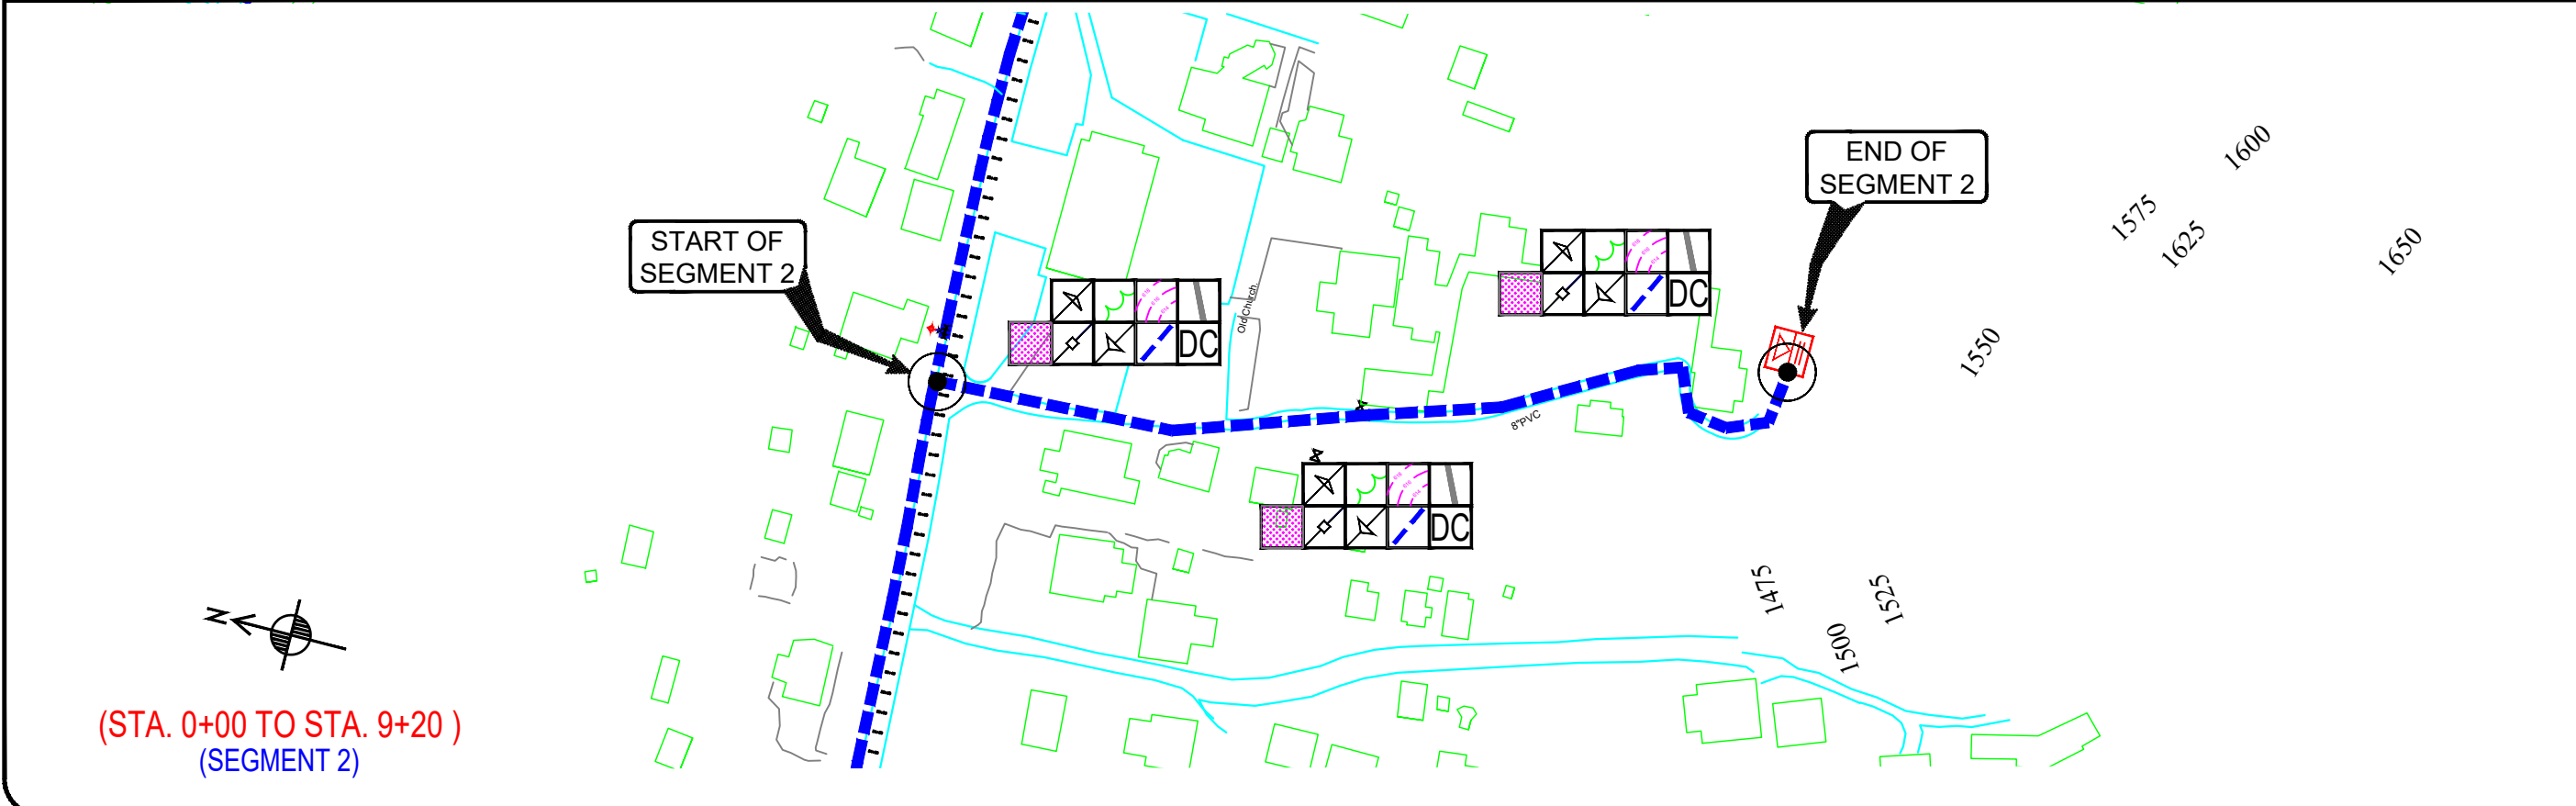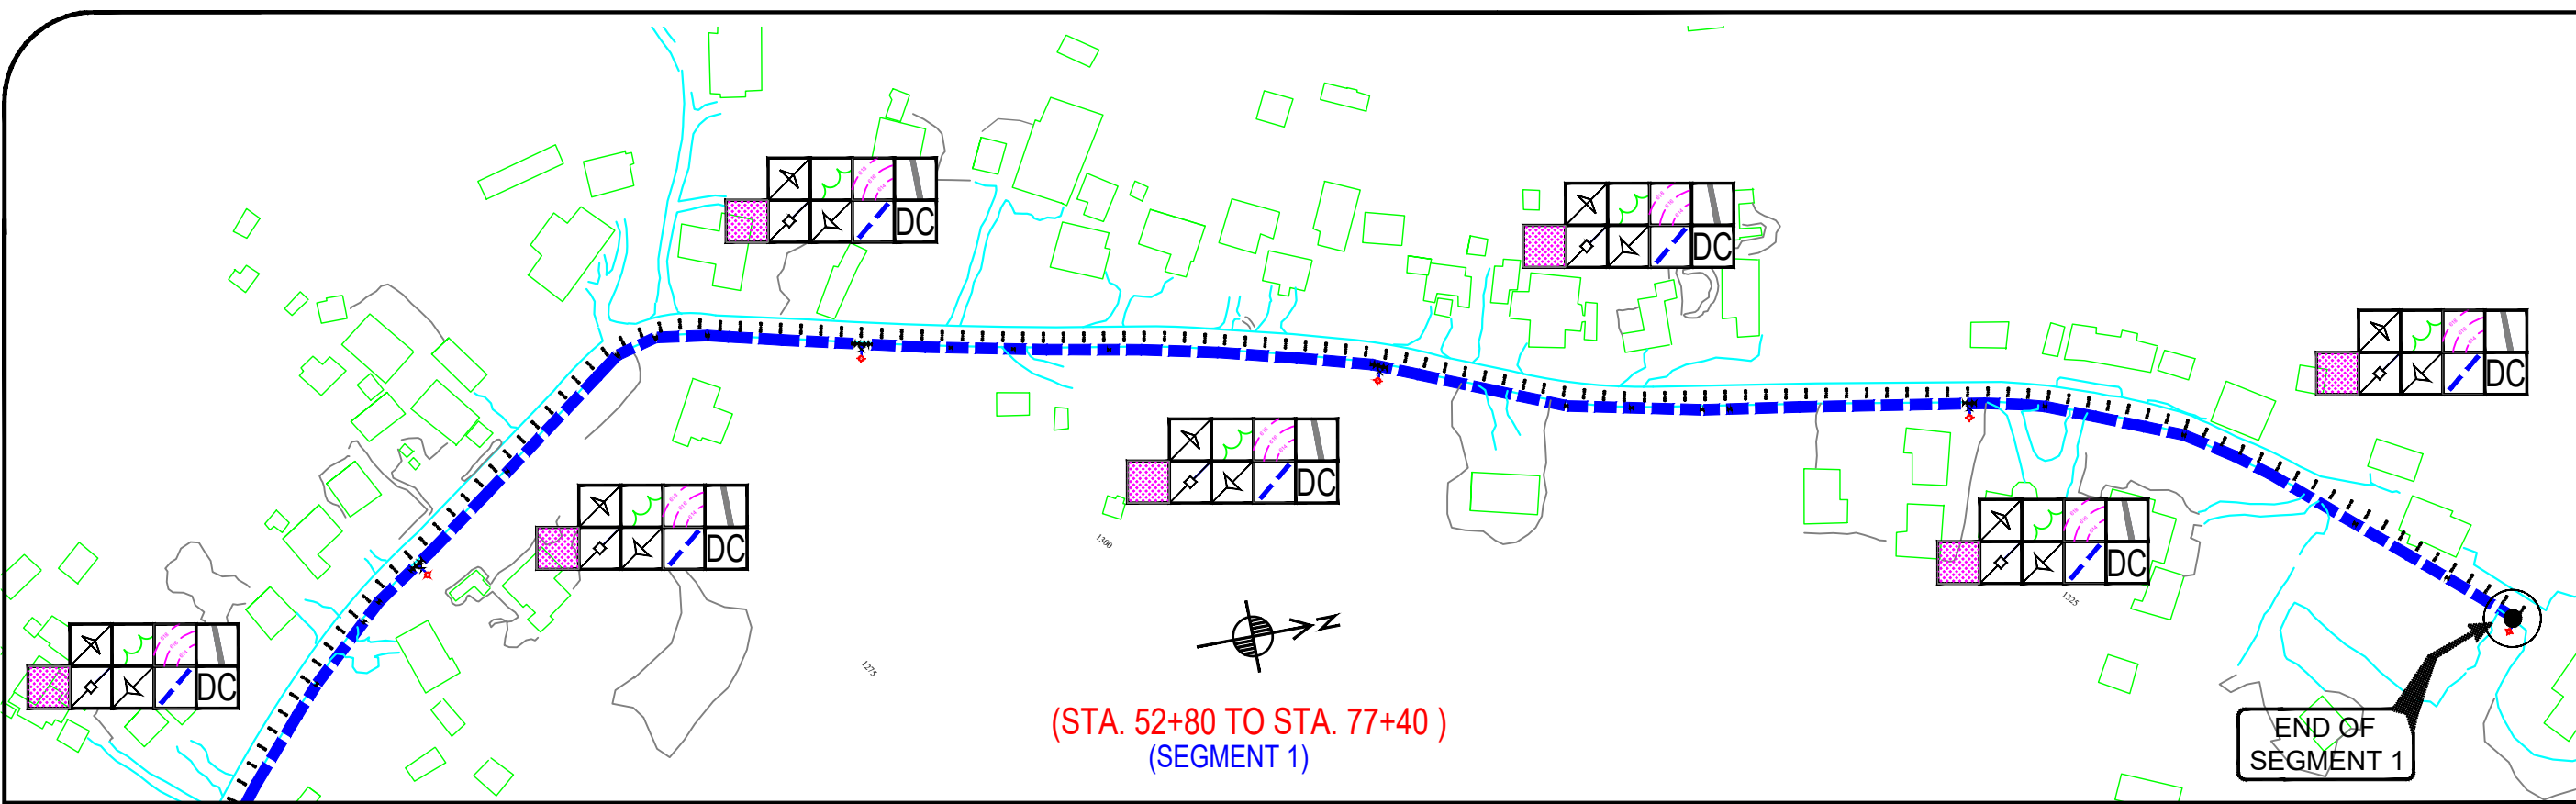

	CONSTRUCTION ENTRANCE	(CE)
	SILT FENCE	(SF)
	DIVERSION DIKE	(DD)
	RIGHT-OF-WAY DIVERSION	(RWD)
	TEMPORARY LEVEL SPREADER	(LS)
	TEMPORARY LEVEL DIVERSION	(LD)
	TEMPORARY FILL DIVERSION	(TFD)
	INLET PROTECTION	(IP)
	EC-2 MATTING	(B/M)
	EC-3 MATTING	(B/M)
	EXISTING TREELINE	
	EXISTING WATERS	
	EXISTING 100' STREAM BUFFER	
	PROPOSED TREELINE	
	PROPOSED GRADING	
	SEDIMENT BASIN DRAINAGE AREA	
	PEA GRAVEL LEVEL SPREADER	
	PEA GRAVEL LEVEL SPREADER	
	LIMIT OF DISTURBANCE	
	NOTE: DUST CONTROL MEASURES ARE TO BE USED ONSITE AS NECESSARY THROUGHOUT THE CONSTRUCTION ACTIVITY	

No.	Description	Date	REV. NO.:	PREPARED BY:	ASPA AMERICAN SAMOA POWER AUTHORITY ENGINEERING SERVICES DIVISION P.O.BOX PPB, TAFUNA, PAGO PAGO, AS 96799 AMERICAN SAMOA POWER AUTHORITY	PROJECT NAME:		SCALE:	SIGNATURE:
				FToala		AOLOAU WATERLINE REPLACEMENT PROJECT			
			REVISION:	CHECKED BY:		DRAWING TITLE:		PROJECT NO:	DATE:
				LTyrell		EROSION AND SEDIMENTATION CONTROL			
			CHECKED BY:	APPROVED BY:		DRAWING DETAILS:		DATE:	SHEET NO.
				FAguila / LTyrell		(STA. 52+80 TO STA. 77+40) (STA. 0+00 TO STA. 9+20)			
APPROVED BY:	ISSUE FOR:	PROJECT LOCATION:		APRIL 2023	ESC3				
	Construction	AOLOAU VILLAGE, AMERICAN SAMOA							

EROSION AND TEMPORARY DUST CONTROL




- 1. DURING CONSTRUCTION, PREVENTIVE MAINTENANCE MEASURES SHALL BE USED TO CONTROL FORESEEABLE DUST, EROSION OR SEDIMENTATION PROBLEMS WHICH MAY ARISE AS THE JOB PROGRESSES.
- 2. FUGITIVE DUST AND SOLID WASTE DISPOSAL DURING GRUBBING ACTIVITIES SHALL MEET REQUIREMENTS OF ADMINISTRATIVE RULES, TITLE II, CHAPTER 60, AIR POLLUTION CONTROL AND CHAPTER 58, SOLID WASTE MANAGEMENT CONTROL.
- 3. THE CONTRACTOR AT HIS OWN EXPENSE, SHALL KEEP THE PROJECT AREA AND SURROUNDING AREA FREE FROM DUST NUISANCE. THE WORK SHALL BE IN CONFORMANCE WITH THE AIR POLLUTION CONTROL STANDARDS AND REGULATIONS OF THE STATE DEPARTMENT OF HEALTH.
- 4. WHERE CONSTRUCTION ACTIVITY ON A PORTION OF THE SITE IS TEMPORARILY CEASED, AND EARTH DISTURBING ACTIVITIES WILL BE RESUMED WITHIN 14 DAYS, TEMPORARILY STABILIZATION MEASURES DO NOT HAVE TO BE INITIATED ON THAT PORTION OF THE SITE. ALL EXPOSED AREAS TO BE LEFT EXPOSED FOR LONGER THAN FOURTEEN (14) DAYS SHALL BE HYDROMULCH SEEDED WITH RYE GRASS.
- 5. ALL SLOPES AND EXPOSED AREAS SHALL BE SODDED OR PLANTED AS SOON AS FINAL GRADES HAVE BEEN ESTABLISHED. PLANTING SHALL NOT BE DELAYED UNTIL ALL GRADING WORKS HAS BEEN COMPLETED. GRADING TO FINAL GRADE SHALL BE CONTINUOUS, AND ANY AREA WITHIN WHICH WORK HAS BEEN INTERRUPTED OR DELAYED SHALL BE PLANTED.

BEST MANAGEMENT PRACTICE NOTES

- 1. MEASURES TO CONTROL EROSION AND OTHER POLLUTANTS SHALL BE IN PLACE BEFORE ANY WORK IS INITIATED. THESE MEASURES SHALL BE PROPERLY CONSTRUCTED AND MAINTAINED THROUGHOUT THE CONSTRUCTION PERIOD.
- 2. ALL TEMPORARY EROSION CONTROL MEASURES SHALL BE CHECKED AND REPAIRED AS NECESSARY.
- 3. GRASSING OR MULCHING OF EXPOSED AREAS TO BE DONE AS FINISH GRADES ARE ESTABLISHED.
- 4. DIVERSION OF STORM RUNOFF AWAY FROM THE FILL SLOPES UNTIL GRASSING ON THE FILL SLOPES ARE ESTABLISHED.
- 5. PROVIDE STABILIZED CONSTRUCTION ENTRANCE.

NOTES:

- 1. STABILIZED CONSTRUCTION ENTRANCE SHALL BE MAINTAINED AT THE EGRESS AND INGRESS TO THE SITE. TIRE WASH MAY BE USED IN LIEU OF STABILIZED CONSTRUCTION ENTRANCE. CONTRACTOR IS RESPONSIBLE TO KEEP ROADWAYS CLEAN FROM SOIL AND CONSTRUCTION DEBRIS.
- 2. DUST CONTROL SHOULD BE APPLIED TO REDUCE DUST EMISSIONS. WATER THE AREA DURING CONSTRUCTION TO CONTROL DUST.
- 3. ALL STORM DRAIN INLETS ON SITE AND THOSE OFF SITE WHICH MAY RECEIVE RUN OFF FROM THE SITE SHALL USE AN INLET PROTECTION DEVICE.

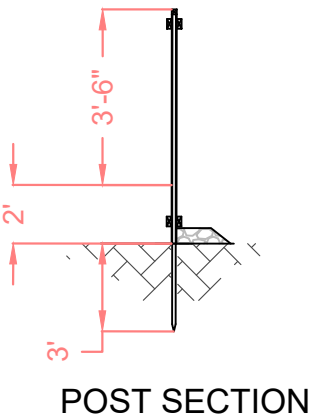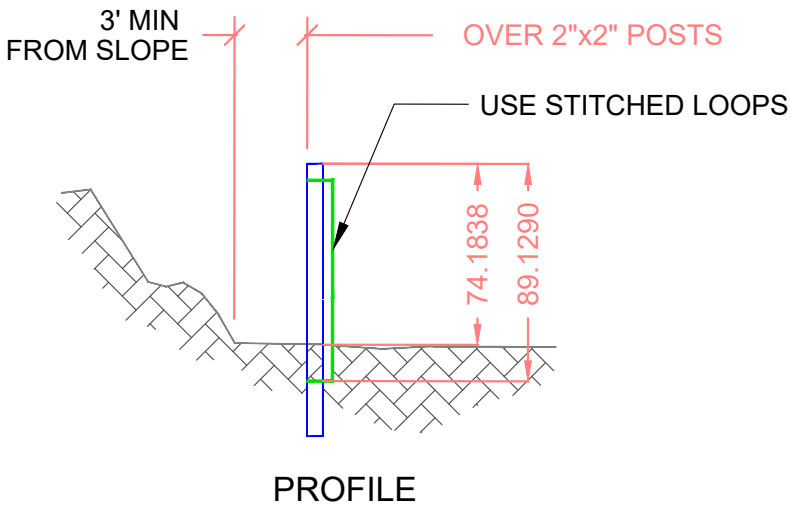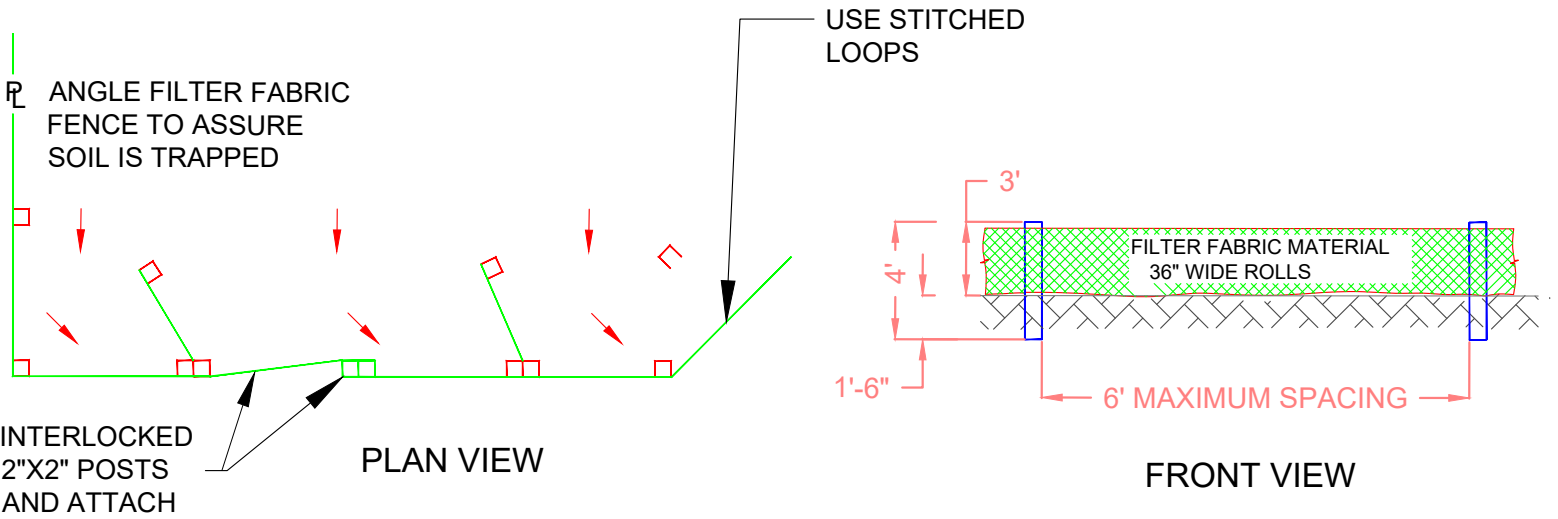

- NOTES:
- 1. BURY BOTTOM OF FILTER FABRIC 6" VERTICALLY BELOW FINISHED GRADE.
 - 2. 2"x2" FIR, PINE OR STEEL FENCE POSTS.
 - 3. POSTS TO BE INSTALLED ON UPHILL SIDE OF SLOPE.
 - 4. COMPACT BOTH SIDES OF FILTER FABRIC TRENCH.
 - 5. PANELS MUST BE PLACED ACCORDING TO SPACING ON DETAIL NO.940

No.	Description	Date

REV. NO.:	PREPARED BY: FToala
REVISION:	CHECKED BY: LTyrell
CHECKED BY:	APPROVED BY: FAguila / LTyrell
APPROVED BY:	ISSUE FOR: Construction
DATE:	



AMERICAN SAMOA POWER AUTHORITY
ENGINEERING SERVICES DIVISION
P.O.BOX PPB, TAFUNA, PAGO PAGO, AS 96799

PROJECT NAME: AOLOAU WATERLINE REPLACEMENT PROJECT	
DRAWING TITLE: EROSION AND SEDIMENTATION CONTROL	
DRAWING DETAILS: GENERAL NOTES	PROTECTIVE FABRIC DETAILS
PROJECT LOCATION: AOLOAU VILLAGE, AMERICAN SAMOA	

SCALE: AS SHOWN
PROJECT NO: 1972803
DATE: APRIL 2023




SIGNATURE:
DATE:
SHEET NO. ESC0

AOLOAU WATERLINE REPLACEMENT PROJECT

TUTUILA ISLAND, AMERICAN SAMOA.

SHEET #		DESCRIPTION	ABBREVIATIONS:			
G1		VICINITY MAP, LOCATION PLAN	@	AT	PROP	PROPOSED
G2		TABLE OF CONTENTS. ABBREVIATIONS	AFF	ABOVE FINISHED FLOOR	PVC	POLYVINYL CHLORIDE PIPE
G3		LEGEND, GENERAL NOTES	AFG	ABOVE FINISHED GRADE	PE	POLYETHYLENE PIPE
G4		CONSTRUCTION NOTES	AGG	AGGREGATE	ACP	ASBESTOS CEMENT PIPE
			ARV	AIR/VAC RELEASE VALVE	GA	GAUGE
ESC0		GENERAL NOTES	AS-EPA	AMERICAN SAMOA ENVIRONMENTAL PROTECTION AGENCY	GALV	GALVANIZED
ESC1		VICINITY MAP FOR EROSION AND SEDIMENTATION CONTROL	BLDG	BUILDING	GR	GRADE
ESC2		EROSION AND SEDIMENTATION CONTROL & DETAILS	CB	CATCH BASIN	GV	GATEVALVE
ESC3		EROSION AND SEDIMENTATION CONTROL & DETAILS	CI	CAST IRON	HB	HOSE BIB
			CL	CENTER LINE	HWY	HIGHWAY
		SEGMENT 1	CMP	CORRUGATED METAL PIPE	ID	INSIDE DIAMETER
C01		PLAN & PROFILE (STA 0+00 – STA 5+00) START OF SEGMENT 1	CO	CLEAN OUT	INSUL	INSULATION
C02		PLAN & PROFILE (STA 5+00 – STA 10+00)	CONC	CONCRETE	INV	INVERT
C03		PLAN & PROFILE (STA 10+00 – STA 15+00)	CP	CONTROL POINT	IR	IRON ROD
C04		PLAN & PROFILE (STA 15+00 – STA 20+00)	DET	DETAIL	JT	JOINT
C05		PLAN & PROFILE (STA 20+00 – STA 25+00)	DIA	DIAMETER	LT	LEFT
C06		PLAN & PROFILE (STA 25+00 – STA 30+00)	DIM	DIMENSION	M	METER
C07		PLAN & PROFILE (STA 30+00 – STA 35+00)	DIP	DUCTILE IRON PIPE	MANUF	MANUFACTURED
C08		PLAN & PROFILE (STA 35+00 – STA 40+00)	DW	DRIVEWAY	MAX	MAXIMUM
C09		PLAN & PROFILE (STA 40+00 – STA 45+00)	E	EAST	MFR	MANUFACTURER
C10		PLAN & PROFILE (STA 45+00 – STA 50+00)	ELEV	ELEVATION	MH	MANHOLE
C11		PLAN & PROFILE (STA 50+00 – STA 55+00)	ELEC	ELECTRICAL	MIN	MINIMUM
C12		PLAN & PROFILE (STA 55+00 – STA 60+00)	EOL	END OF LINE	MISC	MISCELLANEOUS
C13		PLAN & PROFILE (STA 60+00 – STA 65+00)	EOP	EDGE OF PAYMENT	(N)	NEW
C14		PLAN & PROFILE (STA 65+00 – STA 70+00)	EQ	EQUAL	N	NORTH
C15		PLAN & PROFILE (STA 70+00 – STA 75+00)	EXT'G	EXISTING	NIC	NOT IN CONTRACT
C16		PLAN & PROFILE (STA 75+00 – STA 77+40) END OF SEGMENT 1	EXT	EXTERIOR	NO	NOT OPEN
		SEGMENT 2	FD	FLOOR DRAIN	NC	NORMALLY CLOSED
C17		PLAN & PROFILE (STA 0+00 – STA 5+00) START OF SEGMENT 2	FH	FIRE HYDRANT	NTS	NOT TO SCALE
C16		PLAN & PROFILE (STA 5+00 – STA 9+20) END OF SEGMENT 2	FIN	FINISHED	OC	ON CENTER
D01		GATE VALVE, GATE VALVE BOX DETAILS	FLR	FLOOR	OD	OUTSIDE DIAMETER
D02		AIR RELIEF VALVE DETAILS	FND	FOUND	OH	OVERHEAD
D03		THRUST BLOCK DETAILS	FT	FEET	OSHA	OCCUPATIONAL SAFETY HEALTH ADMINISTRATION
D04		UTILITY CROSSING DETAILS	FTG	FOOTING	SC	SERVICE CONNECTION
D05		BACTERIOLOGICAL SAMPLING STATION DETAILS	PL	PROPERTY LINE		
D06		FIRE HYDRANT DETAILS				
D07		TYPICAL MAIN ROAD CROSSING SECTION DETAIL				
D08		TYPICAL ROAD SECTION DETAILS				
D09		MAINLINE SUPPLY TO SERVICE LINE CONNECTION				
D10		TIE-IN DETAILS				
D11		TANK CONNECTION DETAILS				

No.	Description	Date	REV. NO.:	DESIGNED BY:	 AMERICAN SAMOA POWER AUTHORITY ENGINEERING SERVICES DIVISION P.O.BOX PPB, TAFUNA, PAGO PAGO, AS 96799	PROJECT NAME:	SCALE:	SIGNATURE:
			REVISION:	FToala		AOLOAU 6"Ø WATERLINE REPLACEMENT PROJECT	AS SHOWN	DATE:
			CHECKED BY:	LTyrell		DRAWING TITLE:	PROJECT NO:	
			CHECKED BY:			TABLE OF CONTENTS & ABBREVIATIONS	#1958785	
			APPROVED BY:	FAGuila / LTyrell		PROJECT LOCATION:	DATE:	SHEET NO.
			DATE:	Construction		AOLOAU VILLAGE, AMERICAN SAMOA	APRIL 2023	G1

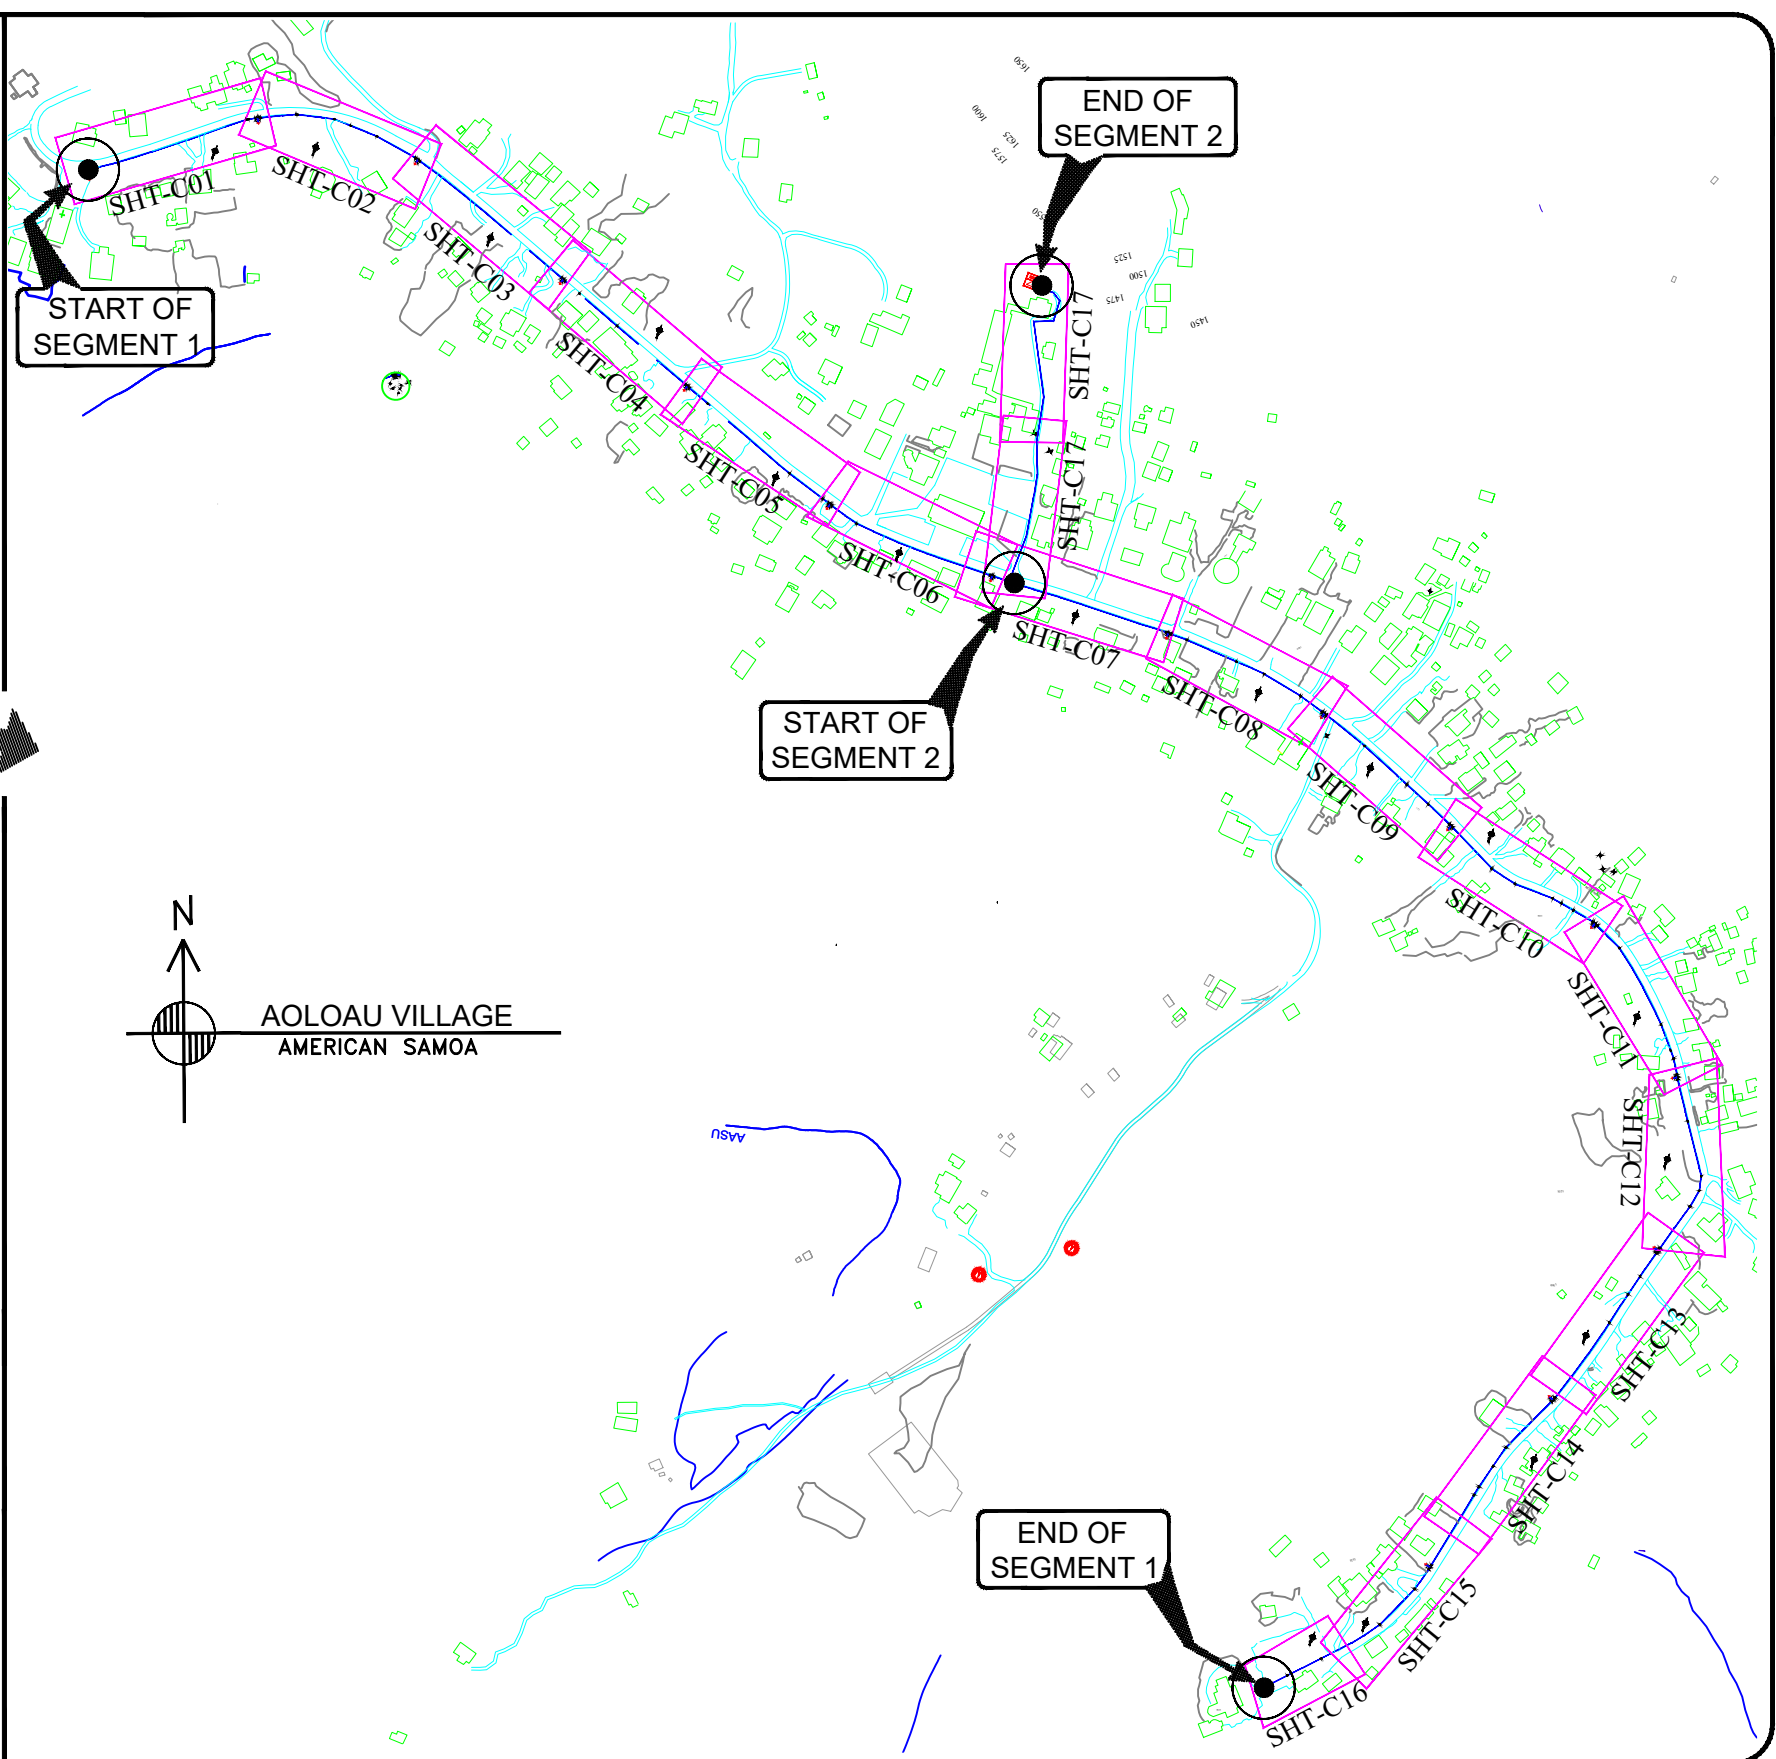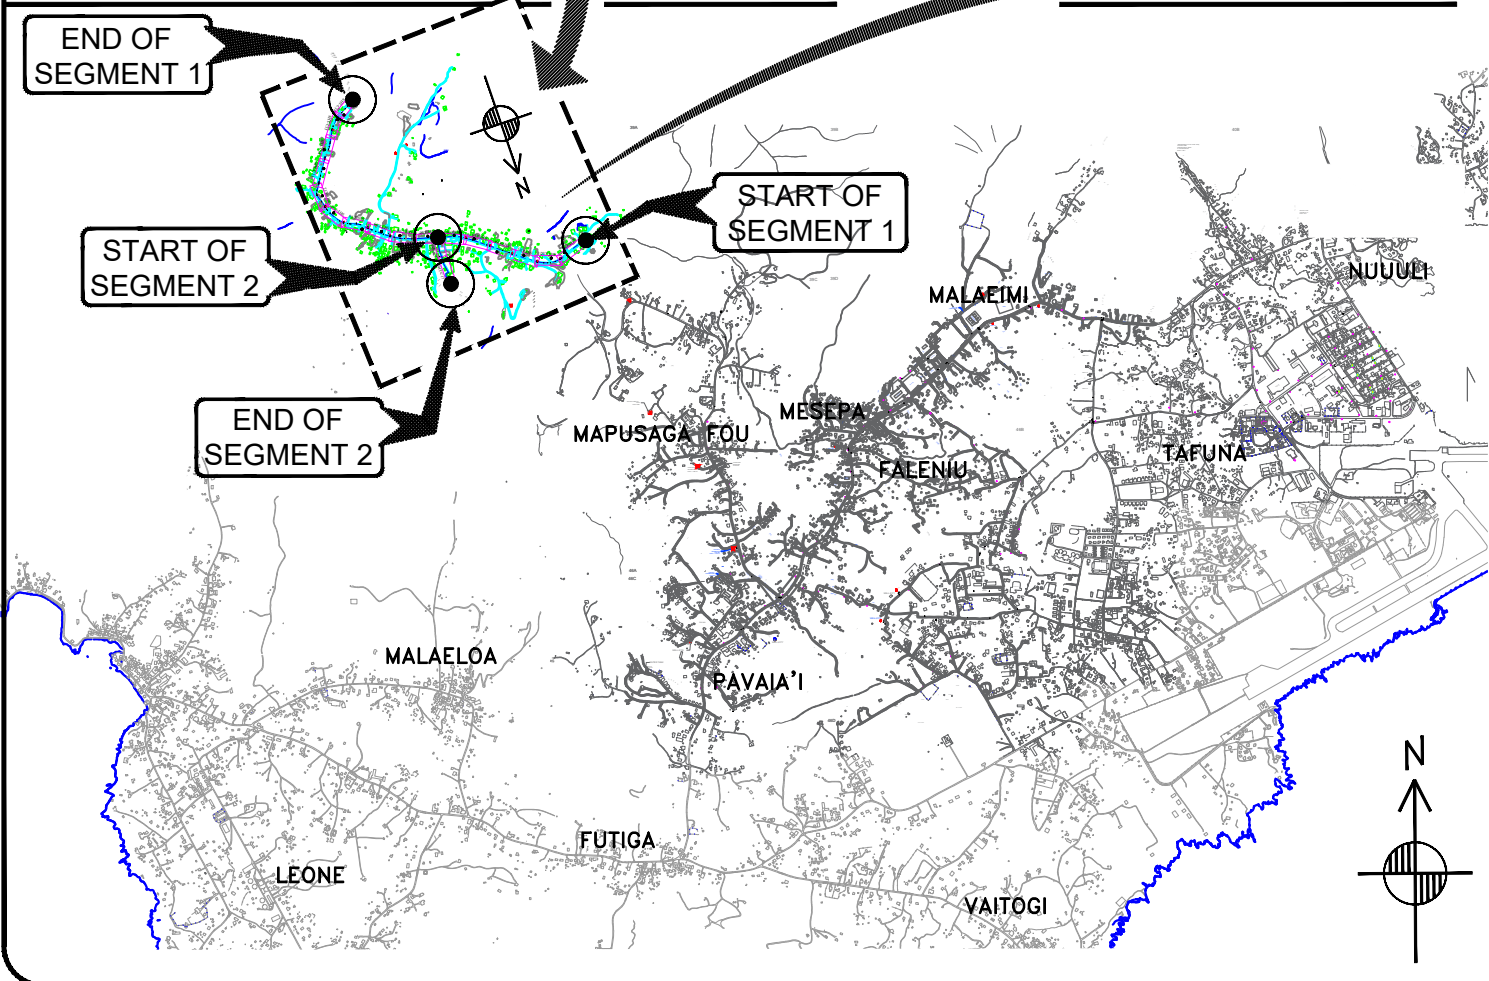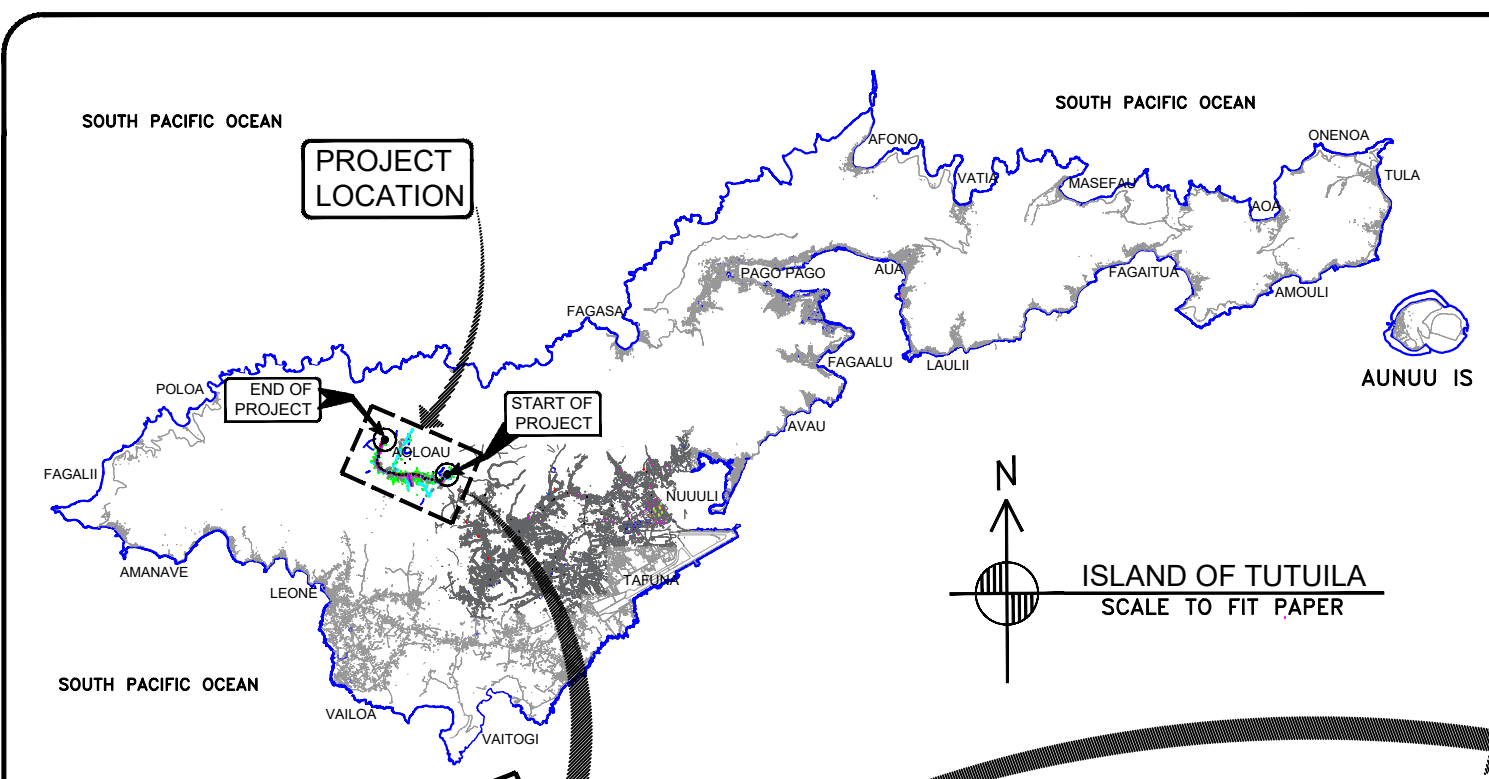

No.	Description	Date	REV. NO.:	DESIGNED BY:	ASPA AMERICAN SAMOA POWER AUTHORITY ENGINEERING SERVICES DIVISION P.O.BOX PPB, TAFUNA, PAGO PAGO, AS 96799	PROJECT NAME:	SCALE:	SIGNATURE:
			REVISION:	CHECKED BY:		AOLOAU 6"Ø WATERLINE REPLACEMENT PROJECT	AS SHOWN	DATE:
			CHECKED BY:	APPROVED BY:		DRAWING TITLE:	PROJECT NO:	
			APPROVED BY:	ISSUE FOR:		VICINITY MAP & PROJECT LOCATION	#1958785	SHEET NO.
			DATE:			PROJECT LOCATION:	DATE:	
						AOLOAU VILLAGE, AMERICAN SAMOA	APRIL 2023	G2

LEGEND:

WATER MAIN

EXISTING WATER MAIN

GATE VALVE

FIRE HYDRANT

ELBOW

TEE

ARV

EXISTING WELL

BENCH MARK

POWER POLE

WATER METER W/ BOX

WATER SERVICE LINE

GATE VALVE W/ BOX

PAVED ROAD

UNPAVED ROAD

SIGN POST

DIAMETER

PRESSURE GAUGE

CONTOUR LINE

PRV

UTILITY GENERAL NOTES:

1. EXISTING WATERLINE LOCATIONS ARE APPROXIMATE. CONTRACTOR SHALL COORDINATE LOCATING EXISTING UTILITY WITH ASPA OR OWNERS OF UTILITY LINES PRIOR TO EXCAVATION WITH APPROPRIATE ADVANCE NOTIFICATION.

2. ABANDON EXISTING WATER MAIN AND SERVICES IN PLACE ONLY AFTER THE NEW WATER MAIN HAS BEEN DISINFECTED AND APPROVED BY THE AMERICAN SAMOA POWER AUTHORITY (ASPA) AND THE AMERICAN SAMOA ENVIRONMENTAL PROTECTION AGENCY.

3. ALL GATE VALVES ARE TO BE INSTALLED WITH VALVE BOXES PER DRAWINGS AND SPECIFICATIONS.

4. ALL FLUSH VALVES ARE TO BE INSTALLED IN VALVE BOXES PER DRAWINGS AND SPECIFICATIONS.

5. ALL STATION LOCATIONS ARE APPROXIMATE.

6. CONTRACTOR IS RESPONSIBLE FOR MEETING CONDITIONS OF THE PNRS LAND-USE PERMIT.

7. FOR CONFLICT BETWEEN DRAWINGS AND SPECIFICATIONS, PNRS PERMIT REQUIREMENTS AND CONDITIONS SHALL APPLY, THEN SPECIFICATIONS, THEN DRAWINGS.

8. CONTRACTOR MUST CONFORM WITH ALL REQUIREMENTS OF THE OSHA STANDARD FOR EXCAVATION SAFETY (29 CFR 1926 SUBPART P). INCLUDED AMONG THE OSHA STANDARDS IS THE REQUIREMENT FOR PROTECTION OF WORKERS IN EXCAVATIONS 4 FEET OR GREATER IN DEPTH. PROTECTIVE SYSTEMS CAN BE SLOPING/BENCHING OF EXCAVATION WALLS, OR INSTALLATION OF SUPPORT/SHIELDING DEVICES. DESIGN OF PROTECTIVE SYSTEMS MUST BE BASED ON FIELD CLASSIFICATION OF THE SOIL BY A COMPETENT PERSON. PROTECTIVE SYSTEMS MUST BE IN ACCORDANCE WITH THE TABLES AND FIGURES SHOWN IN THE OSHA STANDARDS, OR MUST BE A MANUFACTURED PROTECTION SYSTEM USED IN STRICT CONFORMANCE WITH MANUFACTURER'S INSTRUCTIONS, OR MUST BE A PROTECTION SYSTEM DESIGNED BY A REGISTERED PROFESSIONAL ENGINEER. THE
9. CONTRACTOR SHALL PROVIDE BOTH CONC. ANCHORS & CLAY DIKES AS REQUIRED BY THE ENGINEER AS FOLLOWS:

10%<SLOPE<15%: ONE EVERY 200 LINEAR FEET CLAY DIKES ONLY

15% OR GREATER SLOPES: EVERY 100 LINEAR FEET-CONC. ANCHORS & CLAY DIKES.

A.) CLAY DIKES SHALL EXTEND FOR THE FULL TRENCH WIDTH (USED FOR PIPE BEDDING AND COVER) AND HAVE A LENGTH OF 5 FEET. LOCATED IN THE MIDDLE OF PIPE LENGTH, AT LEAST 2 FEET FROM A PIPE JOINT. MATERIALS SHALL BE CLAY AS DESIGNATED "CL" AND DEFINED UNDER THE UNIFIED SOIL CLASSIFICATION SYSTEM.

B.) CONC. ANCHORS SHALL BE LOCATED AT THE DOWNSTREAM SIDE OF JOINTS, SHALL BE UN-REINFORCED AND SHALL BE MINIMUM OF TRENCH WIDTH, 3 FEET HIGH (REPLACING PIPE BEDDING AND COVER) AND 2 FEET THICK.

10. LEVEL SURVEY & TOPOGRAPHIC MAPS USED FOR PLAN SHEETS ARE DATED FEB. 2006, CONDUCTED BY ASG/SURVEY DEPT. BUILDINGS AND ROADWAYS WERE UPDATED BY AERIAL PHOTOGRAPHY DURING AUGUST/SEPTEMBER 1990. LOCATIONS, BUILDING LOCATIONS, AND OTHER FEATURES MAY HAVE CHANGED SINCE THE LAST MAP UPDATE.

11. UTILITIES KNOWN TO EXIST BY THE ENGINEER FROM RESEARCH OF THE AVAILABLE RECORDS ARE SHOWN ON THE DRAWINGS. NO RESPONSIBILITY IS CLAIMED FOR COMPLETENESS OR ACCURACY. PRIOR TO STARTING CONSTRUCTION, VERIFY LOCATION AND ELEVATION OF ALL EXISTING UTILITIES WHICH MAY INTERFERE WITH THE FACILITIES INSTALLED UNDER THIS CONTRACT.

12. ELEVATIONS USED IN THE DRAWINGS ARE BASED ON 0.00 AT THE MEAN SEA LEVEL, HORIZONTAL COORDINATES ARE BASED ON THE AMERICAN SAMOA COORDINATE SYSTEM GRID.
13. PROVIDE, INSTALL, AND MAINTAIN SIGNS BARRICADES, MARKERS, CONES AND PROTECTIVE FACILITIES AND TAKE ALL NECESSARY PRECAUTIONS FOR THE PROTECTION, CONVENIENCE AND SAFETY OF THE PUBLIC DURING THE CONSTRUCTION OPERATIONS, CONFORM TO THE REQUIREMENTS OF THE DEPARTMENT OF PUBLIC SAFETY AND THE DEPARTMENT OF PUBLIC WORKS IN REGARD TO TRAFFIC SAFETY WHILE WORKING IN THE PUBLIC RIGHT-OF-WAY. ALL TRAFFIC CONTROL PLANS MUST BE APPROVED BY DPS AND PUBLIC WORKS PRIOR TO START OF CONSTRUCTION.

14. MAINTAIN TWO-WAY TRAFFIC ON HIGHWAY AT ALL TIMES UNLESS PRIOR PERMISSION TO CLOSE ONE LANE IS OBTAINED FROM THE DEPARTMENT OF PUBLIC SAFETY. IF THE LANE CLOSURE IS REQUIRED, PROPER ADVANCE NOTICE TO PUBLIC VIA NORMAL PUBLICATION OR RADIO ANNOUNCEMENTS IS REQUIRED.

15. KEEP THE WORK SITE AND SURROUNDING AREAS FREE FROM DUST NUISANCE. DUST CONTROL, SEDIMENTATION CONTROL, AND ALL SUCH PLANS MUST BE APPROVED BY THE AMERICAN SAMOA ENVIRONMENTAL PROTECTION AGENCY PRIOR TO START OF CONSTRUCTION.

16. REMOVE ALL SILT AND DEBRIS RESULTING FROM THE WORK AND DEPOSITED IN DRAINAGE FACILITIES, ROADWAYS, AND OTHER AREAS WHEN NECESSARY. CONSTRUCT SILT FENCES AND OTHER EROSION CONTROL DEVICES AROUND THE WORK TO PREVENT DAMAGE TO STREAMS OR OTHER WATERWAYS.
17. BARRICADE OPEN EXCAVATIONS AND POST WITH WARNING LIGHTS. KEEP UNATTENDED EXCAVATIONS FREE OF WATER AND MAINTAIN SLOPING AND STABLE WALLS WHEN OVER 4 FEET DEEP. LEAVE A LADDER OR OTHER DEVICE TO ALLOW ESCAPE FROM EXCAVATION. WHEN PERSONNEL ARE IN THE EXCAVATION, AT LEAST 2 MEANS OF EGRESS ARE REQUIRED. LADDERS ARE REQUIRED TO ALLOW NOT MORE THAN 25 FEET OF LATERAL TRAVEL FOR TRENCH EGRESS.

18. THE CONTRACTOR IS RESPONSIBLE FOR PROVIDING ALL NECESSARY EQUIPMENT AND MATERIALS FOR TESTING WATERLINES.

19. ROADS AND PROPERTIES AFFECTED BY EXCAVATION MUST BE REFURBISHED TO ORIGINAL STATUS OR BETTER AT COMPLETION OF PROJECT.

20. CONTRACTOR TO PROVIDE ELECTRONIC AS-BUILT DRAWINGS IN AUTODESK LAND DEVELOPMENT 2006 OR A RECENT VERSION THEREOF, OF ALL APPURTENANCES AND SURVEY REFERENCE POINTS TO ACCEPTABLE LOCATIONS. MINIMAL REQUIREMENT OF 2 POINTS FOR MINOR AND 3 POINTS FOR MAJOR APPURTANCES.

21. MAINTAIN WATER AND SEWER LINE SEPARATION IN ACCORDANCE WITH REGULATIONS.

22. INSTALL DETECTABLE WARNING TAPE AND CONDUCTOR TAPE ON TOP OF ALL PIPE.

23. ALL REBARS SHOULD BE EPOXY COATED. UNLESS DIRECTED BY ENGINEER

24. CONSTRUCT SWALES AS SHOWN IN DETAILS WHENEVER SLOPE EXCEEDS 8%.

No.	Description	Date	REV. NO.:	DESIGNED BY:	 AMERICAN SAMOA POWER AUTHORITY ENGINEERING SERVICES DIVISION P.O.BOX PPB, TAFUNA, PAGO PAGO, AS 96799 AMERICAN SAMOA POWER AUTHORITY	PROJECT NAME:	SCALE:	SIGNATURE:
			REVISION:	CHECKED BY:		AOLOAU 6"Ø WATERLINE REPLACEMENT PROJECT	AS SHOWN	DATE:
			CHECKED BY:	APPROVED BY:		DRAWING TITLE:	PROJECT NO:	
			APPROVED BY:	ISSUE FOR:		LEGEND UTILITY GENERAL NOTES	#1958785	SHEET NO.
			DATE:			PROJECT LOCATION:	DATE:	
						AOLOAU VILLAGE, AMERICAN SAMOA	APRIL 2023	G3

CONSTRUCTION NOTES:

1. THE CONTRACTOR SHALL COORDINATE HIS HAUL ROUTE STAGING AREA AND ALL ASSOCIATED REQUIREMENTS, SUCH AS, LAND USE PERMIT, WITH THE PNRS, CONTRACTING OFFICER, AND AFFECTED LANDOWNER.

2. A SEPARATE LAND USE PERMIT MUST BE OBTAINED BY THE CONTRACTOR IF THE CONTRACTOR'S STAGING AREA OR ANY WORK IS OUTSIDE THE LIMITS OF THE CONTRACT. THE EXISTING LAND USE PERMIT IS CONDITIONED ON A DIVISION OF MARINE AND WILDLIFE RESOURCES REVIEW PRIOR TO CONSTRUCTION.

3. THE CONTRACTOR SHALL BE RESPONSIBLE FOR THE CLEARING AND REMOVAL OF ALL SILT AND DEBRIS GENERATED BY HIS GRADING AND CONSTRUCTION WORK AND DEPOSITED AND ACCUMULATED ON ROADWAYS AND OTHER AREAS.

4. ALL EXISTING UTILITIES, CONCRETE WALKWAYS, STEPS AND WALLS, WHETHER OR NOT SHOWN ON THE DRAWINGS, EXCEPT THOSE DESIGNATED TO BE REMOVED, SHALL BE PROTECTED FROM DAMAGED AT ALL TIMES DURING CONSTRUCTION AND GRADING WORK. ANY DAMAGES TO THEM SHALL BE REPAIRED BY THE CONTRACTOR AT HIS EXPENSE.

5. THE CONTRACTOR SHALL VERIFY DIMENSIONS, LOCATIONS, ELEVATIONS, ETC. THAT ARE INDICATED FOR VERIFICATION AND INFORM THE CONTRACTING OFFICER IN WRITING OF ANY DIFFERENCES PRIOR TO INSTALLATION OF NEW FACILITIES.

6. THE CONTRACTOR SHALL TONE AND PROBE THE AREA PRIOR TO ALL EXCAVATION AND TRENCHING TO VERIFY THE LOCATION OF ALL EXISTING UTILITIES AND SHALL BE RESPONSIBLE FOR REPAIR OR REPLACEMENT OF SAME IN THE EVENT OF DAMAGES DUE TO CONTRACTORS CONSTRUCTION PRACTICES. WHENEVER CONNECTIONS OF NEW UTILITIES TO EXISTING UTILITIES ARE SHOWN ON THE PLANS, THE CONTRACTOR SHALL EXPOSE THE EXISTING LINES AT THE PROPOSED CONNECTIONS TO VERIFY THEIR LOCATIONS, DEPTHS AND ASSURE THAT CONNECTIONS CAN BE MADE PRIOR TO EXCAVATION FOR THE NEW LINES AT NO COST TO THE OWNER. ANY NECESSARY ADJUSTMENTS FOR THE NEW LINES TO ENSURE PROPER CONNECTIONS TO THE EXISTING SHALL BE THE CONTRACTOR'S RESPONSIBILITY. THE CONTRACTOR SHALL ALSO CONTACT ASPA, BLUESKY AND ASTCA TO PROPERLY LOCATE THE UNDERGROUND UTILITIES AND CABLES THAT LIE IN AND ADJACENT TO THE WORK AREA.

7. WORK SHALL BE DONE BETWEEN 7:30AM AND 4:00PM SAMOA STANDARD
- TIME. NO WORK SHALL BE DONE ON SATURDAYS, SUNDAYS, FEDERAL HOLIDAYS OR AFTER NORMAL WORK HOURS AT ANY TIME, WITHOUT SPECIAL ARRANGEMENT AND PRIOR APPROVAL BY THE CONTRACTING OFFICER. PROJECT WORK SHALL BE IN CONFORMANCE WITH APPLICABLE FEDERAL AND LOCAL LAWS AND REGULATIONS REGARDING COMMUNITY NOISE CONTROL.

8. THE CONTRACTOR SHALL BE RESPONSIBLE FOR THE PROTECTION OF ALL WATERLINES DURING CONSTRUCTION. THE CONTRACTOR SHALL BE ESPECIALLY CAREFUL WHEN EXCAVATING BEHIND WATERLINE TEES AND BENDS WHEREVER THERE IS POSSIBILITY OF WATERLINE MOVEMENT DUE TO REMOVAL OF THE SUPPORTING EARTH BEYOND THE EXISTING REACTION BLOCKS. THE CONTRACTOR SHALL TAKE WHATEVER MEASURE TO PROTECT THE WATERLINE SUCH AS CONSTRUCTING SPECIAL REACTION BLOCKS AND/OR MODIFYING HIS CONSTRUCTION METHODS.

9. NO BLASTING WILL BE ALLOWED ON THIS PROJECT.

10. THE CONTRACTOR SHALL PROTECT EXISTING PUBLIC AND PRIVATE FACILITIES AND UTILITIES, AND PROVIDE SHORING DURING EXCAVATION. THE CONTRACTOR SHALL REPAIR, AT HIS COST, ALL DAMAGES DUE TO EXCAVATION.

11. THE CONTRACTOR SHALL COORDINATE WITH ASPA, ASC, BLUESKY COMMUNICATIONS AND ASTCA FOR ALL NEW POLE INSTALLATION, POWER, TELEVISION AND COMMUNICATIONS RELOCATIONS, AND REMOVAL OF EXISTING POLES. IF THE CONTRACTOR SHALL PROVIDE RELOCATIONS, REMOVAL OF EXISTING POLES. THE CONTRACTOR SHALL PROVIDE SUPPORTS FOR THE EXISTING POLES AFFECTED BY EXCAVATION. THE CONTRACTOR SHALL NOTIFY AFFECTED VILLAGES AND THE UTILITY COMPANIES SEVEN (7) DAYS PRIOR TO SERVICE INTERRUPTIONS. THESE NOTIFICATIONS SHALL BE AT THE CONVENIENCE OF ASPA, ASC, BLUESKY COMMUNICATION AND ASTCA.

12. THE CONTRACTOR SHALL PROVIDE ALL LAND SURVEY CONSTRUCTION STAKEOUT SERVICES, SOIL AGGREGATE, CONCRETE AND PAVEMENT MONITORING, AND SAMPLING AND TESTING SERVICES.

13. WASTE MATERIAL WILL BE DISPOSED OF AT AN APPROVED, PNRS-COMPLIANT, OFF-SITE DISPOSAL AREA. THE CONTRACTOR SHALL BE RESPONSIBLE FOR OBTAINING DISPOSAL AREA.

14. THE CONTRACTOR SHALL TAKE EXTREME CARE IN PERFORMING WORK NEAR EXISTING CONCRETE ELECTRICAL/COMMUNICATION DUCTS.
- APPROPRIATE PROTECTION SHALL BE IMPLEMENTED AS REQUIRED TO PREVENT DAMAGE TO THIS LINE.

15. THE CONTRACTOR SHALL VERIFY, BASED ON THE SITE CONDITIONS AND CONTRACT BASELINE DATA, WITH OVERVIEW AND APPROVAL BY AN AUTHORIZED REPRESENTATIVE OF AMERICAN SAMOA POWER AUTHORITY, THE LOCATION OF ALL EXISTING POLES WHICH IMPACT THE CONSTRUCTION AND ULTIMATE USE OF THE PROPOSED ROAD.

16. THE CONTRACTOR SHALL VERIFY, BASED ON OVERVIEW AND APPROVAL BY AUTHORIZED REPRESENTATIVE OF AMERICAN SAMOA GOVERNMENT OFFICE OF COMMUNICATIONS, THE LOCATIONS AND DEPTH OF EXISTING UNDERGROUND TELEPHONE CABLES. RELOCATE EXISTING DIRECT BURIED CABLES WHICH IMPACT THE CONSTRUCTION AND FINAL USE OF THE PROPOSED ROAD. EITHER INTO A NEW TRENCH AWAY FROM THE ROAD OR IN PVC SCHEDULE80 SLEEVES THROUGH THE ROAD AT A MINIMUM DEPTH OF 3' BELOW FINISHED GRADE IF THE CABLES CANNOT BE RELOCATED. TO EXPOSE THE CABLE, THE CONTRACTOR SHALL TONE FOR THE CABLE AND HAND EXCAVATE THE CABLE TAKING CARE NOT TO DAMAGE THE JACKET AND INSULATION. BASIS OF BID SHALL BE 100 LINEAR FEET OF DIRECT BURIED CABLE.



17. THE CONTRACTOR SHALL REMOVE ALL EXISTING PAVEMENT AND CROSSING ALONG THE NEW ROADWAY. ALL DEMOLITION AND REMOVAL OF EXISTING PAVEMENT SHALL BE CONSIDERED INCIDENTAL TO ROADWAY CONSTRUCTION.

18. ALL TRAFFIC SIGN AND PAVEMENT MARKERS SHALL BE IN ACCORDANCE WITH THE MANUAL ON UNIFORM TRAFFIC CONTROL DEVICES (MUTCD) 2003 EDITION, AND ALL SUBSEQUENT AMENDMENTS AND ADDITIONS.

19. AT THE END OF THE WORKDAY OR AS SOON AS WORK IS COMPLETED, THE CONTRACTOR SHALL TAKE NECESSARY MEASURES TO ENSURE THAT PUBLIC TRAFFIC HAS SAFE PASSAGE AND THAT ALL OPEN HOLES ARE PROPERLY COVERED AND MAINTAINED DURING THE DURATION OF THE PROJECT.

20. IF THE CONTRACTOR UNCOVERS ANY CULTURAL REMAINS, DURING EXCAVATION WORK, THE CONTRACTOR SHALL STOP WORK IN THE AREA OF THE FINDINGS AND NOTIFY THE CONTRACTING OFFICER AND THE AMERICAN SAMOA GOVERNMENT (ASHPO AND ASPA)

No.	Description	Date	REV. NO.:	DESIGNED BY:	ASPA AMERICAN SAMOA POWER AUTHORITY ENGINEERING SERVICES DIVISION P.O.BOX PPB, TAFUNA, PAGO PAGO, AS 96799 AMERICAN SAMOA POWER AUTHORITY	PROJECT NAME:	SCALE:	SIGNATURE:
			REVISION:	CHECKED BY:		AOLOAU 6"Ø WATERLINE REPLACEMENT PROJECT	AS SHOWN	DATE:
			CHECKED BY:	APPROVED BY:		DRAWING TITLE:	PROJECT NO:	SHEET NO.
			APPROVED BY:	ISSUE FOR:		CONSTRUCTION NOTES	#1958785	
			DATE:			PROJECT LOCATION:	DATE:	
						AOLOAU VILLAGE, AMERICAN SAMOA	APRIL 2023	G4

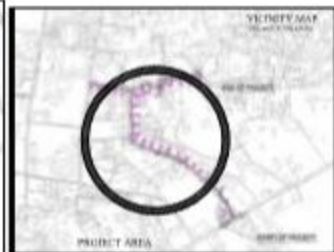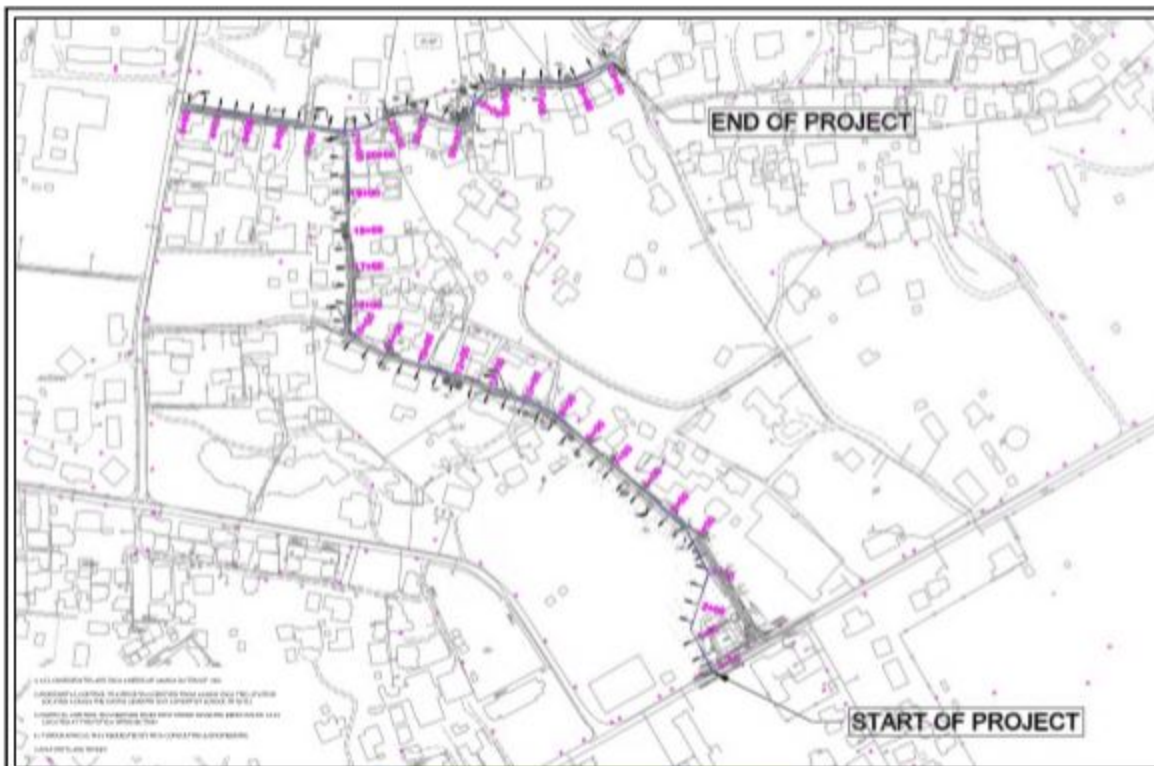


LEGEND

- | | |
|--|--|
| | |
| | |
NOTES:

1. DESIGN ALIGNMENT & PROFILE ARE APPROXIMATE.
2. CONTRACTOR SHALL LOCATE THRU POT HOUND ALL UNKNOWN UTILITIES/STRUCTURES PRIOR TO ANY EXCAVATION WORKS & SUBMIT TO APE FOR APPROVAL. A MOST PRACTICAL ALIGNMENT & PROFILE BASED ON ACTUAL LOCATION OF UTILITIES WITHIN THE LIMIT OF ROWS/ADJACENT. CONTRACTOR SHALL RESTORE TO THEIR ORIGINAL CONDITION ALL IMPROVEMENTS DAMAGED AS A RESULT OF THE CONSTRUCTION INCLUDING BUT NOT LIMITED TO PAVEMENTS, SIDEWALK, EMBANKMENTS, STORM DRAIN, SOAK-PI, CURBS, OUTLETS, RAMPS, SIGNS, LANDSCAPING, STRUCTURES, UTILITIES, WALLS, FENCES, ETC. MATCH EXISTING AND TO THE SATISFACTION OF THE OWNER.
3. CONTRACTOR SHALL REMOVE/RELOCATE POWER/COMM. POLE AS REQUIRED.
4. CONTRACTOR SHALL RECORD IN THE AS-BUILT ALL NEW AND EXISTING UTILITIES, STRUCTURES AND ALL APPURTENANCES DISCOVERED BEFORE AND DURING CONSTRUCTION.
5. CONTRACTOR SHALL SECURE AS NECESSARY PERMIT PRIOR TO ANY EXCAVATION WORKS.
6. CONTRACTOR TO SECURE ROW APPROVAL PRIOR TO ANY SITE CLEARING & EXCAVATION.

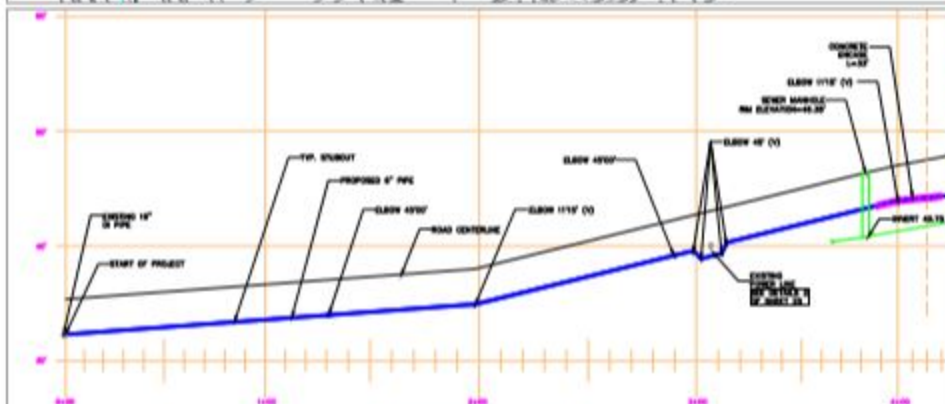

LEGEND:

- W_1 EXIST. WATERMAIN
- W_2 EXIST. 6" PVC WATERMAIN
- EXIST. WATER SERVICE LINE
- S_1 EXIST. SEWER GRAVITY MAIN
- EXIST. UNDERGROUND ASTCA
- SEWER MANHOLE
- UTILITY POLE W/ OVERHEAD POWER LINE
- EXIST. WATER METER
- PROPOSED PVC WATER MAIN
- PROP. 2" SERVICE LINE
- PROP. TEE-FITTINGS
- 11.25 ELBOW
- 22.50 ELBOW
- PROPOSED AIR RELIEF VALVE
- PROPOSED FIRE HYDRANT-PLAN
- PROPOSED GATE VALVE-PLAN



PREPARED BY
PETER JAMES OHN

CHECKED BY
WILLIAM SPITZENBERG, P.E.

APPROVED BY
WILLIAM SPITZENBERG, P.E.

DATE FOR
CONSTRUCTION




PROJECT NAME
HOPE PIPE UPGRADE & REPLACEMENT PROJECT --
COST-U-LESS RD

DRAWING TITLE
PLAN AND PROFILE SHEET 0+00 TO 4+20

PROJECT LOCATION
LUAL, AS 98788

REVISION HISTORY			SCALE
NO.	DATE	DETAILS OF REVISION	BY
			AS SHOWN
			PROJECT #
			SHEET NO.
			15
			35

- DESIGN ALIGNMENT & PROFILE AND APPROXIMATE
- CONTRACTOR SHALL LOCATE AND EXPOSE ALL POTENTIAL AND UNKNOWN UTILITIES/STRUCTURES PRIOR TO ANY EXCAVATION WORKS & SUBMIT THE RESULTS FOR APPROVAL. A MOST PRACTICAL ALIGNMENT & PROFILE BASED ON ACTUAL LOCATION OF UTILITIES SHALL BE THE LIMIT OF WORK EXCAVATION
- CONTRACTOR SHALL RESTORE TO THEIR ORIGINAL CONDITION ALL IMPROVED AREAS EXPOSED AS A RESULT OF THE CONSTRUCTION INCLUDED BUT NOT LIMITED TO PAVEMENTS, SIDEWALKS, LIMBS, CURBS, STORM DRAIN, GROUND, CURBS, GUTTERS, MANHOLE, BURNING, LANDSCAPING, STRUCTURES, UTILITIES, ETC. MATCH EXISTING AND TO THE SATISFACTION OF THE OWNER
- CONTRACTOR SHALL REMOVE/RELOCATE FORMS/COAL POLE AS NEEDED.
- CONTRACTOR SHALL RECORD IN THE AS-BUILT ALL NEW AND EXISTING UTILITIES, STRUCTURES AND ALL APPURTENANCES DISCOVERED BEFORE AND DURING CONSTRUCTION
- CONTRACTOR SHALL SECURE ALL NECESSARY PERMIT PRIOR TO ANY EXCAVATION WORKS
- CONTRACTOR TO SECURE NECESSARY APPROVAL PRIOR TO ANY SITE CLEARING & EXCAVATION

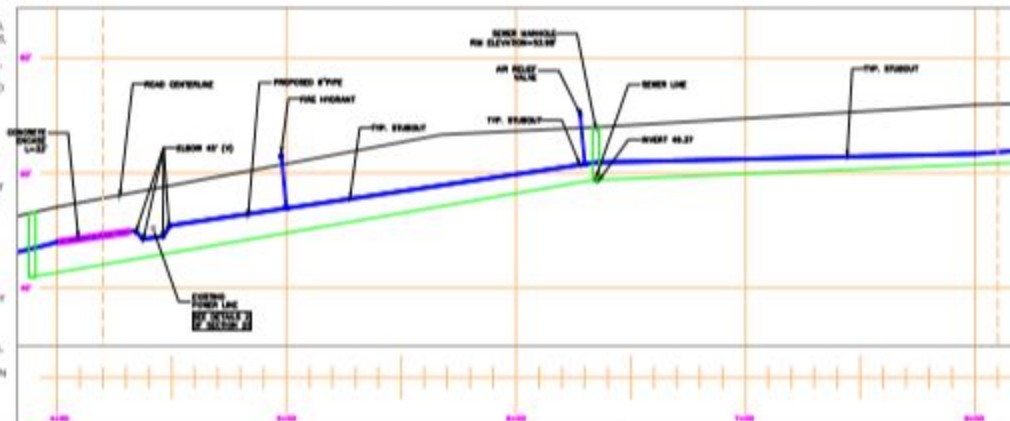

	EXIST. WATERMAIN
	EXIST. 6" PVC WATERMAIN
	EXIST. WATER SERVICE LINE
	EXIST. SEWER GRAVITY MAIN
	EXIST. UNDERGROUND ASTCA
	SEWER MANHOLE
	UTILITY POLE W/ OVHD POWER LINE
	EXIST. WATER METER
	PROPOSED PVC WATER MAIN
	PROP. 2" SERVICE LINE
	PROP. TEE-FITTINGS
	11.25 ELBOW
	22.50 ELBOW
	PROPOSED AIR RELIEF VALVE
	PROPOSED FIRE HYDRANT-PLAN
	PROPOSE GATE VALVE-PLAN




PREPARED BY:	PETER JAMES OHN
CHECKED BY:	WILLIAM SPITZENBERG, P.E.
APPROVED BY:	WILLIAM SPITZENBERG, P.E.
ISSUE FOR:	CONSTRUCTION



PROJECT NAME:	HOPE PIPE UPGRADE & REPLACEMENT PROJECT COST-U-LESS RD
DRAWING TITLE:	PLAN AND PROFILE SHEET 4+20 TO 8+10
PROJECT LOCATION:	USL 48 00790

REVISION HISTORY				SCALE
NO.	DATE	DETAILS OF REVISION	REMOVED BY	AS SHOWN
				PROJECT #
				SHEET NO.
				16
				35

- NOTES:
1. DESIGN ALIGNMENT & PROFILE ARE APPROXIMATE. CONTRACTOR SHALL LOCATE THRU POT-HOLES ALL UNKNOWN UTILITIES/STRUCTURES PRIOR TO ANY EXCAVATION WORKS & SUBMIT TO AISC FOR APPROVAL. A MOST PRACTICAL ALIGNMENT & PROFILE BASED ON ACTUAL LOCATION OF UTILITIES WITHIN THE LIMIT OF ROW LAYOUT.
 2. CONTRACTOR SHALL RESTORE TO THEIR ORIGINAL CONDITION ALL IMPROVEMENTS DAMAGED AS A RESULT OF THE CONSTRUCTION INCLUDING BUT NOT LIMITED TO PAVEMENTS, SIDEWALK, CEMENT/CONCRETE, STORM DRAINS, ROADWAY, CURBS, CUTTERS, RAMP, BENCH, LANDSCAPING, STRUCTURES, UTILITIES, WALLS, FENCES ETC. MATCH EXISTING AND TO THE SATISFACTION OF THE OWNER.
 3. CONTRACTOR SHALL RELOCATE/RELOCATE POWER/COMM. POLES AS NEEDED.
 4. CONTRACTOR SHALL SECURE ALL NECESSARY PERMIT PRIOR TO ANY EXCAVATION WORKS.
 5. CONTRACTOR SHALL SECURE ROW APPROVAL PRIOR TO ANY SITE CLEARING & EXCAVATION.

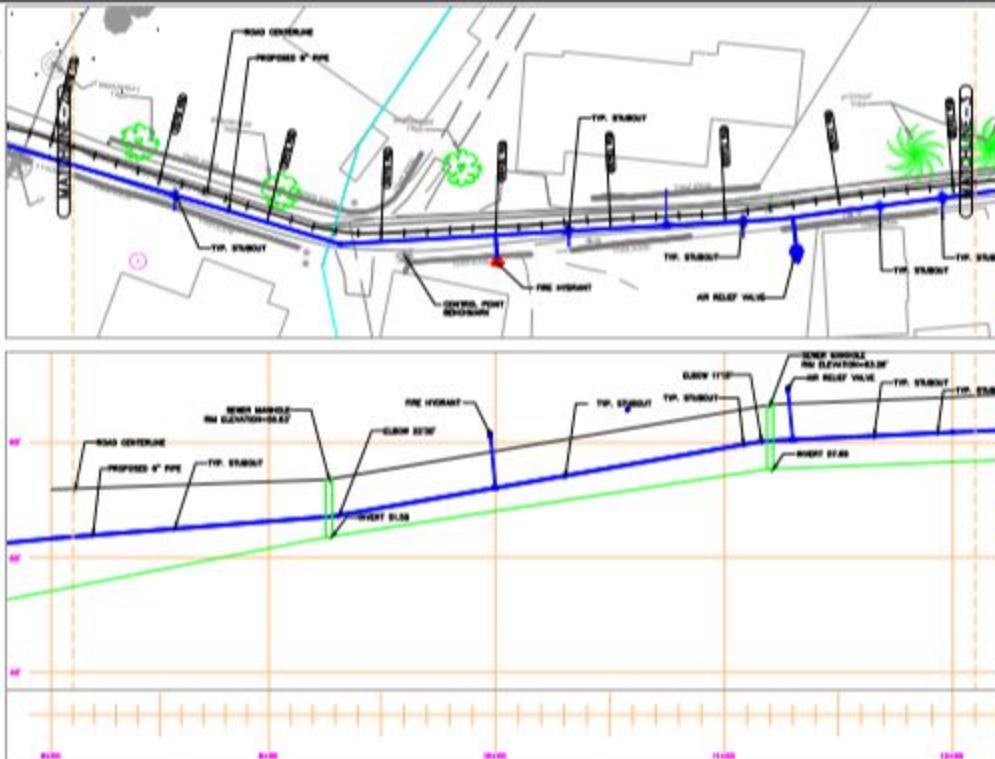

LEGEND:

- EXIST. WATERMAIN
- EXIST. 6" PVC WATERMAIN
- EXIST. WATER SERVICE LINE
- EXIST. SEWER GRAVITY MAIN
- EXIST. UNDERGROUND ASTCA
- SEWER MANHOLE
- UTILITY POLE W/ OVD POWER LINE
- EXIST. WATER METER
- PROPOSED PVC WATER MAIN
- PROP. 2" SERVICE LINE
- PROP. TEE-FITTINGS
- 11.25 ELBOW
- 22.50 ELBOW
- PROPOSED AIR RELIEF VALVE
- PROPOSED FIRE HYDRANT-PLAN
- PROPOSED GATE VALVE-PLAN



PREPARED BY:
PETER JAMES CHIN

CHECKED BY:
WILLIAM SPITZENBERG, P.E.

APPROVED BY:
WILLIAM SPITZENBERG, P.E.

SCALE FOR:
CONSTRUCTION





PROJECT NAME:
HOPE PIPE UPGRADE & REPLACEMENT PROJECT -
COST-U-LESS RD

DRAWING TITLE:
PLAN AND PROFILE SHEET 8+10 TO 12+10

PROJECT LOCATION:
CALI, AS 98799

REVISION HISTORY			SCALE
NO.	DATE	DETAILS OF REVISION	REVIEWED BY
			AS 11/10/23
			PROJECT #
			SHEET NO.
			17
			35

- NOTES:
1. DESIGN ALIGNMENT & PROFILES ARE APPROPRIATE.
 2. CONTRACTOR SHALL LOCATE THIS POT HOLE IN ALL UNKNOWN UTILITIES STRUCTURES PRIOR TO ANY EXCAVATION WORKS & SUBMIT TO APE FOR APPROVAL. A MOST PRACTICAL ALIGNMENT & PROFILE BASE ON ACTUAL LOCATION OF UTILITIES WITHIN THE LIMIT OF ROW EASEMENT.
 3. CONTRACTOR SHALL RESTORE TO THEIR ORIGINAL CONDITION ALL IMPROVEMENTS DAMAGED AS A RESULT OF THE CONSTRUCTION INCLUDING BUT NOT LIMITED TO PAVEMENTS, SIDEWALK, EMBANKMENTS, STORM DRAIN, SOAK-PIT, CUMBS, CUTTERS, HAMPS, BOMS, LANDSCAPING, STRUCTURES, UTILITIES, WALLS, FENCES, ETC. MATCH EXISTING AND TO THE SATISFACTION OF THE OWNER.
 4. CONTRACTOR SHALL REMOVE/RELOCATE POWER/COMM. POLE AS NEEDED.
 5. CONTRACTOR SHALL RECORD IN THE AS-BUILT ALL NEW AND EXISTING UTILITIES, STRUCTURES AND ALL APPURTENANCES DISCOVERED BEFORE AND DURING CONSTRUCTION.
 6. CONTRACTOR SHALL SECURE ALL NECESSARY PERMIT PRIOR TO ANY EXCAVATION WORKS.
 7. CONTRACTOR TO SECURE ROW APPROVAL PRIOR TO ANY SITE CLEARING & EXCAVATION.

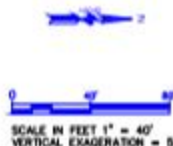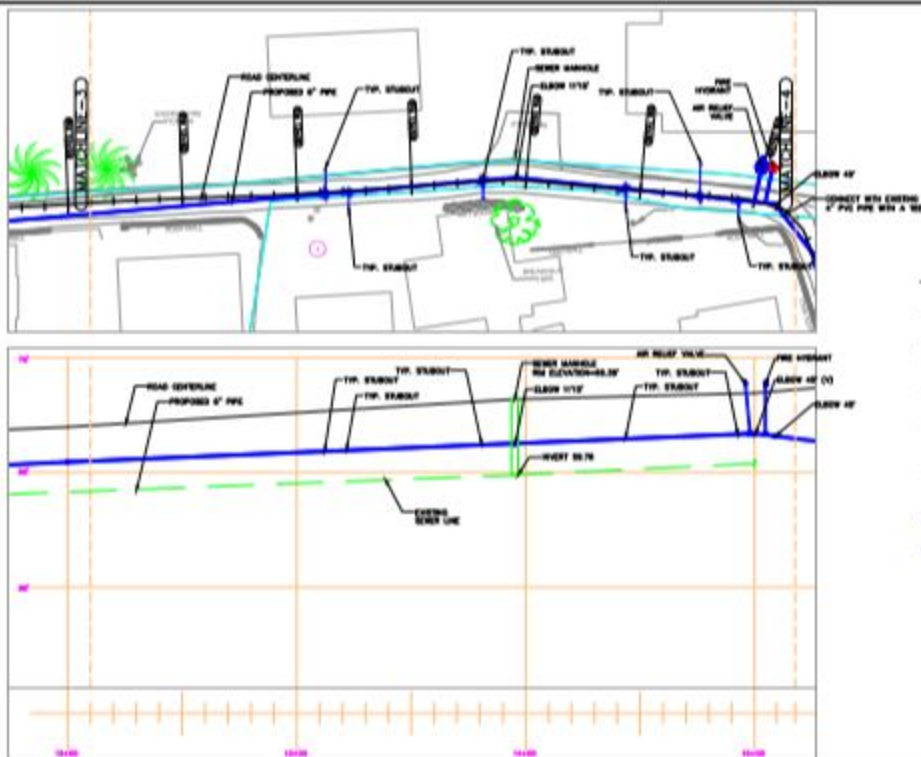

LEGEND:

- W_2 EXIST. WATERMAIN
- W_6 EXIST. 6" PVC WATERMAIN
- EXIST. WATER SERVICE LINE
- EXIST. SEWER GRAVITY MAIN
- EXIST. UNDERGROUND ASTCA
-  SEWER MANHOLE
-  UTILITY POLE W/ O/HV POWER LINE
-  EXIST. WATER METER
- PROPOSED PVCD WATER MAIN
- PROP. 2" SERVICE LINE
-  PROP. TEE-FITTINGS
-  11.25 ELBOW
-  22.50 ELBOW
-  PROPOSED AIR RELIEF VALVE
-  PROPOSED FIRE HYDRANT-PLAN
-  PROPOSED GATE VALVE-PLAN



PREPARED BY:
PETER JAMES CHIN

CHECKED BY:
WILLIAM SPITZBERG, P.E.

APPROVED BY:
WILLIAM SPITZBERG, P.E.

BOOK FOR
CONSTRUCTION



PROJECT NAME:
HOPE PIPE UPGRADE & REPLACEMENT PROJECT -
COST-U-LESS RD


DRAWING TITLE:
PLAN AND PROFILE SHEET 13+10 TO 15+20

PROJECT LOCATION:
URL, AS 98789

REVISION HISTORY				SCALE:
NO.	DATE	DETAILS OF REVISION	REVIEWED BY	AS SHOWN
				PROJECT #
				SHEET NO.
				18
				35

NOTES:

1. DESIGN ALIGNMENT & PROFILE ARE APPROXIMATE. CONTRACTOR SHALL LOCATE THRU POT-HOLES ALL UNKNOWN UTILITIES/STRUCTURES PRIOR TO ANY EXCAVATION WORKS & SUBMIT TO A/E FOR APPROVAL. A MOST PRACTICAL ALIGNMENT & PROFILE BASED ON ACTUAL LOCATION OF UTILITIES WITHIN THE LIMIT OF ROW EASEMENT.
2. CONTRACTOR SHALL RESTORE TO THEIR ORIGINAL CONDITION ALL IMPROVEMENTS DAMAGED AS A RESULT OF THE CONSTRUCTION INCLUDING BUT NOT LIMITED TO: PAVEMENTS, SIDEWALK, EMBANKMENTS, STORM DRAINS, ROADSIDE, CURBS, GUTTERS, RAMP, BENCH, LANDSCAPING, STRUCTURES, UTILITIES, WALLS, FENCES, ETC. MATCH EXISTING AND TO THE SATISFACTION OF THE OWNER.
3. CONTRACTOR SHALL REMOVE/RELOCATE POWER/COMM. POLE AS NEEDED.
4. CONTRACTOR SHALL RECORD IN THE AS-BUILT ALL NEW AND EXISTING UTILITIES, STRUCTURES AND ALL APPURTENANCES DISCOVERED BEFORE AND DURING CONSTRUCTION.
5. CONTRACTOR SHALL SECURE ALL NECESSARY PERMIT PRIOR TO ANY EXCAVATION WORKS.
6. CONTRACTOR SHALL SECURE ROW APPROVAL PRIOR TO ANY SITE CLEARING & EXCAVATION.

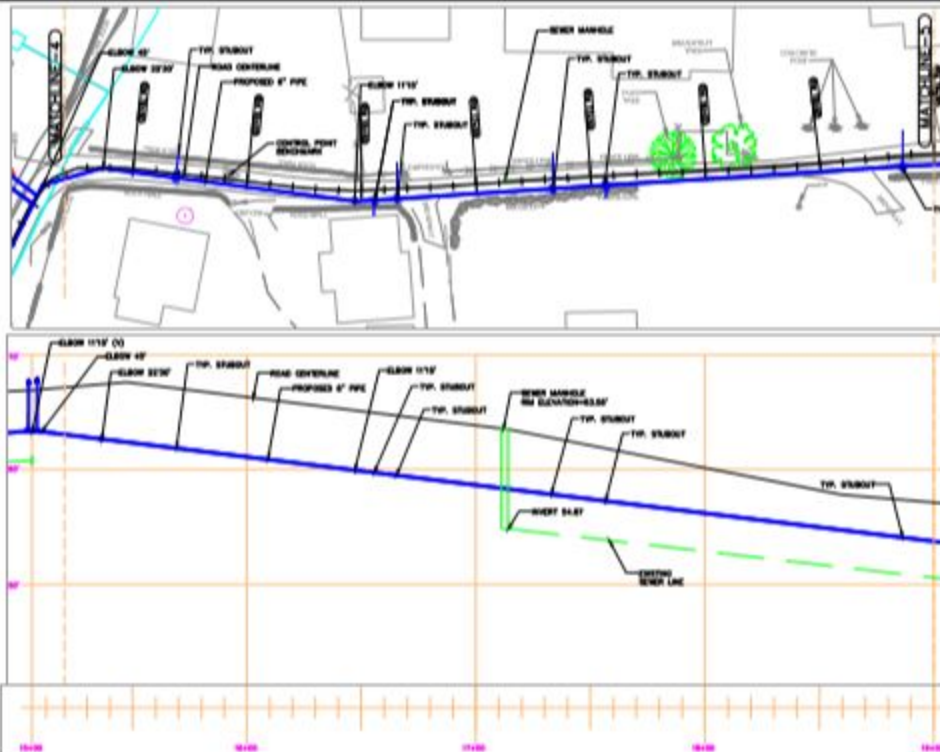

LEGEND

- W_6 EXST. WATERMAIN
- EXST. 6" PVC WATERMAIN
- EXST. WATER SERVICE LINE
- S_6 EXST. SEWER GRAVITY MAIN
- EXST. UNDERGROUND ASTCA
- SEWER MANHOLE
- UTILITY POLE W/ O/H/D POWER LINE
- EXST. WATER METER
- PROPOSED PVC WATER MAIN
- PROP. 2" SERVICE LINE
- PROP. TEE-FITTINGS
- 11.25' ELBOW
- 22.50' ELBOW
- PROPOSED AIR RELIEF VALVE
- PROPOSED FIRE HYDRANT-PLAN
- PROPOSED GATE VALVE-PLAN



PREPARED BY
PETER JAMES CHIN

DRAWN BY
WILLIAM SPITZENBERG, P.E.

APPROVED BY
WILLIAM SPITZENBERG, P.E.

DATE FOR
CONSTRUCTION



PROJECT NAME
HOPE PIPE UPGRADE & REPLACEMENT PROJECT -
COST-U-LESS RD



DRAWING TITLE
PLAN AND PROFILE SHEET 15+00 TO 18+00

PROJECT LOCATION
I-94, AS 90799

REVISION HISTORY			SCALE
NO.	DATE	DETAILS OF REVISION	REVIEWED BY
			AS SHOWN
			PROJECT #
			SHEET NO.
			19
			35

NOTES:

- DESIGN ALIGNMENT & PROFILE ARE APPROXIMATE. CONTRACTOR SHALL LOCATE THRU POT-HOLING ALL UNKNOWN UTILITIES/STRUCTURES PRIOR TO ANY EXCAVATION WORKS & SUBMIT TO APE FOR APPROVAL. A MOST PRACTICAL ALIGNMENT & PROFILE BASED ON ACTUAL LOCATION OF UTILITIES WITHIN THE LIMIT OF ROW CASEMENT.
- CONTRACTOR SHALL RESTORE TO THEIR ORIGINAL CONDITION ALL IMPROVEMENTS DAMAGED AS A RESULT OF THE CONSTRUCTION WORK INCLUDING BUT NOT LIMITED TO: PAVEMENTS, SIDEWALK, EMBANKMENTS, STORM DRAIN, SOAK-PIT, CURBS, GUTTERS, RAMP, SIGNS, LANDSCAPING, STRUCTURES, UTILITIES, WALLS, FENCES, ETC. MATCH EXISTING AND TO THE SATISFACTION OF THE OWNER.
- CONTRACTOR SHALL HERETOFORE LOCATE POWER/COMM. POLE AS NEEDED.
- CONTRACTOR SHALL RECORD IN THE AS-BUILT ALL NEW AND EXISTING UTILITIES, STRUCTURES AND ALL APPURTENANCES DISCOVERED BEFORE AND DURING CONSTRUCTION.
- CONTRACTOR SHALL SECURE AS NECESSARY PERMIT PRIOR TO ANY EXCAVATION WORKS.
- CONTRACTOR TO SECURE ROW APPROVAL PRIOR TO ANY SITE CLEARING & EXCAVATION.

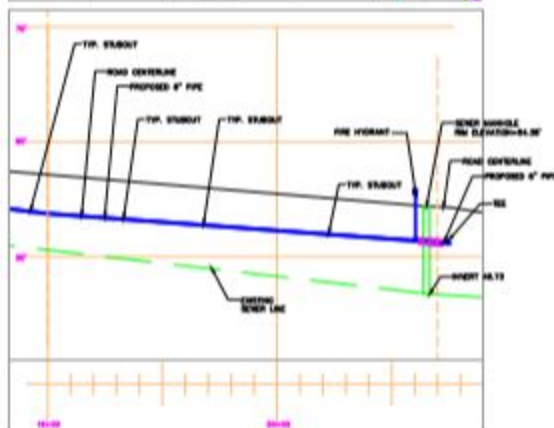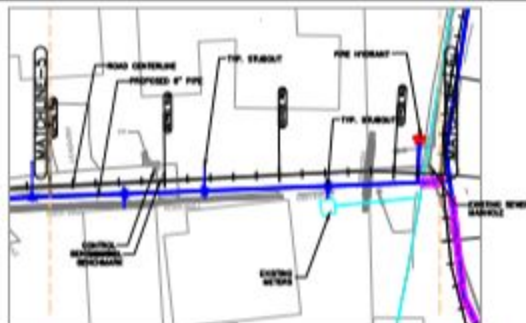

SCALE IN FEET 1" = 40'
VERTICAL EXAGGERATION = 5

LEGEND:

- EXIST. WATERMAIN
- EXIST. 6" PVC WATERMAIN
- EXIST. WATER SERVICE LINE
- EXIST. SEWER GRAVITY MAIN
- EXIST. UNDERGROUND ASTCA
- SEWER MANHOLE
- UTILITY POLE W/ O/HV POWER LINE
- EXIST. WATER METER
- PROPOSED PVC80 WATER MAIN
- PROP. 2" SERVICE LINE
- PROP. TEE-FITTINGS
- 11.25 ELBOW
- 22.50 ELBOW
- PROPOSED AIR RELIEF VALVE
- PROPOSED FIRE HYDRANT-PLAN
- PROPOSED GATE VALVE-PLAN



PREPARED BY:
PETER JAMES CHIN

DRAWN BY:
WILLIAM SPITZBERG, P.E.

APPROVED BY:
WILLIAM SPITZBERG, P.E.

DATE FOR
CONSTRUCTION





PROJECT NAME:
HOPE PIPE UPGRADE & REPLACEMENT PROJECT -
COST-U-LESS RD

DRAWING TITLE:
PLAN AND PROFILE SHEET 10+00 TO 20+70

PROJECT LOCATION:
RUL, AS 00799

REVISION HISTORY:

NO.	DATE	DETAILS OF REVISION	REVIEWED BY	SEAL
				AS SHOWN
				PROJECT #
				SHEET NO.
				20
				35

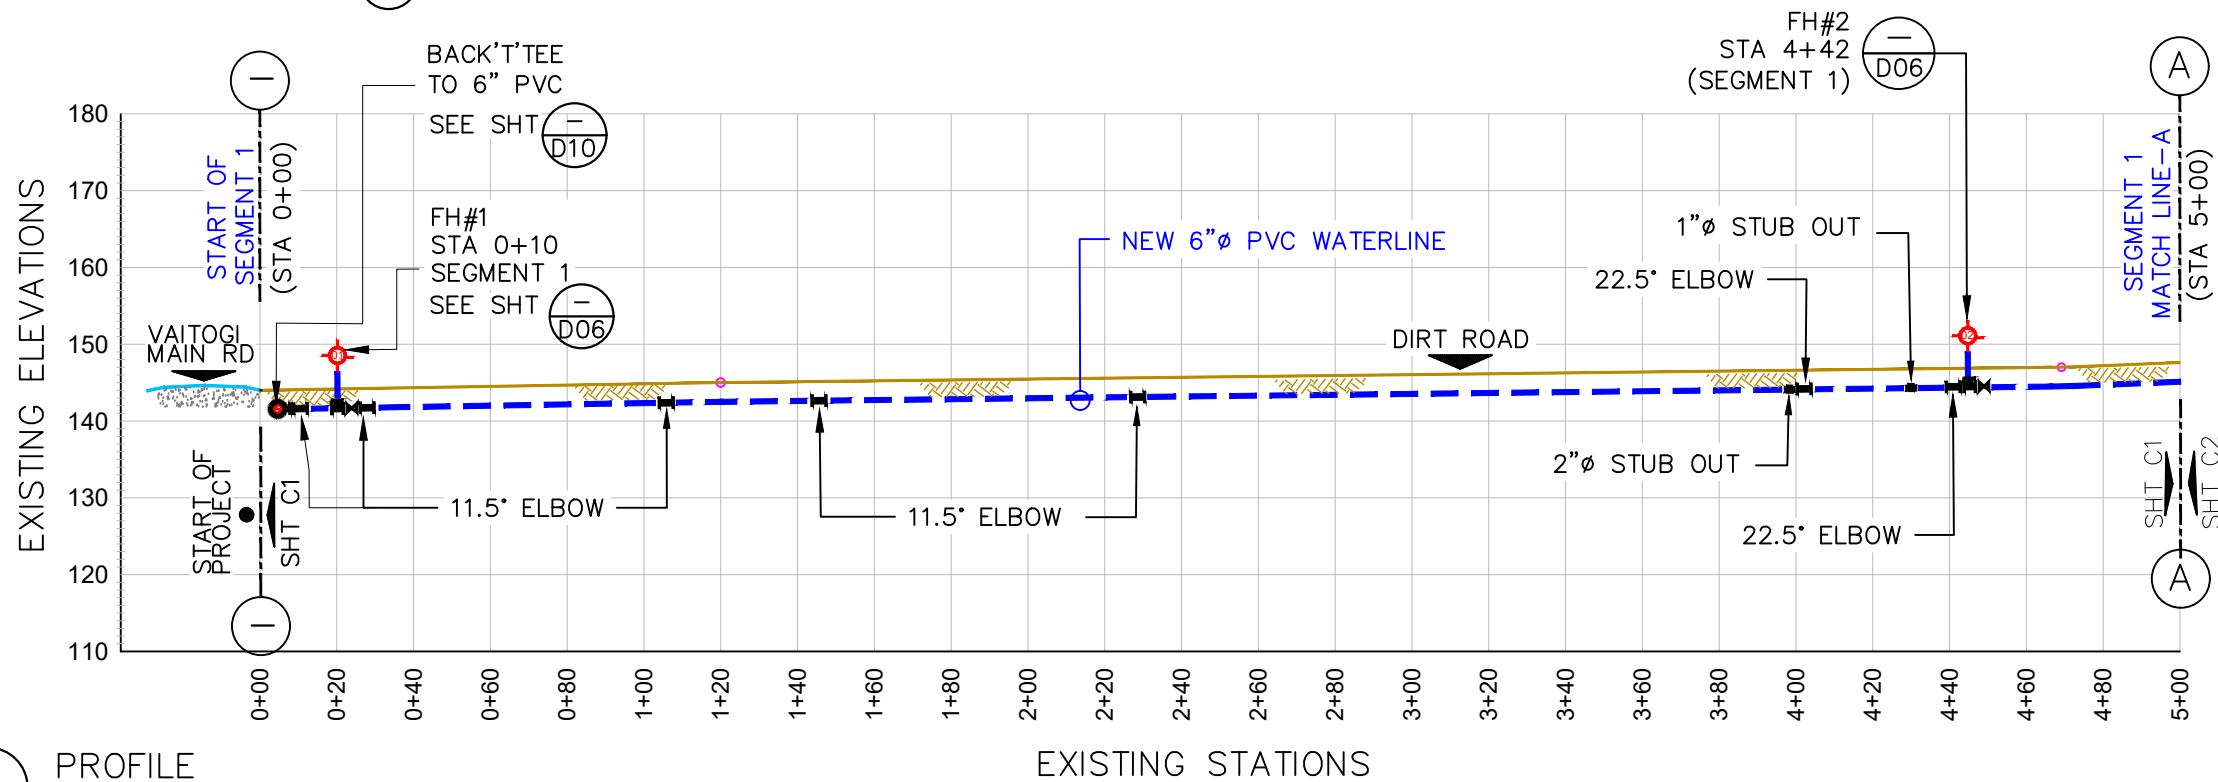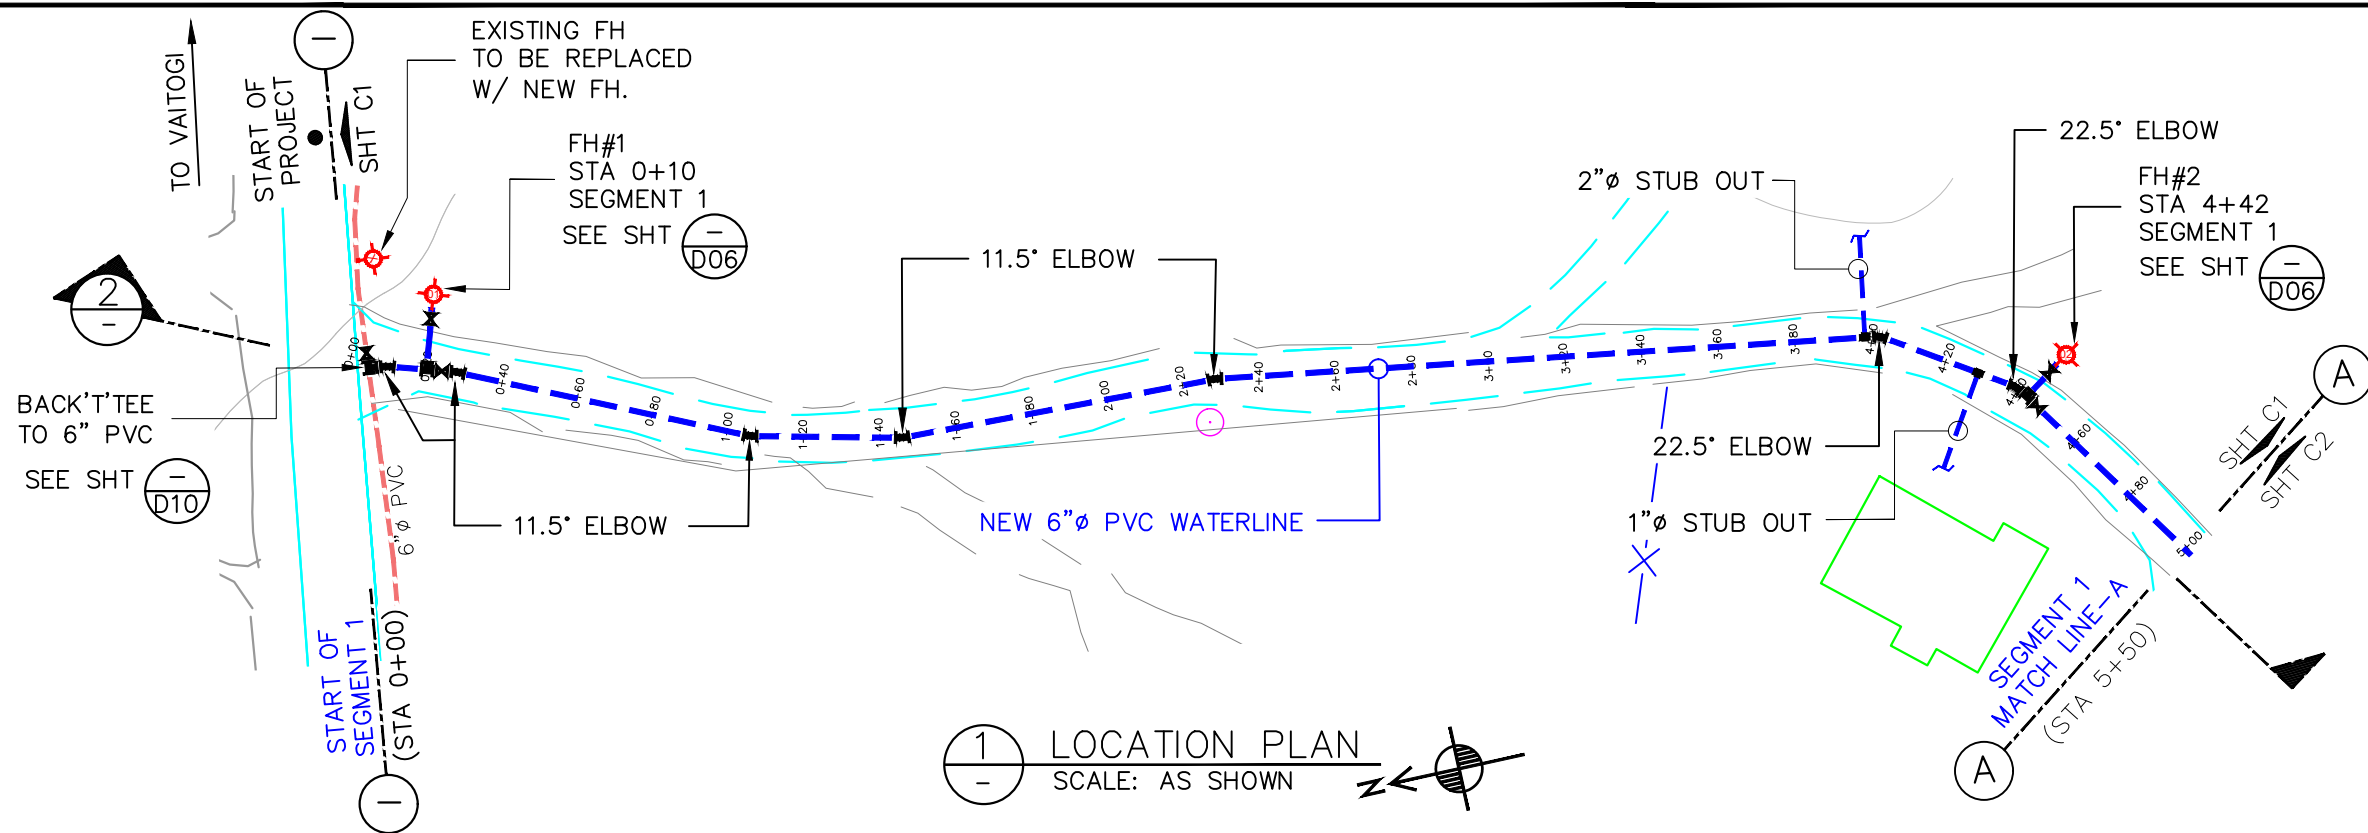


LEGEND:	
EXISTING WATER SERVICE:	
EXISTING ACP WATER:	
NEW 6" PVC WATER:	
TELEPHONE CONDUIT:	
EXISTING STORM DRAIN:	
EXISTING SEWER MAIN:	
GATE VALVE:	
POWER/TEL POLE:	
AIR RELIEVE VALVE:	
ELBOWS:	
11.25°	
22.5°	
45°	
90°	
BACK TEE	
FIRE HYDRANT:	
BAC-T SAMPLING STN:	
SERVICE METER:	
STUB-OUT:	
PRV / PSV :	
EXISTING SERVICE LINE TRANSFERRED TO NEW LINE:	
TREES:	
HEDGES:	
ROCK WALL:	
WIRE FENCE:	

NOTES:
CONSTRUCTION CONTRACTOR SHALL FIELD VERIFY ALL EXISTING UNDERGROUND INFRASTRUCTURE TO ENSURE SAFETY OF ITS WORKERS AND AVOID ANY DAMAGES TO EXISTING GOVERNMENT UTILITIES.

ALL EXISTING FIRE HYDRANT TO BE TRANSFERRED TO NEW LINE.
SEE SHT-D06 FOR FIRE HYDRANT CONNECTION DETAILS.

INSTALL 2"x6" SADDLE FOR NEW SERVICE CONNECTION @ EVERY 500 FEET

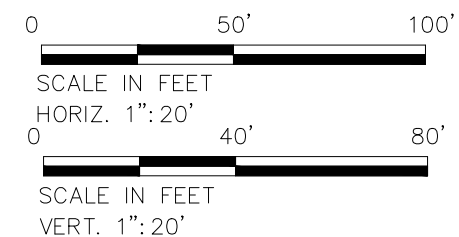

2 PROFILE
SCALE: AS SHOWN

No.	Description	Date

REV. NO.:	
REVISION:	
CHECKED BY:	
APPROVED BY:	
DATE:	

DESIGNED BY:	F.Toala
CHECKED BY:	L.Tyrell
APPROVED BY:	F.Aquila / L.Tyrell
ISSUE FOR:	Construction



AMERICAN SAMOA POWER AUTHORITY

AMERICAN SAMOA POWER AUTHORITY
ENGINEERING SERVICES DIVISION

P.O.BOX PPB, TAFUNA, PAGO PAGO, AS 96799


PROJECT NAME:
PHASE 3
VAITOGI HDPE PIPE REPLACEMENT
WATERLINE PROJECT

DRAWING TITLE:
SEGMENT 1 START
PLAN & PROFILE (STA, 0+00 TO 5+00)

PROJECT LOCATION:
VAITOGI VILLAGE, AMERICAN SAMOA

PROJECT NO:	#1658785
SIGNATURE:	
DATE:	

SCALE:	AS SHOWN
DATE:	JAN-2024
SHEET NO.	C01

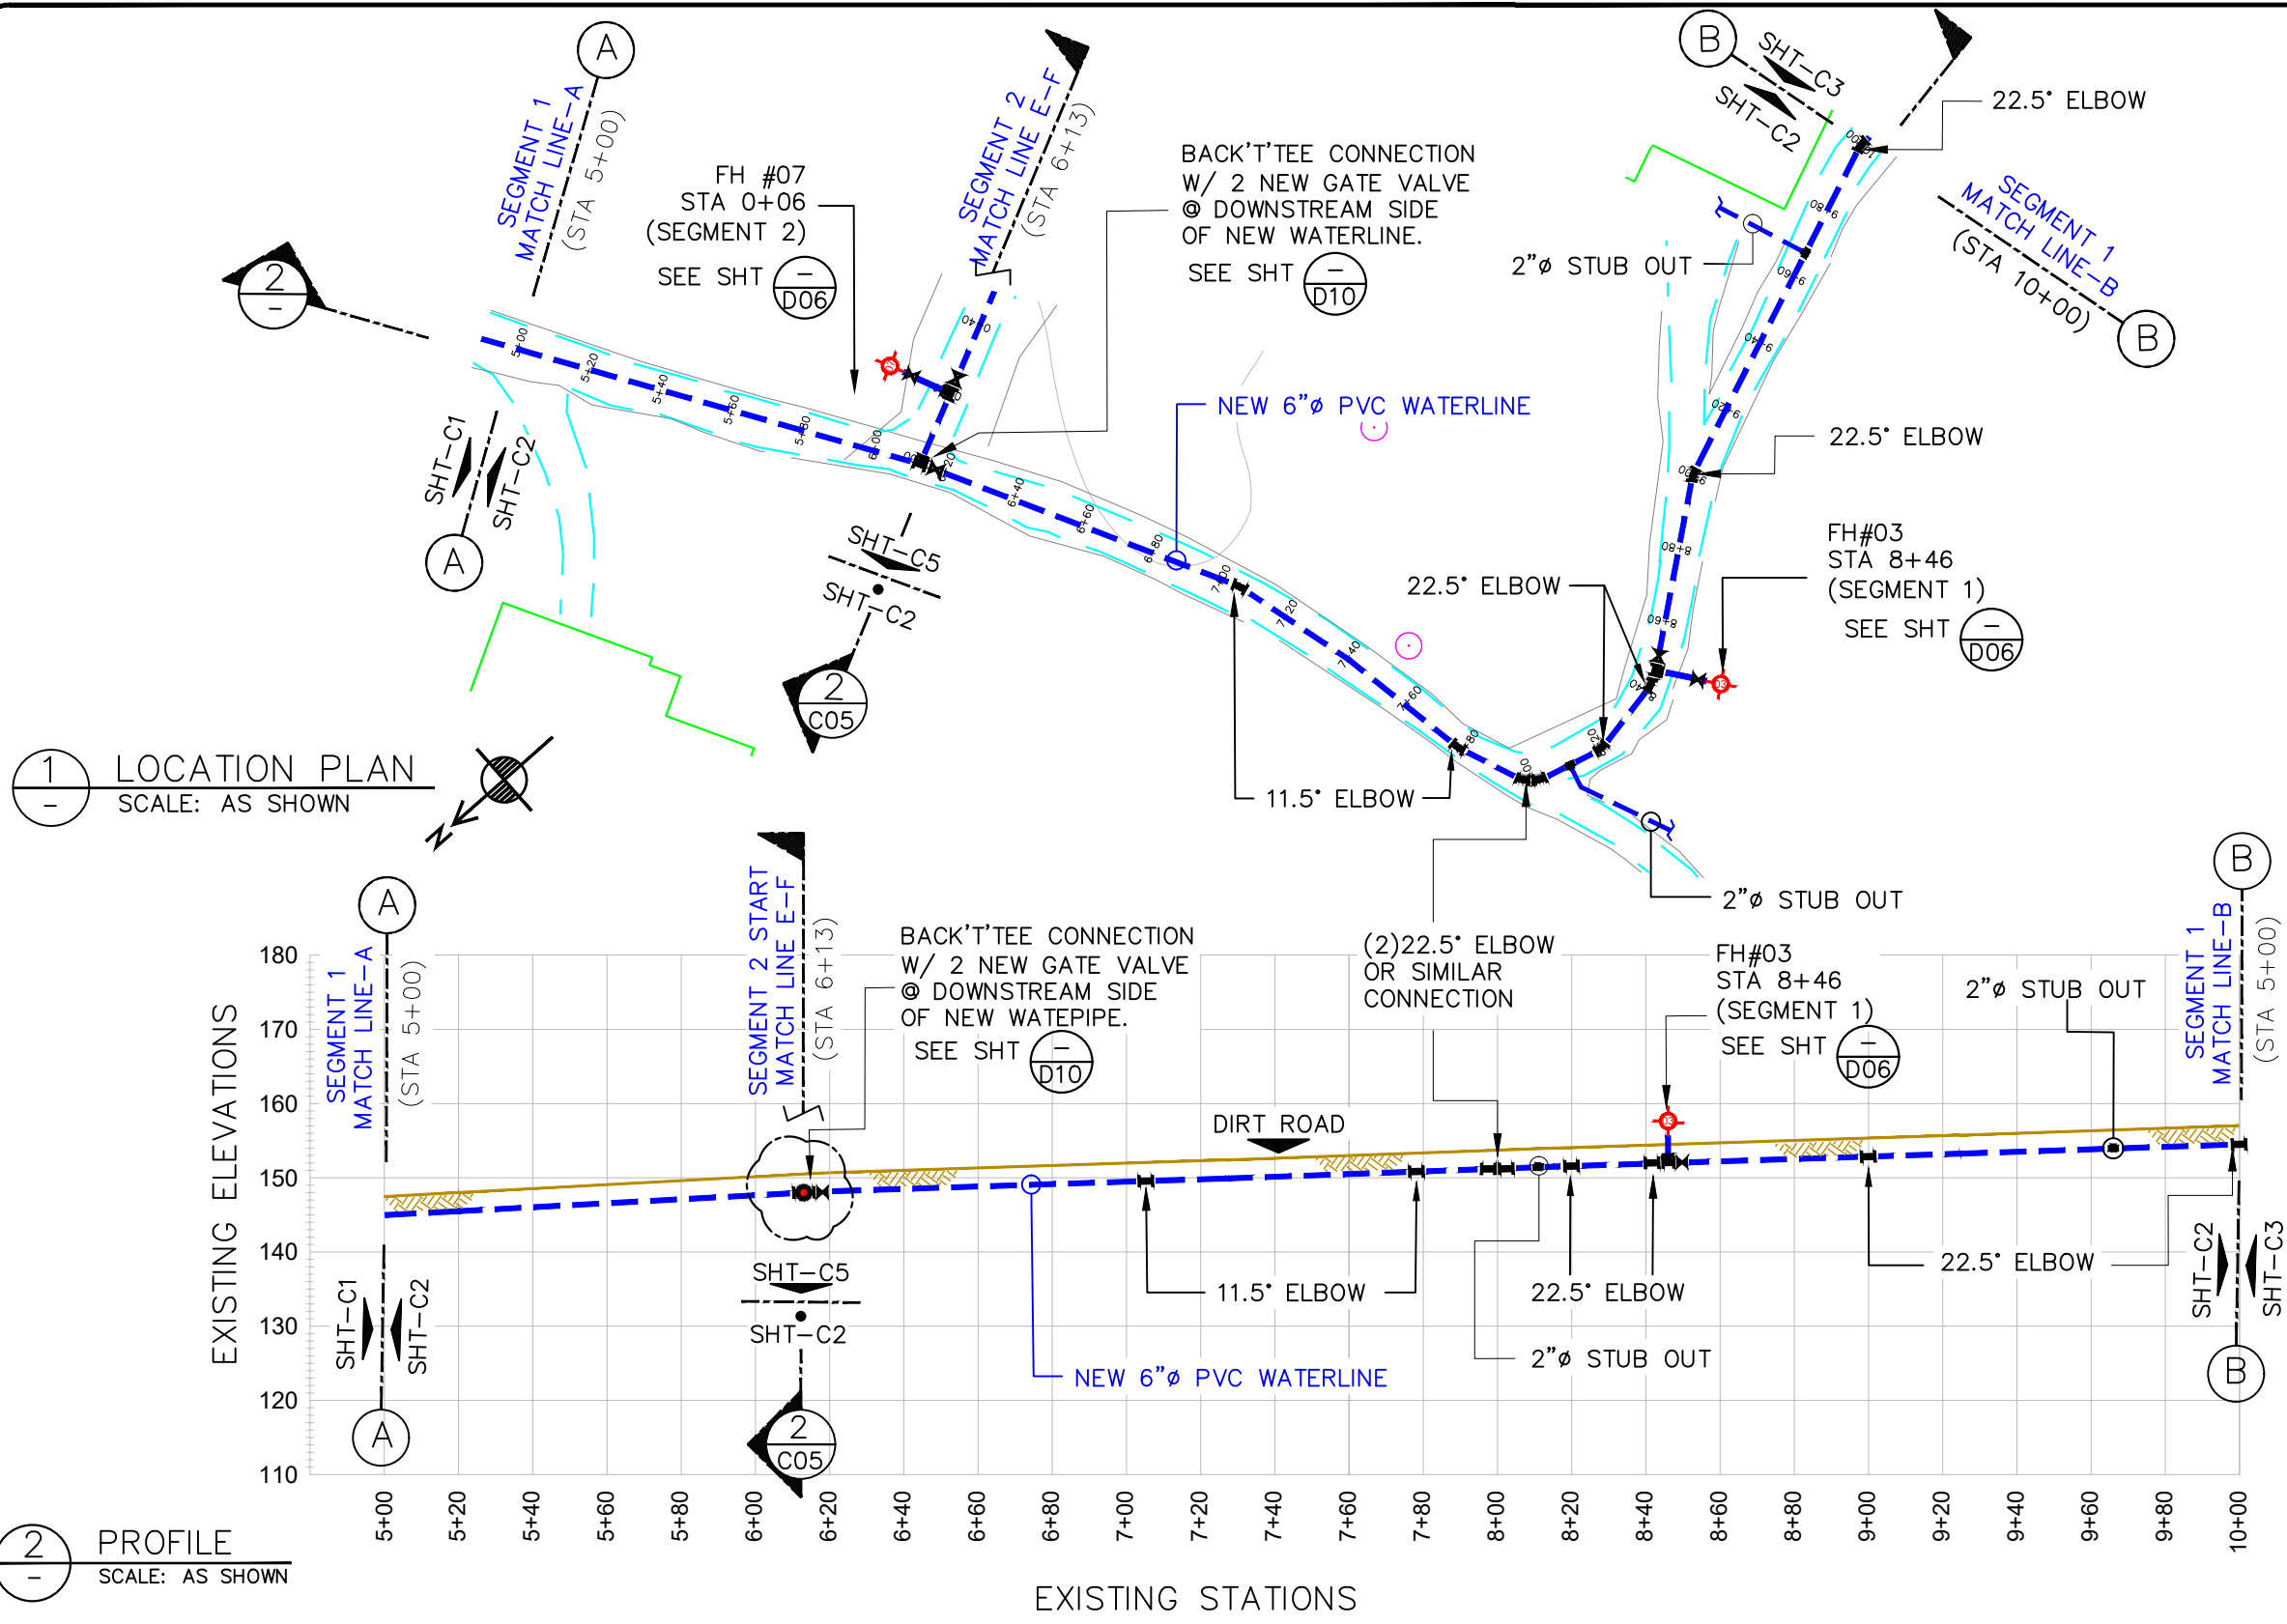


LEGEND:	
EXISTING WATER SERVICE:	
EXISTING ACP WATER:	
NEW 6" PVC WATER:	
TELEPHONE CONDUIT:	
EXISTING STORM DRAIN:	
EXISTING SEWER MAIN:	
GATE VALVE:	
POWER/TEL POLE:	
AIR RELIEVE VALVE:	
ELBOWS:	
11.25°	
22.5°	
45°	
90°	
BACK TEE	
FIRE HYDRANT:	
BAC-T SAMPLING STN:	
SERVICE METER:	
STUB-OUT:	
PRV / PSV :	
EXISTING SERVICE LINE TRANSFERRED TO NEW LINE:	
TREES:	
HEDGES:	
ROCK WALL:	
WIRE FENCE:	

NOTES:
CONSTRUCTION CONTRACTOR SHALL FIELD VERIFY ALL EXISTING UNDERGROUND INFRASTRUCTURE TO ENSURE SAFETY OF ITS WORKERS AND AVOID ANY DAMAGES TO EXISTING GOVERNMENT UTILITIES.

ALL EXISTING FIRE HYDRANT TO BE TRANSFERRED TO NEW LINE.
SEE SHT-D06 FOR FIRE HYDRANT CONNECTION DETAILS.

INSTALL 2"x6" SADDLE FOR NEW SERVICE CONNECTION @ EVERY 500 FEET

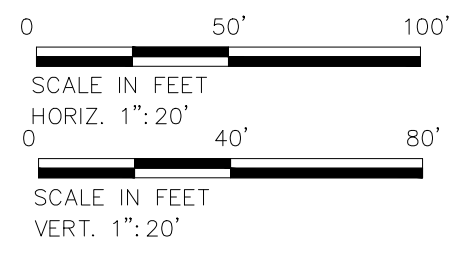

No.	Description	Date


REV. NO.:	DESIGNED BY:
	F.Toala
REVISION:	CHECKED BY:
	L.Tyrell
CHECKED BY:	APPROVED BY:
	F.Aquila / L.Tyrell
APPROVED BY:	ISSUE FOR:
	Construction
DATE:	




AMERICAN SAMOA POWER AUTHORITY
ENGINEERING SERVICES DIVISION
P.O.BOX PPB, TAFUNA, PAGO PAGO, AS 96799

PROJECT NAME:
PHASE 3 VAITOGI HDPE PIPE REPLACEMENT WATERLINE PROJECT
DRAWING TITLE:
SEGMENT 1 PLAN & PROFILE (STA, 5+00 TO 10+00)
PROJECT LOCATION:
VAITOGI VILLAGE, AMERICAN SAMOA

PROJECT NO:	SCALE:
#1958785	AS SHOWN
SIGNATURE:	DATE:
	JAN-2024
DATE:	SHEET NO.
	C02

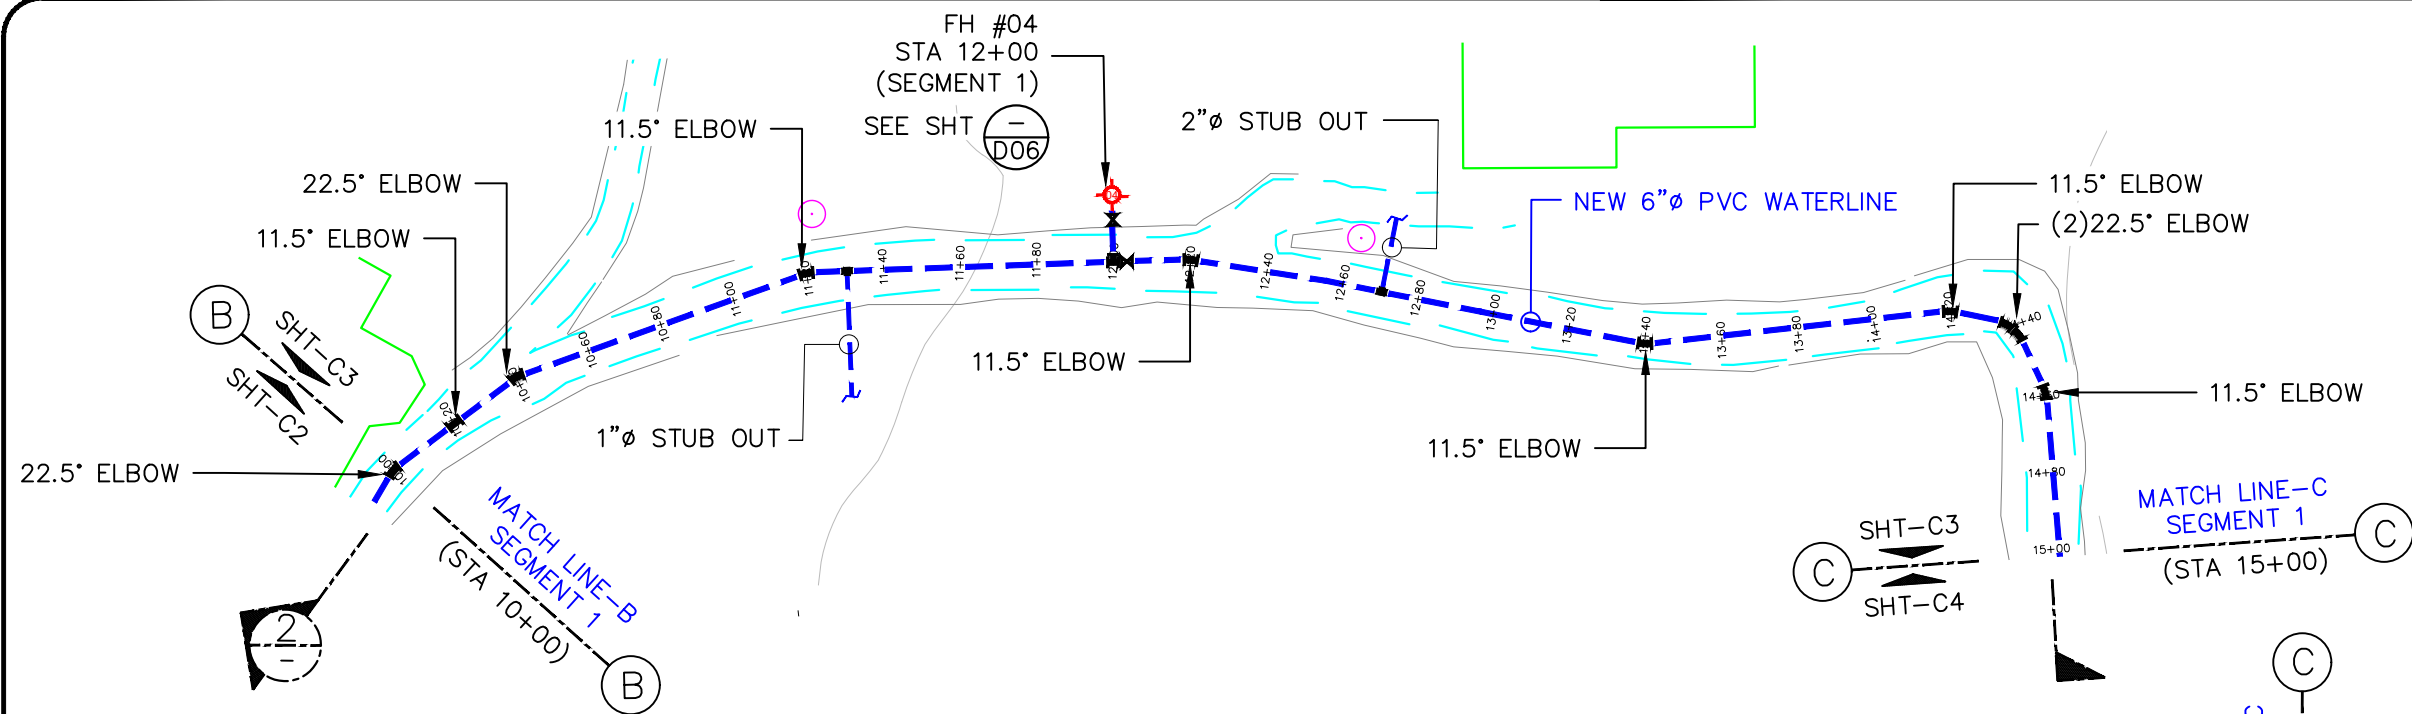

1 LOCATION PLAN
SCALE: AS SHOWN

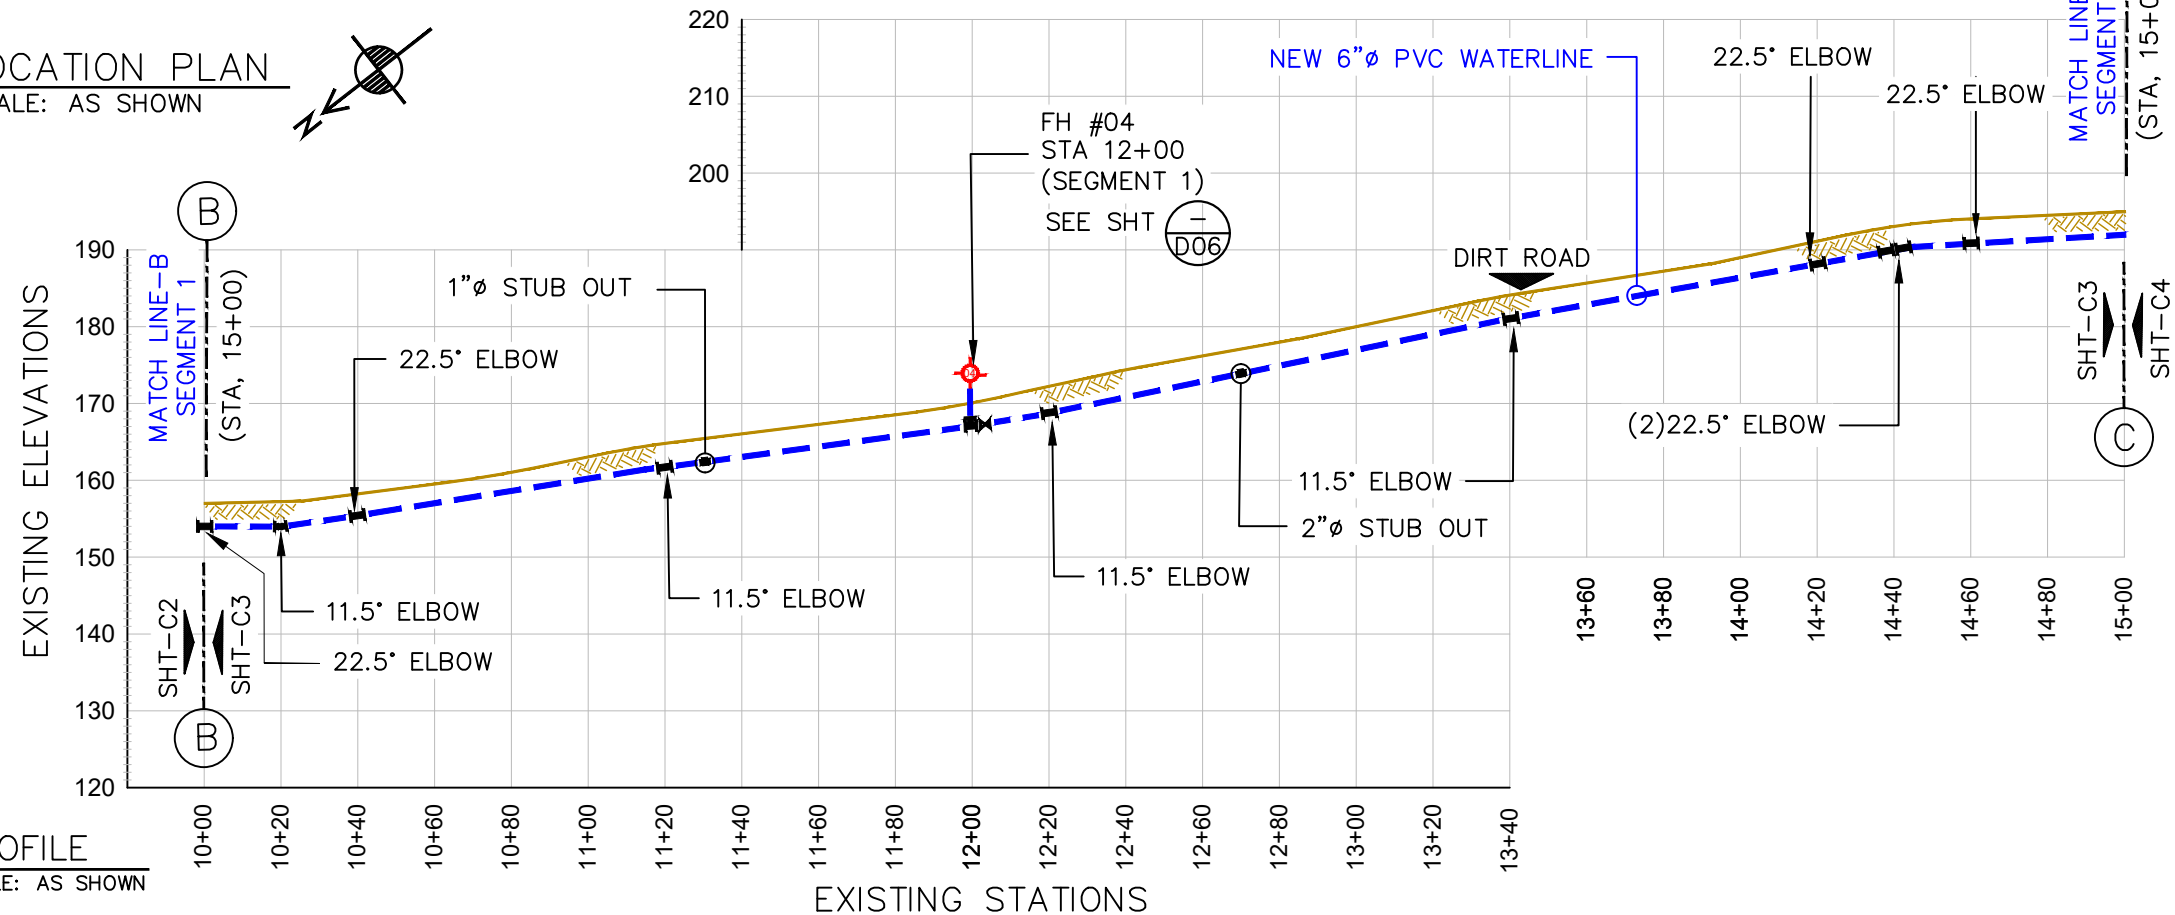


2 PROFILE
SCALE: AS SHOWN

LEGEND:	
EXISTING WATER SERVICE:	
EXISTING ACP WATER:	
NEW 6" PVC WATER:	
TELEPHONE CONDUIT:	
EXISTING STORM DRAIN:	
EXISTING SEWER MAIN:	
GATE VALVE:	
POWER/TEL POLE:	
AIR RELIEVE VALVE:	
ELBOWS:	11.25° 22.5° 45° 90° BACK TEE
FIRE HYDRANT:	
BAC-T SAMPLING STN:	
SERVICE METER:	
STUB-OUT:	
PRV / PSV :	
EXISTING SERVICE LINE TRANSFERRED TO NEW LINE:	
TREES:	
HEDGES:	
ROCK WALL:	
WIRE FENCE:	

NOTES:
CONSTRUCTION CONTRACTOR SHALL FIELD VERIFY ALL EXISTING UNDERGROUND INFRASTRUCTURE TO ENSURE SAFETY OF ITS WORKERS AND AVOID ANY DAMAGES TO EXISTING GOVERNMENT UTILITIES.

ALL EXISTING FIRE HYDRANT TO BE TRANSFERRED TO NEW LINE.
SEE SHT-DO6 FOR FIRE HYDRANT CONNECTION DETAILS.

INSTALL 2"Øx6"Ø SADDLE FOR NEW SERVICE CONNECTION @ EVERY 500 FEET

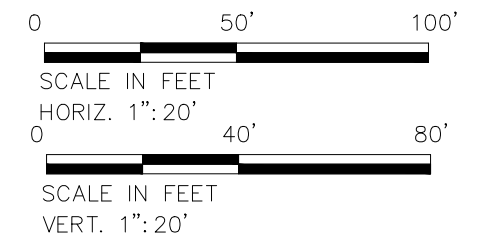

No.	Description	Date

REV. NO.:	
REVISION:	
CHECKED BY:	
APPROVED BY:	
DATE:	

DESIGNED BY:	F.Toala
CHECKED BY:	L.Tyrell
APPROVED BY:	F.Aquila / L.Tyrell
ISSUE FOR:	Construction



AMERICAN SAMOA POWER AUTHORITY

AMERICAN SAMOA POWER AUTHORITY
ENGINEERING SERVICES DIVISION

P.O.BOX PPB, TAFUNA, PAGO PAGO, AS 96799

PROJECT NAME:
PHASE 3
VAITOGI HDPE PIPE REPLACEMENT
WATERLINE PROJECT

DRAWING TITLE:
SEGMENT 1
PLAN & PROFILE (STA, 10+00 TO 15+00)

PROJECT LOCATION:
VAITOGI VILLAGE, AMERICAN SAMOA

PROJECT NO:
#1658785


SIGNATURE:

DATE:

SCALE:
AS SHOWN

DATE:
JAN-2024

SHEET NO.
C03

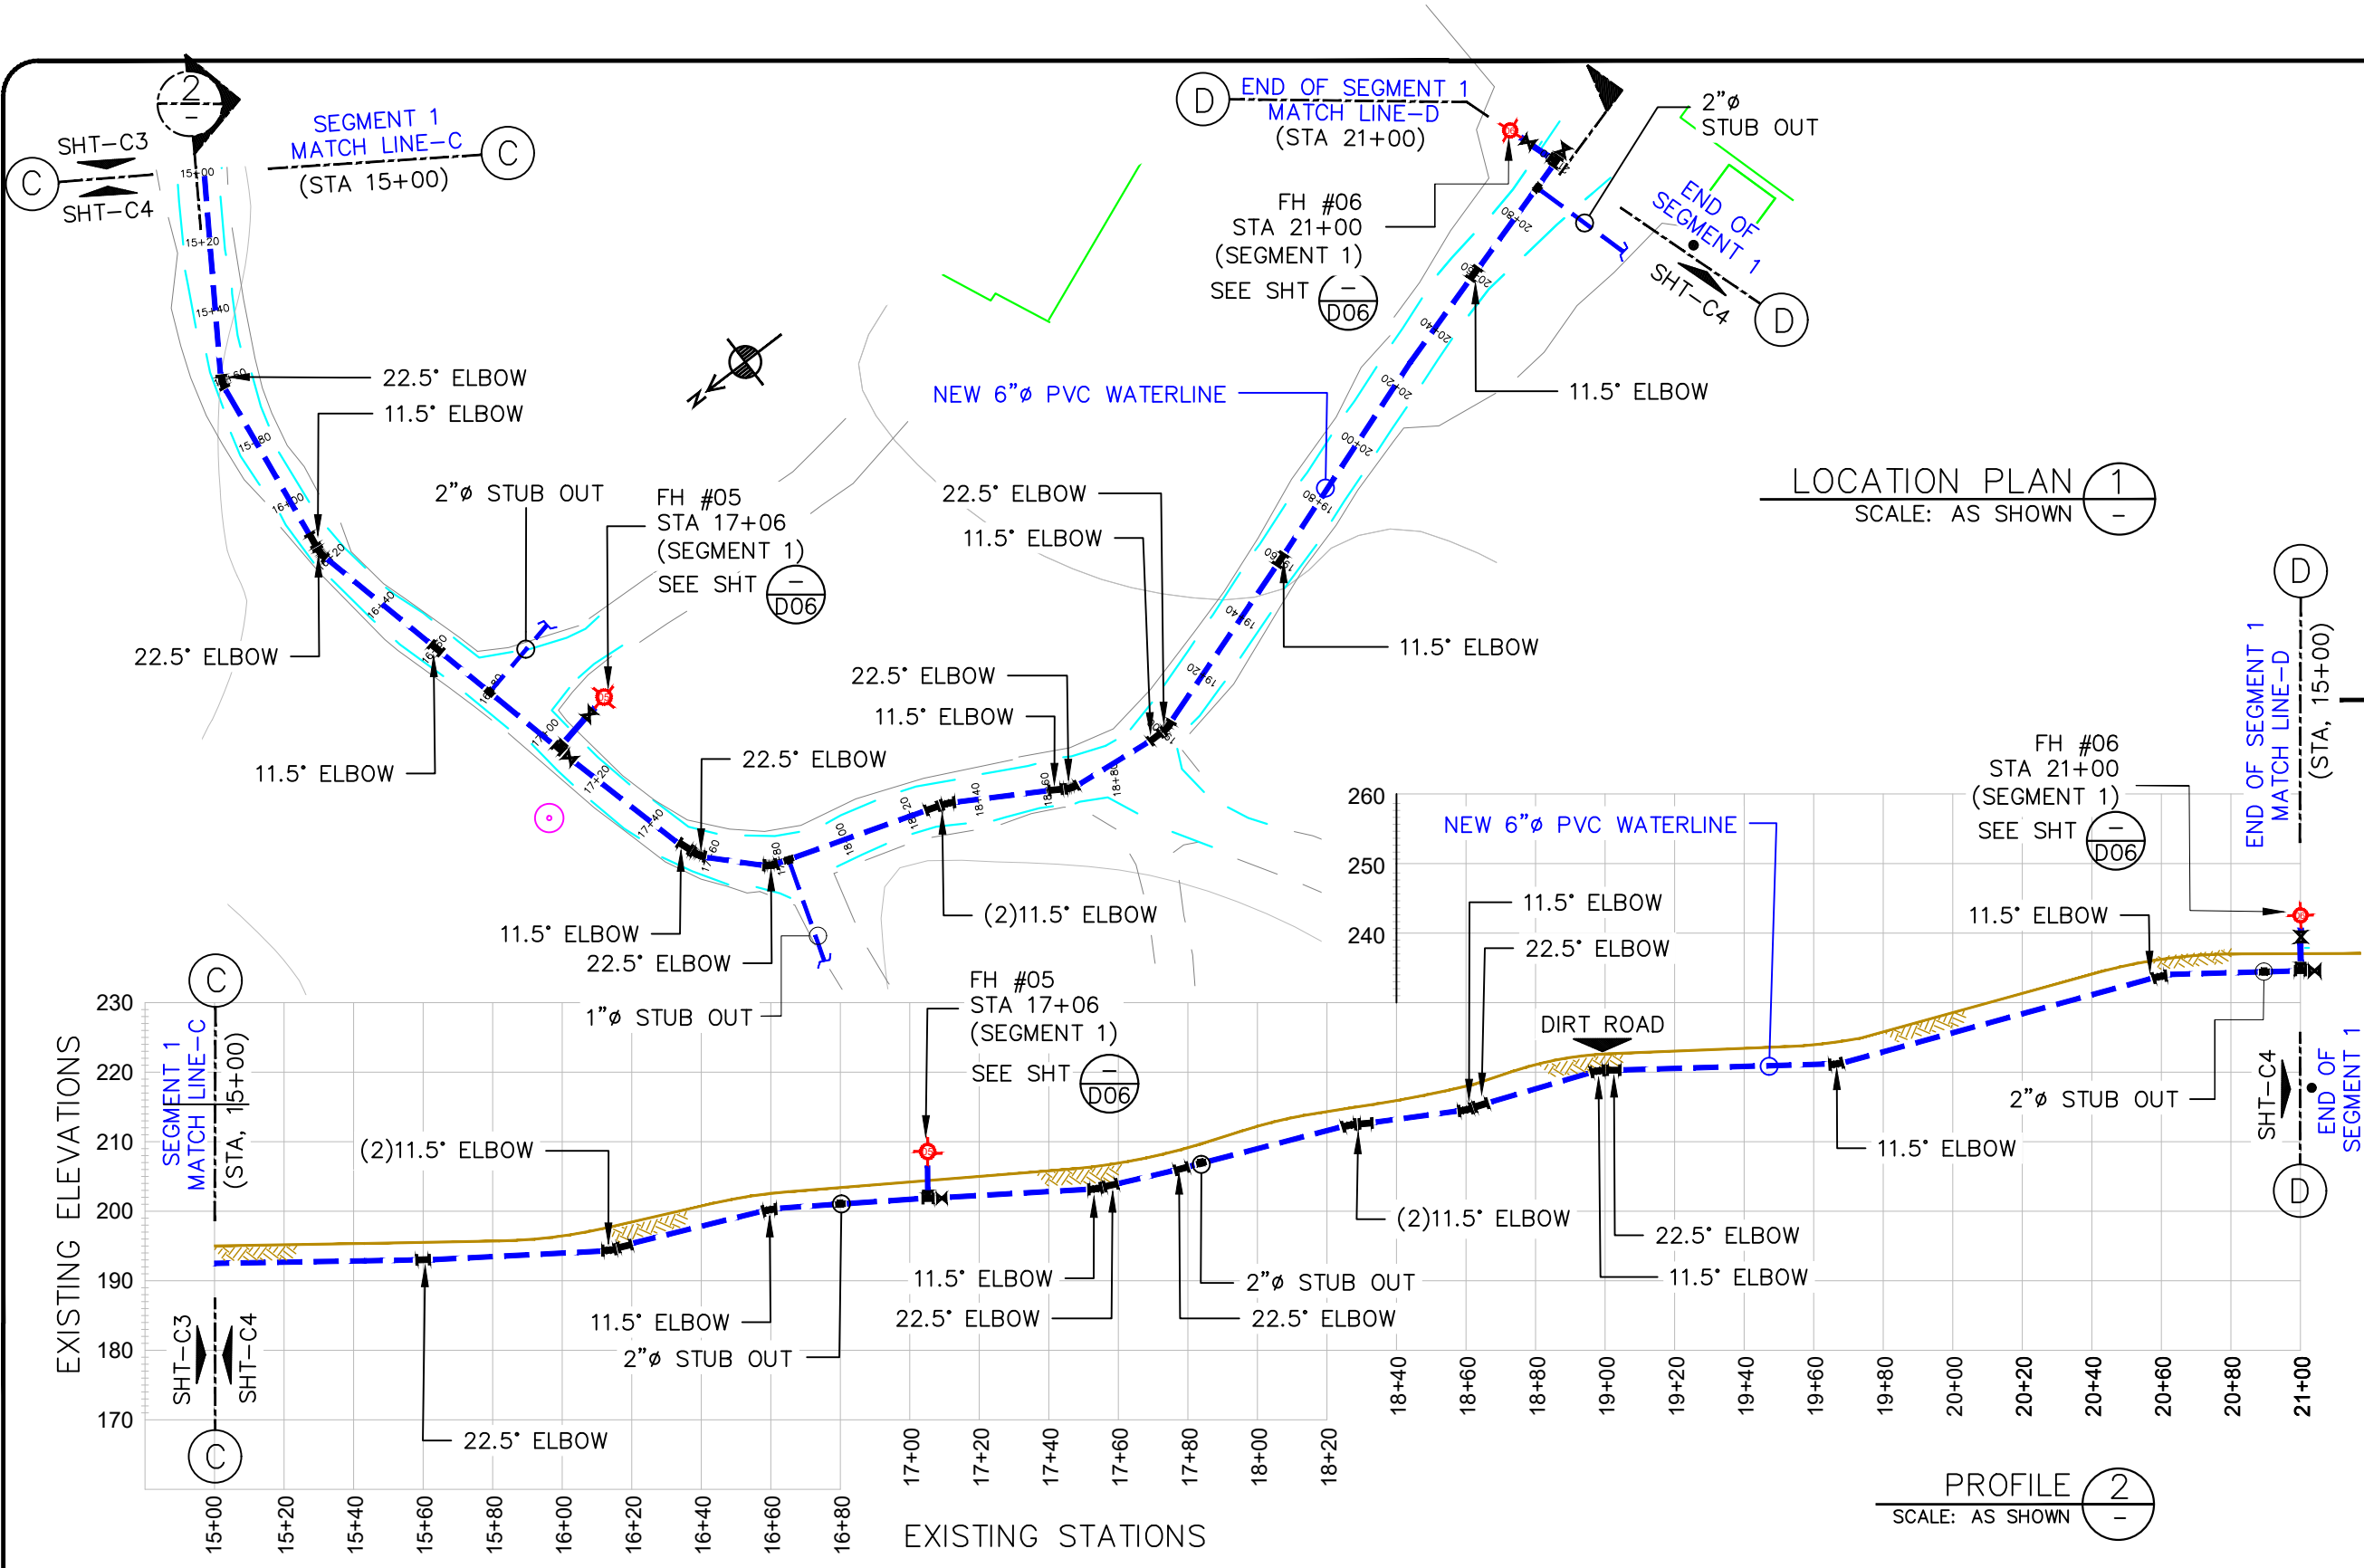


LEGEND:	
EXISTING WATER SERVICE:	
EXISTING ACP WATER:	
NEW 6" PVC WATER:	
TELEPHONE CONDUIT:	
EXISTING STORM DRAIN:	
EXISTING SEWER MAIN:	
GATE VALVE:	
POWER/TEL POLE:	
AIR RELIEVE VALVE:	
ELBOWS:	
11.25°	
22.5°	
45°	
90°	
BACK TEE	
FIRE HYDRANT:	
BAC-T SAMPLING STN:	
SERVICE METER:	
STUB-OUT:	
PRV / PSV :	
EXISTING SERVICE LINE TRANSFERRED TO NEW LINE:	
TREES:	
HEDGES:	
ROCK WALL:	
WIRE FENCE:	

NOTES:
CONSTRUCTION CONTRACTOR SHALL FIELD VERIFY ALL EXISTING UNDERGROUND INFRASTRUCTURE TO ENSURE SAFETY OF ITS WORKERS AND AVOID ANY DAMAGES TO EXISTING GOVERNMENT UTILITIES.

ALL EXISTING FIRE HYDRANT TO BE TRANSFERRED TO NEW LINE.
SEE SHT-D06 FOR FIRE HYDRANT CONNECTION DETAILS.

INSTALL 2"Øx6"Ø SADDLE FOR NEW SERVICE CONNECTION @ EVERY 500 FEET

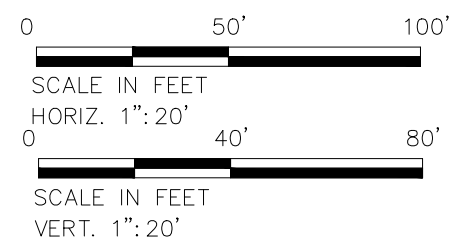

No.	Description	Date

REV. NO.:	
REVISION:	
CHECKED BY:	
APPROVED BY:	
DATE:	



DESIGNED BY:	F.Toala
CHECKED BY:	L.Tyrell
APPROVED BY:	F.Aquila / L.Tyrell
ISSUE FOR:	Construction



AMERICAN SAMOA POWER AUTHORITY
ENGINEERING SERVICES DIVISION
P.O.BOX PPB, TAFUNA, PAGO PAGO, AS 96799

PROJECT NAME:	PHASE 3 VAITOGI HDPE PIPE REPLACEMENT WATERLINE PROJECT
DRAWING TITLE:	SEGMENT 1 PLAN & PROFILE (STA, 15+00 TO 21+00)
PROJECT LOCATION:	VAITOGI VILLAGE, AMERICAN SAMOA

PROJECT NO:	#1658785
SIGNATURE:	
DATE:	JAN-2024
SCALE:	AS SHOWN
SHEET NO.	C04

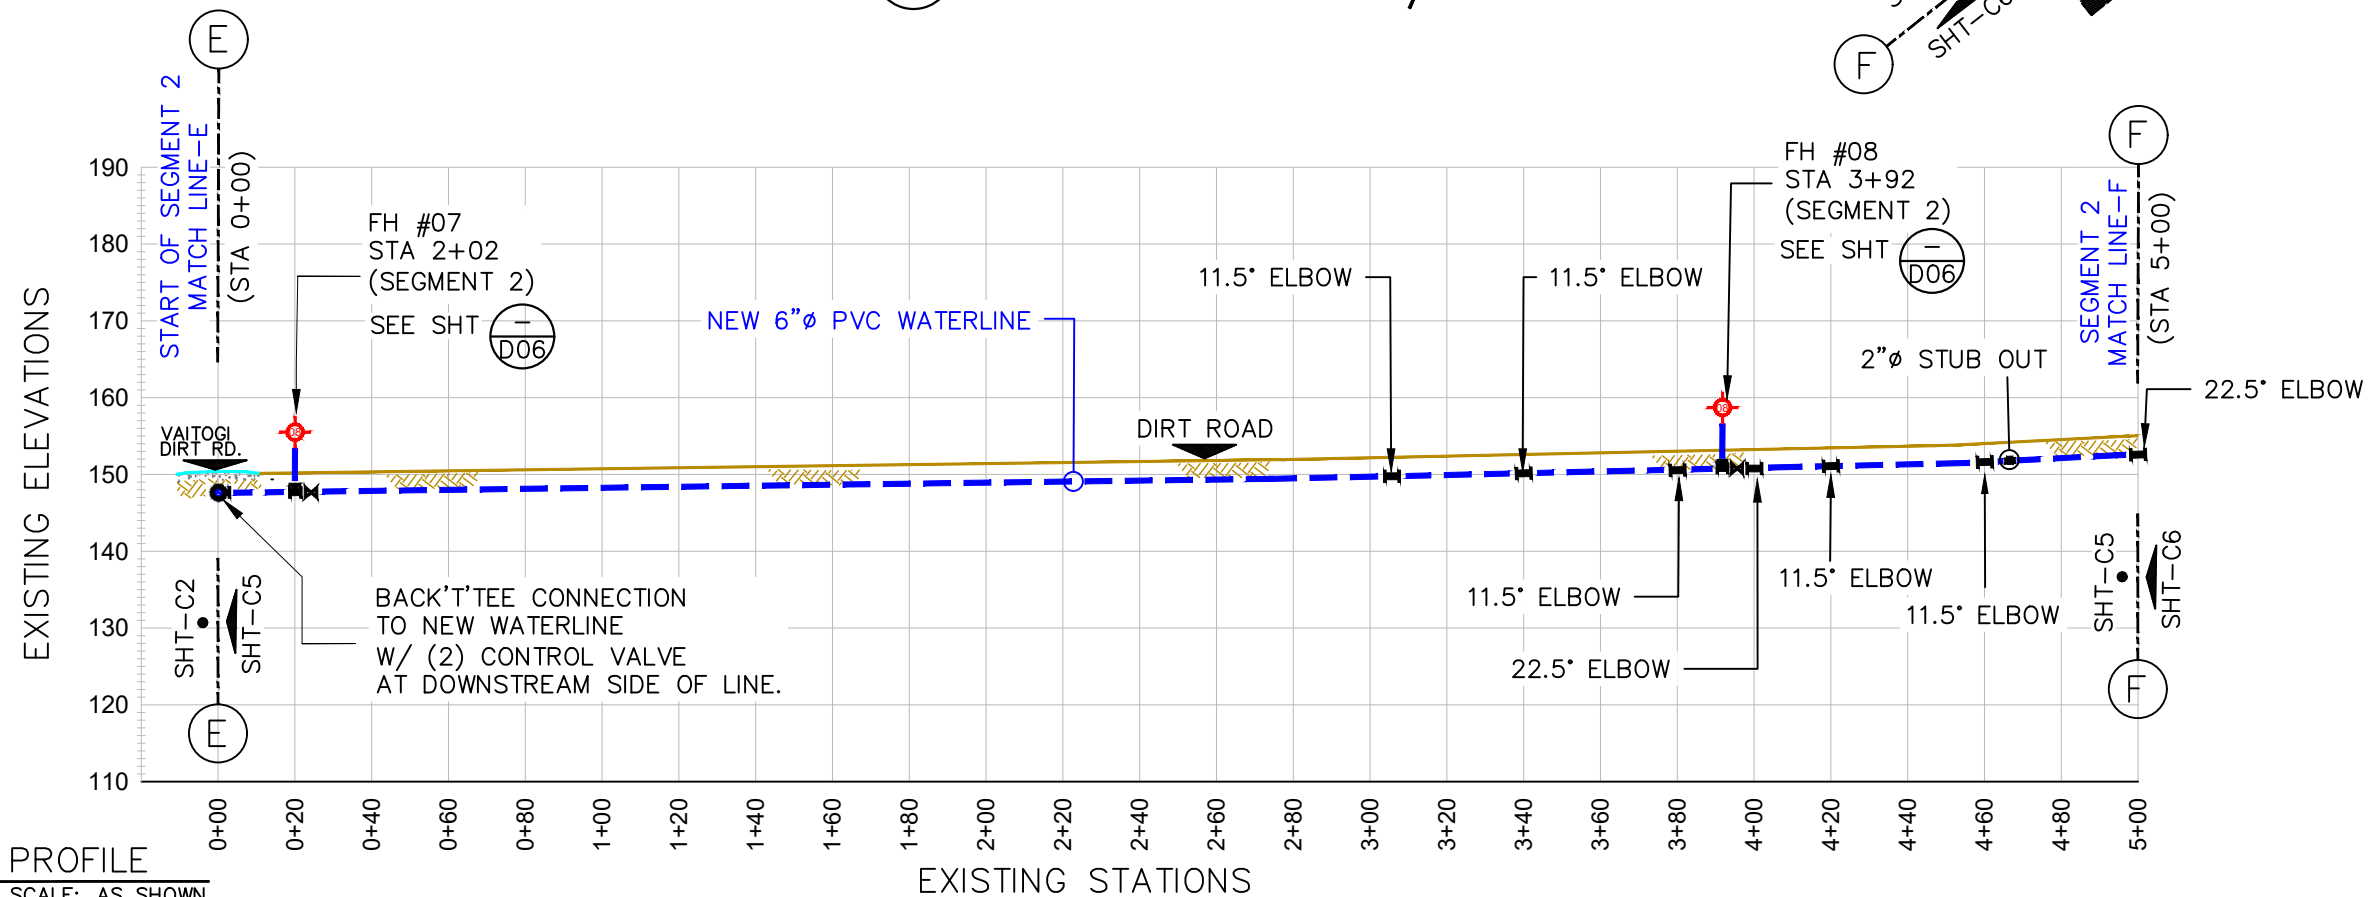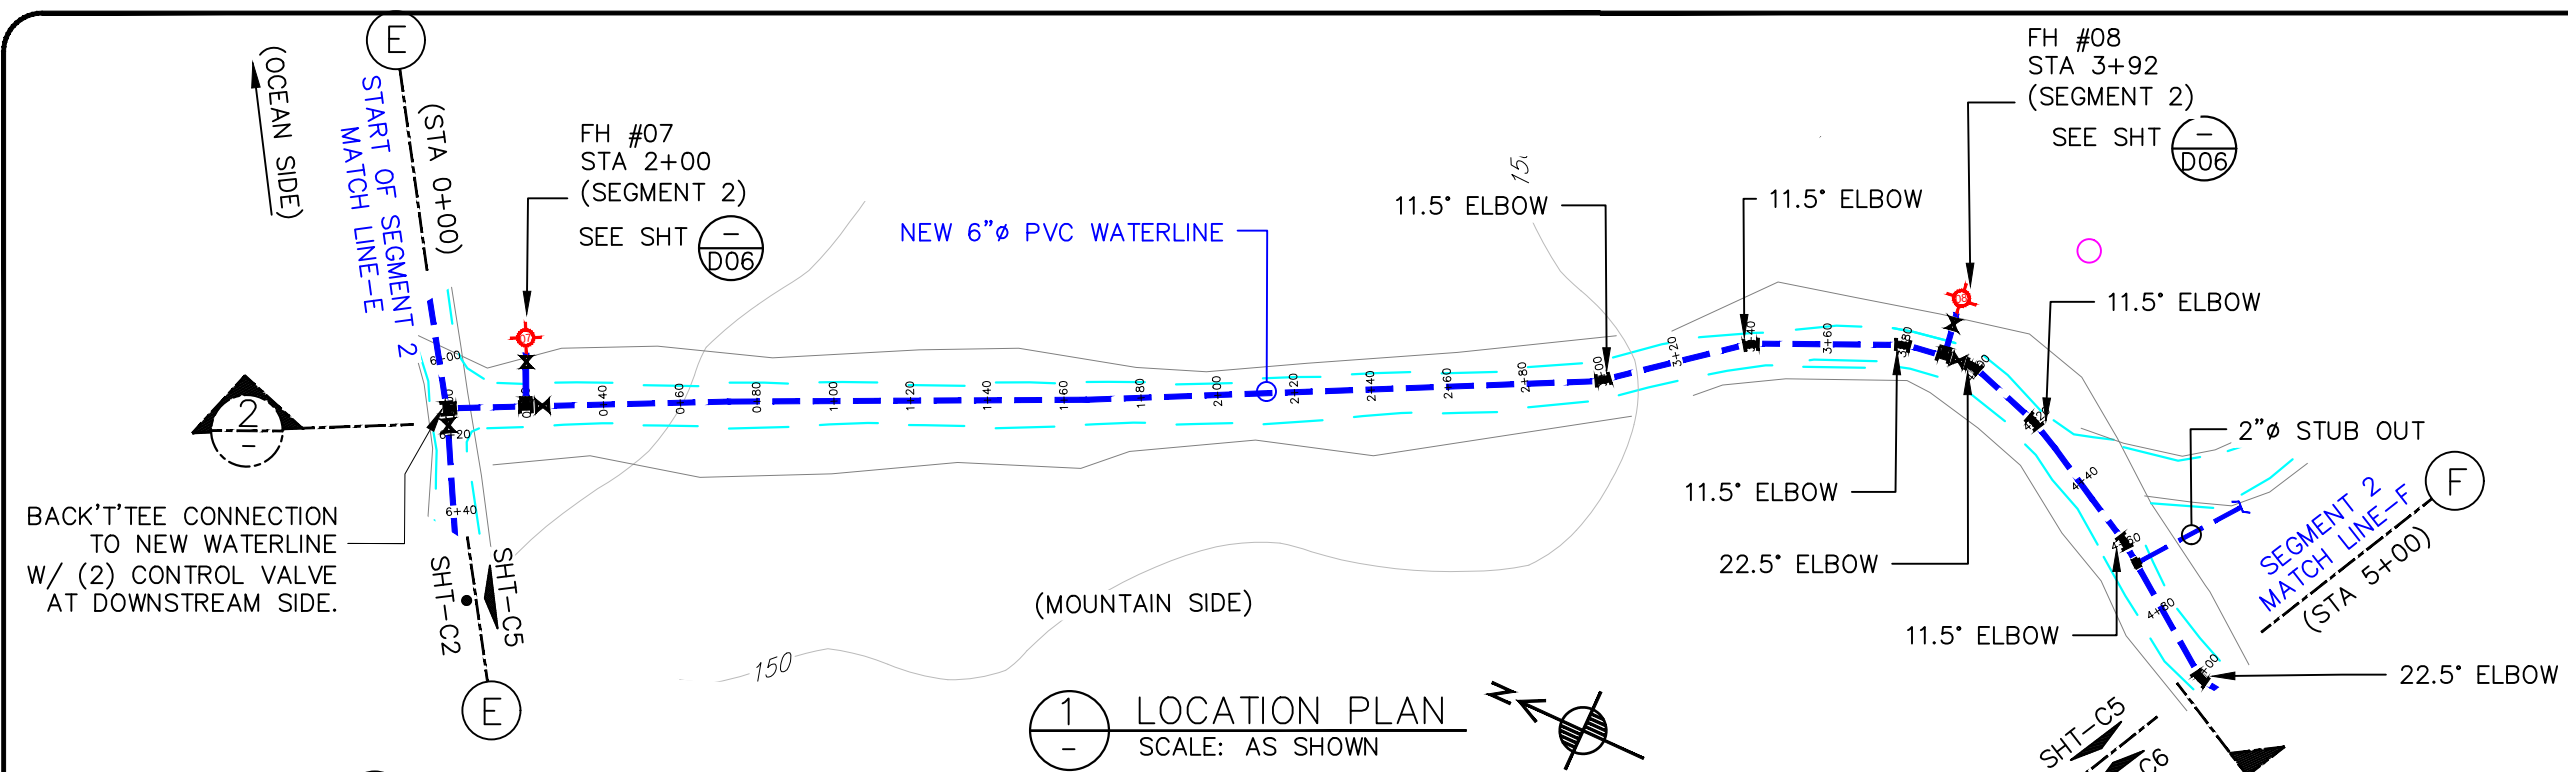

LEGEND:


EXISTING WATER SERVICE:	
EXISTING ACP WATER:	---
NEW 6"Ø PVC WATER:	---
TELEPHONE CONDUIT:	---
EXISTING STORM DRAIN:	---
EXISTING SEWER MAIN:	---
GATE VALVE:	⊗
POWER/TEL POLE:	⊗
AIR RELIEVE VALVE:	⊗
ELBOWS:	11.25° 22.5° 45° 90° BACK TEE
FIRE HYDRANT:	⊗
BAC-T SAMPLING STN:	⊗
SERVICE METER:	---
STUB-OUT:	---
PRV / PSV :	---
EXISTING SERVICE LINE TRANSFERRED TO NEW LINE:	---
TREES:	⊗
HEDGES:	⊗
ROCK WALL:	---
WIRE FENCE:	---

NOTES:

CONSTRUCTION CONTRACTOR SHALL FIELD VERIFY ALL EXISTING UNDERGROUND INFRASTRUCTURE TO ENSURE SAFETY OF ITS WORKERS AND AVOID ANY DAMAGES TO EXISTING GOVERNMENT UTILITIES.

ALL EXISTING FIRE HYDRANT TO BE TRANSFERRED TO NEW LINE.
SEE SHT-D06 FOR FIRE HYDRANT CONNECTION DETAILS.

INSTALL 2"Øx6"Ø SADDLE FOR NEW SERVICE CONNECTION @ EVERY 500 FEET

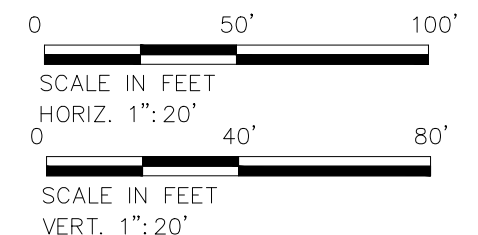

No.	Description	Date

REV. NO.:	
REVISION:	
CHECKED BY:	
APPROVED BY:	
DATE:	

DESIGNED BY:
F.Toala

CHECKED BY:
L.Tyrell

APPROVED BY:
F.Aquila / L.Tyrell

ISSUE FOR:
Construction



AMERICAN SAMOA POWER AUTHORITY

AMERICAN SAMOA POWER AUTHORITY
ENGINEERING SERVICES DIVISION

P.O.BOX PPB, TAFUNA, PAGO PAGO, AS 96799

PROJECT NAME:
PHASE 3
VAITOGI HDPE PIPE REPLACEMENT
WATERLINE PROJECT

DRAWING TITLE:
SEGMENT 2
PLAN & PROFILE (STA, 0+00 TO 5+00)

PROJECT LOCATION:
VAITOGI VILLAGE, AMERICAN SAMOA

PROJECT NO:
#1658785

SIGNATURE:


DATE:

SCALE:
AS SHOWN


DATE:
JAN-2024

SHEET NO.

C05

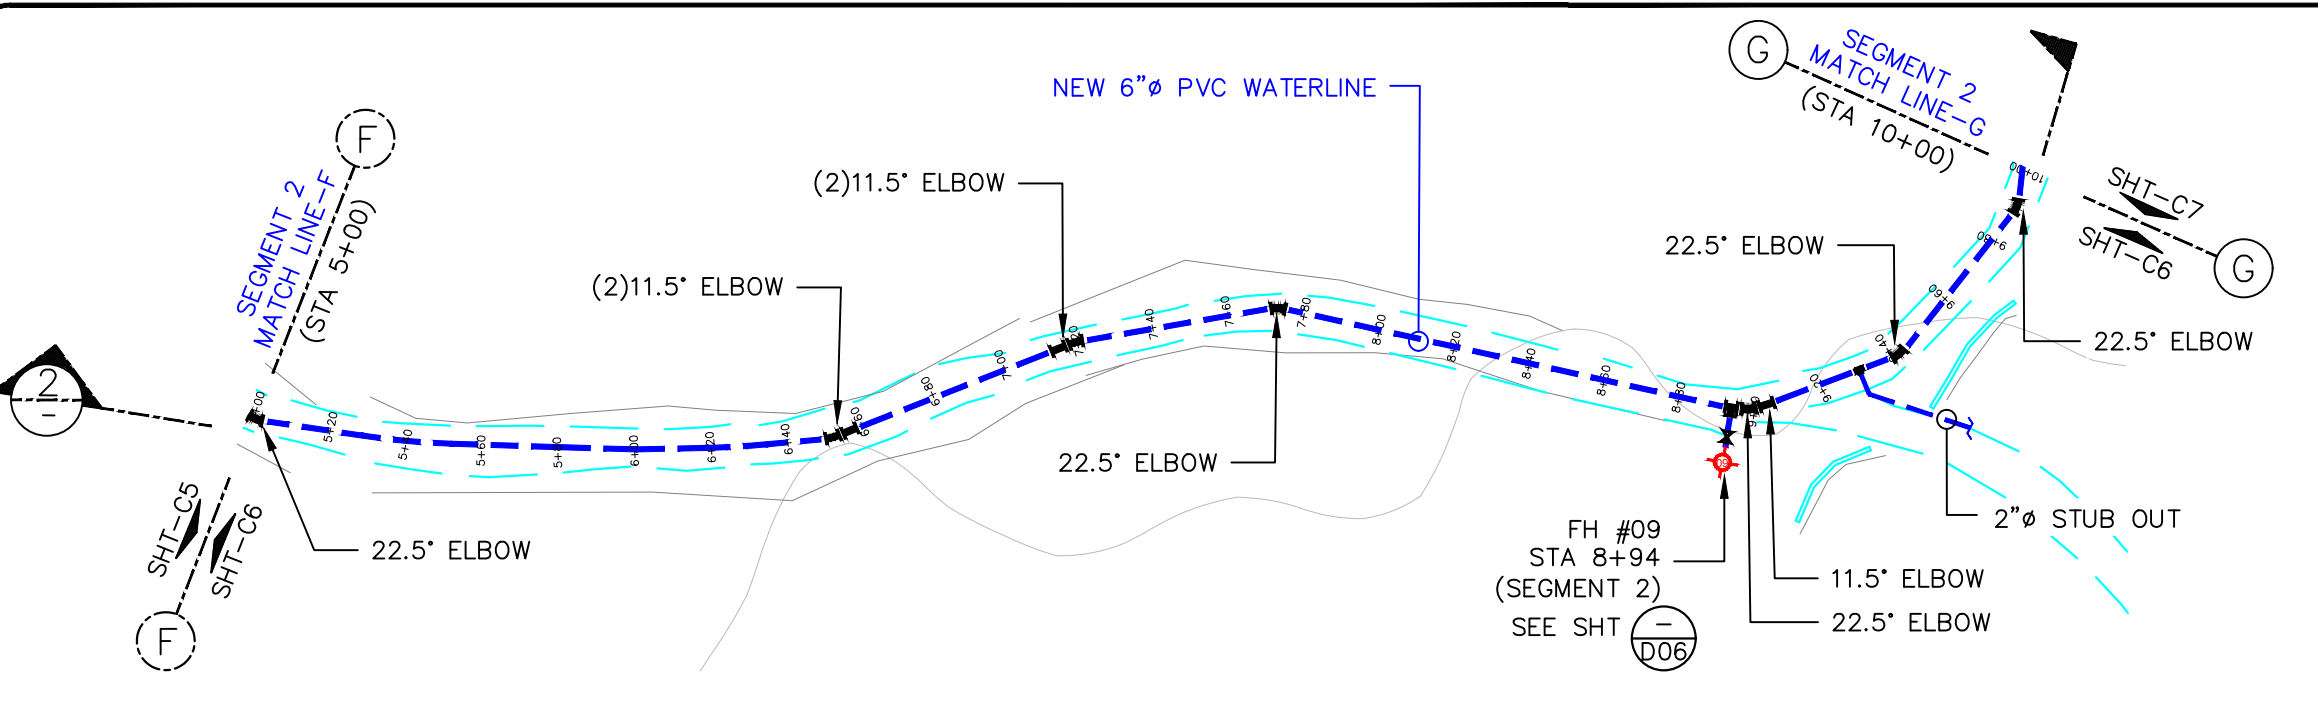

1 LOCATION PLAN
SCALE: AS SHOWN

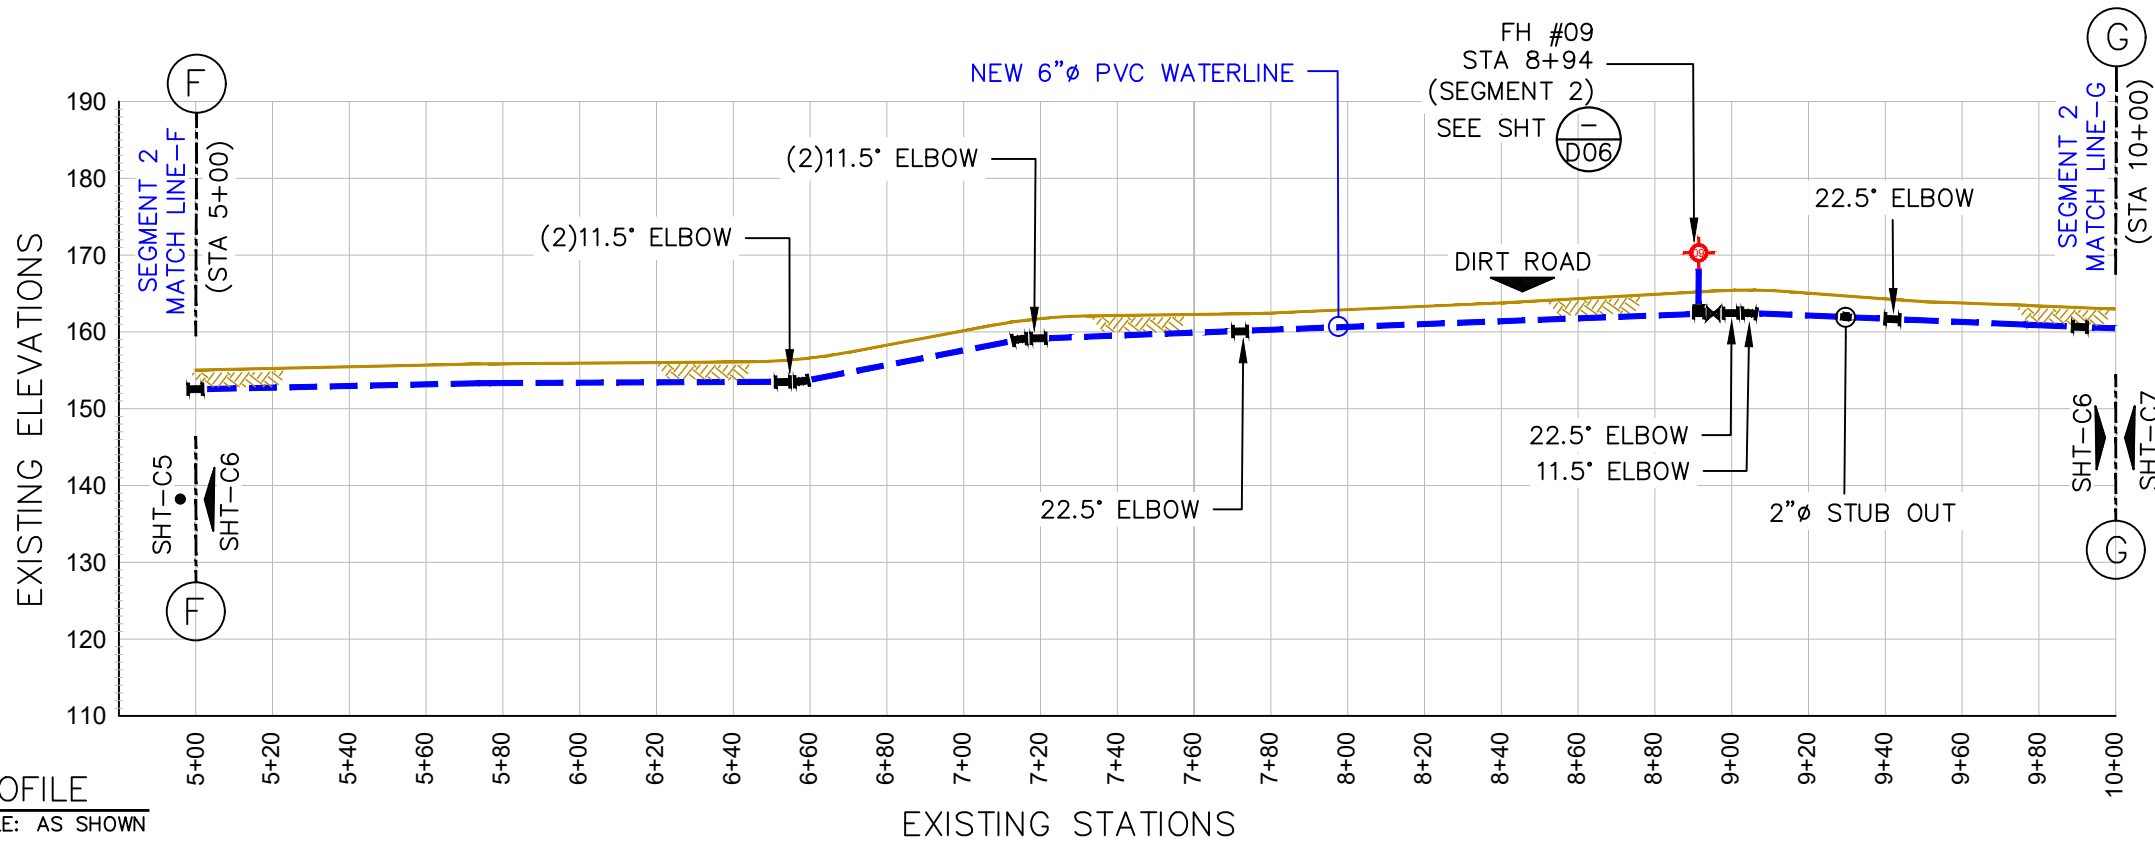

2 PROFILE
SCALE: AS SHOWN


LEGEND:	
EXISTING WATER SERVICE:	
EXISTING ACP WATER:	
NEW 6" PVC WATER:	
TELEPHONE CONDUIT:	
EXISTING STORM DRAIN:	
EXISTING SEWER MAIN:	
GATE VALVE:	
POWER/TEL POLE:	
AIR RELIEVE VALVE:	
ELBOWS:	11.25° 22.5° 45° 90°
FIRE HYDRANT:	
BAC-T SAMPLING STN:	
SERVICE METER:	
STUB-OUT:	
PRV / PSV :	
EXISTING SERVICE LINE TRANSFERRED TO NEW LINE:	
TREES:	
HEDGES:	
ROCK WALL:	
WIRE FENCE:	

NOTES:

CONSTRUCTION CONTRACTOR SHALL FIELD VERIFY ALL EXISTING UNDERGROUND INFRASTRUCTURE TO ENSURE SAFETY OF ITS WORKERS AND AVOID ANY DAMAGES TO EXISTING GOVERNMENT UTILITIES.

ALL EXISTING FIRE HYDRANT TO BE TRANSFERRED TO NEW LINE. SEE SHT-D06 FOR FIRE HYDRANT CONNECTION DETAILS.

INSTALL 2"x6" SADDLE FOR NEW SERVICE CONNECTION @ EVERY 500 FEET

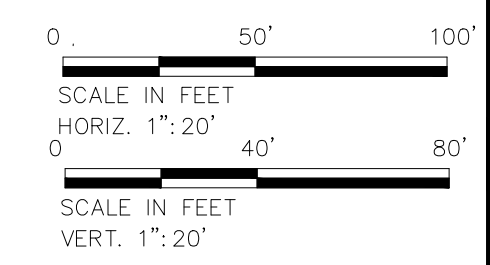

No.	Description	Date

REV. NO.:	
REVISION:	
CHECKED BY:	
APPROVED BY:	
DATE:	

DESIGNED BY:	F.Toala
CHECKED BY:	L.Tyrell
APPROVED BY:	F.Aquila / L.Tyrell
ISSUE FOR:	Construction

AMERICAN SAMOA POWER AUTHORITY



ENGINEERING SERVICES DIVISION

P.O.BOX PPB, TAFUNA, PAGO PAGO, AS 96799

PROJECT NAME:	PHASE 3 VAITOGI HDPE PIPE REPLACEMENT WATERLINE PROJECT
DRAWING TITLE:	SEGMENT 2 PLAN & PROFILE (STA, 5+00 TO 10+00)
PROJECT LOCATION:	VAITOGI VILLAGE, AMERICAN SAMOA

PROJECT NO:	#1658785
SIGNATURE:	
DATE:	

SCALE:	AS SHOWN
DATE:	JAN-2024
SHEET NO.	C06

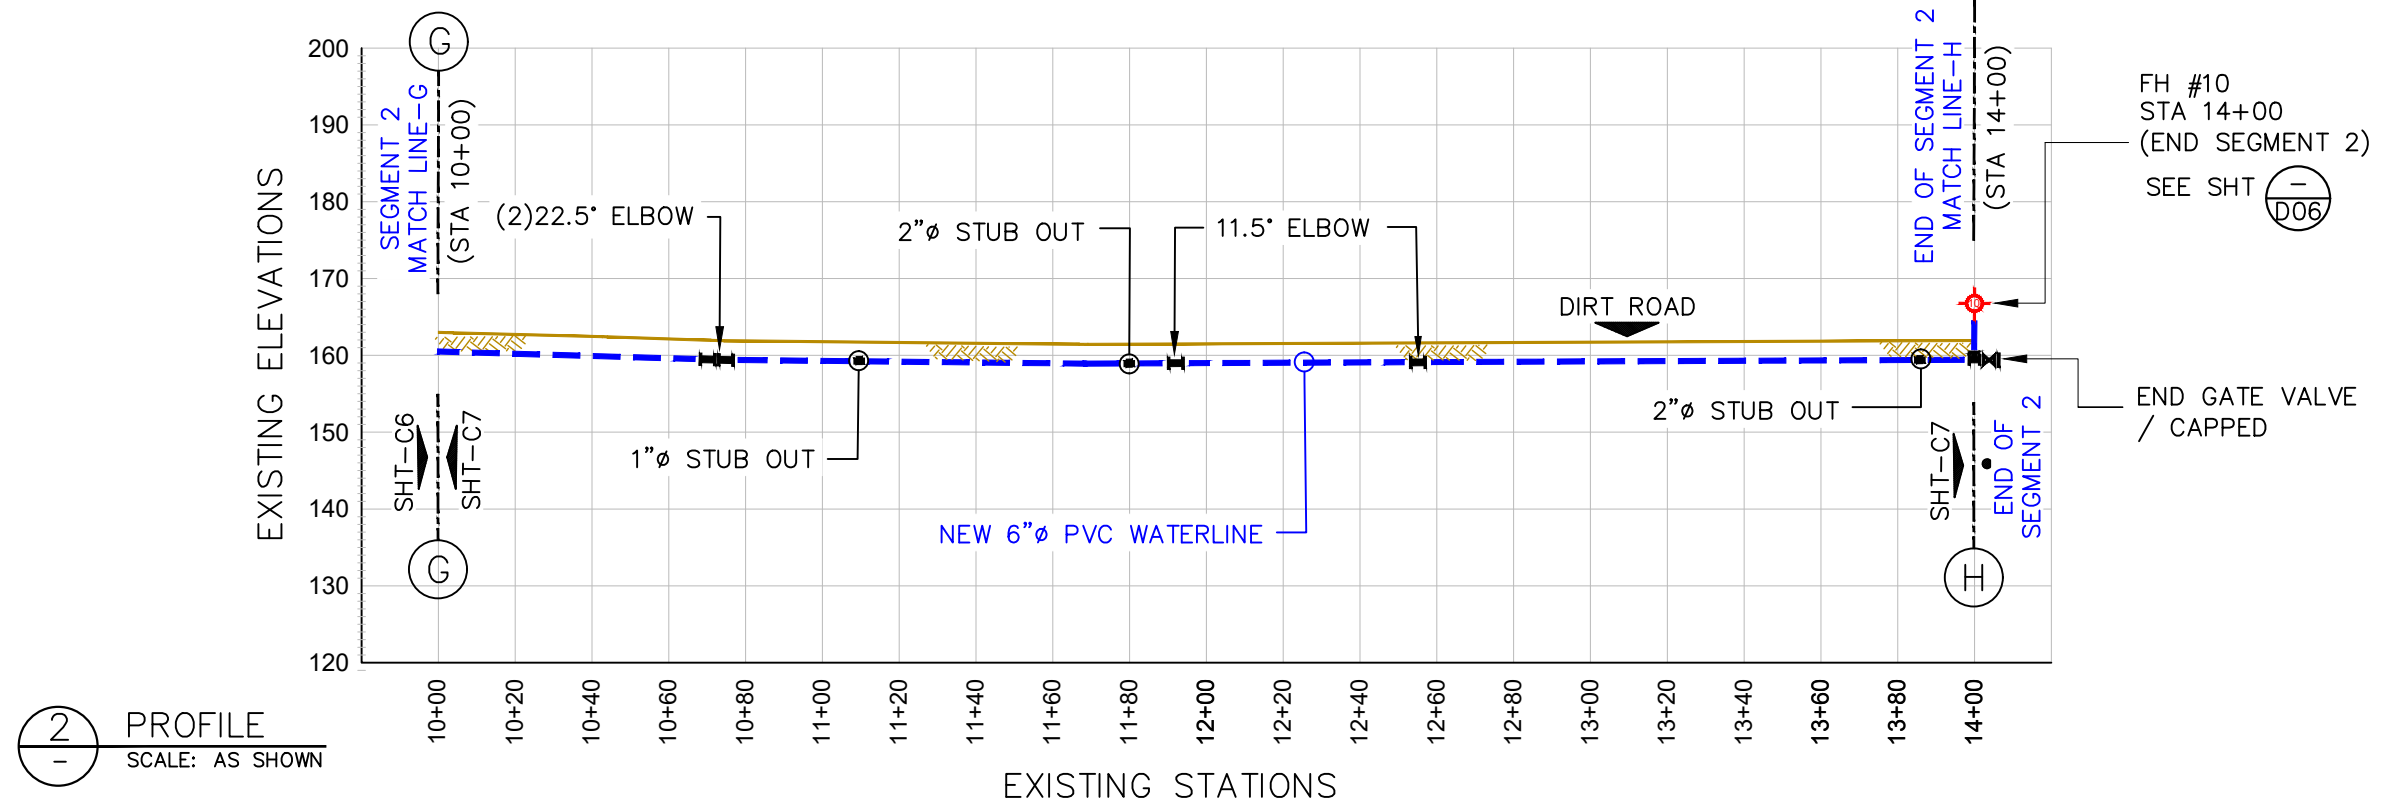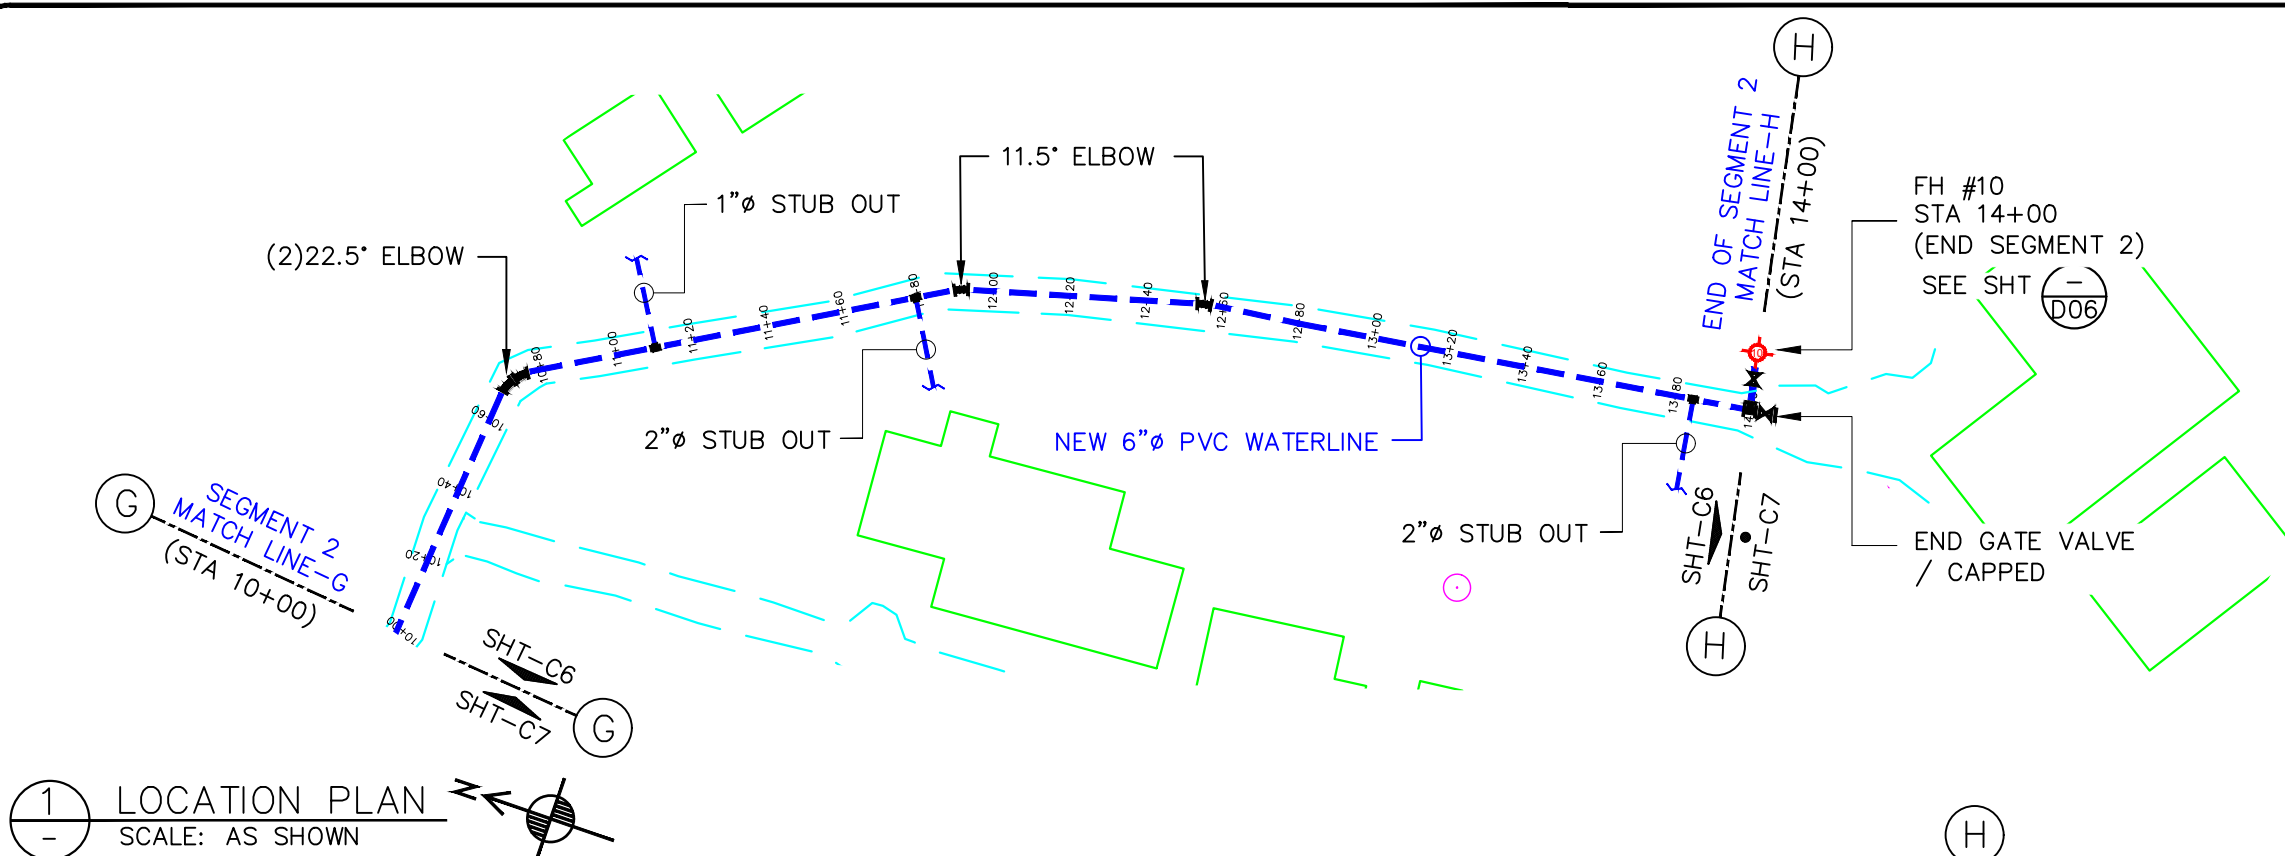


LEGEND:	
EXISTING WATER SERVICE:	
EXISTING ACP WATER:	
NEW 6" PVC WATER:	
TELEPHONE CONDUIT:	
EXISTING STORM DRAIN:	
EXISTING SEWER MAIN:	
GATE VALVE:	
POWER/TEL POLE:	
AIR RELIEVE VALVE:	
ELBOWS:	
11.25°	
22.5°	
45°	
90°	
BACK TEE	
FIRE HYDRANT:	
BAC-T SAMPLING STN:	
SERVICE METER:	
STUB-OUT:	
PRV / PSV :	
EXISTING SERVICE LINE TRANSFERRED TO NEW LINE:	
TREES:	
HEDGES:	
ROCK WALL:	
WIRE FENCE:	

NOTES:

CONSTRUCTION CONTRACTOR SHALL FIELD VERIFY ALL EXISTING UNDERGROUND INFRASTRUCTURE TO ENSURE SAFETY OF ITS WORKERS AND AVOID ANY DAMAGES TO EXISTING GOVERNMENT UTILITIES.

ALL EXISTING FIRE HYDRANT TO BE TRANSFERRED TO NEW LINE. SEE SHT-D06 FOR FIRE HYDRANT CONNECTION DETAILS.

INSTALL 2"x6" SADDLE FOR NEW SERVICE CONNECTION @ EVERY 500 FEET

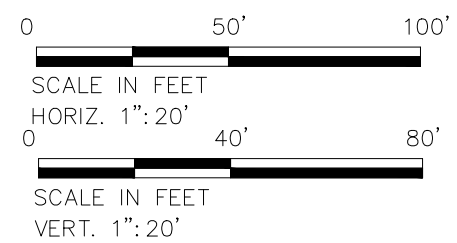

<table><tr><td>No.</td><td>Description</td><td>Date</td></tr><tr><td> </td><td> </td><td> </td></tr><tr><td> </td><td> </td><td> </td></tr><tr><td> </td><td> </td><td> </td></tr><tr><td> </td><td> </td><td> </td></tr><tr><td> </td><td> </td><td> </td></tr></table>	No.	Description	Date																REV. NO.: REVISION: CHECKED BY: APPROVED BY: DATE:		DESIGNED BY: F.Toala CHECKED BY: L.Tyrell APPROVED BY: F.Aquila / L.Tyrell ISSUE FOR: Construction		 AMERICAN SAMOA POWER AUTHORITY ENGINEERING SERVICES DIVISION P.O.BOX PPB, TAFUNA, PAGO PAGO, AS 96799	PROJECT NAME: PHASE 3 VAITOGI HDPE PIPE REPLACEMENT WATERLINE PROJECT DRAWING TITLE: SEGMENT 2 ENDS PLAN & PROFILE (STA, 10+00 TO 14+00) PROJECT LOCATION: VAITOGI VILLAGE, AMERICAN SAMOA		PROJECT NO: #1658785 SIGNATURE: DATE:	SCALE: AS SHOWN DATE: JAN-2024 SHEET NO. C07
No.	Description	Date																									

VENT-GUARD FLITOP FIBERGLASS
AIR VALVE ENCLOSURE MODEL
LV018018024 BY "HOTBOX" OR
ASPA APPROVED EQUAL

1"Ø AIR RELIEF/AIR VACUUM
VALVE, PLAST-O-MATIC
MODEL ARV100EPT-PV "OR"
ASPA APPROVED EQUAL.

1"Ø COPPER PIPE SHORT
PIECE, MIPxPE.

1"Ø BALL VALVE CURB STOPS W/
BRASS COUPLING BOTH SIDES
(B22-444) "OR" ASPA
APPROVED EQUAL

3' MIN
SEE TRENCH DETAIL

4" THICK CONCRETE
PAD W/ #665 WWF

1"Ø COPPER PIPE

1"Ø BRASS PACK JOINT
COUPLING (C24-44) "OR"
ASPA APPROVED EQUAL

8"X 1"Ø SERVICE SADDLE,
(ROMAC 202S -7.5-1" IP)
"OR" ASPA APPROVED EQUAL

6" MIN.

1'-2" MIN.

FINISHED GRADE OR
EXISTING GROUND

(2) 45° ELBOW

1"Ø PVC PIPE

1"Ø CORP. STOP
W/ PACK JOINT
FOR PE PIPE


8" WATER MAIN

NATURAL GRADE

3'-0" MIN
(OR AS DETERMINED
BY ENGINEER)

0'-6" MIN

ARV VALVE SECTION DETAILS
SCALE: 3/4" = 1'

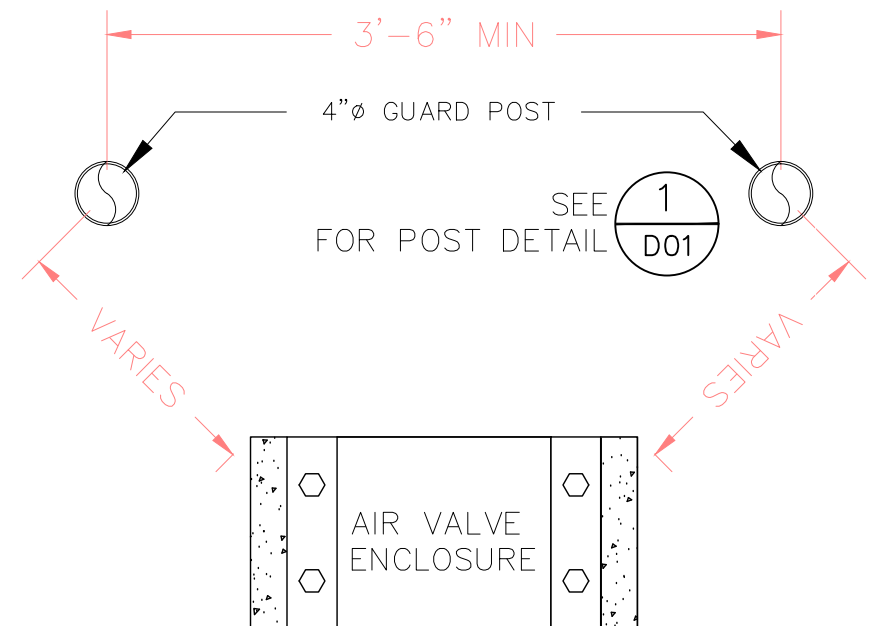

2 PLAN VIEW SHOWING
ARV GUARD POST LOCATION
NOT TO SCALE

No.	Description	Date

REV. NO.:
REVISION:
CHECKED BY:
APPROVED BY:
DATE:

DESIGNED BY: F.Toala
CHECKED BY: L.Tyrell
APPROVED BY: F.Aquila / L.Tyrell
ISSUE FOR: Construction



AMERICAN SAMOA POWER AUTHORITY

AMERICAN SAMOA POWER AUTHORITY
ENGINEERING SERVICES DIVISION

P.O.BOX PPB, TAFUNA, PAGO PAGO, AS 96799

PROJECT NAME:

PHASE 3
VAITOGI HDPE PIPE REPLACEMENT
WATERLINE PROJECT

DRAWING TITLE:

AIR RELIEF VALVE & DETAILS

PROJECT LOCATION:

VAITOGI VILLAGE, AMERICAN SAMOA

PROJECT NO:

#1658785

SIGNATURE:

DATE:

SCALE:

AS SHOWN

DATE:

JAN-2024

SHEET NO.

D02




GENERAL NOTES:

- 1. TABLE IS BASED ON 2000#/SQ. FT. SOIL. IF CONDITIONS ARE FOUND TO INDICATE SOIL BEARING IS LESS, THE AREAS SHALL BE INCREASED ACCORDINGLY.
- 2. AREAS FOR PIPE LARGER THAN 18" SHALL BE CALCULATED.
- 3. CONCRETE SHALL HAVE A MINIMUM COMPRESSION STRENGTH OF 2500 PSI.
- 4. THRUST BLOCK IS TO EXTEND TO UNDISTURBED SOIL.
- 5. SIZE MAY BE DECREASED FOR LESSER DEGREE BENDS AS DETERMINED BY ENGINEER.
- 6. KEEP CONCRETE CLEAR OF M.J. OR BELL AND SPIGOT JOINTS.
- 7. BLOCK IN A SIMILAR MANNER AT TEES, HYDRANTS, PLUG OR OTHER LOCATIONS AS REQUIRED.
- 8. WHEN NECESSARY ADDITIONAL THRUST RESTRAINT METHODS MAY BE USED, SUCH AS MECHANICAL JOINT RESTRAINTS, TIE-RODS (INSTALLED PER MANUFACTURERS' RECOMMENDATIONS) OR OTHER APPROVED METHODS.

CONSTRUCTION KEY NOTES:



- A. LENGTH "Y & W" AS REQUIRED TO OBTAIN BEARING AREA AGAINST UNDISTURBED SOIL.
- B. ADDITIONAL EXCAVATION IF NECESSARY TO OBTAIN REQUIRED BEARING AREA.
- C. MINIMUM THRUST BLOCK AREA REQUIREMENTS FOR (Y & W) AS FOLLOWS:

PIPE SIZE	WATER PIPE	
	TEE, DEAD END 90° BEND	45° AND 22 1/2° BENDS
4" & LESS	3 SQ. FEET	3 SQ. FEET
6"	4 SQ. FEET	3 SQ. FEET
8"	6 SQ. FEET	3 SQ. FEET
10"	9 SQ. FEET	5 SQ. FEET
12"	13 SQ. FEET	7 SQ. FEET
16"	23 SQ. FEET	12 SQ. FEET
18"	29 SQ. FEET	15 SQ. FEET

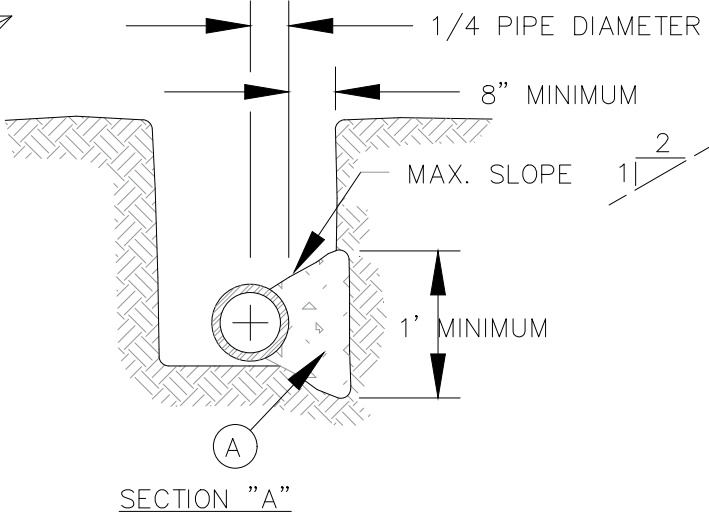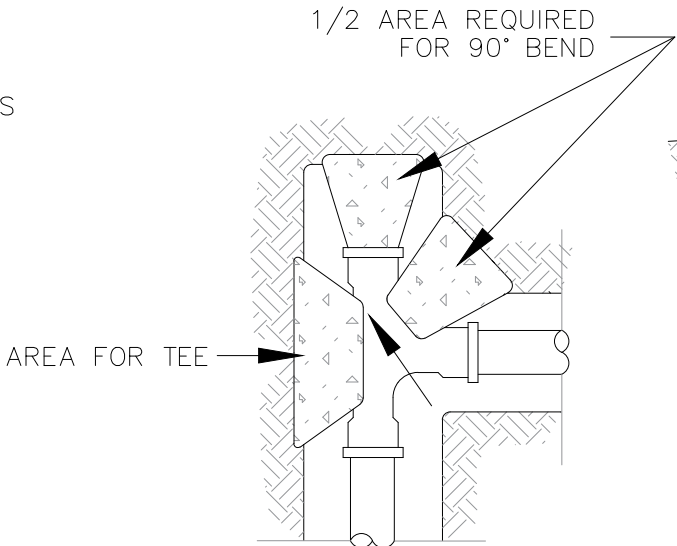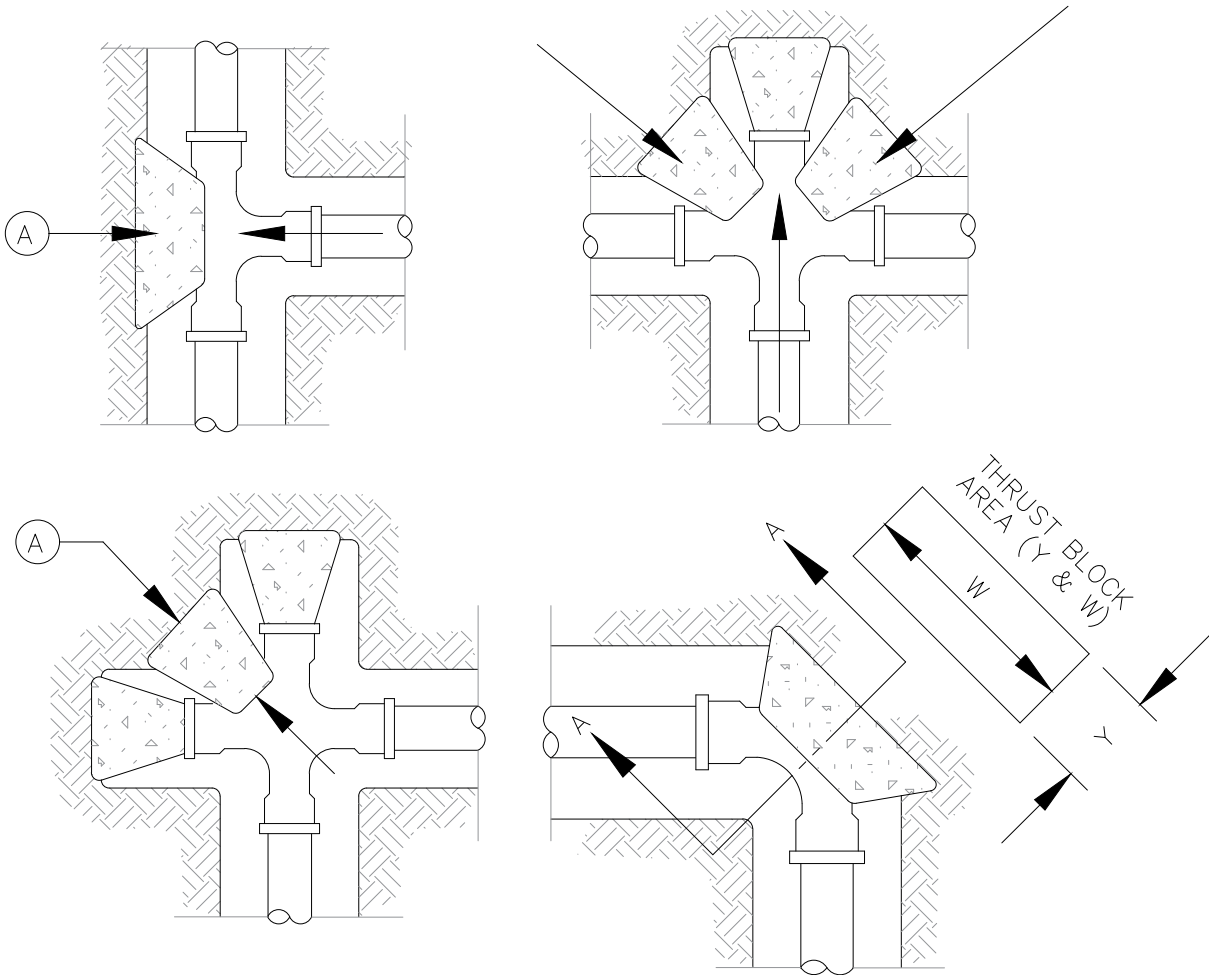

NOTES:

- 1. ALL ANCHOR RODS ARE TO BE COVERED WITH 80MILS OF BITUMASTIC COMPOUND.
- 2. WRAP EXTERIOR OF VALVE, ACTUATOR AND REBAR WITH 8 MIL POLYETHYLENE SHEETING AND TAPE.

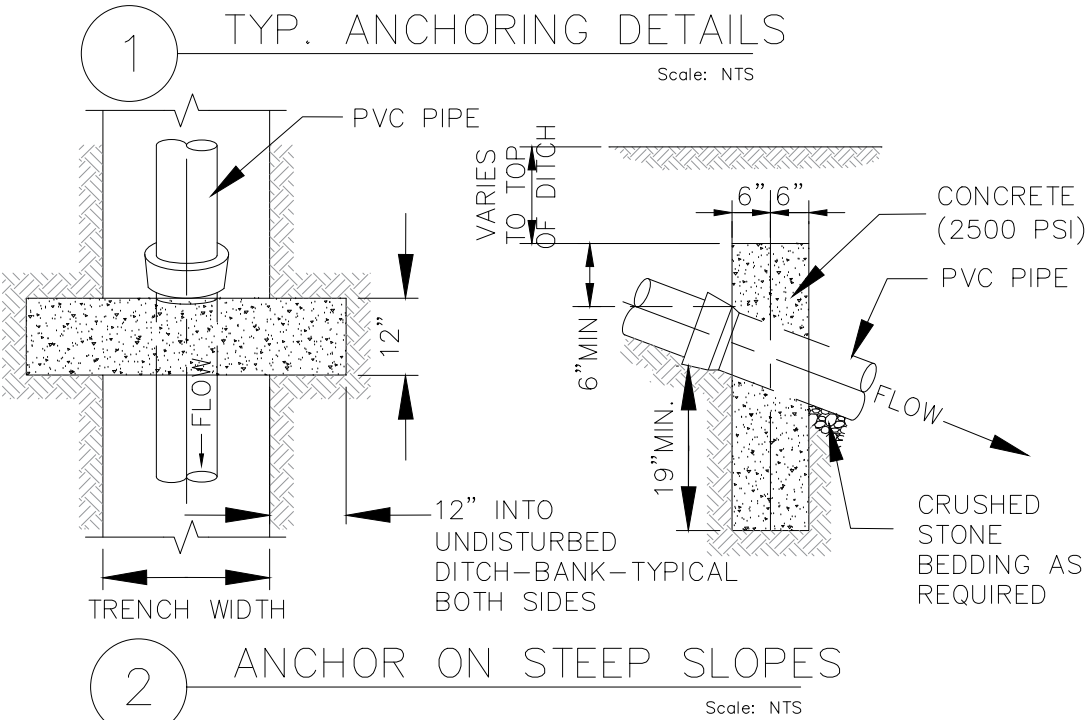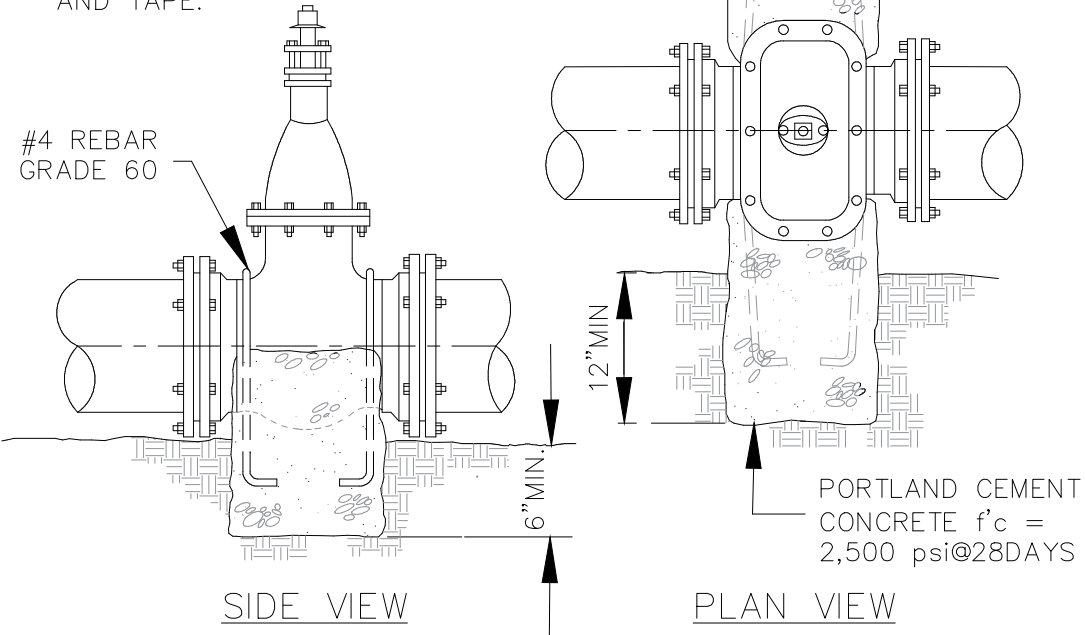

No.	Description	Date

REV. NO.:
REVISION:
CHECKED BY:
APPROVED BY:
DATE:

DESIGNED BY:
CHECKED BY:
APPROVED BY:
ISSUE FOR:




AMERICAN SAMOA POWER AUTHORITY
ENGINEERING SERVICES DIVISION
P.O.BOX PPB, TAFUNA, PAGO PAGO, AS 96799

PROJECT NAME:
DRAWING TITLE:
PROJECT LOCATION:

PROJECT NO:
SIGNATURE:
DATE:

SCALE:
DATE:
SHEET NO.

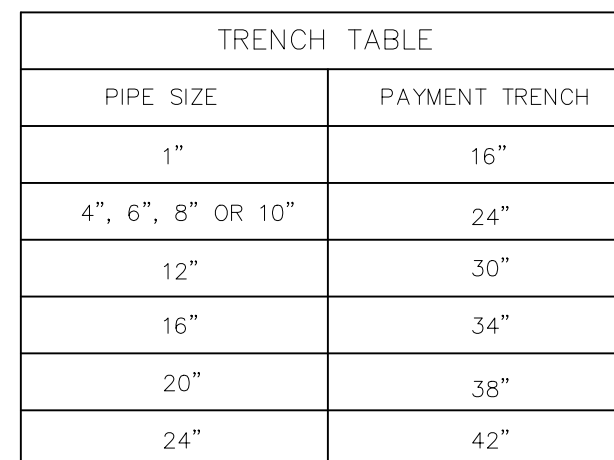

4 INCH TELECOM CONDUIT
(SIMILAR DETAILS FOR EXISTING
UTILITY CROSSING PIPES
UP TO 36")



D02 AIR RELIEF VALVE
SCALE: 1/2" = 1'









DESIGNED BY:	F.Toala
CHECKED BY:	L.Tyrell
APPROVED BY:	F.Aquila / L.Tyrell
ISSUE FOR:	Construction



AMERICAN SAMOA POWER AUTHORITY
ENGINEERING SERVICES DIVISION
P.O.BOX PPB, TAFUNA, PAGO PAGO, AS 96799

PROJECT NO: #1658785	SCALE: AS SHOWN
SIGNATURE: 	DATE: JAN-2024
DATE: 	SHEET NO. D04

No.	Description	Date	REV. NO.:	DESIGNED BY:	 AMERICAN SAMOA POWER AUTHORITY ENGINEERING SERVICES DIVISION P.O.BOX PPB, TAFUNA, PAGO PAGO, AS 96799	PROJECT NAME:	PROJECT NO:	SCALE:
			REVISION:	F.Toala		PHASE 3	#1658785	AS SHOWN
			CHECKED BY:	L.Tyrell		VAITOGI HDPE PIPE REPLACEMENT	SIGNATURE:	DATE:
			APPROVED BY:	F.Aquila / L.Tyrell		WATERLINE PROJECT	DATE:	JAN-2024
			DATE:	ISSUE FOR:		DRAWING TITLE:	SHEET NO.	D05
				Construction		BACTERIOLOGICAL SAMPLING STATION & DETAILS		
						PROJECT LOCATION:		
						VAITOGI VILLAGE, AMERICAN SAMOA		

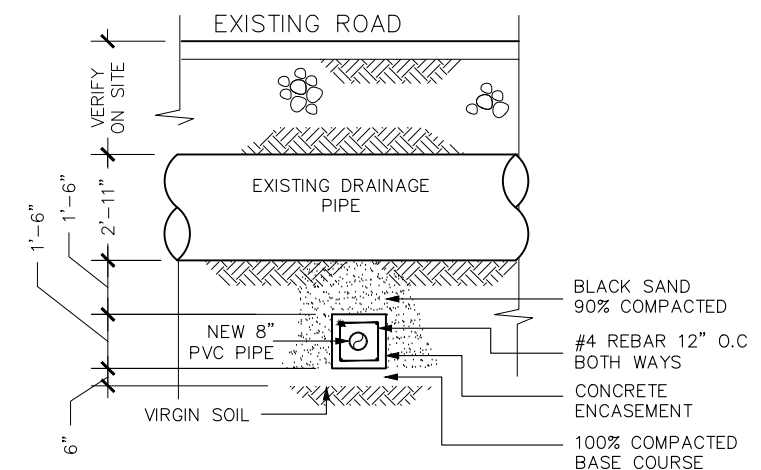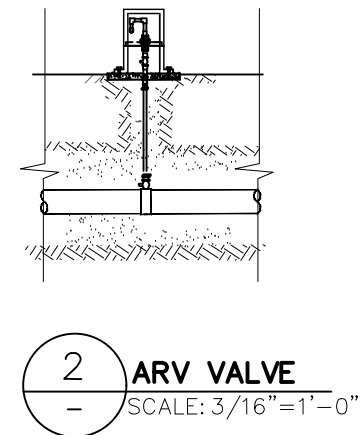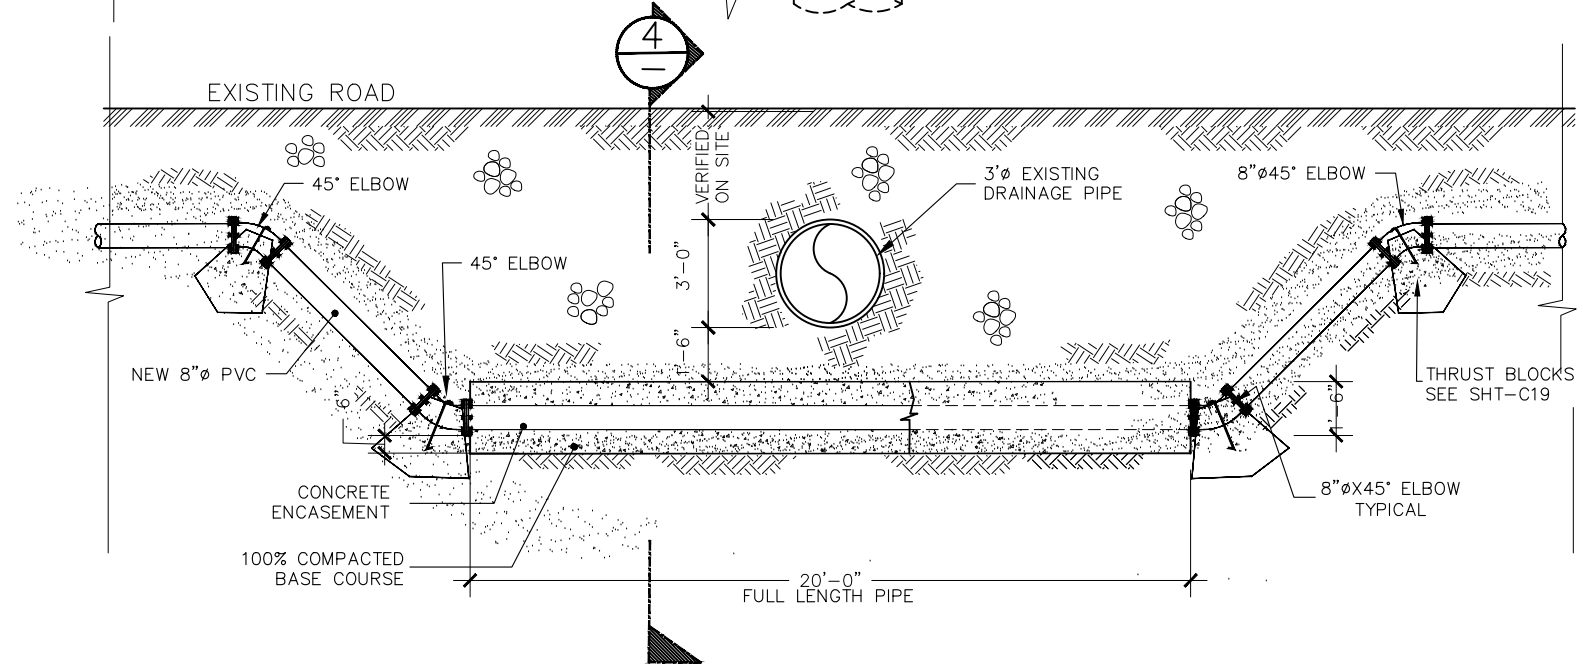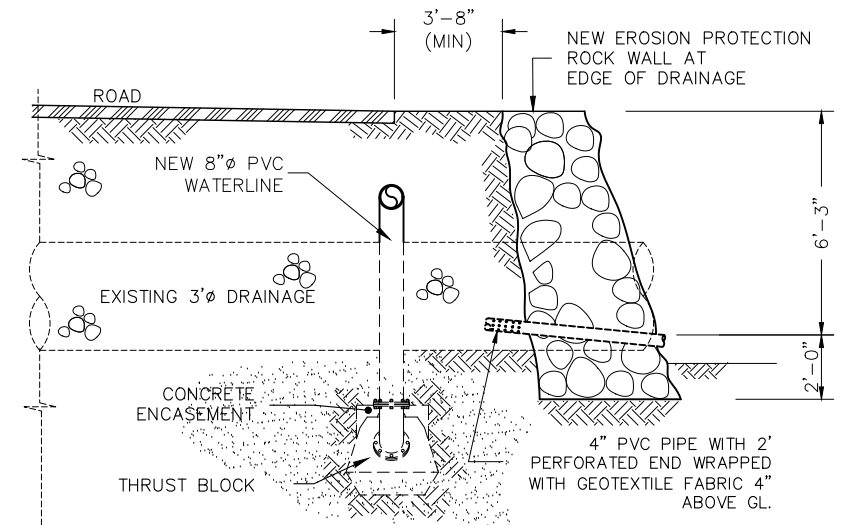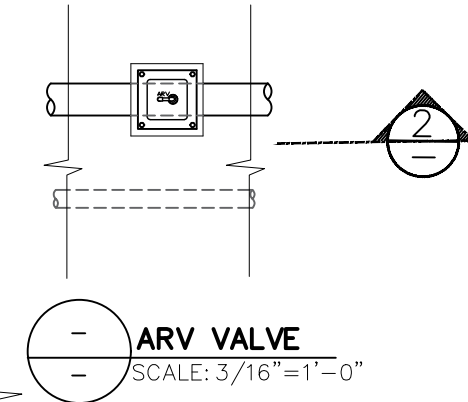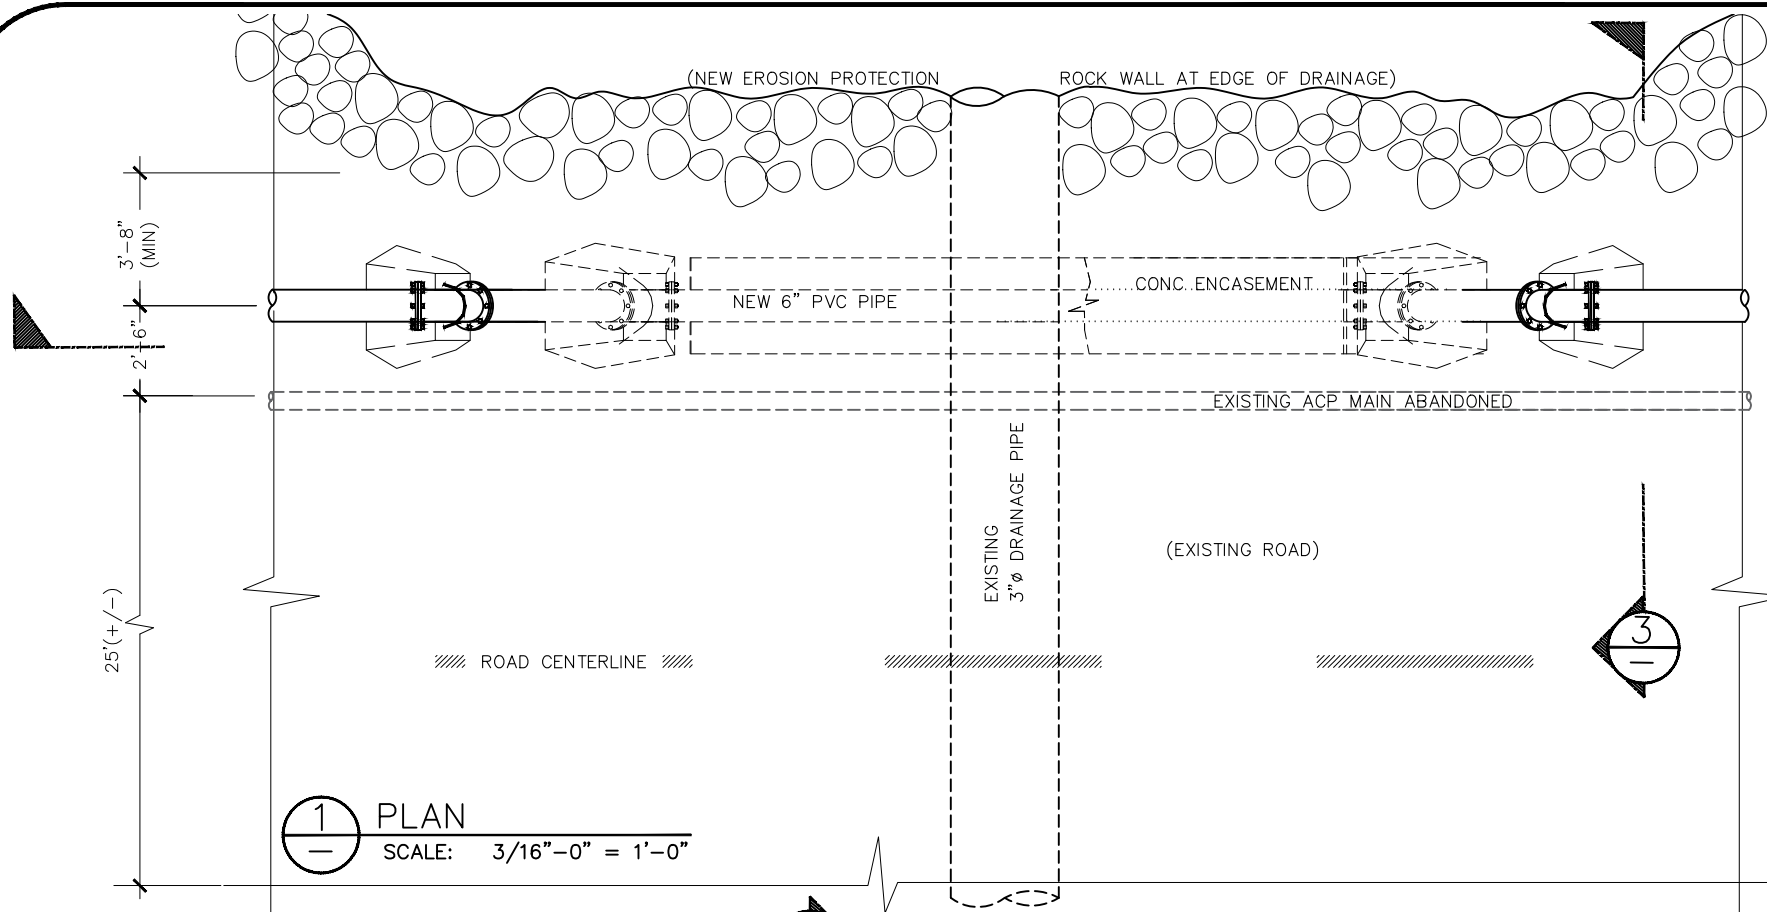

2 DRAINAGE CROSSING SECTION DETAILS

SCALE: 3/16" = 1'-0"

4 DRAINAGE LATITUDE SECTION DETAILS

SCALE: 3/16" = 1'-0"

No.	Description	Date

REV. NO.:
REVISION:
CHECKED BY:
APPROVED BY:
DATE:

DESIGNED BY:
CHECKED BY:
APPROVED BY:
ISSUE FOR:




AMERICAN SAMOA POWER AUTHORITY
ENGINEERING SERVICES DIVISION
P.O.BOX PPB, TAFUNA, PAGO PAGO, AS 96799

PROJECT NAME:
DRAWING TITLE:
PROJECT LOCATION:

PROJECT NO:
SIGNATURE:
DATE:

SCALE:
DATE:
SHEET NO.

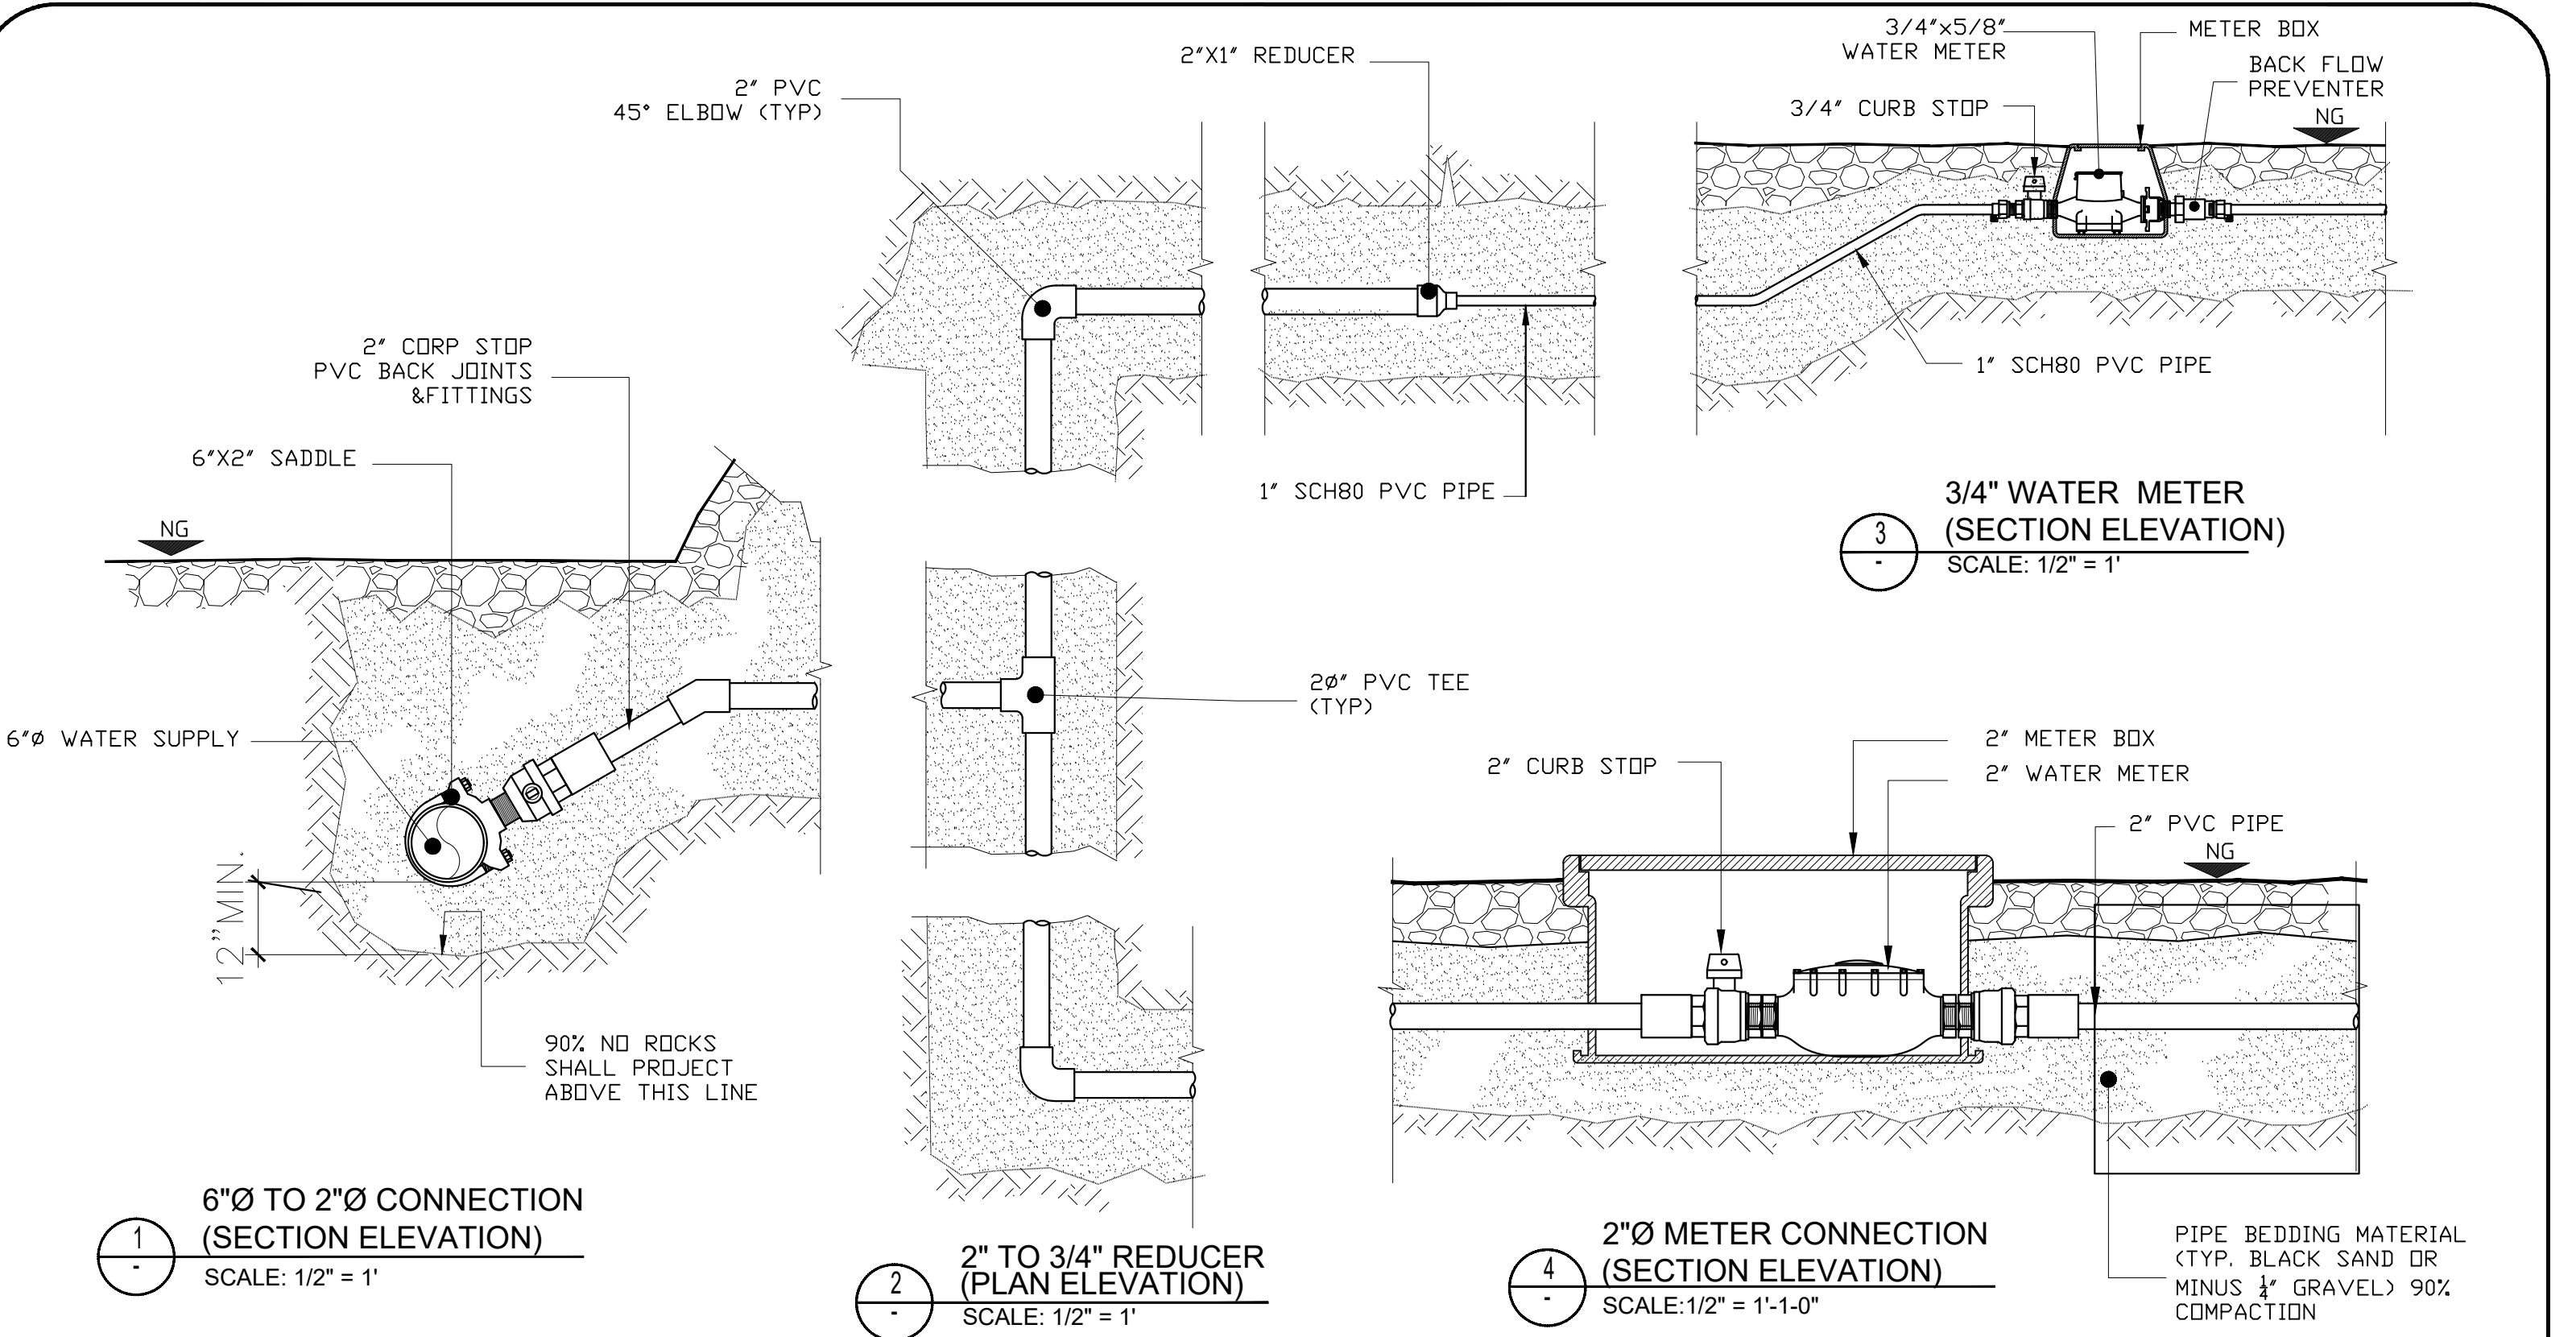

<table><tr><th>No.</th><th>Description</th><th>Date</th></tr><tr><td> </td><td> </td><td> </td></tr><tr><td> </td><td> </td><td> </td></tr><tr><td> </td><td> </td><td> </td></tr><tr><td> </td><td> </td><td> </td></tr><tr><td> </td><td> </td><td> </td></tr><tr><td> </td><td> </td><td> </td></tr><tr><td> </td><td> </td><td> </td></tr></table>			No.	Description	Date																						<table><tr><td>REV. NO.:</td><td>DESIGNED BY:</td></tr><tr><td> </td><td>F.Toala</td></tr><tr><td>REVISION:</td><td>CHECKED BY:</td></tr><tr><td> </td><td>L.Tyrell</td></tr><tr><td>CHECKED BY:</td><td>APPROVED BY:</td></tr><tr><td> </td><td>F.Aquila / L.Tyrell</td></tr><tr><td>APPROVED BY:</td><td>ISSUE FOR:</td></tr><tr><td> </td><td>Construction</td></tr><tr><td>DATE:</td><td> </td></tr></table>		REV. NO.:	DESIGNED BY:		F.Toala	REVISION:	CHECKED BY:		L.Tyrell	CHECKED BY:	APPROVED BY:		F.Aquila / L.Tyrell	APPROVED BY:	ISSUE FOR:		Construction	DATE:		 AMERICAN SAMOA POWER AUTHORITY ENGINEERING SERVICES DIVISION P.O.BOX PPB, TAFUNA, PAGO PAGO, AS 96799 PROJECT NAME: PHASE 3 VAITOGI HDPE PIPE REPLACEMENT WATERLINE PROJECT DRAWING TITLE: TYPICAL PVC PIPE SERVICE LINE LAYOUT & CONNECTION DETAILS PROJECT LOCATION: VAITOGI VILLAGE, AMERICAN SAMOA		<table><tr><td>PROJECT NO.:</td><td>SCALE:</td></tr><tr><td>#1658785</td><td>AS SHOWN</td></tr><tr><td>SIGNATURE:</td><td>DATE:</td></tr><tr><td> </td><td>JAN-2024</td></tr><tr><td>DATE:</td><td>SHEET NO.</td></tr><tr><td> </td><td>D09</td></tr></table>		PROJECT NO.:	SCALE:	#1658785	AS SHOWN	SIGNATURE:	DATE:		JAN-2024	DATE:	SHEET NO.		D09
No.	Description	Date																																																												
REV. NO.:	DESIGNED BY:																																																													
	F.Toala																																																													
REVISION:	CHECKED BY:																																																													
	L.Tyrell																																																													
CHECKED BY:	APPROVED BY:																																																													
	F.Aquila / L.Tyrell																																																													
APPROVED BY:	ISSUE FOR:																																																													
	Construction																																																													
DATE:																																																														
PROJECT NO.:	SCALE:																																																													
#1658785	AS SHOWN																																																													
SIGNATURE:	DATE:																																																													
	JAN-2024																																																													
DATE:	SHEET NO.																																																													
	D09																																																													

EROSION AND TEMPORARY DUST CONTROL

1. DURING CONSTRUCTION, PREVENTIVE MAINTENANCE MEASURES SHALL BE USED TO CONTROL FORESEEABLE DUST, EROSION OR SEDIMENTATION PROBLEMS WHICH MAY ARISE AS THE JOB PROGRESSES.
2. FUGITIVE DUST AND SOLID WASTE DISPOSAL DURING GRUBBING ACTIVITIES SHALL MEET REQUIREMENTS OF ADMINISTRATIVE RULES, TITLE II, CHAPTER 60, AIR POLLUTION CONTROL AND CHAPTER 58, SOLID WASTE MANAGEMENT CONTROL.
3. THE CONTRACTOR AT HIS OWN EXPENSE, SHALL KEEP THE PROJECT AREA AND SURROUNDING AREA FREE FROM DUST NUISANCE. THE WORK SHALL BE IN CONFORMANCE WITH THE AIR POLLUTION CONTROL STANDARDS AND REGULATIONS OF THE STATE DEPARTMENT OF HEALTH.
4. WHERE CONSTRUCTION ACTIVITY ON A PORTION OF THE SITE IS TEMPORARILY CEASED, AND EARTH DISTURBING ACTIVITIES WILL BE RESUMED WITHIN 14 DAYS, TEMPORARILY STABILIZATION MEASURES DO NOT HAVE TO BE INITIATED ON THAT PORTION OF THE SITE. ALL EXPOSED AREAS TO BE LEFT EXPOSED FOR LONGER THAN FOURTEEN (14) DAYS SHALL BE HYDROMULCH SEEDED WITH RYE GRASS.
5. ALL SLOPES AND EXPOSED AREAS SHALL BE SODDED OR PLANTED AS SOON AS FINAL GRADES HAVE BEEN ESTABLISHED. PLANTING SHALL NOT BE DELAYED UNTIL ALL GRADING WORKS HAS BEEN COMPLETED. GRADING TO FINAL GRADE SHALL BE CONTINUOUS, AND ANY AREA WITHIN WHICH WORK HAS BEEN INTERRUPTED OR DELAYED SHALL BE PLANTED.


BEST MANAGEMENT PRACTICE NOTES

1. MEASURES TO CONTROL EROSION AND OTHER POLLUTANTS SHALL BE IN PLACE BEFORE ANY WORK IS INITIATED. THESE MEASURES SHALL BE PROPERLY CONSTRUCTED AND MAINTAINED THROUGHOUT THE CONSTRUCTION PERIOD.
2. ALL TEMPORARY EROSION CONTROL MEASURES SHALL BE CHECKED AND REPAIRED AS NECESSARY.
3. GRASSING OR MULCHING OF EXPOSED AREAS TO BE DONE AS FINISH GRADES ARE ESTABLISHED.
4. DIVERSION OF STORM RUNOFF AWAY FROM THE FILL SLOPES UNTIL GRASSING ON THE FILL SLOPES ARE ESTABLISHED.
5. PROVIDE STABILIZED CONSTRUCTION ENTRANCE.

NOTES:


1. STABILIZED CONSTRUCTION ENTRANCE SHALL BE MAINTAINED AT THE EGRESS AND INGRESS TO THE SITE. TIRE WASH MAY BE USED IN LIEU OF STABILIZED CONSTRUCTION ENTRANCE. CONTRACTOR IS RESPONSIBLE TO KEEP ROADWAYS CLEAN FROM SOIL AND CONSTRUCTION DEBRIS.
2. DUST CONTROL SHOULD BE APPLIED TO REDUCE DUST EMISSIONS. WATER THE AREA DURING CONSTRUCTION TO CONTROL DUST.
3. ALL STORM DRAIN INLETS ON SITE AND THOSE OFF SITE WHICH MAY RECEIVE RUN OFF FROM THE SITE SHALL USE AN INLET PROTECTION DEVICE.

	CONSTRUCTION ENTRANCE	(CE)
	SILT FENCE	(SF)
	DIVERSION DIKE	(DD)
	RIGHT-OF-WAY DIVERSION	(RWD)
	TEMPORARY LEVEL SPREADER	(LS)
	TEMPORARY LEVEL DIVERSION	(LD)
	TEMPORARY FILL DIVERSION	(TFD)
	INLET PROTECTION	(IP)
	EC-2 MATTING	(B/M)
	EC-3 MATTING	(B/M)
	EXISTING TREELINE	
	EXISTING WATERS	
	EXISTING 100' STREAM BUFFER	
	PROPOSED TREELINE	
	PROPOSED GRADING	
	SEDIMENT BASIN DRAINAGE AREA	
	PEA GRAVEL LEVEL SPREADER	
	PEA GRAVEL LEVEL SPREADER	
	LIMIT OF DISTURBANCE	
	NOTE: DUST CONTROL MEASURES ARE TO BE USED ONSITE AS NECESSARY THROUGHOUT THE CONSTRUCTION ACTIVITY	

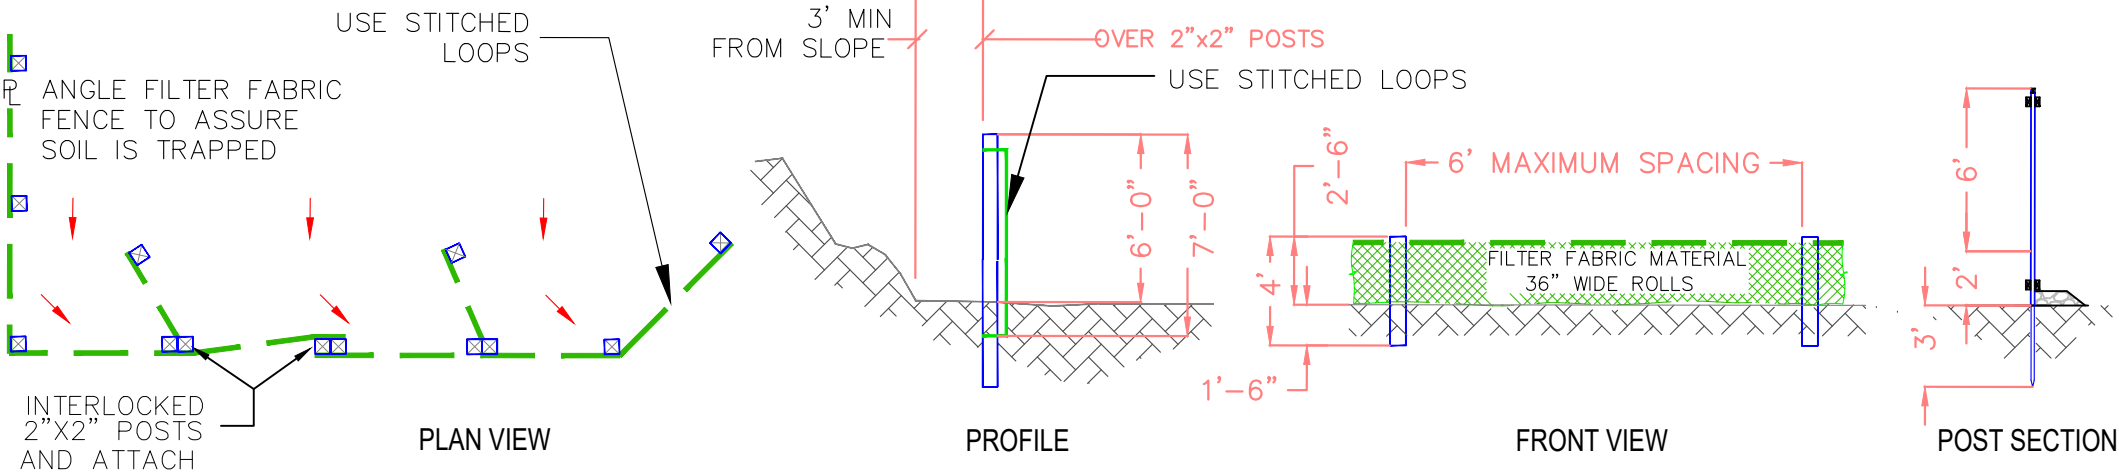


- NOTES:
1. BURY BOTTOM OF FILTER FABRIC 6" VERTICALLY BELOW FINISHED GRADE.
2. 2"x2" FIR, PINE OR STEEL FENCE POSTS.
3. POSTS TO BE INSTALLED ON UPHILL SIDE OF SLOPE.
4. COMPACT BOTH SIDES OF FILTER FABRIC TRENCH.
5. PANELS MUST BE PLACED ACCORDING TO SPACING ON DETAIL NO.940

<table><tr><th>No.</th><th>Description</th><th>Date</th></tr><tr><td> </td><td> </td><td> </td></tr><tr><td> </td><td> </td><td> </td></tr><tr><td> </td><td> </td><td> </td></tr><tr><td> </td><td> </td><td> </td></tr><tr><td> </td><td> </td><td> </td></tr><tr><td> </td><td> </td><td> </td></tr><tr><td> </td><td> </td><td> </td></tr></table>			No.	Description	Date																						<table><tr><td>REV. NO.:</td><td>DESIGNED BY:</td></tr><tr><td> </td><td>F.Toala</td></tr><tr><td>REVISION:</td><td>CHECKED BY:</td></tr><tr><td> </td><td>L.Tyrell</td></tr><tr><td>CHECKED BY:</td><td>APPROVED BY:</td></tr><tr><td> </td><td>F.Aquila / L.Tyrell</td></tr><tr><td>APPROVED BY:</td><td>ISSUE FOR:</td></tr><tr><td> </td><td>Construction</td></tr><tr><td>DATE:</td><td> </td></tr></table>		REV. NO.:	DESIGNED BY:		F.Toala	REVISION:	CHECKED BY:		L.Tyrell	CHECKED BY:	APPROVED BY:		F.Aquila / L.Tyrell	APPROVED BY:	ISSUE FOR:		Construction	DATE:		 AMERICAN SAMOA POWER AUTHORITY ENGINEERING SERVICES DIVISION P.O.BOX PPB, TAFUNA, PAGO PAGO, AS 96799		<table><tr><td colspan="2">PROJECT NAME:</td></tr><tr><td colspan="2">PHASE 3 VAITOGI HDPE PIPE REPLACEMENT WATERLINE PROJECT</td></tr><tr><td colspan="2">DRAWING TITLE:</td></tr><tr><td colspan="2">EROSION & SEDIMENTATION CONTROL GENERAL NOTES CONSTRUCTION SITE SIGNS & SYMBOLS DEFINITIONS.</td></tr><tr><td colspan="2">PROJECT LOCATION:</td></tr><tr><td colspan="2">VAITOGI VILLAGE, AMERICAN SAMOA</td></tr></table>		PROJECT NAME:		PHASE 3 VAITOGI HDPE PIPE REPLACEMENT WATERLINE PROJECT		DRAWING TITLE:		EROSION & SEDIMENTATION CONTROL GENERAL NOTES CONSTRUCTION SITE SIGNS & SYMBOLS DEFINITIONS.		PROJECT LOCATION:		VAITOGI VILLAGE, AMERICAN SAMOA		<table><tr><td>PROJECT NO:</td><td>SCALE:</td></tr><tr><td>#1658785</td><td>SCALE TO FIT</td></tr><tr><td>SIGNATURE:</td><td>DATE:</td></tr><tr><td> </td><td>JAN-2024</td></tr><tr><td>DATE:</td><td>SHEET NO.</td></tr><tr><td> </td><td>ESC-1</td></tr></table>	PROJECT NO:	SCALE:	#1658785	SCALE TO FIT	SIGNATURE:	DATE:		JAN-2024	DATE:	SHEET NO.		ESC-1
No.	Description	Date																																																																									
REV. NO.:	DESIGNED BY:																																																																										
	F.Toala																																																																										
REVISION:	CHECKED BY:																																																																										
	L.Tyrell																																																																										
CHECKED BY:	APPROVED BY:																																																																										
	F.Aquila / L.Tyrell																																																																										
APPROVED BY:	ISSUE FOR:																																																																										
	Construction																																																																										
DATE:																																																																											
PROJECT NAME:																																																																											
PHASE 3 VAITOGI HDPE PIPE REPLACEMENT WATERLINE PROJECT																																																																											
DRAWING TITLE:																																																																											
EROSION & SEDIMENTATION CONTROL GENERAL NOTES CONSTRUCTION SITE SIGNS & SYMBOLS DEFINITIONS.																																																																											
PROJECT LOCATION:																																																																											
VAITOGI VILLAGE, AMERICAN SAMOA																																																																											
PROJECT NO:	SCALE:																																																																										
#1658785	SCALE TO FIT																																																																										
SIGNATURE:	DATE:																																																																										
	JAN-2024																																																																										
DATE:	SHEET NO.																																																																										
	ESC-1																																																																										

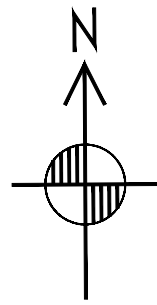

ISLAND OF TUTUILA
SCALE TO FIT PAPER

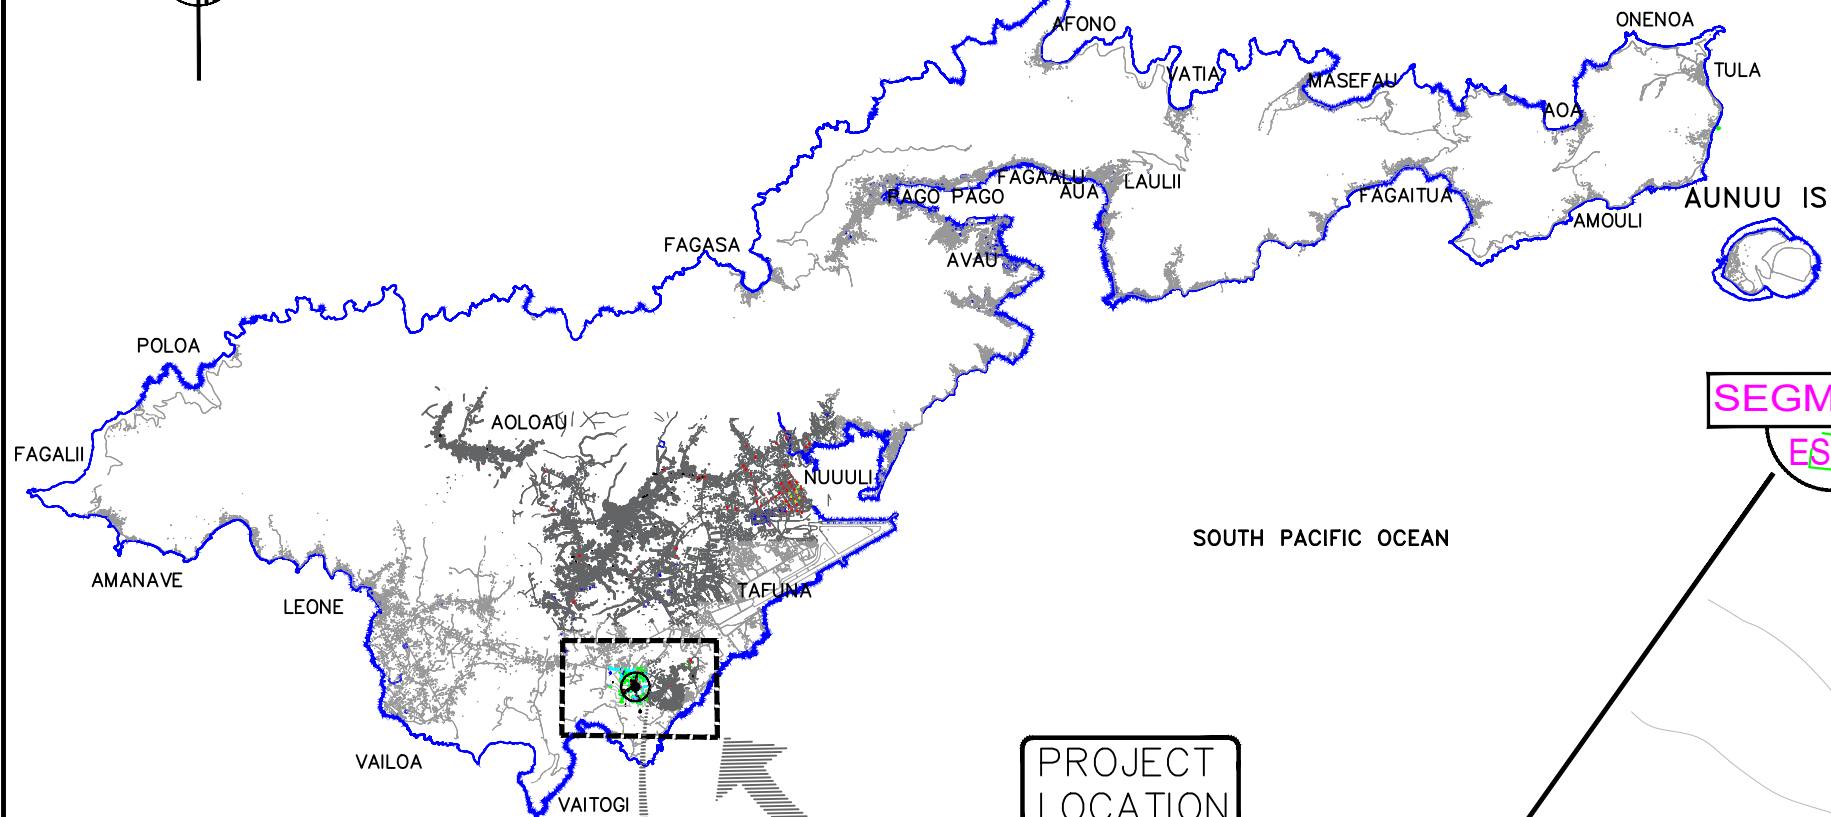

PROJECT
LOCATION

SOUTH PACIFIC OCEAN

SOUTH PACIFIC OCEAN

SOUTH PACIFIC OCEAN

SEGMENT 1
ESC-3

END OF
SEGMENT 1

START OF
SEGMENT 1

START OF
SEGMENT 2

SEGMENT 1
ESC-4

END OF
SEGMENT 2

VAITOGI

No.	Description	Date

REV. NO.:
REVISION:
CHECKED BY:
APPROVED BY:
DATE:

DESIGNED BY: F.Toala
CHECKED BY: L.Tyrell
APPROVED BY: F.Aquila / L.Tyrell
ISSUE FOR: Construction



AMERICAN SAMOA POWER AUTHORITY


AMERICAN SAMOA POWER AUTHORITY
ENGINEERING SERVICES DIVISION

P.O.BOX PPB, TAFUNA, PAGO PAGO, AS 96799

PROJECT NAME: PHASE 3 VAITOGI HDPE PIPE REPLACEMENT WATERLINE PROJECT
DRAWING TITLE: EROSION & SEDIMENTATION CONTROL / VICINITY MAP / CONSTRUCTION LOCATION SITE
PROJECT LOCATION: VAITOGI VILLAGE, AMERICAN SAMOA

PROJECT NO: #1958785
SIGNATURE:
DATE:

SCALE: SCALE TO FIT
DATE: JAN-2024
SHEET NO. ESC-2

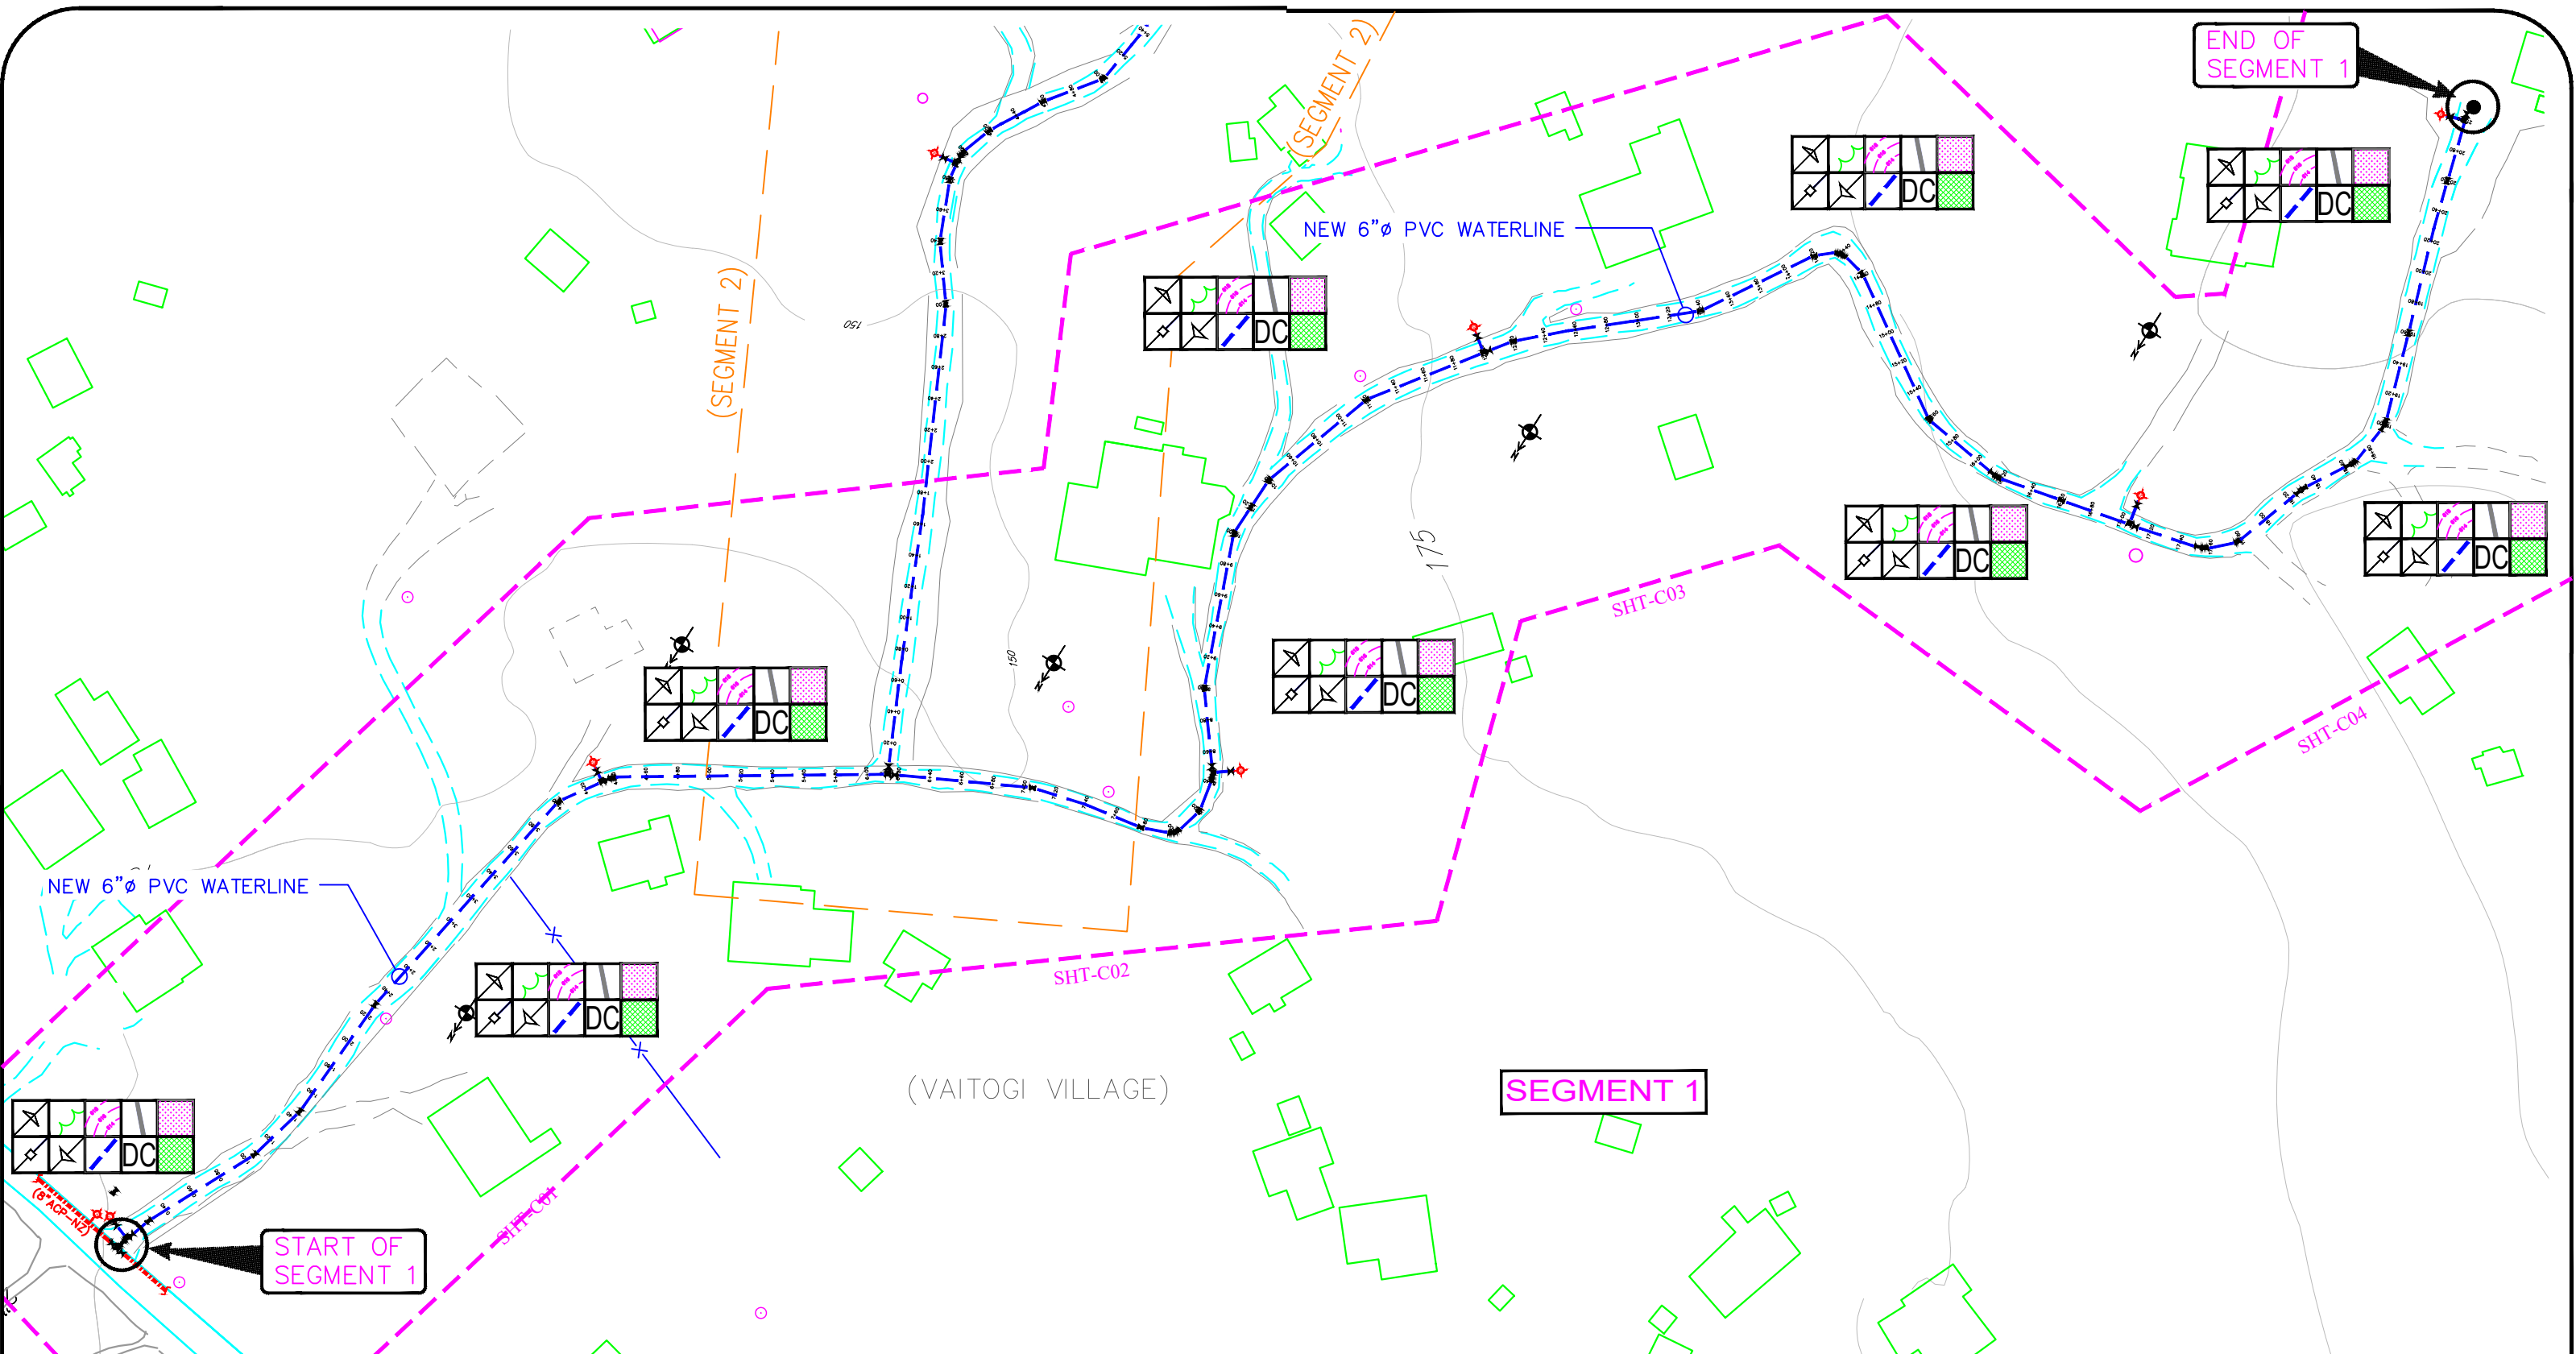

No.	Description	Date

REV. NO.:
REVISION:
CHECKED BY:
APPROVED BY:
DATE:

DESIGNED BY: F.Toala
CHECKED BY: L.Tyrell
APPROVED BY: F.Aquila / L.Tyrell
ISSUE FOR: Construction



AMERICAN SAMOA POWER AUTHORITY
ENGINEERING SERVICES DIVISION
P.O.BOX PPB, TAFUNA, PAGO PAGO, AS 96799

PROJECT NAME: PHASE 3 VAITOGI HDPE PIPE REPLACEMENT WATERLINE PROJECT
DRAWING TITLE: SEGMENT 1, EROSION & SEDIMENTATION CONTROL PLAN & PROFILE (STA, 0+00 TO 21+00)
PROJECT LOCATION: VAITOGI VILLAGE, AMERICAN SAMOA




PROJECT NO: #1958785
SIGNATURE:
DATE:

SCALE: SCALE TO FIT
DATE: JAN-2024
SHEET NO. ESC-3

PHASE 3 VAITOGI HDPE PIPE REPLACEMENT WATERLINE PROJECT
TUTUILA ISLAND, AMERICAN SAMOA.

SHEET #		DESCRIPTION		ABBREVIATIONS:			
		@	AT	PROP	PROPOSED		
	VICINITY MAP & GENERAL NOTES	AFF	ABOVE FINISHED FLOOR	PVC	POLYVINYL CHLORIDE PIPE		
G1	VICINITY MAP, LOCATION PLAN	AFG	ABOVE FINISHED GRADE	PE	POLYETHYLENE PIPE		
G2	TABLE OF CONTENTS. ABBREVIATIONS	AGG	AGGREGATE	ACP	ASBESTOS CEMENT PIPE		
G3	LEGEND, GENERAL NOTES	ARV	AIR/VAC RELEASE VALVE	GA	GAUGE		
G4	CONSTRUCTION NOTES	AS-EPA	AMERICAN SAMOA ENVIRONMENTAL PROTECTION AGENCY	GALV	GALVANIZED		
		BLDG	BUILDING	GR	GRADE		
	EROSION PLANS / DETAILS	CB	CATCH BASIN	GV	GATEVALVE		
ESC1	VICINITY MAP FOR EROSION AND SEDIMENTATION CONTROL / GENERAL NOTES	CI	CAST IRON	HB	HOSE BIB		
ESC2	EROSION AND SEDIMENTATION CONTROL & DETAILS	CL	CENTER LINE	HWY	HIGHWAY		
ESC3	EROSION AND SEDIMENTATION CONTROL	CMP	CORRUGATED METAL PIPE	ID	INSIDE DIAMETER		
		CO	CLEAN OUT	INSUL	INSULATION		
	SEGMENT 1 PLANS & PROFILE	CONC	CONCRETE	INV	INVERT		
C01	START OF SEGMENT 1, PLAN & PROFILE (STA 0+00 – STA 5+00)	CP	CONTROL POINT	IR	IRON ROD		
C02	SEGMENT 1, PLAN & PROFILE (STA 5+00 – STA 10+00)	DET	DETAIL	JT	JOINT		
C03	SEGMENT 1, PLAN & PROFILE (STA 10+00 – STA 15+00)	DIA	DIAMETER	LT	LEFT		
C04	END OF SEGMENT 1, PLAN & PROFILE (STA 15+00 – STA 21+00)	DIM	DIMENSION	M	METER		
		DIP	DUCTILE IRON PIPE	MANUF	MANUFACTURED		
	SEGMENT 2 PLANS & PROFILE	DW	DRIVEWAY	MAX	MAXIMUM		
C05	START OF SEGMENT 2, PLAN & PROFILE (STA 0+00 – STA 5+00)	E	EAST	MFR	MANUFACTURER		
C06	SEGMENT 2, PLAN & PROFILE (STA 5+00 – STA 10+00)	ELEV	ELEVATION	MH	MANHOLE		
C07	END OF SEGMENT 2, PLAN & PROFILE (STA 10+00 – STA 14+00)	ELEC	ELECTRICAL	MIN	MINIMUM		
		EOL	END OF LINE	MISC	MISCELLANEOUS		
	CONSTRUCTION DRAWINGS	EOP	EDGE OF PAYMENT	(N)	NEW		
D01	GATE VALVE, GATE VALVE BOX DETAILS	EQ	EQUAL	N	NORTH		
D02	AIR RELIEF VALVE DETAILS	EXT'G	EXISTING	NIC	NOT IN CONTRACT		
D03	THRUST BLOCK DETAILS	EXT	EXTERIOR	NO	NOT OPEN		
D04	UTILITY CROSSING DETAILS	FD	FLOOR DRAIN	NC	NORMALLY CLOSED		
D05	BACTERIOLOGICAL SAMPLING STATION DETAILS	FH	FIRE HYDRANT	NTS	NOT TO SCALE		
D06	FIRE HYDRANT DETAILS	FIN	FINISHED	OC	ON CENTER		
D07	TYPICAL MAIN ROAD CROSSING SECTION DETAIL	FLR	FLOOR	OD	OUTSIDE DIAMETER		
D08	TYPICAL ROAD SECTION DETAILS	FND	FOUND	OH	OVERHEAD		
D09	MAINLINE SUPPLY TO SERVICE LINE CONNECTION	FT	FEET	OSHA	OCCUPATIONAL SAFETY HEALTH ADMINISTRATION		
D10	TIE-IN DETAILS	FTG	FOOTING	SC	SERVICE CONNECTION		
D11	PRESSURE SUSTAINING VALVE DETAILS	PL	PROPERTY LINE				

No.	Description	Date	REV. NO.:	DESIGNED BY:	ASPA AMERICAN SAMOA POWER AUTHORITY AMERICAN SAMOA POWER AUTHORITY ENGINEERING SERVICES DIVISION P.O.BOX PPB, TAFUNA, PAGO PAGO, AS 96799	PROJECT NAME:	PROJECT NO:	SCALE:
			REVISION:	F.Toala		PHASE 3	#1958785	SCALE TO FIT
			CHECKED BY:	L.Tyrell		VAITOGI HDPE PIPE REPLACEMENT	SIGNATURE:	DATE:
			APPROVED BY:	F.Aquila / L.Tyrell		WATERLINE PROJECT	DATE:	JAN-2024
			DATE:	ISSUE FOR:		DRAWING TITLE:		SHEET NO.
				Construction		TABLE OF CONTENTS & ABBREVIATIONS		G1
					PROJECT LOCATION:			
						VAITOGI VILLAGE, AMERICAN SAMOA		

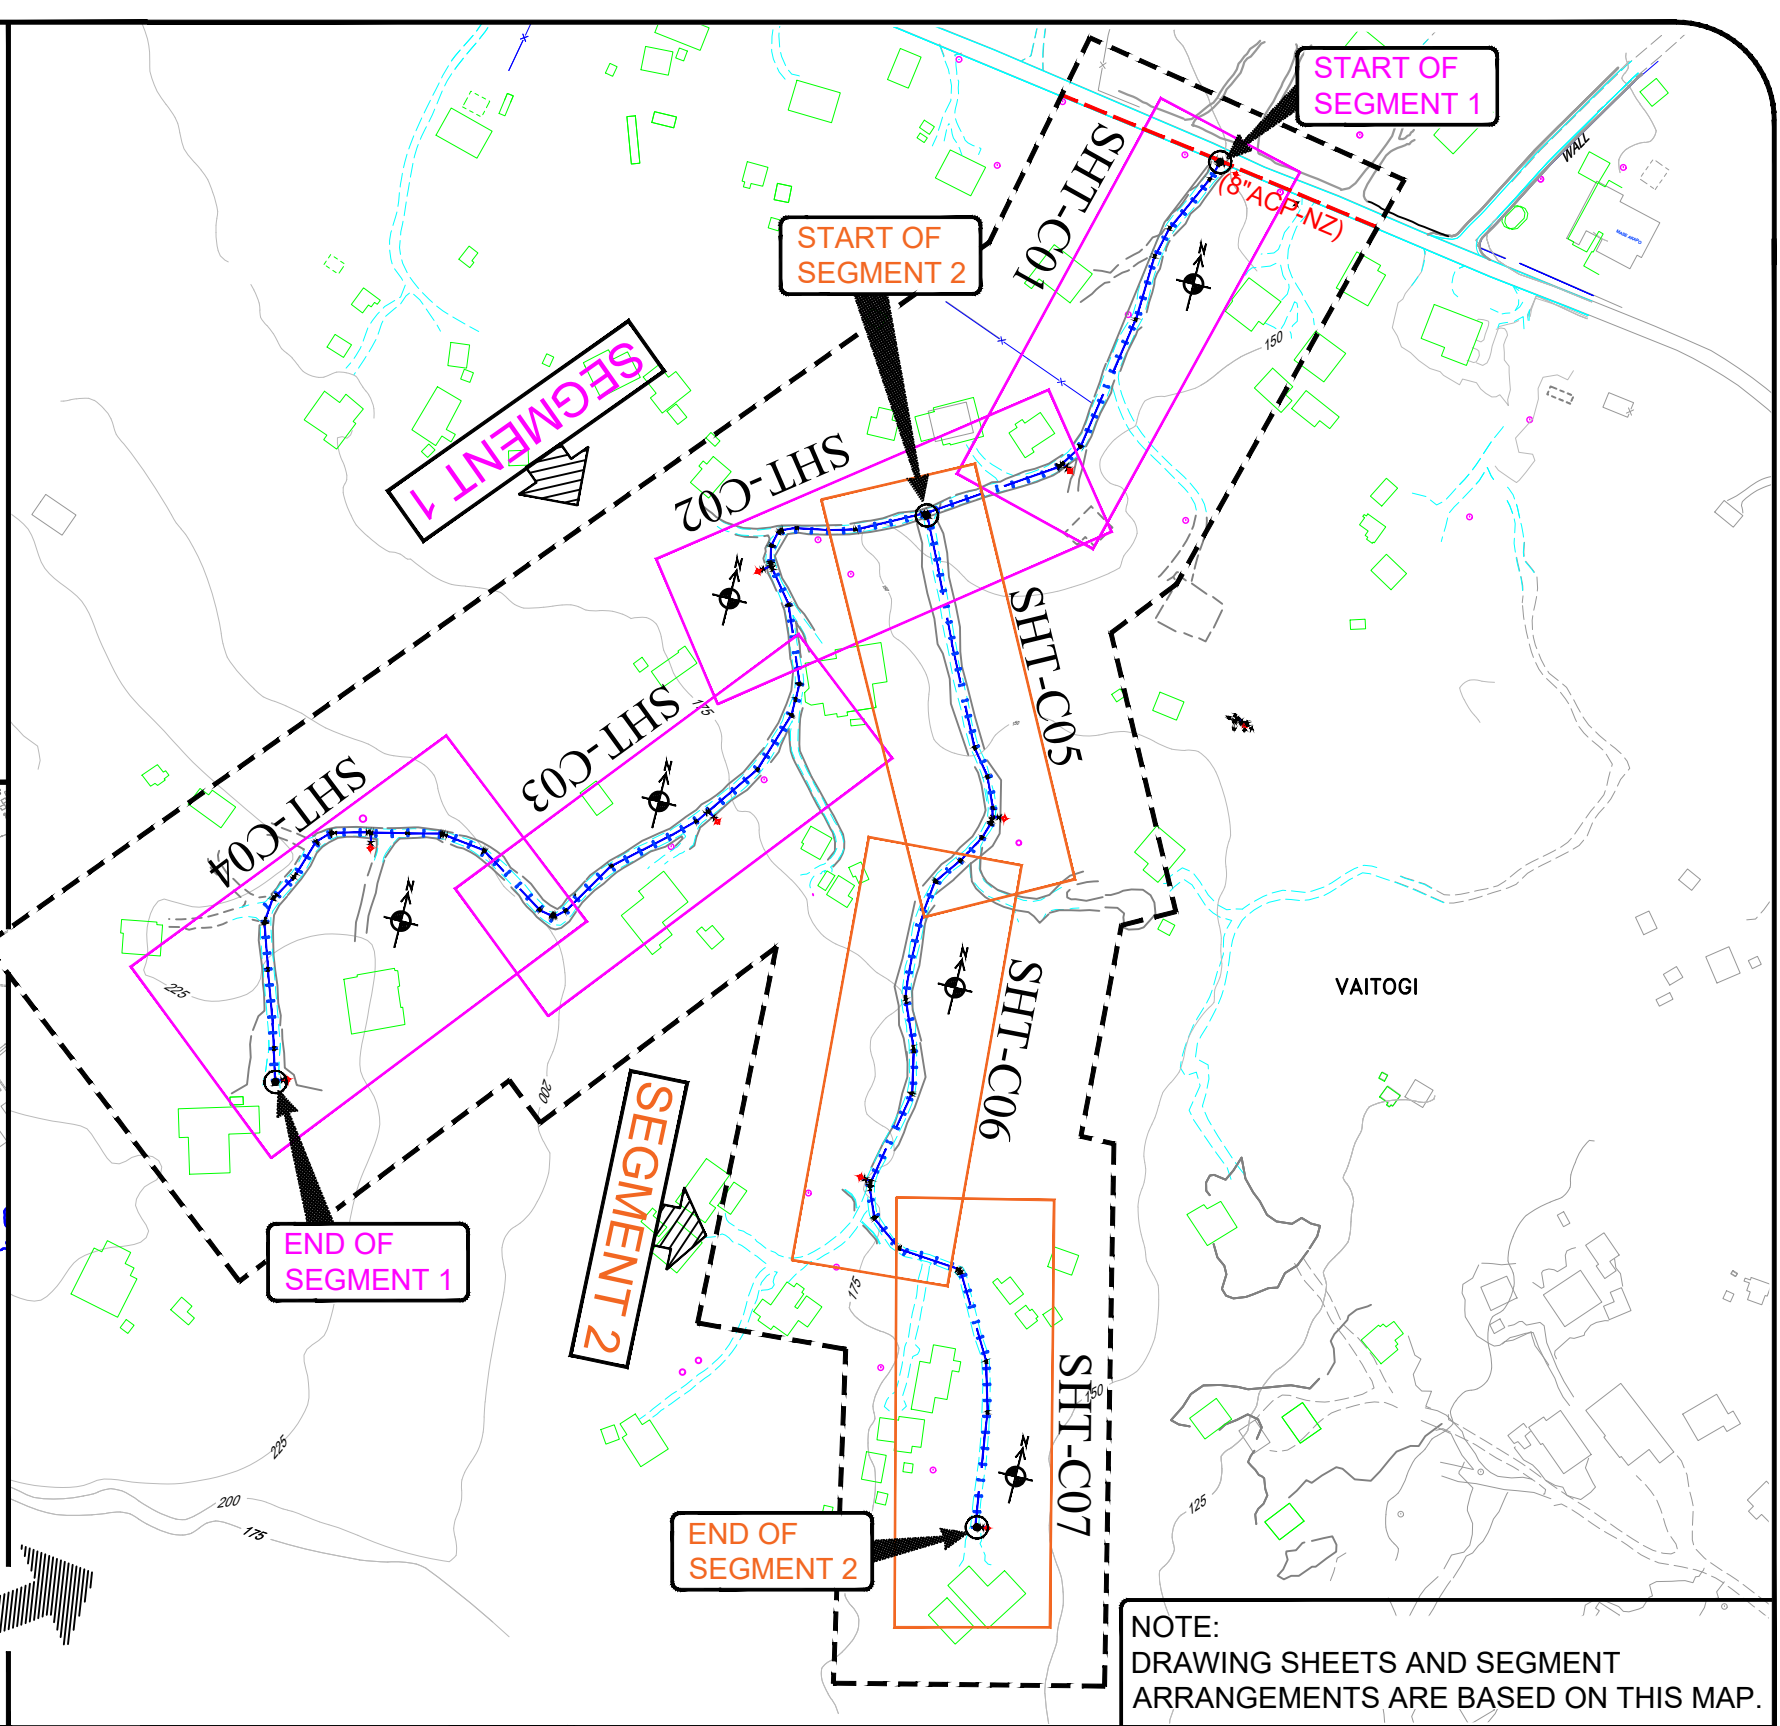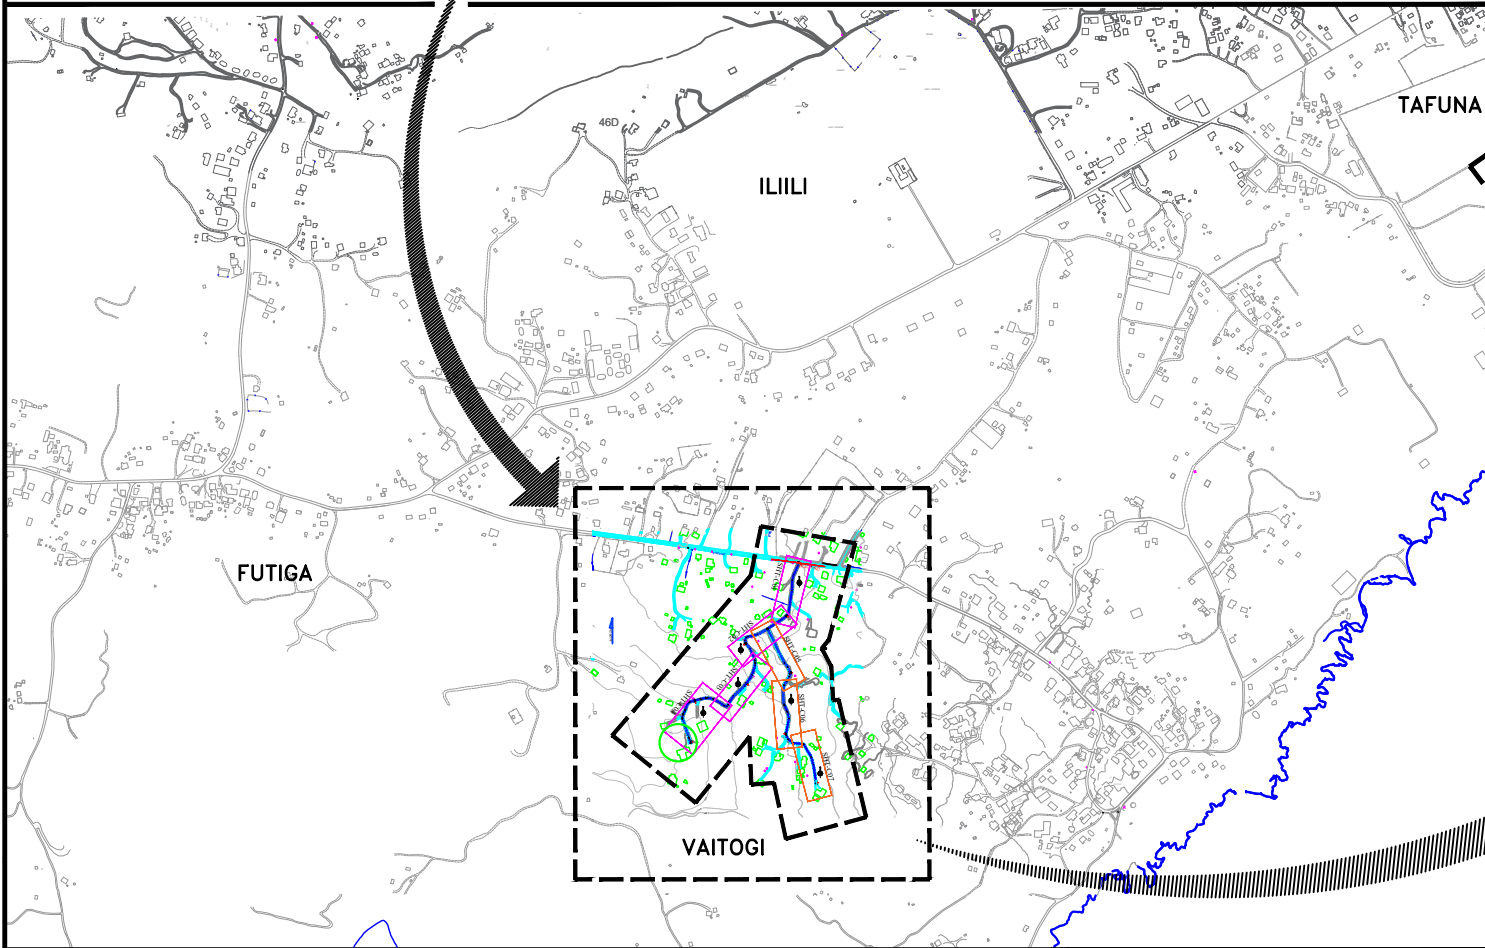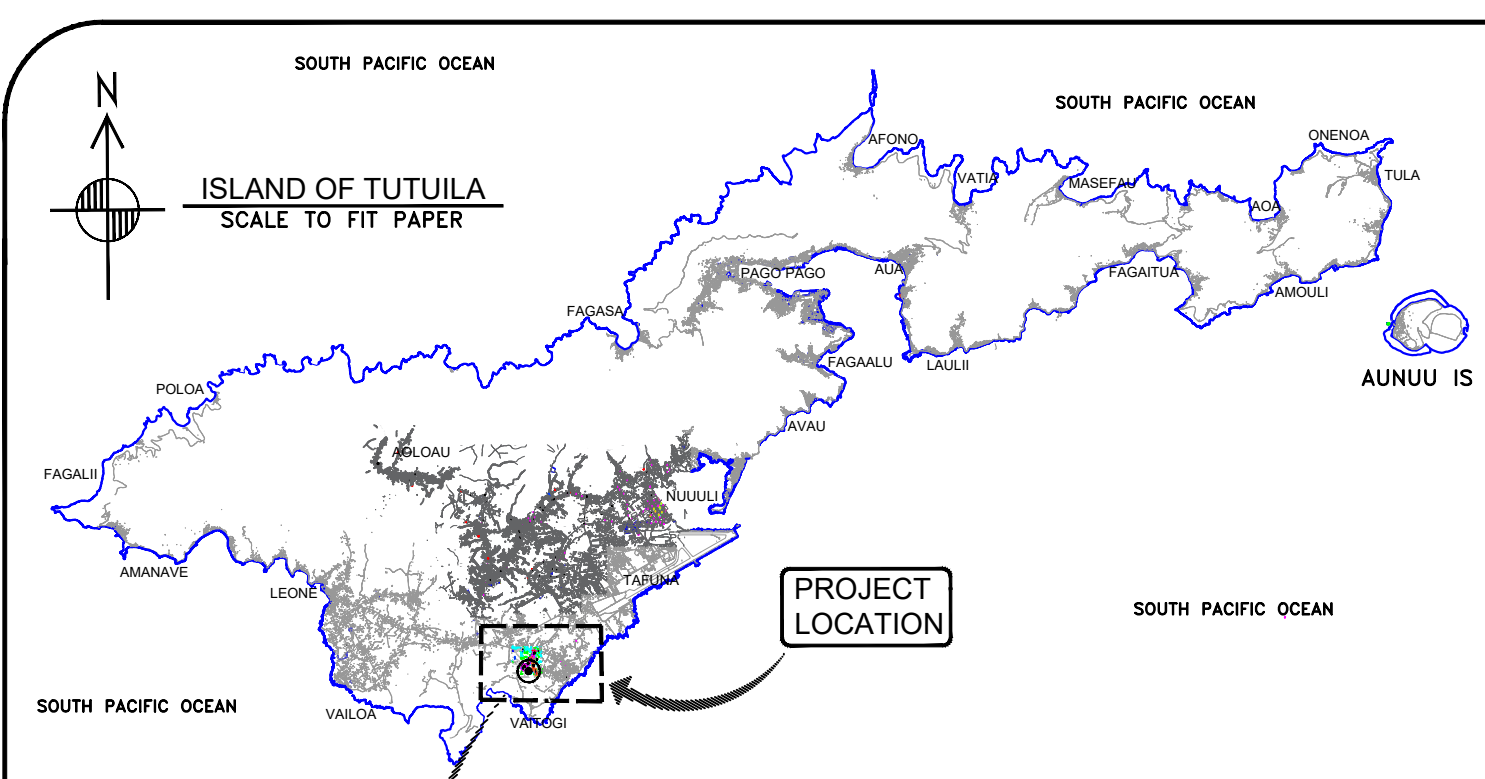

No.	Description	Date

REV. NO.:	DESIGNED BY:
REVISION:	CHECKED BY:
CHECKED BY:	APPROVED BY:
APPROVED BY:	ISSUE FOR:
DATE:	

F.Toala
L.Tyrell
F.Aquila / L.Tyrell
Construction



AMERICAN SAMOA POWER AUTHORITY
ENGINEERING SERVICES DIVISION
P.O.BOX PPB, TAFUNA, PAGO PAGO, AS 96799

PROJECT NAME:	PROJECT NO:
PHASE 3 VAITOGI HDPE PIPE REPLACEMENT WATERLINE PROJECT	#1958785
DRAWING TITLE:	SIGNATURE:
VICINITY MAP & SEGMENT LOCATIONS	DATE:
PROJECT LOCATION:	SHEET NO.
VAITOGI VILLAGE, AMERICAN SAMOA	G2

SCALE:	SCALE TO FIT
DATE:	JAN-2024
SHEET NO.	G2

LEGEND:

 
 WATER MAIN

 EXISTING WATER MAIN

 GATE VALVE

 FIRE HYDRANT

 ELBOW

 TEE

 ARV

 EXISTING WELL

 
 BENCH MARK

 POWER POLE


 WATER METER W/ BOX

 WATER SERVICE LINE

 GATE VALVE W/ BOX


 PAVED ROAD

  UNPAVED ROAD

 SIGN POST

 DIAMETER

  PRESSURE GAUGE

 CONTOUR LINE

 PRV

UTILITY GENERAL NOTES:

1. EXISTING WATERLINE LOCATIONS ARE APPROXIMATE. CONTRACTOR SHALL COORDINATE LOCATING EXISTING UTILITY WITH ASPA OR OWNERS OF UTILITY LINES PRIOR TO EXCAVATION WITH APPROPRIATE ADVANCE NOTIFICATION.

2. ABANDON EXISTING WATER MAIN AND SERVICES IN PLACE ONLY AFTER THE NEW WATER MAIN HAS BEEN DISINFECTED AND APPROVED BY THE AMERICAN SAMOA POWER AUTHORITY (ASPA) AND THE AMERICAN SAMOA ENVIRONMENTAL PROTECTION AGENCY.

3. ALL GATE VALVES ARE TO BE INSTALLED WITH VALVE BOXES PER DRAWINGS AND SPECIFICATIONS.

4. ALL FLUSH VALVES ARE TO BE INSTALLED IN VALVE BOXES PER DRAWINGS AND SPECIFICATIONS.

5. ALL STATION LOCATIONS ARE APPROXIMATE.

6. CONTRACTOR IS RESPONSIBLE FOR MEETING CONDITIONS OF THE PNRS LAND-USE PERMIT.

7. FOR CONFLICT BETWEEN DRAWINGS AND SPECIFICATIONS, PNRS PERMIT REQUIREMENTS AND CONDITIONS SHALL APPLY, THEN SPECIFICATIONS, THEN DRAWINGS.

8. CONTRACTOR MUST CONFORM WITH ALL REQUIREMENTS OF THE OSHA STANDARD FOR EXCAVATION SAFETY (29 CFR 1926 SUBPART P). INCLUDED AMONG THE OSHA STANDARDS IS THE REQUIREMENT FOR PROTECTION OF WORKERS IN EXCAVATIONS 4 FEET OR GREATER IN DEPTH. PROTECTIVE SYSTEMS CAN BE SLOPING/BENCHING OF EXCAVATION WALLS, OR INSTALLATION OF SUPPORT/SHIELDING DEVICES. DESIGN OF PROTECTIVE SYSTEMS MUST BE BASED ON FIELD CLASSIFICATION OF THE SOIL BY A COMPETENT PERSON. PROTECTIVE SYSTEMS MUST BE IN ACCORDANCE WITH THE TABLES AND FIGURES SHOWN IN THE OSHA STANDARDS, OR MUST BE A MANUFACTURED PROTECTION SYSTEM USED IN STRICT CONFORMANCE WITH MANUFACTURER'S INSTRUCTIONS, OR MUST BE A PROTECTION SYSTEM DESIGNED BY A REGISTERED PROFESSIONAL ENGINEER. THE
9. CONTRACTOR SHALL PROVIDE BOTH CONC. ANCHORS & CLAY DIKES AS REQUIRED BY THE ENGINEER AS FOLLOWS:

10%<SLOPE<15%: ONE EVERY 200 LINEAR FEET CLAY DIKES ONLY

15% OR GREATER SLOPES: EVERY 100 LINEAR FEET-CONC. ANCHORS & CLAY DIKES.

A.) CLAY DIKES SHALL EXTEND FOR THE FULL TRENCH WIDTH (USED FOR PIPE BEDDING AND COVER) AND HAVE A LENGTH OF 5 FEET. LOCATED IN THE MIDDLE OF PIPE LENGTH, AT LEAST 2 FEET FROM A PIPE JOINT. MATERIALS SHALL BE CLAY AS DESIGNATED "CL" AND DEFINED UNDER THE UNIFIED SOIL CLASSIFICATION SYSTEM.

B.) CONC. ANCHORS SHALL BE LOCATED AT THE DOWNSTREAM SIDE OF JOINTS, SHALL BE UN-REINFORCED AND SHALL BE MINIMUM OF TRENCH WIDTH, 3 FEET HIGH (REPLACING PIPE BEDDING AND COVER) AND 2 FEET THICK.

10. LEVEL SURVEY & TOPOGRAPHIC MAPS USED FOR PLAN SHEETS ARE DATED FEB. 2006, CONDUCTED BY ASG/SURVEY DEPT. BUILDINGS AND ROADWAYS WERE UPDATED BY AERIAL PHOTOGRAPHY DURING AUGUST/SEPTEMBER 1990. LOCATIONS, BUILDING LOCATIONS, AND OTHER FEATURES MAY HAVE CHANGED SINCE THE LAST MAP UPDATE.

11. UTILITIES KNOWN TO EXIST BY THE ENGINEER FROM RESEARCH OF THE AVAILABLE RECORDS ARE SHOWN ON THE DRAWINGS. NO RESPONSIBILITY IS CLAIMED FOR COMPLETENESS OR ACCURACY. PRIOR TO STARTING CONSTRUCTION, VERIFY LOCATION AND ELEVATION OF ALL EXISTING UTILITIES WHICH MAY INTERFERE WITH THE FACILITIES INSTALLED UNDER THIS CONTRACT.

12. ELEVATIONS USED IN THE DRAWINGS ARE BASED ON 0.00 AT THE MEAN SEA LEVEL, HORIZONTAL COORDINATES ARE BASED ON THE AMERICAN SAMOA COORDINATE SYSTEM GRID.
13. PROVIDE, INSTALL, AND MAINTAIN SIGNS BARRICADES, MARKERS, CONES AND PROTECTIVE FACILITIES AND TAKE ALL NECESSARY PRECAUTIONS FOR THE PROTECTION, CONVENIENCE AND SAFETY OF THE PUBLIC DURING THE CONSTRUCTION OPERATIONS, CONFORM TO THE REQUIREMENTS OF THE DEPARTMENT OF PUBLIC SAFETY AND THE DEPARTMENT OF PUBLIC WORKS IN REGARD TO TRAFFIC SAFETY WHILE WORKING IN THE PUBLIC RIGHT-OF-WAY. ALL TRAFFIC CONTROL PLANS MUST BE APPROVED BY DPS AND PUBLIC WORKS PRIOR TO START OF CONSTRUCTION.

14. MAINTAIN TWO-WAY TRAFFIC ON HIGHWAY AT ALL TIMES UNLESS PRIOR PERMISSION TO CLOSE ONE LANE IS OBTAINED FROM THE DEPARTMENT OF PUBLIC SAFETY. IF THE LANE CLOSURE IS REQUIRED, PROPER ADVANCE NOTICE TO PUBLIC VIA NORMAL PUBLICATION OR RADIO ANNOUNCEMENTS IS REQUIRED.

15. KEEP THE WORK SITE AND SURROUNDING AREAS FREE FROM DUST NUISANCE. DUST CONTROL, SEDIMENTATION CONTROL, AND ALL SUCH PLANS MUST BE APPROVED BY THE AMERICAN SAMOA ENVIRONMENTAL PROTECTION AGENCY PRIOR TO START OF CONSTRUCTION.

16. REMOVE ALL SILT AND DEBRIS RESULTING FROM THE WORK AND DEPOSITED IN DRAINAGE FACILITIES, ROADWAYS, AND OTHER AREAS WHEN NECESSARY. CONSTRUCT SILT FENCES AND OTHER EROSION CONTROL DEVICES AROUND THE WORK TO PREVENT DAMAGE TO STREAMS OR OTHER WATERWAYS.
17. BARRICADE OPEN EXCAVATIONS AND POST WITH WARNING LIGHTS. KEEP UNATTENDED EXCAVATIONS FREE OF WATER AND MAINTAIN SLOPING AND STABLE WALLS WHEN OVER 4 FEET DEEP. LEAVE A LADDER OR OTHER DEVICE TO ALLOW ESCAPE FROM EXCAVATION. WHEN PERSONNEL ARE IN THE EXCAVATION, AT LEAST 2 MEANS OF EGRESS ARE REQUIRED. LADDERS ARE REQUIRED TO ALLOW NOT MORE THAN 25 FEET OF LATERAL TRAVEL FOR TRENCH EGRESS.

18. THE CONTRACTOR IS RESPONSIBLE FOR PROVIDING ALL NECESSARY EQUIPMENT AND MATERIALS FOR TESTING WATERLINES.

19. ROADS AND PROPERTIES AFFECTED BY EXCAVATION MUST BE REFURBISHED TO ORIGINAL STATUS OR BETTER AT COMPLETION OF PROJECT.

20. CONTRACTOR TO PROVIDE ELECTRONIC AS-BUILT DRAWINGS IN AUTODESK LAND DEVELOPMENT 2006 OR A RECENT VERSION THEREOF, OF ALL APPURTENANCES AND SURVEY REFERENCE POINTS TO ACCEPTABLE LOCATIONS. MINIMAL REQUIREMENT OF 2 POINTS FOR MINOR AND 3 POINTS FOR MAJOR APPURTANCES.

21. MAINTAIN WATER AND SEWER LINE SEPARATION IN ACCORDANCE WITH REGULATIONS.

22. INSTALL DETECTABLE WARNING TAPE AND CONDUCTOR TAPE ON TOP OF ALL PIPE.

23. ALL REBARS SHOULD BE EPOXY COATED. UNLESS DIRECTED BY ENGINEER

24. CONSTRUCT SWALES AS SHOWN IN DETAILS WHENEVER SLOPE EXCEEDS 8%.

No. Description Date			REV. NO.:		DESIGNED BY: F.Toala	
			REVISION:		CHECKED BY: L.Tyrell	
			CHECKED BY:		APPROVED BY: F.Aquila / L.Tyrell	
			APPROVED BY:		ISSUE FOR: Construction	
			DATE:			

ASPA

AMERICAN SAMOA POWER AUTHORITY

AMERICAN SAMOA POWER AUTHORITY

ENGINEERING SERVICES DIVISION

P.O.BOX PPB, TAFUNA, PAGO PAGO, AS 96799

PROJECT NAME: PHASE 3 VAITOGI HDPE PIPE REPLACEMENT WATERLINE PROJECT		PROJECT NO: #1958785	SCALE: SCALE TO FIT
DRAWING TITLE: LEGEND UTILITY GENERAL NOTES		SIGNATURE:	DATE: JAN-2024
PROJECT LOCATION: VAITOGI VILLAGE, AMERICAN SAMOA		DATE:	SHEET NO. G3

CONSTRUCTION NOTES:

1. THE CONTRACTOR SHALL COORDINATE HIS HAUL ROUTE STAGING AREA AND ALL ASSOCIATED REQUIREMENTS, SUCH AS, LAND USE PERMIT, WITH THE PNRS, CONTRACTING OFFICER, AND AFFECTED LANDOWNER.

2. A SEPARATE LAND USE PERMIT MUST BE OBTAINED BY THE CONTRACTOR IF THE CONTRACTOR'S STAGING AREA OR ANY WORK IS OUTSIDE THE LIMITS OF THE CONTRACT. THE EXISTING LAND USE PERMIT IS CONDITIONED ON A DIVISION OF MARINE AND WILDLIFE RESOURCES REVIEW PRIOR TO CONSTRUCTION.

3. THE CONTRACTOR SHALL BE RESPONSIBLE FOR THE CLEARING AND REMOVAL OF ALL SILT AND DEBRIS GENERATED BY HIS GRADING AND CONSTRUCTION WORK AND DEPOSITED AND ACCUMULATED ON ROADWAYS AND OTHER AREAS.

4. ALL EXISTING UTILITIES, CONCRETE WALKWAYS, STEPS AND WALLS, WHETHER OR NOT SHOWN ON THE DRAWINGS, EXCEPT THOSE DESIGNATED TO BE REMOVED, SHALL BE PROTECTED FROM DAMAGED AT ALL TIMES DURING CONSTRUCTION AND GRADING WORK. ANY DAMAGES TO THEM SHALL BE REPAIRED BY THE CONTRACTOR AT HIS EXPENSE.

5. THE CONTRACTOR SHALL VERIFY DIMENSIONS, LOCATIONS, ELEVATIONS, ETC. THAT ARE INDICATED FOR VERIFICATION AND INFORM THE CONTRACTING OFFICER IN WRITING OF ANY DIFFERENCES PRIOR TO INSTALLATION OF NEW FACILITIES.

6. THE CONTRACTOR SHALL TONE AND PROBE THE AREA PRIOR TO ALL EXCAVATION AND TRENCHING TO VERIFY THE LOCATION OF ALL EXISTING UTILITIES AND SHALL BE RESPONSIBLE FOR REPAIR OR REPLACEMENT OF SAME IN THE EVENT OF DAMAGES DUE TO CONTRACTORS CONSTRUCTION PRACTICES. WHENEVER CONNECTIONS OF NEW UTILITIES TO EXISTING UTILITIES ARE SHOWN ON THE PLANS, THE CONTRACTOR SHALL EXPOSE THE EXISTING LINES AT THE PROPOSED CONNECTIONS TO VERIFY THEIR LOCATIONS, DEPTHS AND ASSURE THAT CONNECTIONS CAN BE MADE PRIOR TO EXCAVATION FOR THE NEW LINES AT NO COST TO THE OWNER. ANY NECESSARY ADJUSTMENTS FOR THE NEW LINES TO ENSURE PROPER CONNECTIONS TO THE EXISTING SHALL BE THE CONTRACTOR'S RESPONSIBILITY. THE CONTRACTOR SHALL ALSO CONTACT ASPA, BLUESKY AND ASTCA TO PROPERLY LOCATE THE UNDERGROUND UTILITIES AND CABLES THAT LIE IN AND ADJACENT TO THE WORK AREA.

7. WORK SHALL BE DONE BETWEEN 7:30AM AND 4:00PM SAMOA STANDARD
- TIME. NO WORK SHALL BE DONE ON SATURDAYS, SUNDAYS, FEDERAL HOLIDAYS OR AFTER NORMAL WORK HOURS AT ANY TIME, WITHOUT SPECIAL ARRANGEMENT AND PRIOR APPROVAL BY THE CONTRACTING OFFICER. PROJECT WORK SHALL BE IN CONFORMANCE WITH APPLICABLE FEDERAL AND LOCAL LAWS AND REGULATIONS REGARDING COMMUNITY NOISE CONTROL.

8. THE CONTRACTOR SHALL BE RESPONSIBLE FOR THE PROTECTION OF ALL WATERLINES DURING CONSTRUCTION. THE CONTRACTOR SHALL BE ESPECIALLY CAREFUL WHEN EXCAVATING BEHIND WATERLINE TEES AND BENDS WHEREVER THERE IS POSSIBILITY OF WATERLINE MOVEMENT DUE TO REMOVAL OF THE SUPPORTING EARTH BEYOND THE EXISTING REACTION BLOCKS. THE CONTRACTOR SHALL TAKE WHATEVER MEASURE TO PROTECT THE WATERLINE SUCH AS CONSTRUCTING SPECIAL REACTION BLOCKS AND/OR MODIFYING HIS CONSTRUCTION METHODS.

9. NO BLASTING WILL BE ALLOWED ON THIS PROJECT.

10. THE CONTRACTOR SHALL PROTECT EXISTING PUBLIC AND PRIVATE FACILITIES AND UTILITIES, AND PROVIDE SHORING DURING EXCAVATION. THE CONTRACTOR SHALL REPAIR, AT HIS COST, ALL DAMAGES DUE TO EXCAVATION.

11. THE CONTRACTOR SHALL COORDINATE WITH ASPA, ASC, BLUESKY COMMUNICATIONS AND ASTCA FOR ALL NEW POLE INSTALLATION, POWER, TELEVISION AND COMMUNICATIONS RELOCATIONS, AND REMOVAL OF EXISTING POLES. IF THE CONTRACTOR SHALL PROVIDE RELOCATIONS, REMOVAL OF EXISTING POLES. THE CONTRACTOR SHALL PROVIDE SUPPORTS FOR THE EXISTING POLES AFFECTED BY EXCAVATION. THE CONTRACTOR SHALL NOTIFY AFFECTED VILLAGES AND THE UTILITY COMPANIES SEVEN (7) DAYS PRIOR TO SERVICE INTERRUPTIONS. THESE NOTIFICATIONS SHALL BE AT THE CONVENIENCE OF ASPA, ASC, BLUESKY COMMUNICATION AND ASTCA.

12. THE CONTRACTOR SHALL PROVIDE ALL LAND SURVEY CONSTRUCTION STAKEOUT SERVICES, SOIL AGGREGATE, CONCRETE AND PAVEMENT MONITORING, AND SAMPLING AND TESTING SERVICES.

13. WASTE MATERIAL WILL BE DISPOSED OF AT AN APPROVED, PNRS-COMPLIANT, OFF-SITE DISPOSAL AREA. THE CONTRACTOR SHALL BE RESPONSIBLE FOR OBTAINING DISPOSAL AREA.

14. THE CONTRACTOR SHALL TAKE EXTREME CARE IN PERFORMING WORK NEAR EXISTING CONCRETE ELECTRICAL/COMMUNICATION DUCTS.
- APPROPRIATE PROTECTION SHALL BE IMPLEMENTED AS REQUIRED TO PREVENT DAMAGE TO THIS LINE.

15. THE CONTRACTOR SHALL VERIFY, BASED ON THE SITE CONDITIONS AND CONTRACT BASELINE DATA, WITH OVERVIEW AND APPROVAL BY AN AUTHORIZED REPRESENTATIVE OF AMERICAN SAMOA POWER AUTHORITY, THE LOCATION OF ALL EXISTING POLES WHICH IMPACT THE CONSTRUCTION AND ULTIMATE USE OF THE PROPOSED ROAD.

16. THE CONTRACTOR SHALL VERIFY, BASED ON OVERVIEW AND APPROVAL BY AUTHORIZED REPRESENTATIVE OF AMERICAN SAMOA GOVERNMENT OFFICE OF COMMUNICATIONS, THE LOCATIONS AND DEPTH OF EXISTING UNDERGROUND TELEPHONE CABLES. RELOCATE EXISTING DIRECT BURIED CABLES WHICH IMPACT THE CONSTRUCTION AND FINAL USE OF THE PROPOSED ROAD. EITHER INTO A NEW TRENCH AWAY FROM THE ROAD OR IN PVC SCHEDULE80 SLEEVES THROUGH THE ROAD AT A MINIMUM DEPTH OF 3' BELOW FINISHED GRADE IF THE CABLES CANNOT BE RELOCATED. TO EXPOSE THE CABLE, THE CONTRACTOR SHALL TONE FOR THE CABLE AND HAND EXCAVATE THE CABLE TAKING CARE NOT TO DAMAGE THE JACKET AND INSULATION. BASIS OF BID SHALL BE 100 LINEAR FEET OF DIRECT BURIED CABLE.



17. THE CONTRACTOR SHALL REMOVE ALL EXISTING PAVEMENT AND CROSSING ALONG THE NEW ROADWAY. ALL DEMOLITION AND REMOVAL OF EXISTING PAVEMENT SHALL BE CONSIDERED INCIDENTAL TO ROADWAY CONSTRUCTION.

18. ALL TRAFFIC SIGN AND PAVEMENT MARKERS SHALL BE IN ACCORDANCE WITH THE MANUAL ON UNIFORM TRAFFIC CONTROL DEVICES (MUTCD) 2003 EDITION, AND ALL SUBSEQUENT AMENDMENTS AND ADDITIONS.

19. AT THE END OF THE WORKDAY OR AS SOON AS WORK IS COMPLETED, THE CONTRACTOR SHALL TAKE NECESSARY MEASURES TO ENSURE THAT PUBLIC TRAFFIC HAS SAFE PASSAGE AND THAT ALL OPEN HOLES ARE PROPERLY COVERED AND MAINTAINED DURING THE DURATION OF THE PROJECT.

20. IF THE CONTRACTOR UNCOVERS ANY CULTURAL REMAINS, DURING EXCAVATION WORK, THE CONTRACTOR SHALL STOP WORK IN THE AREA OF THE FINDINGS AND NOTIFY THE CONTRACTING OFFICER AND THE AMERICAN SAMOA GOVERNMENT (ASHPO AND ASPA)

No.	Description	Date	REV. NO.:	DESIGNED BY:	ASPA AMERICAN SAMOA POWER AUTHORITY ENGINEERING SERVICES DIVISION P.O.BOX PPB, TAFUNA, PAGO PAGO, AS 96799	PROJECT NAME:	PROJECT NO:	SCALE:
			REVISION:	CHECKED BY:		PHASE 3	#1958785	SCALE TO FIT
			CHECKED BY:	APPROVED BY:		VAITOGI HDPE PIPE REPLACEMENT	SIGNATURE:	DATE:
			APPROVED BY:	ISSUE FOR:		WATERLINE PROJECT		JAN-2024
			DATE:			CONSTRUCTION NOTES	DATE:	SHEET NO.
						PROJECT LOCATION:		G4
						VAITOGI VILLAGE, AMERICAN SAMOA		

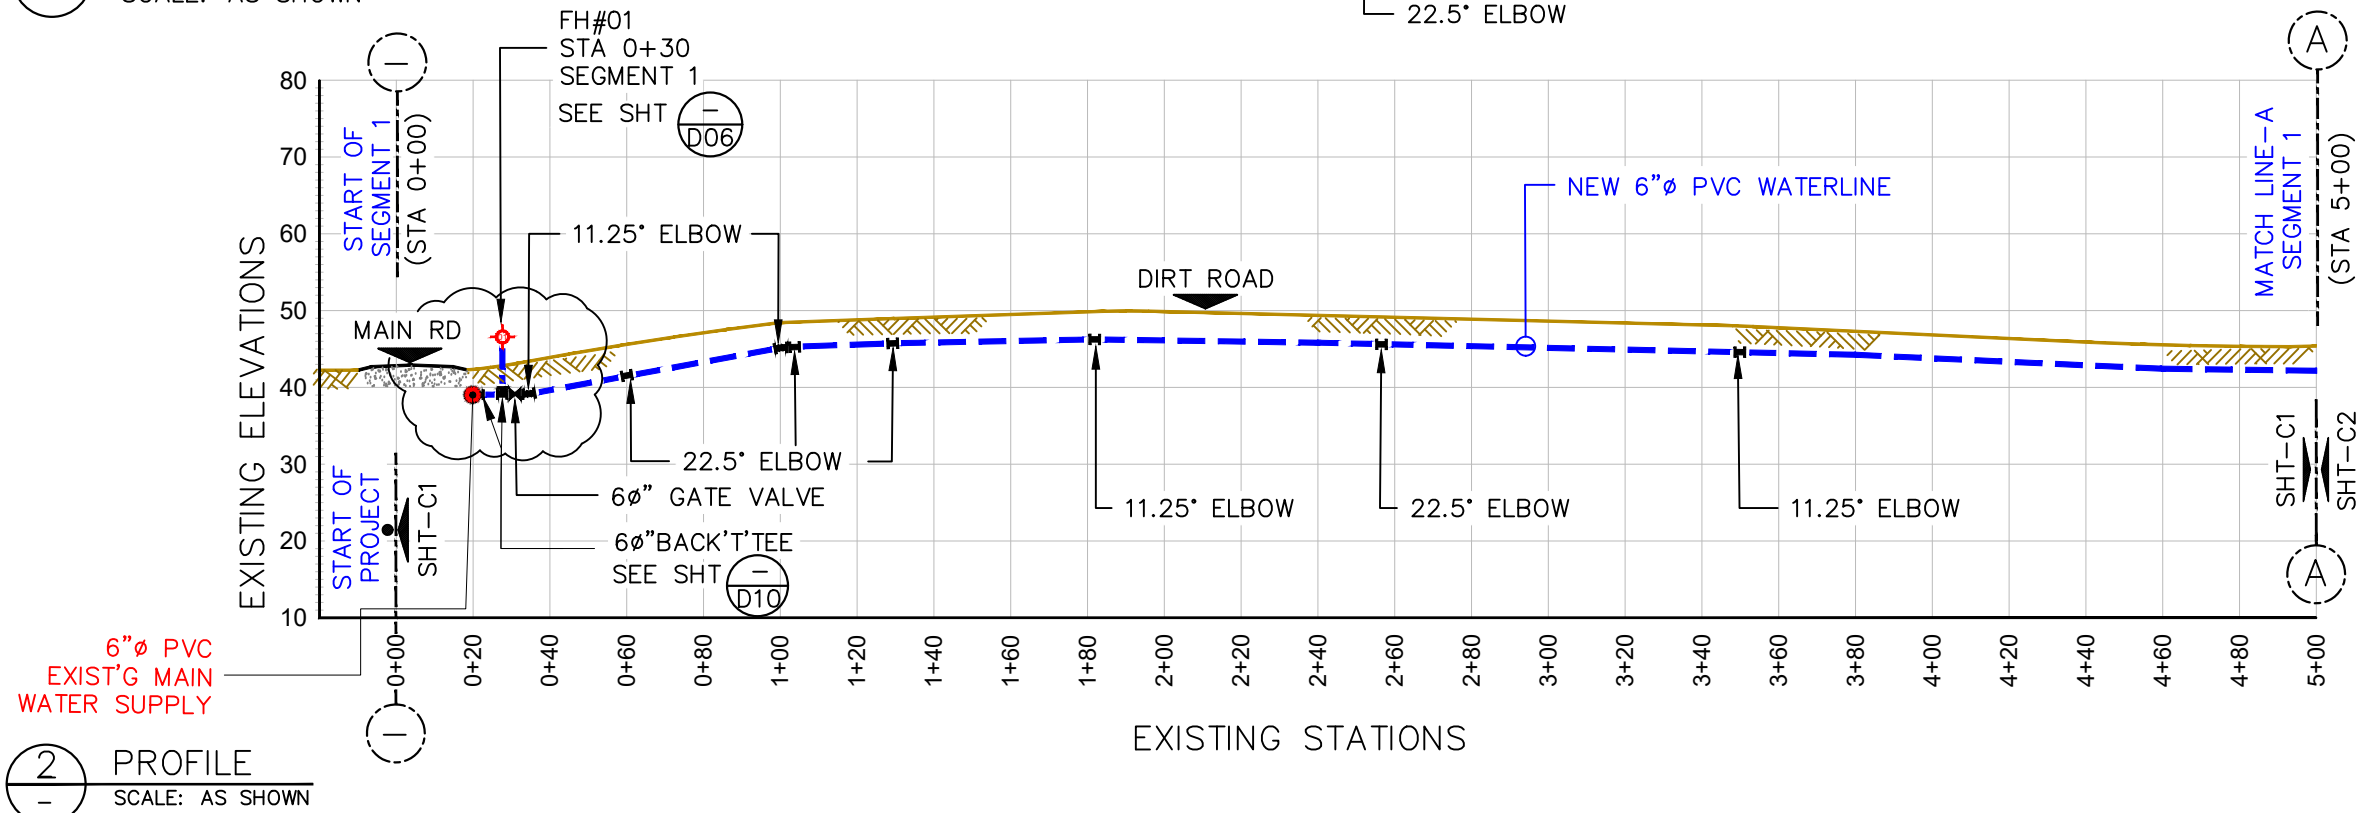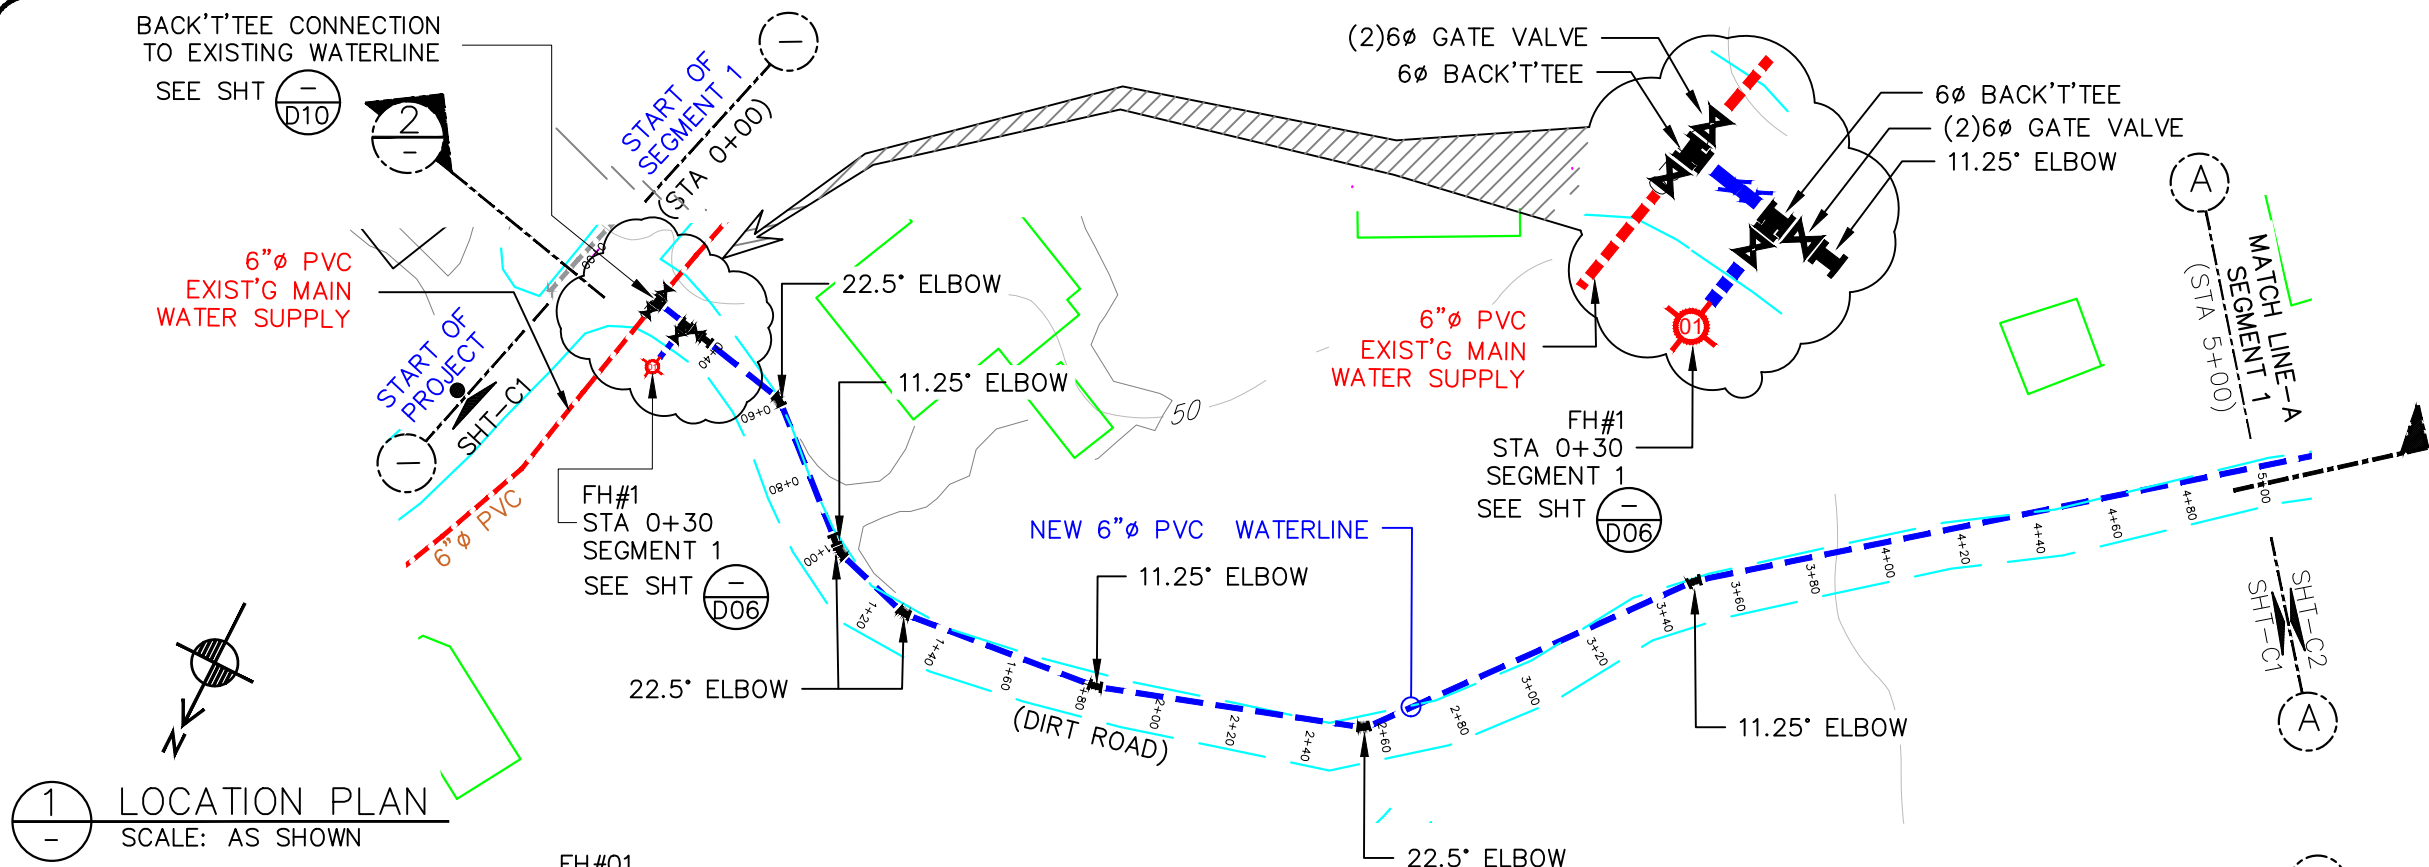


LEGEND:

EXISTING WATER SERVICE:	
EXISTING ACP WATER:	---
NEW 6" PVC WATER:	---
TELEPHONE CONDUIT:	---
EXISTING STORM DRAIN:	---
EXISTING SEWER MAIN:	---
GATE VALVE:	⊗
POWER/TEL POLE:	⊗
AIR RELIEVE VALVE:	⊗
ELBOWS:	11.25° 22.5° 45° 90° BACK TEE
FIRE HYDRANT:	⊗
BAC-T SAMPLING STN:	⊗
SERVICE METER:	---
STUB-OUT:	---
PRV / PSV :	---
EXISTING SERVICE LINE TRANSFERRED TO NEW LINE:	---
TREES:	⊗
HEDGES:	⊗
ROCK WALL:	---
WIRE FENCE:	---

NOTES:
CONSTRUCTION CONTRACTOR SHALL FIELD VERIFY ALL EXISTING UNDERGROUND INFRASTRUCTURE TO ENSURE SAFETY OF ITS WORKERS AND AVOID ANY DAMAGES TO EXISTING GOVERNMENT UTILITIES.

ALL EXISTING FIRE HYDRANT TO BE TRANSFERRED TO NEW LINE.
SEE SHT-DO6 FOR FIRE HYDRANT CONNECTION DETAILS.

INSTALL 2"Øx6"Ø SADDLE FOR NEW SERVICE CONNECTION @ EVERY 500 FEET

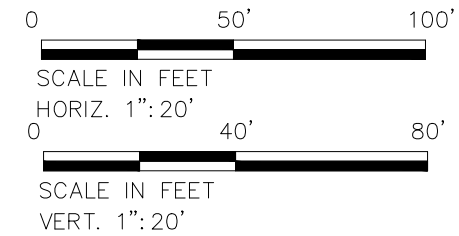

No.	Description	Date

REV. NO.:	
REVISION:	
CHECKED BY:	
APPROVED BY:	
DATE:	


PREPARED BY:	F.Toala
CHECKED BY:	L.Tyrell
APPROVED BY:	F.Aquila, L.Tyrell
ISSUE FOR:	Construction




AMERICAN SAMOA POWER AUTHORITY
ENGINEERING SERVICES DIVISION
P.O.BOX PPB, TAFUNA, PAGO PAGO, AS 96799

PROJECT NAME:	VAITOGI ACP WATERLINE REPLACEMENT
DRAWING TITLE:	SEGMENT 1 START PLAN & PROFILE (STA, 0+00 TO 5+00)
PROJECT LOCATION:	VAITOGI VILLAGE, AMERICAN SAMOA

SCALE:	AS SHOWN	PROJECT NO:	
DATE:	SEP-2022	SIGNATURE:	
SHEET NO.	C01	DATE:	

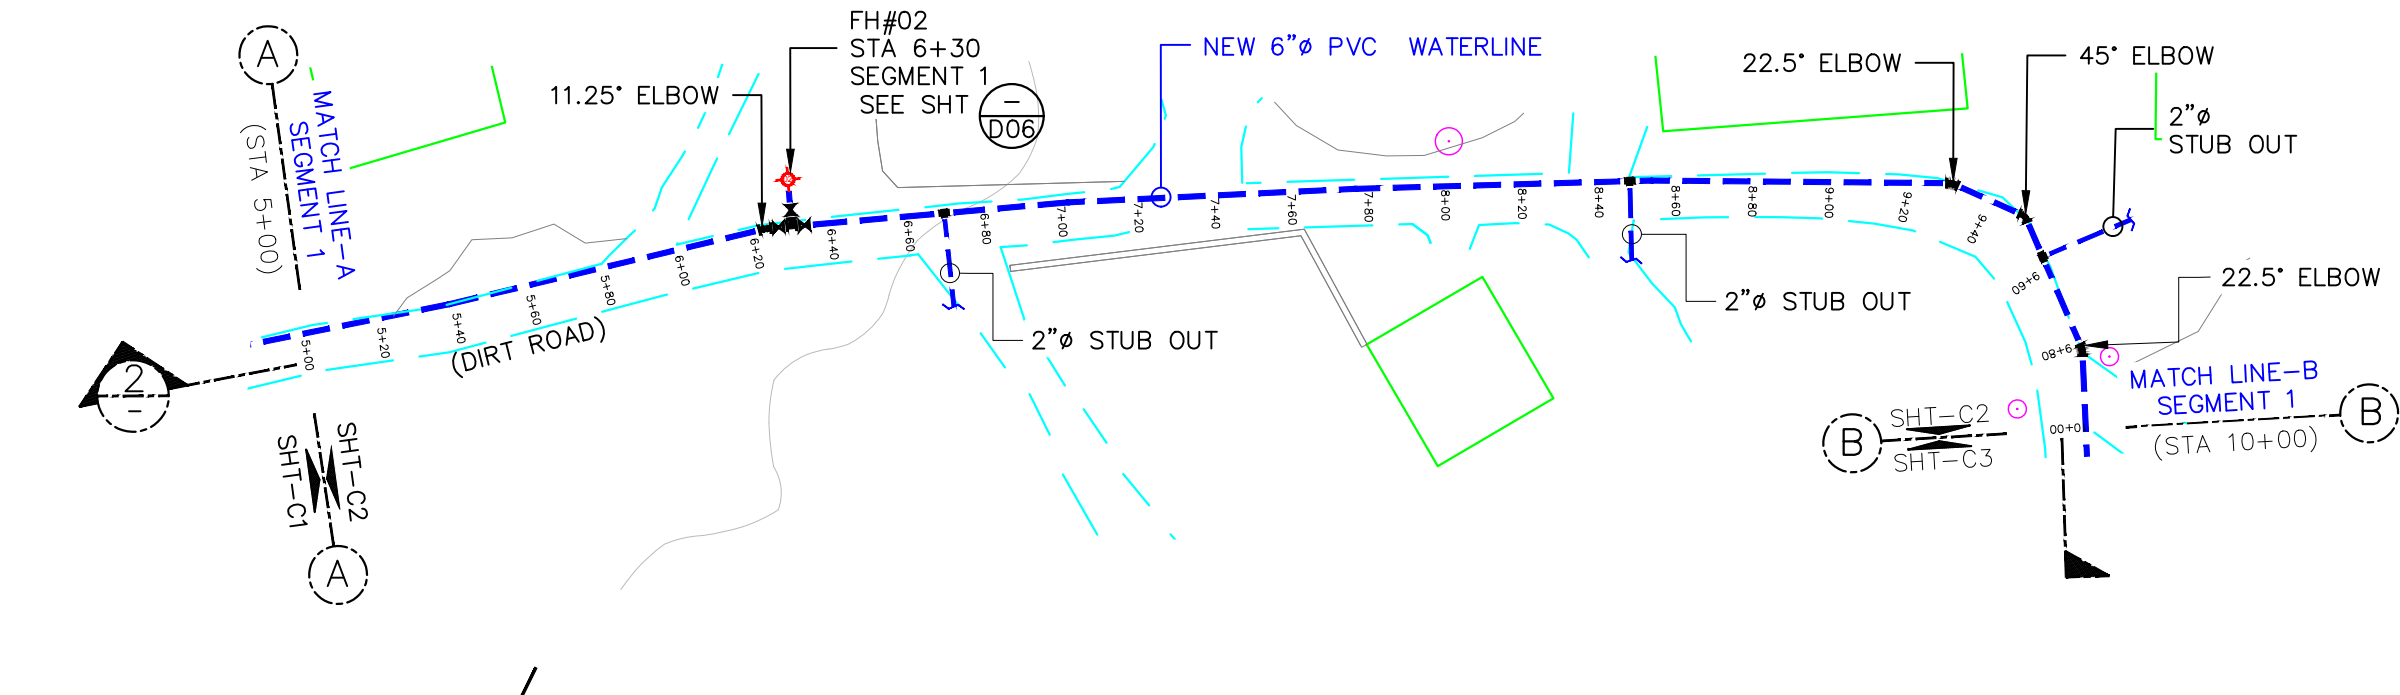

1 LOCATION PLAN
SCALE: AS SHOWN

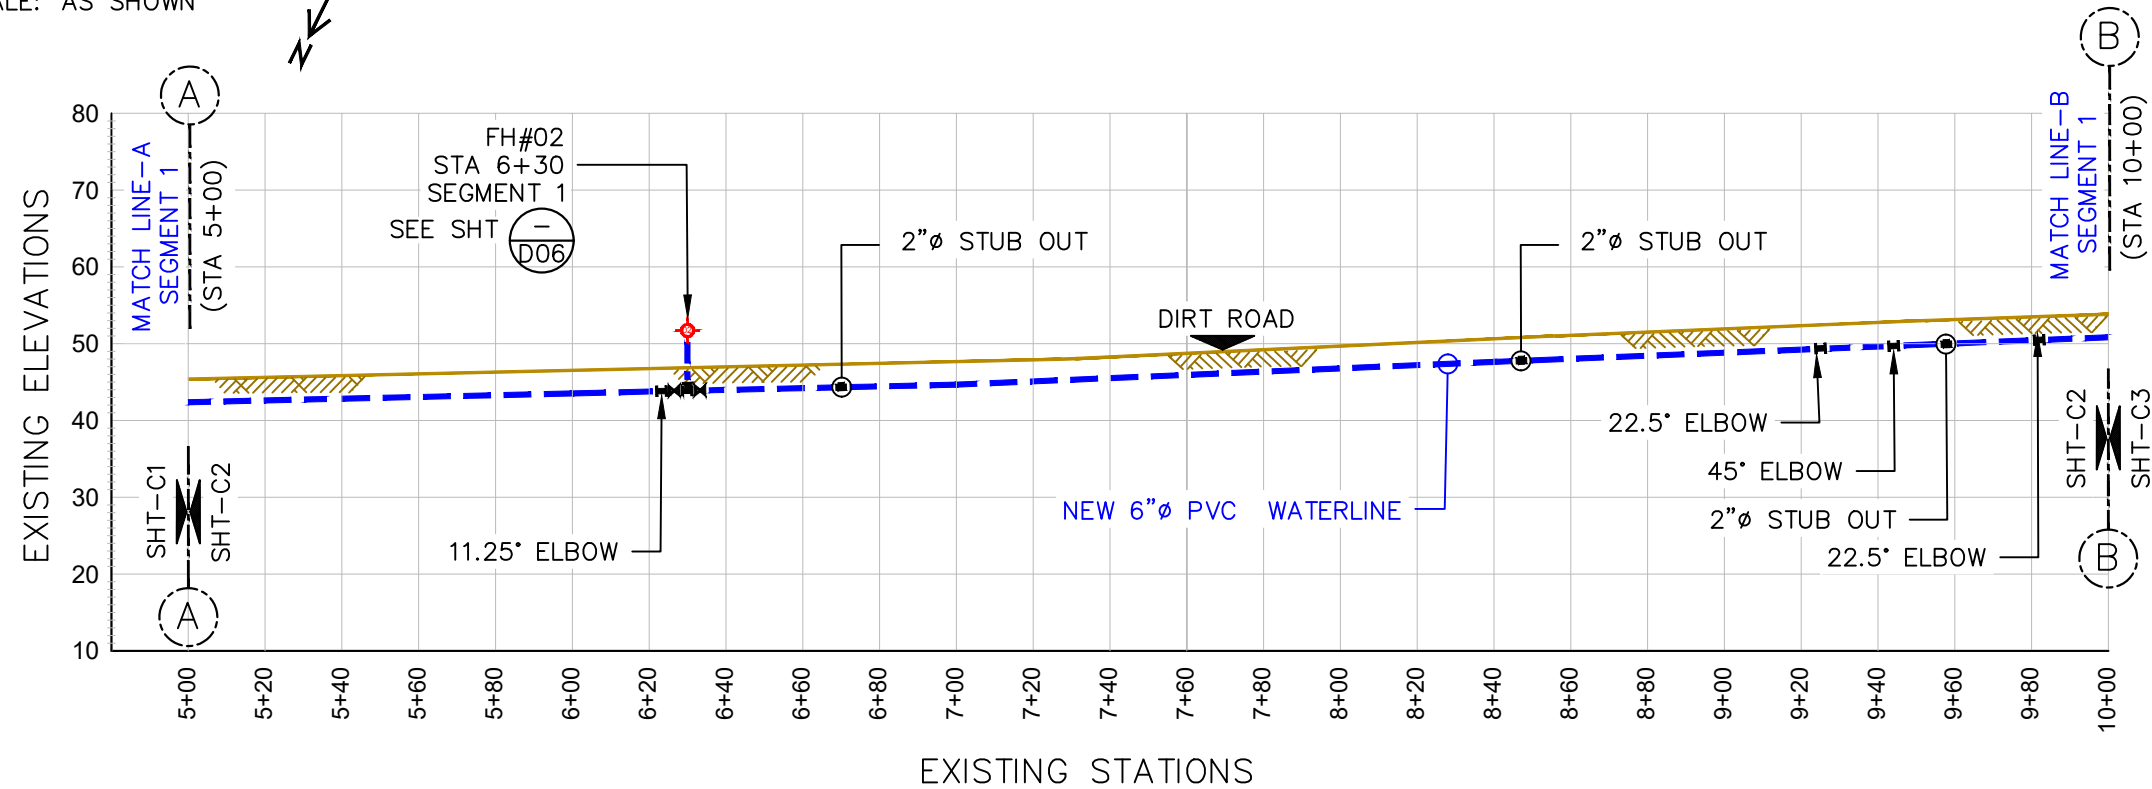


2 PROFILE
SCALE: AS SHOWN

LEGEND:	
EXISTING WATER SERVICE:	
EXISTING ACP WATER:	
NEW 6" PVC WATER:	
TELEPHONE CONDUIT:	
EXISTING STORM DRAIN:	
EXISTING SEWER MAIN:	
GATE VALVE:	
POWER/TEL POLE:	
AIR RELIEVE VALVE:	
ELBOWS:	11.25° 22.5° 45° 90°
FIRE HYDRANT:	
BAC-T SAMPLING STN:	
SERVICE METER:	
STUB-OUT:	
PRV / PSV :	
EXISTING SERVICE LINE TRANSFERRED TO NEW LINE:	
TREES:	
HEDGES:	
ROCK WALL:	
WIRE FENCE:	

NOTES:
CONSTRUCTION CONTRACTOR SHALL
FIELD VERIFY ALL EXISTING
UNDERGROUND INFRASTRUCTURE TO
ENSURE SAFETY OF ITS WORKERS AND
AVOID ANY DAMAGES TO EXISTING
GOVERNMENT UTILITIES.

ALL EXISTING FIRE HYDRANT TO BE
TRANSFERRED TO NEW LINE.
SEE SHT-DO6 FOR FIRE HYDRANT
CONNECTION DETAILS.

INSTALL 2"Øx6"Ø SADDLE FOR NEW SERVICE
CONNECTION @ EVERY 500 FEET

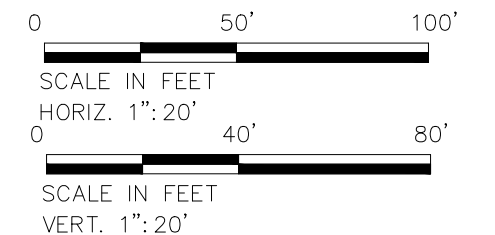

No.	Description	Date

REV. NO.:	
REVISION:	
CHECKED BY:	
APPROVED BY:	
DATE:	

PREPARED BY:	F.Toala
CHECKED BY:	L.Tyrell
APPROVED BY:	F.Aquila, L.Tyrell
ISSUE FOR:	Construction




AMERICAN SAMOA POWER AUTHORITY
ENGINEERING SERVICES DIVISION
P.O.BOX PPB, TAFUNA, PAGO PAGO, AS 96799


PROJECT NAME:	VAITOGI ACP WATERLINE REPLACEMENT
DRAWING TITLE:	SEGMENT 1 PLAN & PROFILE (STA, 5+00 TO 10+00)
PROJECT LOCATION:	VAITOGI VILLAGE, AMERICAN SAMOA

SCALE:	AS SHOWN
DATE:	SEP-2022
SHEET NO.	C02

PROJECT NO:	
SIGNATURE:	
DATE:	

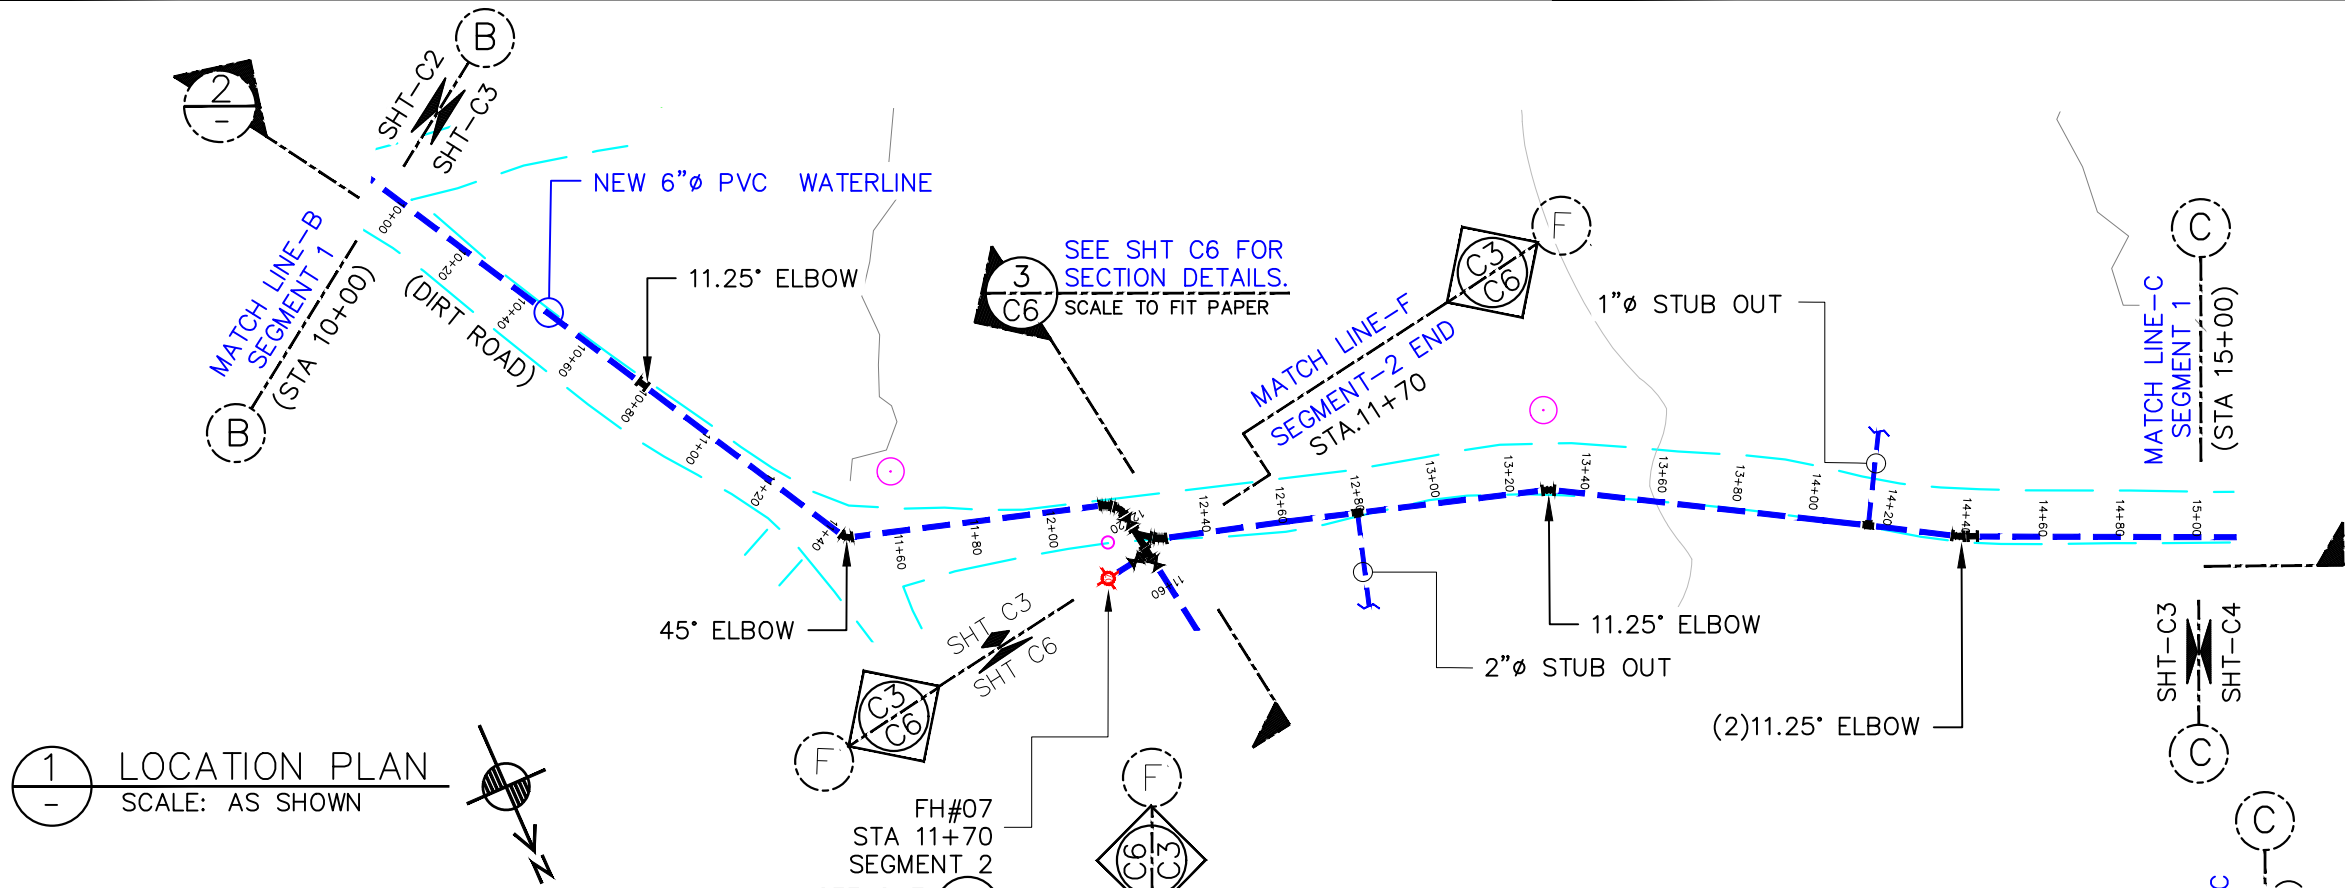

1 LOCATION PLAN
SCALE: AS SHOWN

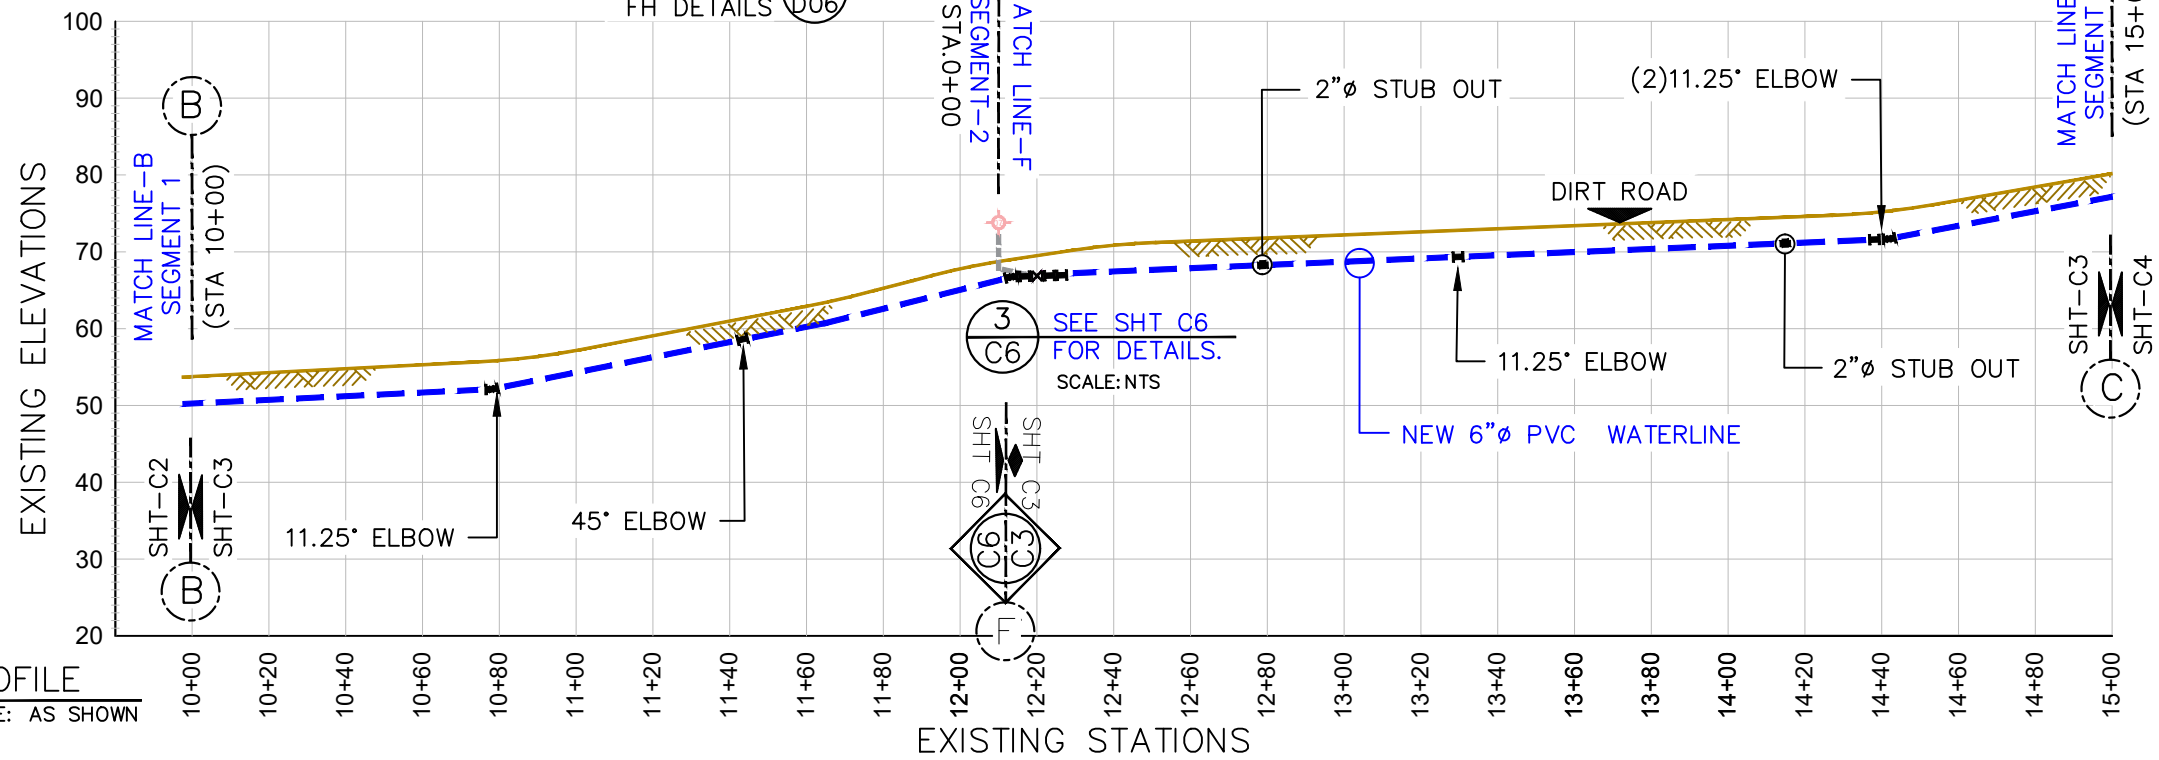


2 PROFILE
SCALE: AS SHOWN

LEGEND:	
EXISTING WATER SERVICE:	
EXISTING ACP WATER:	
NEW 6" PVC WATER:	
TELEPHONE CONDUIT:	
EXISTING STORM DRAIN:	
EXISTING SEWER MAIN:	
GATE VALVE:	
POWER/TEL POLE:	
AIR RELIEVE VALVE:	
ELBOWS:	11.25° 45° 90° BACK TEE
FIRE HYDRANT:	
BAC-T SAMPLING STN:	
SERVICE METER:	
STUB-OUT:	
PRV / PSV :	
EXISTING SERVICE LINE TRANSFERRED TO NEW LINE:	
TREES:	
HEDGES:	
ROCK WALL:	
WIRE FENCE:	

NOTES:
CONSTRUCTION CONTRACTOR SHALL FIELD VERIFY ALL EXISTING UNDERGROUND INFRASTRUCTURE TO ENSURE SAFETY OF ITS WORKERS AND AVOID ANY DAMAGES TO EXISTING GOVERNMENT UTILITIES.

ALL EXISTING FIRE HYDRANT TO BE TRANSFERRED TO NEW LINE.
SEE SHT-DO6 FOR FIRE HYDRANT CONNECTION DETAILS.

INSTALL 2"x6" SADDLE FOR NEW SERVICE CONNECTION @ EVERY 500 FEET

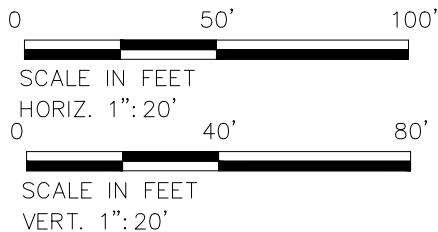

No.	Description	Date

REV. NO.:	
REVISION:	
CHECKED BY:	
APPROVED BY:	
DATE:	

PREPARED BY:	F.Toala
CHECKED BY:	L.Tyrell
APPROVED BY:	F.Aquila, L.Tyrell
ISSUE FOR:	Construction




AMERICAN SAMOA POWER AUTHORITY
ENGINEERING SERVICES DIVISION
P.O.BOX PPB, TAFUNA, PAGO PAGO, AS 96799


PROJECT NAME:	VAITOGI ACP WATERLINE REPLACEMENT
DRAWING TITLE:	SEGMENT 1 PLAN & PROFILE (STA, 10+00 TO 15+00)
PROJECT LOCATION:	VAITOGI VILLAGE, AMERICAN SAMOA

SCALE:	AS SHOWN
DATE:	SEP-2022
SHEET NO.	C03

PROJECT NO:	
SIGNATURE:	
DATE:	

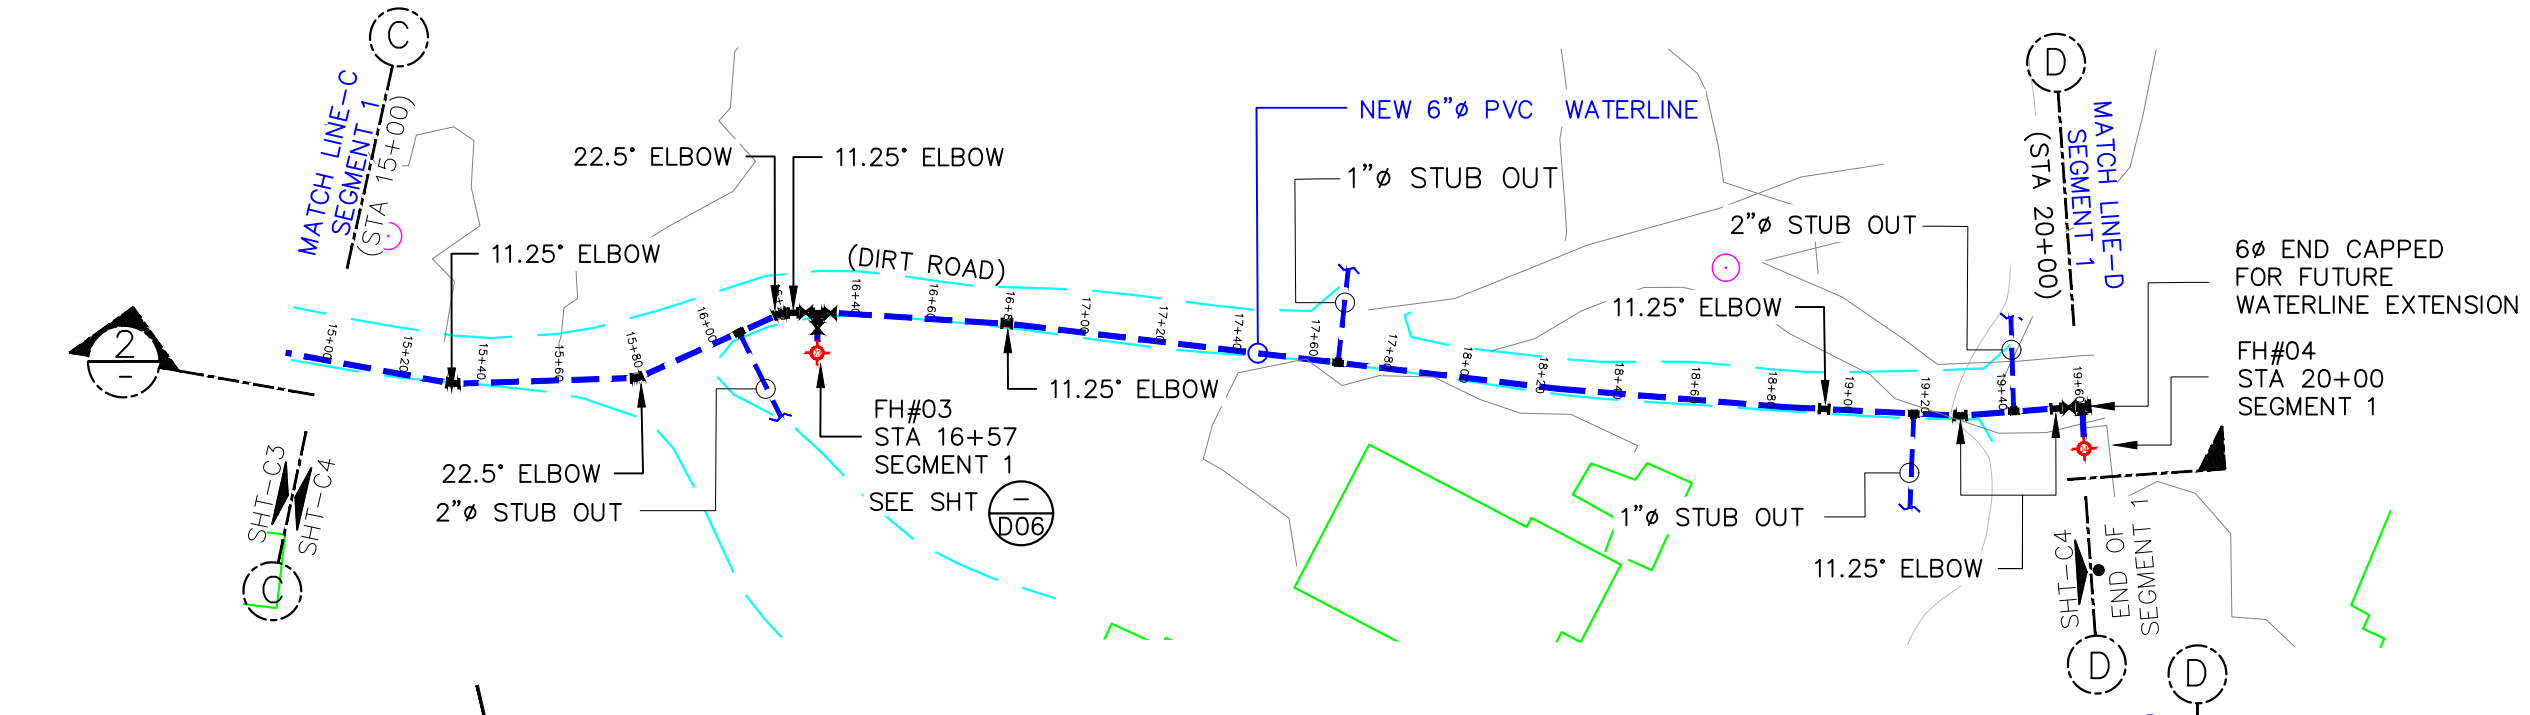

1 LOCATION PLAN
SCALE: AS SHOWN

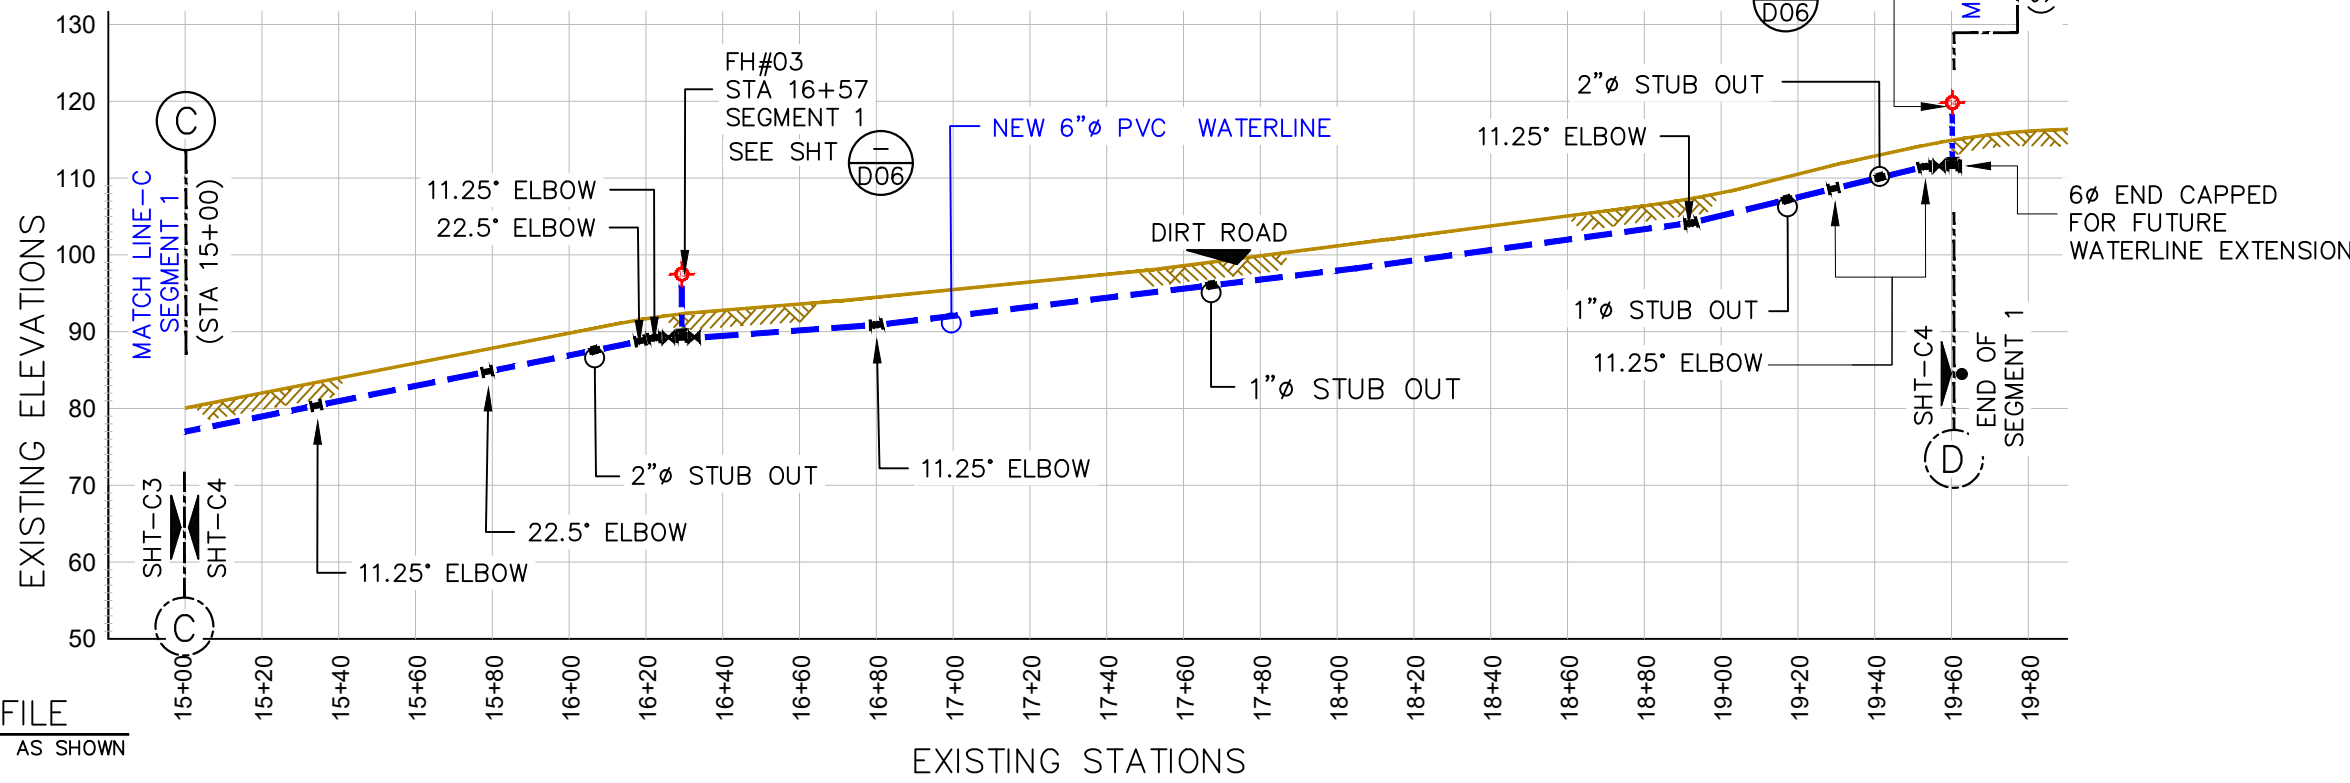


2 PROFILE
SCALE: AS SHOWN

LEGEND:	
EXISTING WATER SERVICE:	
EXISTING ACP WATER:	
NEW 6" PVC WATER:	
TELEPHONE CONDUIT:	
EXISTING STORM DRAIN:	
EXISTING SEWER MAIN:	
GATE VALVE:	
POWER/TEL POLE:	
AIR RELIEVE VALVE:	
ELBOWS:	
11.25°	
22.5°	
45°	
90°	
BACK TEE	
FIRE HYDRANT:	
BAC-T SAMPLING STN:	
SERVICE METER:	
STUB-OUT:	
PRV / PSV :	
EXISTING SERVICE LINE TRANSFERRED TO NEW LINE:	
TREES:	
HEDGES:	
ROCK WALL:	
WIRE FENCE:	

NOTES:
CONSTRUCTION CONTRACTOR SHALL FIELD VERIFY ALL EXISTING UNDERGROUND INFRASTRUCTURE TO ENSURE SAFETY OF ITS WORKERS AND AVOID ANY DAMAGES TO EXISTING GOVERNMENT UTILITIES.

ALL EXISTING FIRE HYDRANT TO BE TRANSFERRED TO NEW LINE.
SEE SHT-DO6 FOR FIRE HYDRANT CONNECTION DETAILS.

INSTALL 2"x6" SADDLE FOR NEW SERVICE CONNECTION @ EVERY 500 FEET

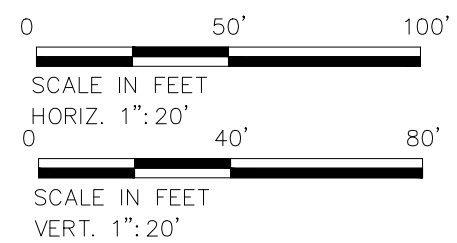

No.	Description	Date


REV. NO.:	PREPARED BY:
	F.Toala
REVISION:	CHECKED BY:
	L.Tyrell
CHECKED BY:	APPROVED BY:
	F.Aquila, L.Tyrell
APPROVED BY:	ISSUE FOR:
	Construction
DATE:	



AMERICAN SAMOA POWER AUTHORITY
ENGINEERING SERVICES DIVISION
P.O.BOX PPB, TAFUNA, PAGO PAGO, AS 96799


PROJECT NAME:	VAITOGI ACP WATERLINE REPLACEMENT
DRAWING TITLE:	SEGMENT 1 PLAN & PROFILE (STA, 15+00 TO 20+00)
PROJECT LOCATION:	VAITOGI VILLAGE, AMERICAN SAMOA

SCALE:	PROJECT NO:
AS SHOWN	
DATE:	SIGNATURE:
SEP-2022	
SHEET NO.	DATE:
C04	

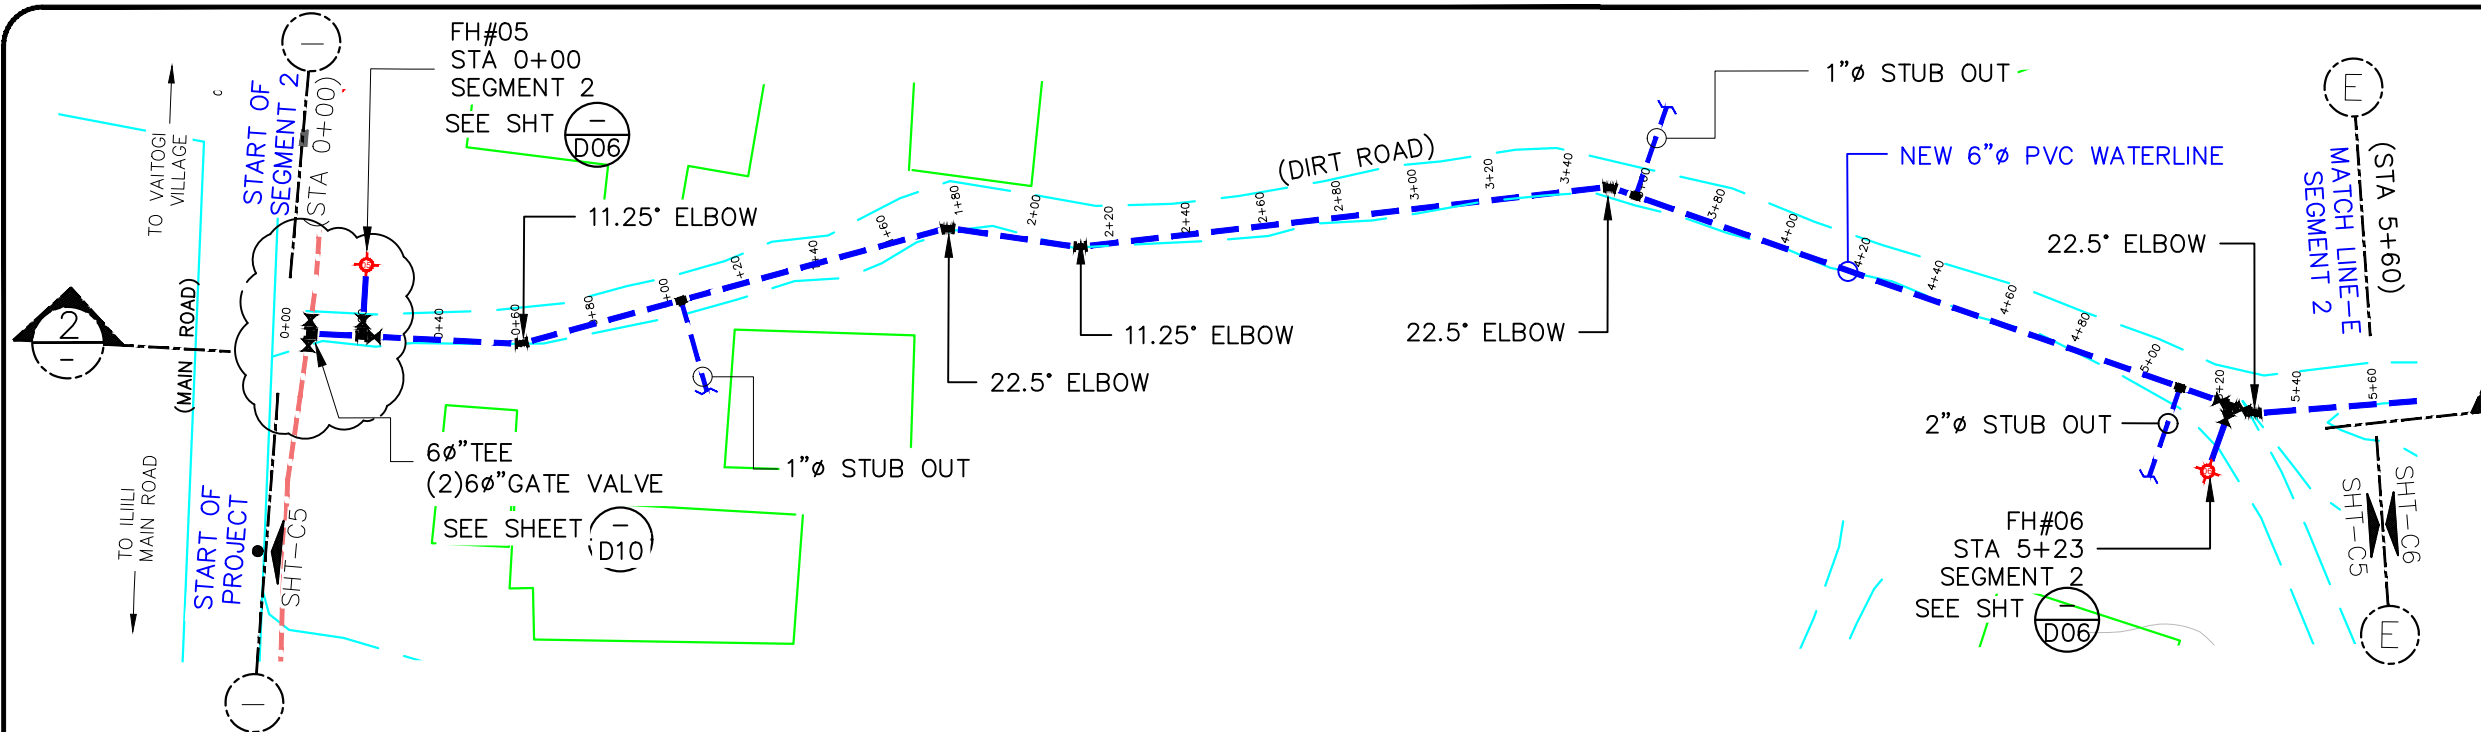

1 LOCATION PLAN
SCALE: AS SHOWN

4 CONNECTION DETAILS
SCALE: NTS

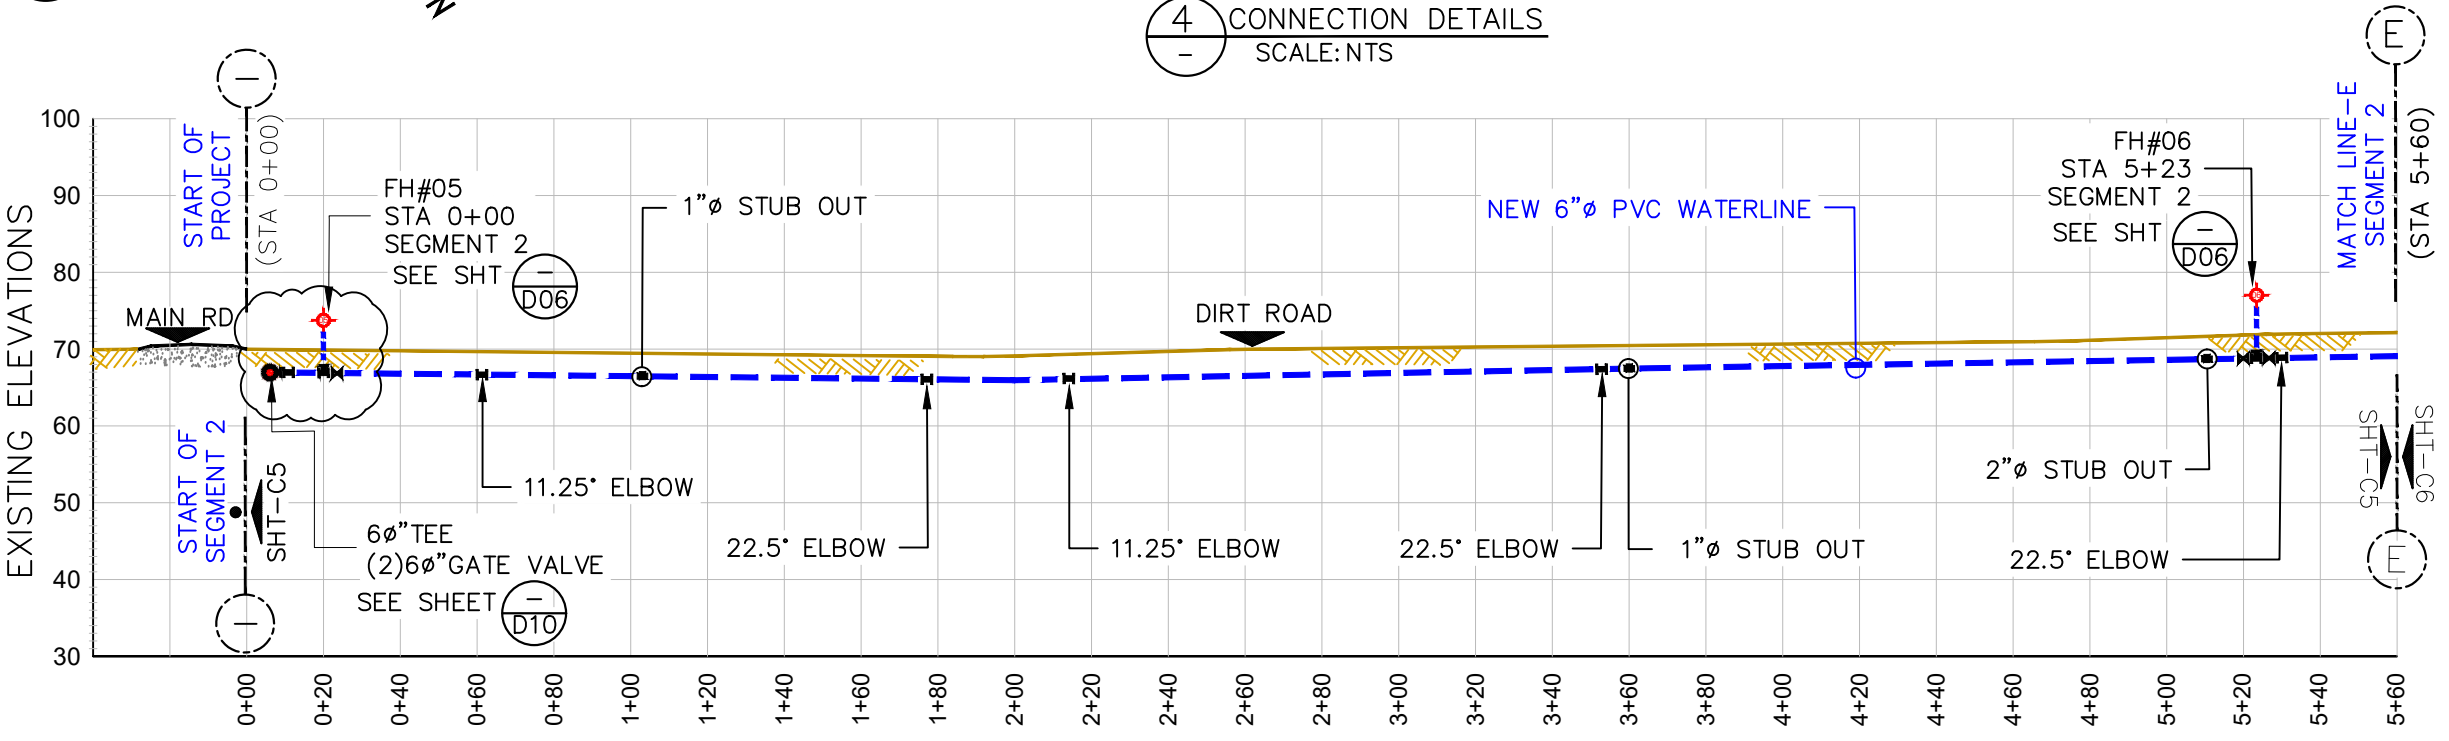


2 PROFILE
SCALE: AS SHOWN

LEGEND:	
EXISTING WATER SERVICE:	
EXISTING ACP WATER:	
NEW 6" PVC WATER:	
TELEPHONE CONDUIT:	
EXISTING STORM DRAIN:	
EXISTING SEWER MAIN:	
GATE VALVE:	
POWER/TEL POLE:	
AIR RELIEVE VALVE:	
ELBOWS:	
11.25°	
22.5°	
45°	
90°	
BACK TEE	
FIRE HYDRANT:	
BAC-T SAMPLING STN:	
SERVICE METER:	
STUB-OUT:	
PRV / PSV :	
EXISTING SERVICE LINE TRANSFERRED TO NEW LINE:	
TREES:	
HEDGES:	
ROCK WALL:	
WIRE FENCE:	

NOTES:
CONSTRUCTION CONTRACTOR SHALL FIELD VERIFY ALL EXISTING UNDERGROUND INFRASTRUCTURE TO ENSURE SAFETY OF ITS WORKERS AND AVOID ANY DAMAGES TO EXISTING GOVERNMENT UTILITIES.

ALL EXISTING FIRE HYDRANT TO BE TRANSFERRED TO NEW LINE.
SEE SHT-DO6 FOR FIRE HYDRANT CONNECTION DETAILS.

INSTALL 2"x6" SADDLE FOR NEW SERVICE CONNECTION @ EVERY 500 FEET

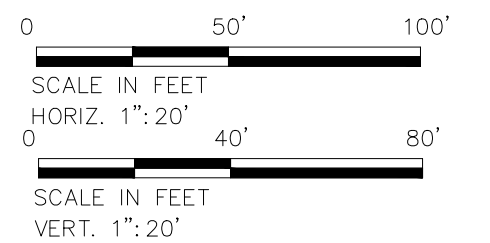

No.	Description	Date

REV. NO.:	
REVISION:	
CHECKED BY:	
APPROVED BY:	
DATE:	

PREPARED BY:	F.Toala
CHECKED BY:	L.Tyrell
APPROVED BY:	F.Aquila, L.Tyrell
ISSUE FOR:	Construction




AMERICAN SAMOA POWER AUTHORITY
ENGINEERING SERVICES DIVISION
P.O.BOX PPB, TAFUNA, PAGO PAGO, AS 96799


PROJECT NAME:	VAITOGI ACP WATERLINE REPLACEMENT
DRAWING TITLE:	SEGMENT 2 START PLAN & PROFILE (STA, 0+00 TO 5+60)
PROJECT LOCATION:	VAITOGI VILLAGE, AMERICAN SAMOA

SCALE:	AS SHOWN
DATE:	SEP-2022
SHEET NO.	C05

PROJECT NO:	
SIGNATURE:	
DATE:	

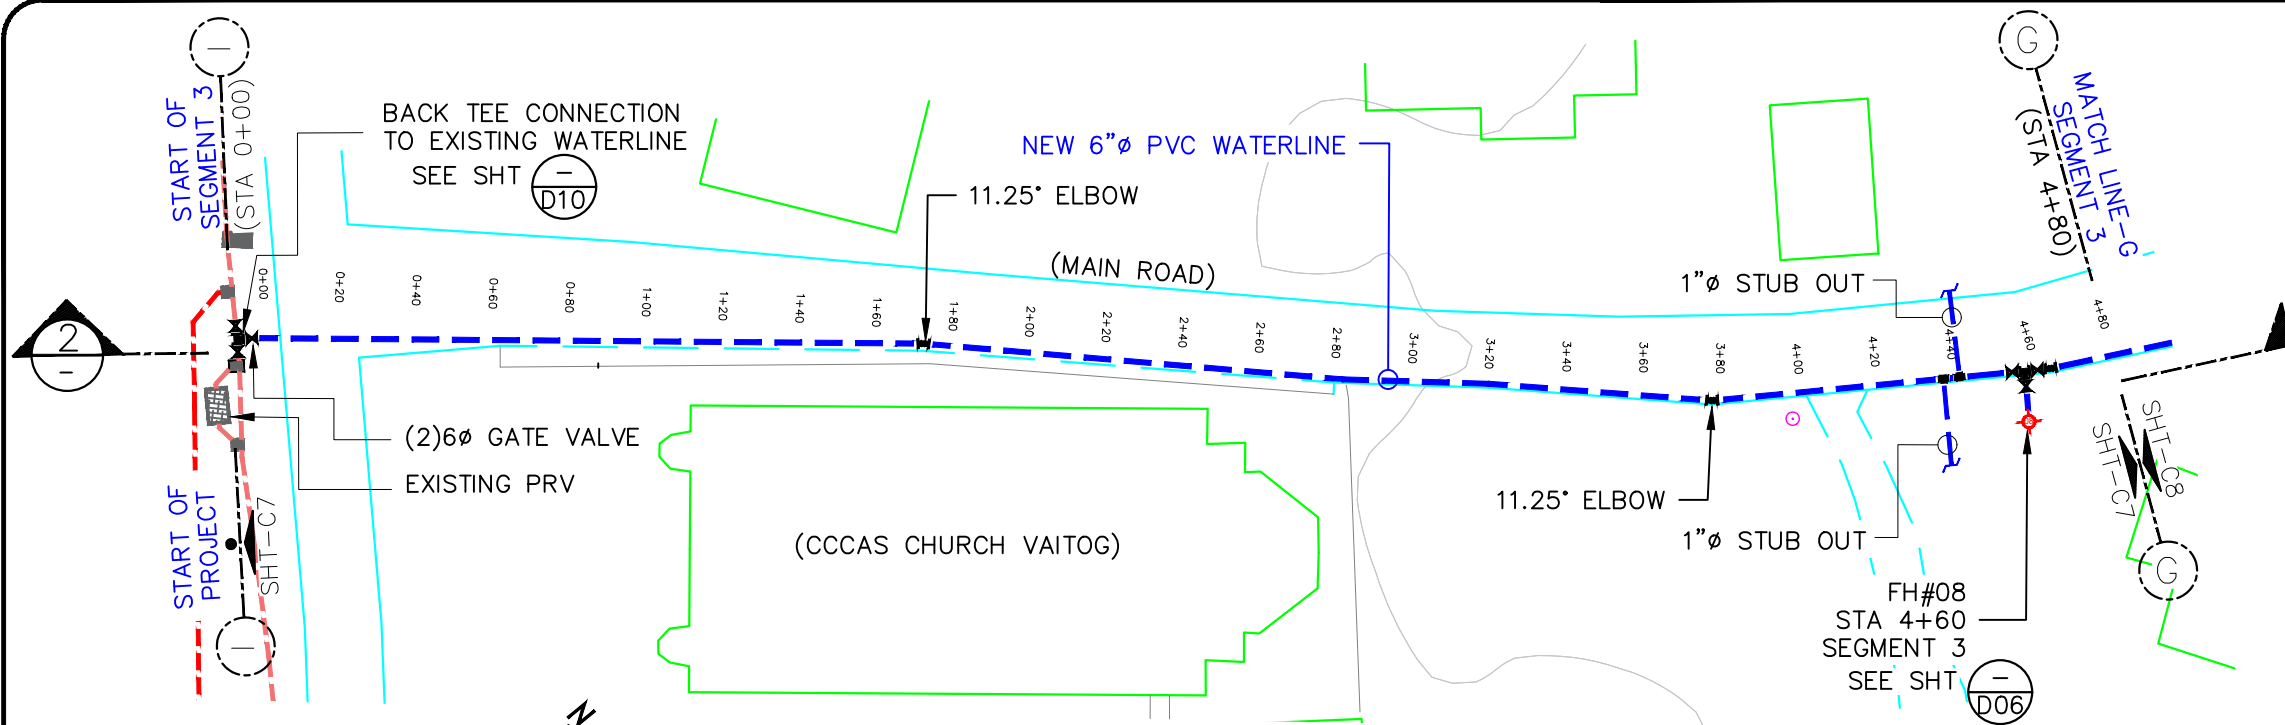

1 LOCATION PLAN
SCALE: AS SHOWN

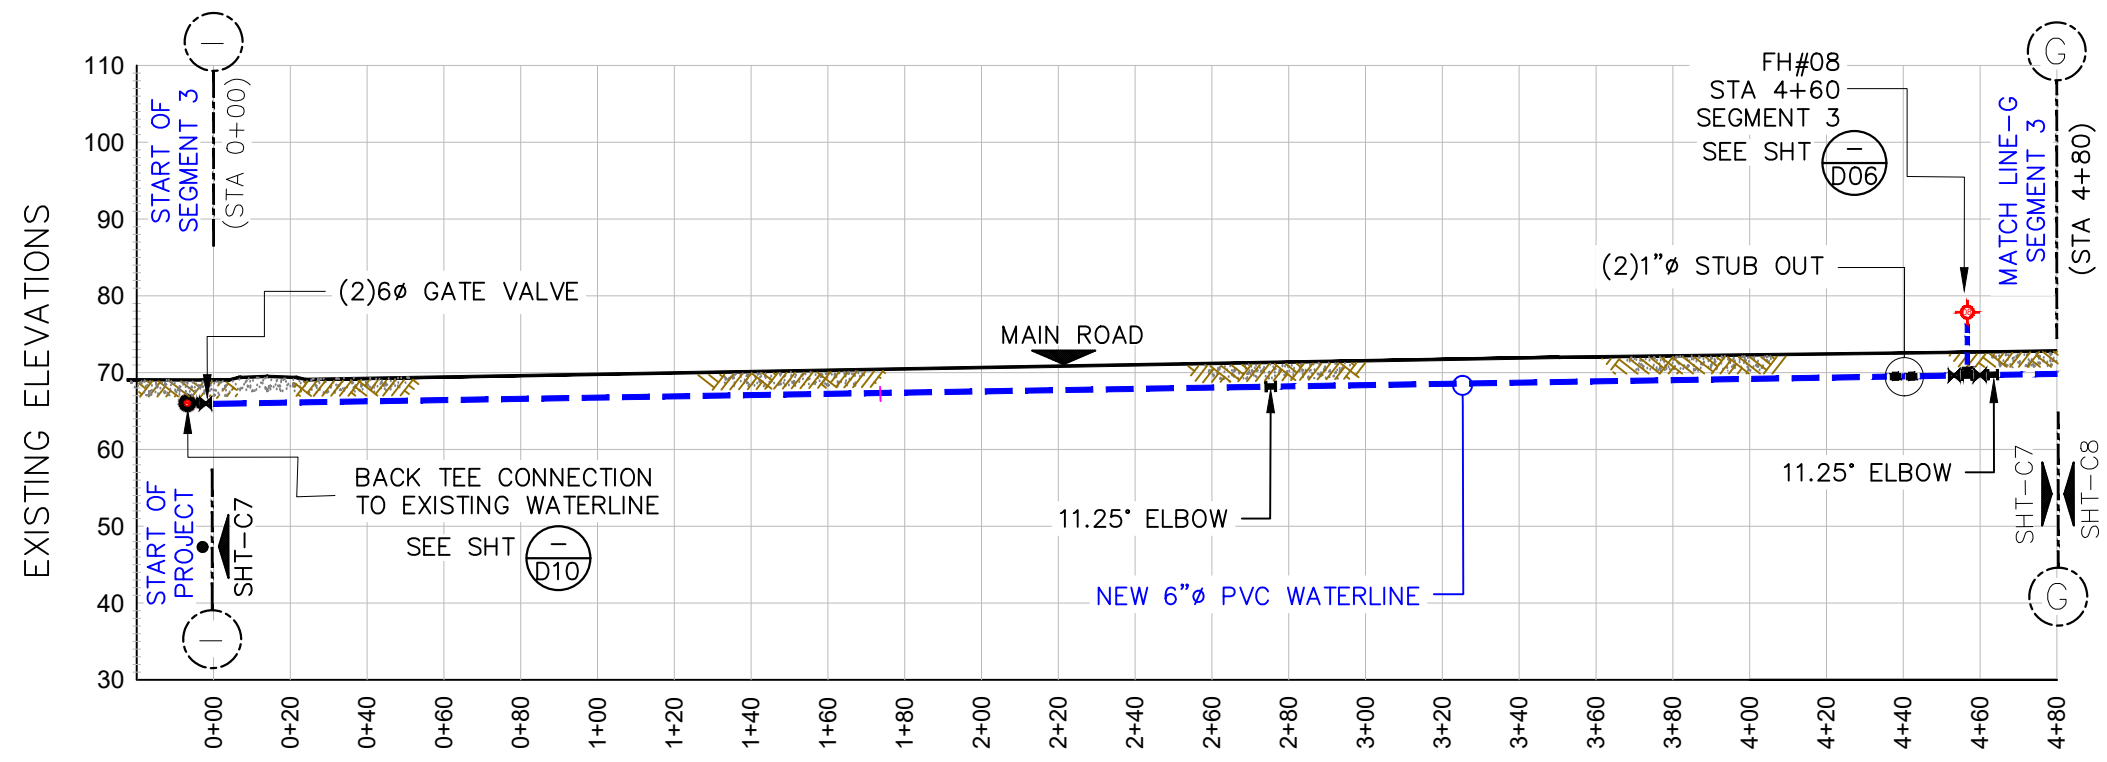


2 PROFILE
SCALE: AS SHOWN

LEGEND:	
EXISTING WATER SERVICE:	
EXISTING ACP WATER:	
NEW 6" PVC WATER:	
TELEPHONE CONDUIT:	
EXISTING STORM DRAIN:	
EXISTING SEWER MAIN:	
GATE VALVE:	
POWER/TEL POLE:	
AIR RELIEVE VALVE:	
ELBOWS:	
11.25°	
22.5°	
45°	
90°	
BACK TEE	
FIRE HYDRANT:	
BAC-T SAMPLING STN:	
SERVICE METER:	
STUB-OUT:	
PRV / PSV :	
EXISTING SERVICE LINE TRANSFERRED TO NEW LINE:	
TREES:	
HEDGES:	
ROCK WALL:	
WIRE FENCE:	

NOTES:
CONSTRUCTION CONTRACTOR SHALL FIELD VERIFY ALL EXISTING UNDERGROUND INFRASTRUCTURE TO ENSURE SAFETY OF ITS WORKERS AND AVOID ANY DAMAGES TO EXISTING GOVERNMENT UTILITIES.

ALL EXISTING FIRE HYDRANT TO BE TRANSFERRED TO NEW LINE.
SEE SHT-DO6 FOR FIRE HYDRANT CONNECTION DETAILS.

INSTALL 2"Øx6"Ø SADDLE FOR NEW SERVICE CONNECTION @ EVERY 500 FEET

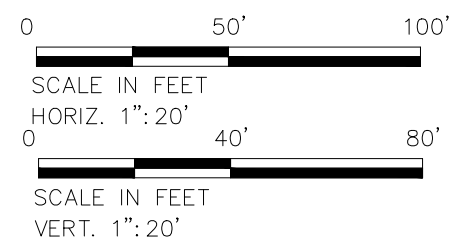

No.	Description	Date

REV. NO.:	
REVISION:	
CHECKED BY:	
APPROVED BY:	
DATE:	

PREPARED BY:	F.Toala
CHECKED BY:	L.Tyrell
APPROVED BY:	F.Aquila, L.Tyrell
ISSUE FOR:	Construction




AMERICAN SAMOA POWER AUTHORITY
ENGINEERING SERVICES DIVISION
P.O.BOX PPB, TAFUNA, PAGO PAGO, AS 96799


PROJECT NAME:	VAITOGI ACP WATERLINE REPLACEMENT
DRAWING TITLE:	SEGMENT 3 START PLAN & PROFILE (STA, 0+00 TO 4+80)
PROJECT LOCATION:	VAITOGI VILLAGE, AMERICAN SAMOA

SCALE:	AS SHOWN
DATE:	SEP-2022
SHEET NO.	C07

PROJECT NO:	
SIGNATURE:	
DATE:	

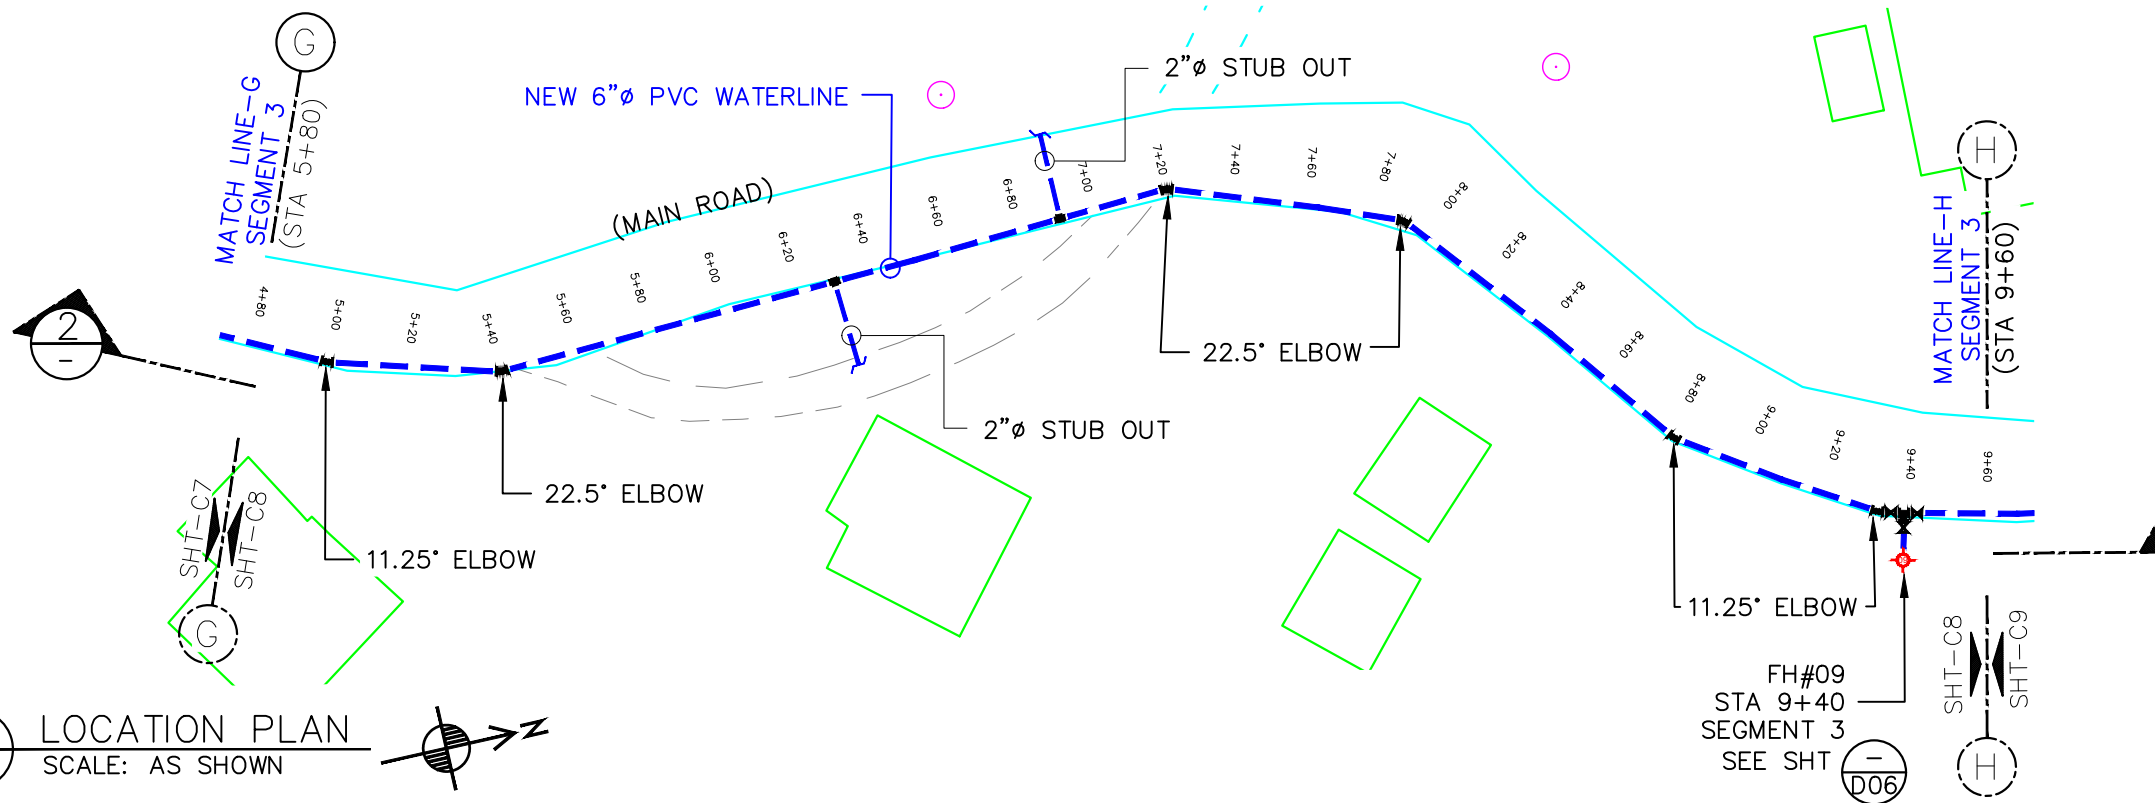

1 LOCATION PLAN
SCALE: AS SHOWN

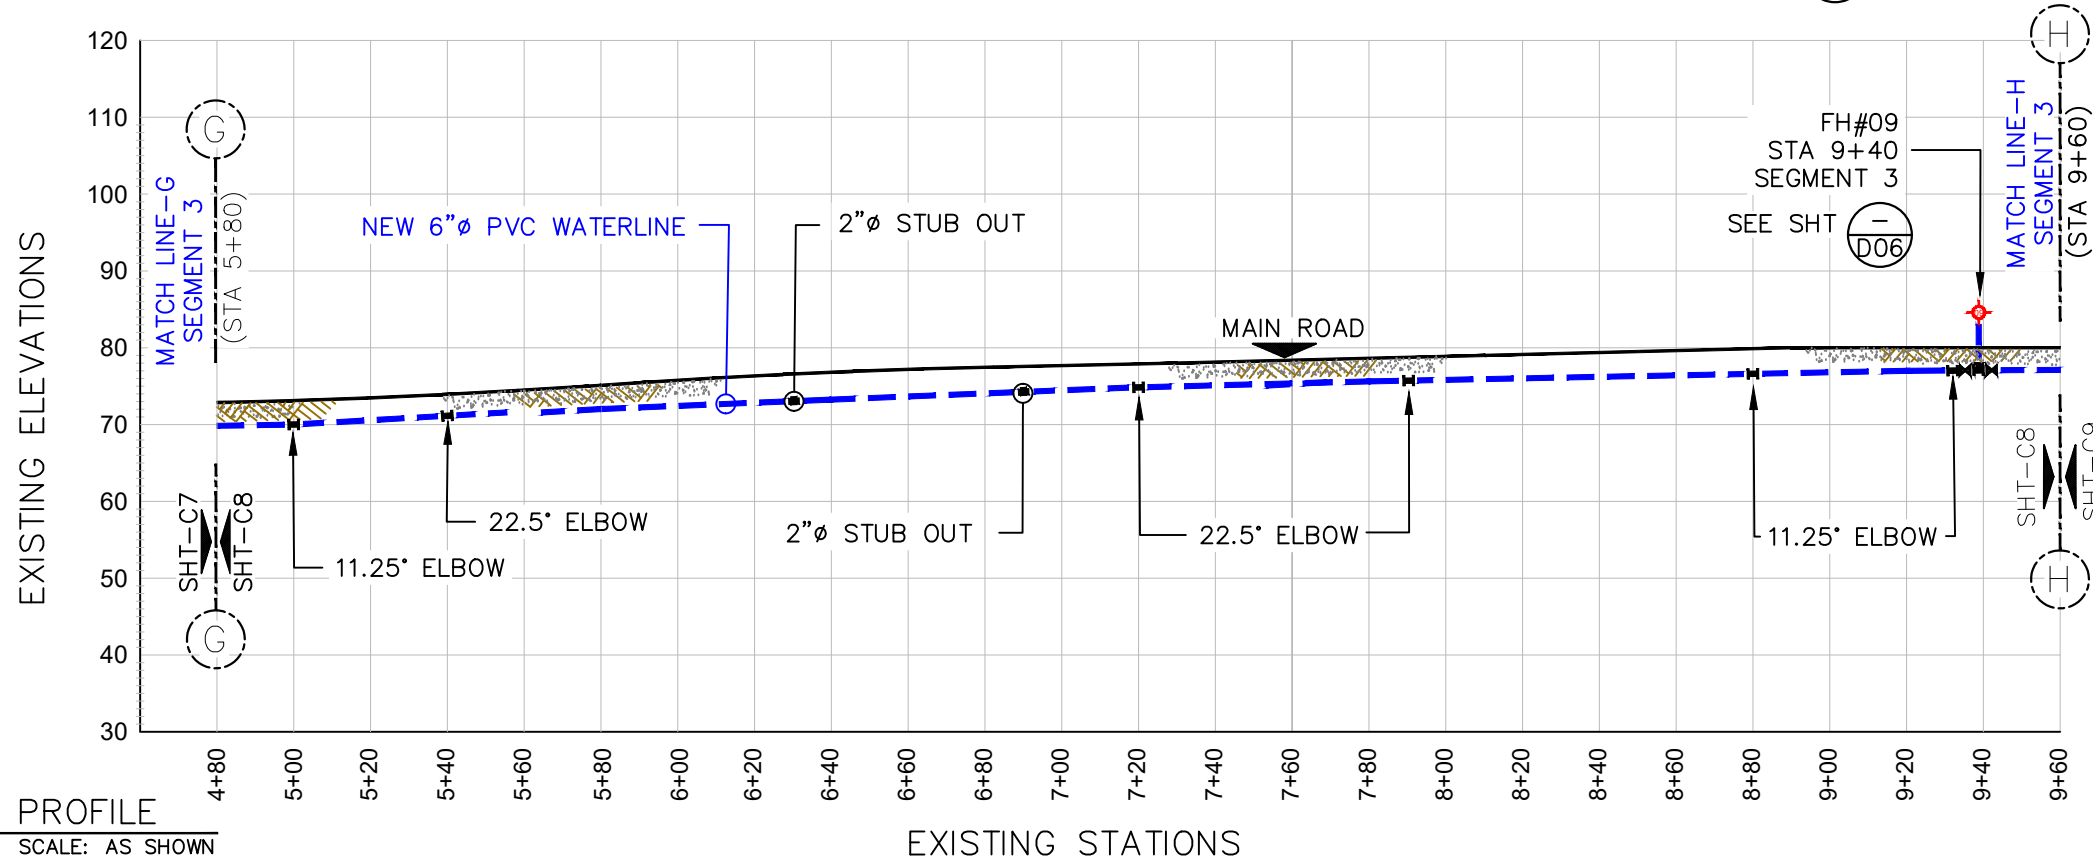


2 PROFILE
SCALE: AS SHOWN

LEGEND:	
EXISTING WATER SERVICE:	
EXISTING ACP WATER:	
NEW 6" PVC WATER:	
TELEPHONE CONDUIT:	
EXISTING STORM DRAIN:	
EXISTING SEWER MAIN:	
GATE VALVE:	
POWER/TEL POLE:	
AIR RELIEVE VALVE:	
ELBOWS:	
FIRE HYDRANT:	
BAC-T SAMPLING STN:	
SERVICE METER:	
STUB-OUT:	
PRV / PSV :	
EXISTING SERVICE LINE TRANSFERRED TO NEW LINE:	
TREES:	
HEDGES:	
ROCK WALL:	
WIRE FENCE:	

NOTES:
CONSTRUCTION CONTRACTOR SHALL FIELD VERIFY ALL EXISTING UNDERGROUND INFRASTRUCTURE TO ENSURE SAFETY OF ITS WORKERS AND AVOID ANY DAMAGES TO EXISTING GOVERNMENT UTILITIES.

ALL EXISTING FIRE HYDRANT TO BE TRANSFERRED TO NEW LINE.
SEE SHT-DO6 FOR FIRE HYDRANT CONNECTION DETAILS.

INSTALL 2"x6" SADDLE FOR NEW SERVICE CONNECTION @ EVERY 500 FEET

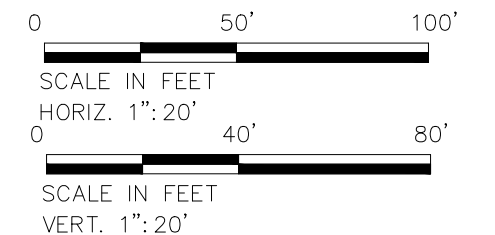

No.	Description	Date

REV. NO.:	
REVISION:	
CHECKED BY:	
APPROVED BY:	
DATE:	

PREPARED BY:	F.Toala
CHECKED BY:	L.Tyrell
APPROVED BY:	F.Aquila, L.Tyrell
ISSUE FOR:	Construction




AMERICAN SAMOA POWER AUTHORITY
ENGINEERING SERVICES DIVISION
P.O.BOX PPB, TAFUNA, PAGO PAGO, AS 96799


PROJECT NAME:	VAITOGI ACP WATERLINE REPLACEMENT
DRAWING TITLE:	SEGMENT 3 PLAN & PROFILE (STA, 4+80 TO 9+60)
PROJECT LOCATION:	VAITOGI VILLAGE, AMERICAN SAMOA

SCALE:	AS SHOWN
DATE:	SEP-2022
SHEET NO.	C08

PROJECT NO:	
SIGNATURE:	
DATE:	

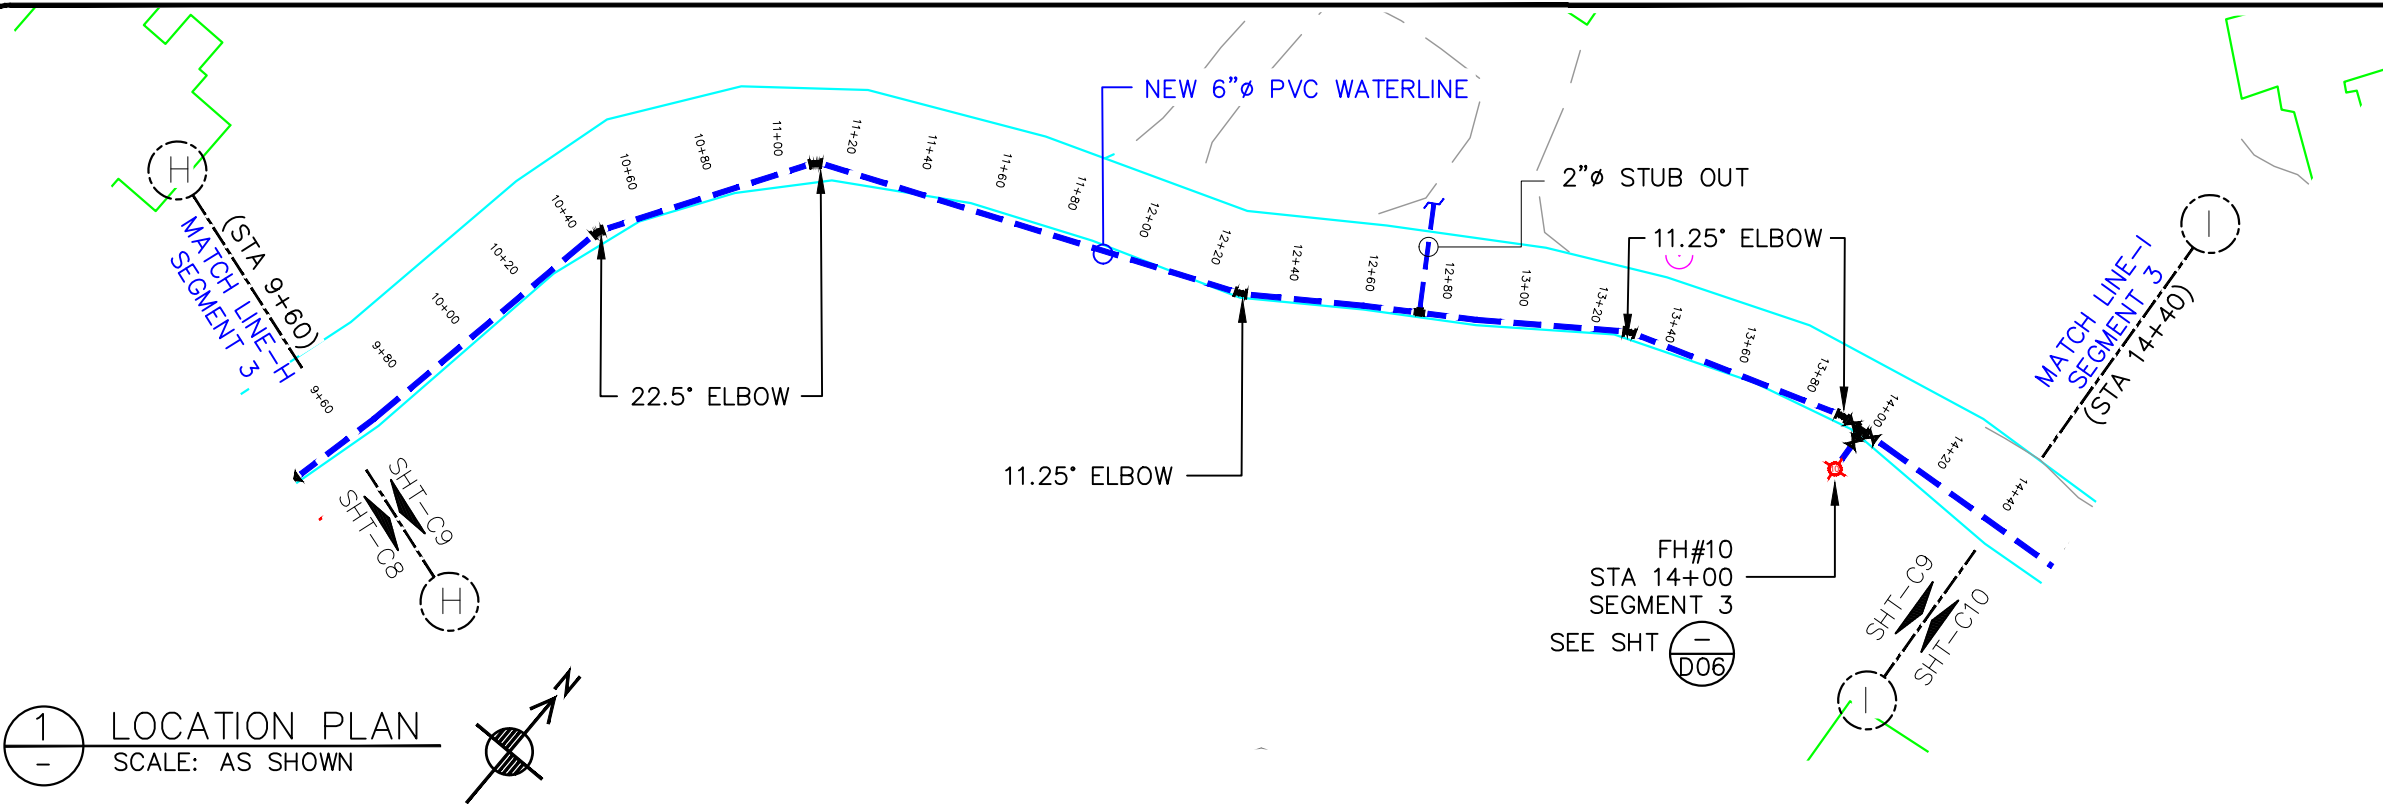

1 LOCATION PLAN
SCALE: AS SHOWN

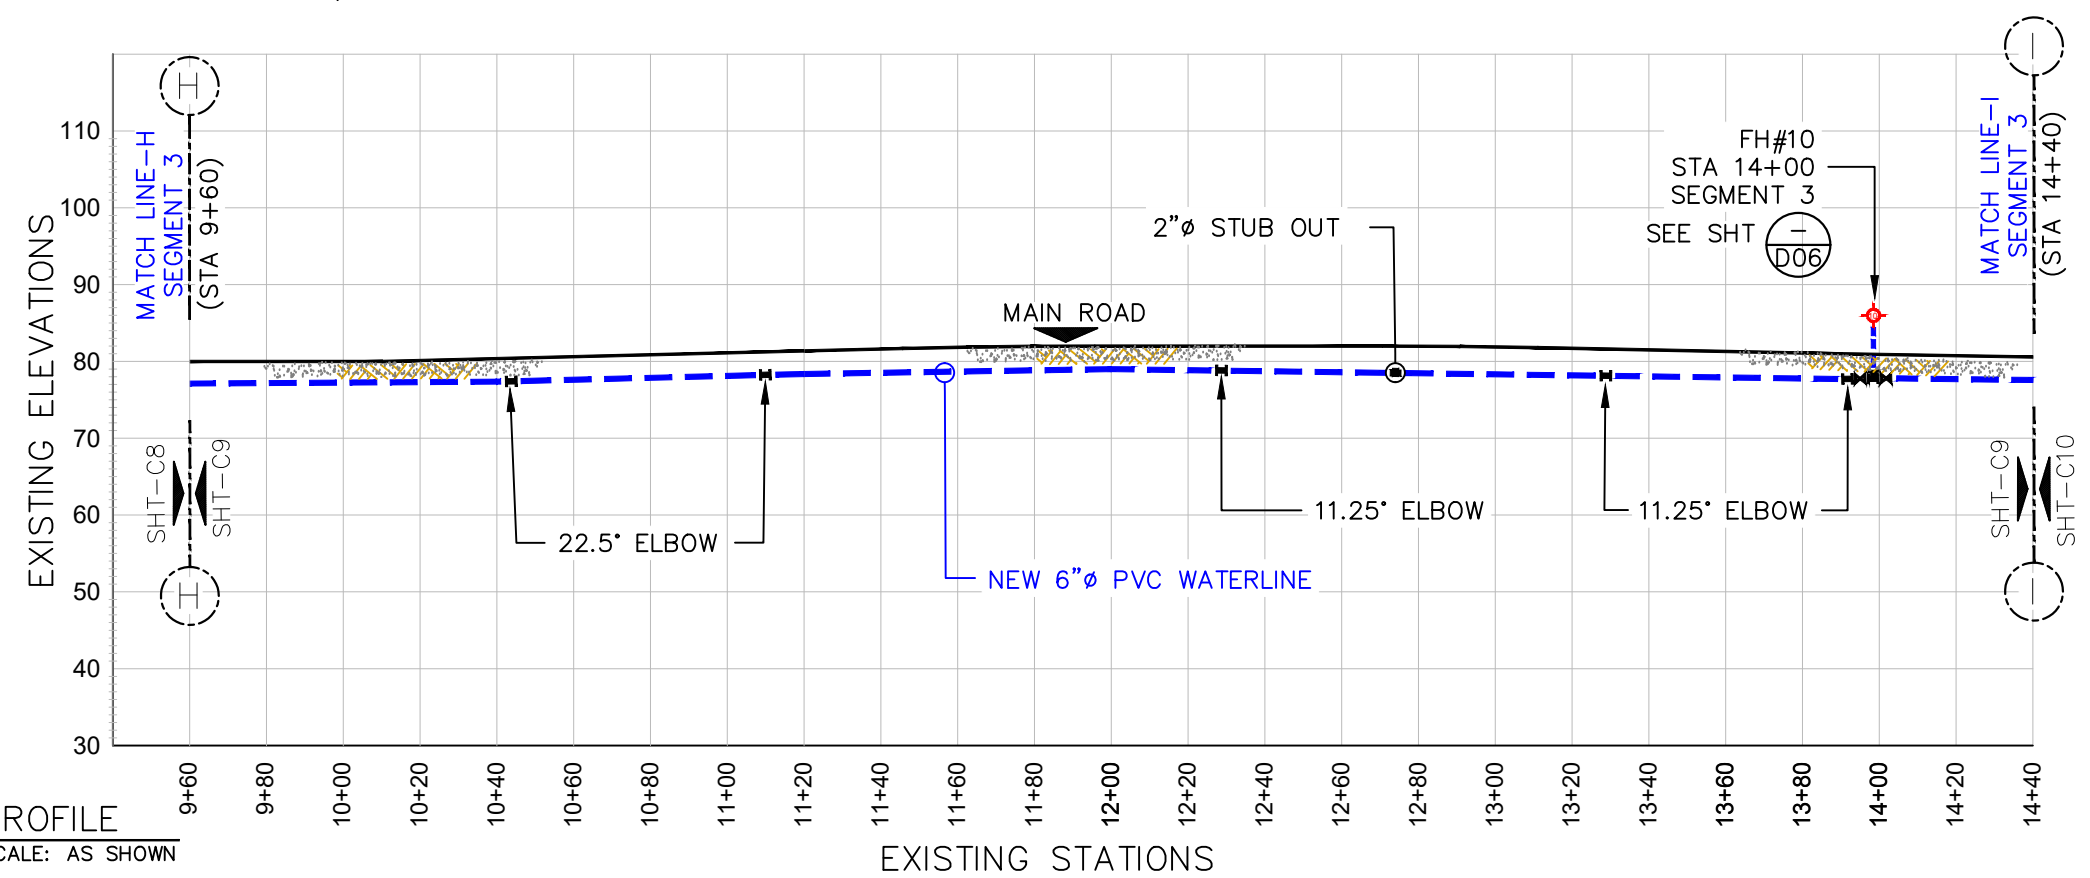

2 PROFILE
SCALE: AS SHOWN

LEGEND:


EXISTING WATER SERVICE:	
EXISTING ACP WATER:	
NEW 6" PVC WATER:	
TELEPHONE CONDUIT:	
EXISTING STORM DRAIN:	
EXISTING SEWER MAIN:	
GATE VALVE:	
POWER/TEL POLE:	
AIR RELIEVE VALVE:	
ELBOWS:	
11.25°	
22.5°	
45°	
90°	
BACK TEE	
FIRE HYDRANT:	
BAC-T SAMPLING STN:	
SERVICE METER:	
STUB-OUT:	
PRV / PSV :	
EXISTING SERVICE LINE TRANSFERRED TO NEW LINE:	
TREES:	
HEDGES:	
ROCK WALL:	
WIRE FENCE:	

NOTES:

CONSTRUCTION CONTRACTOR SHALL FIELD VERIFY ALL EXISTING UNDERGROUND INFRASTRUCTURE TO ENSURE SAFETY OF ITS WORKERS AND AVOID ANY DAMAGES TO EXISTING GOVERNMENT UTILITIES.

ALL EXISTING FIRE HYDRANT TO BE TRANSFERRED TO NEW LINE.
SEE SHT-DO6 FOR FIRE HYDRANT CONNECTION DETAILS.

INSTALL 2"Øx6"Ø SADDLE FOR NEW SERVICE CONNECTION @ EVERY 500 FEET

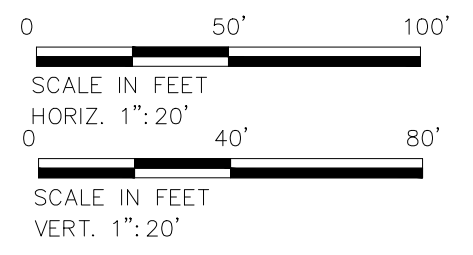

No.	Description	Date

REV. NO.:
REVISION:
CHECKED BY:
APPROVED BY:
DATE:

PREPARED BY: F.Toala
CHECKED BY: L.Tyrell
APPROVED BY: F.Aquila, L.Tyrell
ISSUE FOR: Construction




AMERICAN SAMOA POWER AUTHORITY
ENGINEERING SERVICES DIVISION
P.O.BOX PPB, TAFUNA, PAGO PAGO, AS 96799


PROJECT NAME: VAITOGI ACP WATERLINE REPLACEMENT
DRAWING TITLE: SEGMENT 3 PLAN & PROFILE (STA, 9+60 TO 14+40)
PROJECT LOCATION: VAITOGI VILLAGE, AMERICAN SAMOA

SCALE: AS SHOWN
DATE: SEP-2022
SHEET NO. C09

PROJECT NO:
SIGNATURE:
DATE:

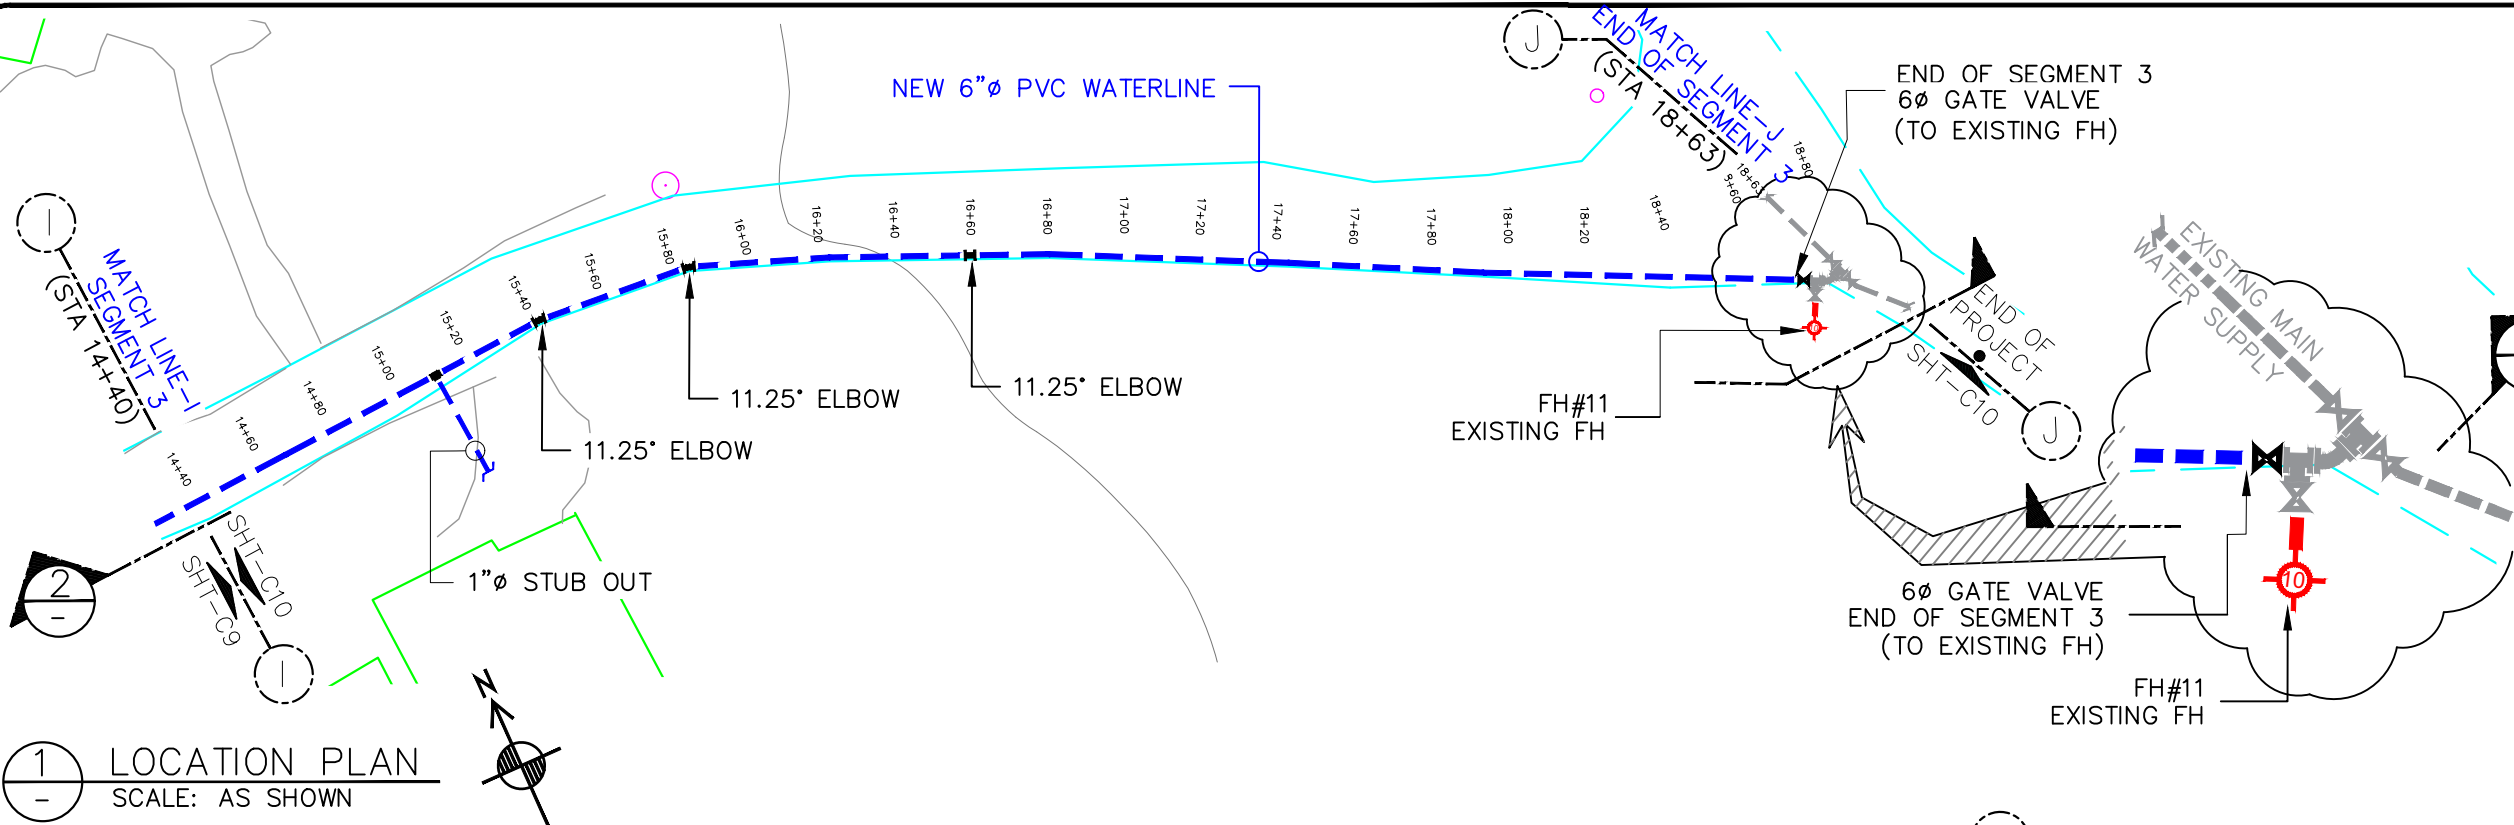

1 LOCATION PLAN
SCALE: AS SHOWN

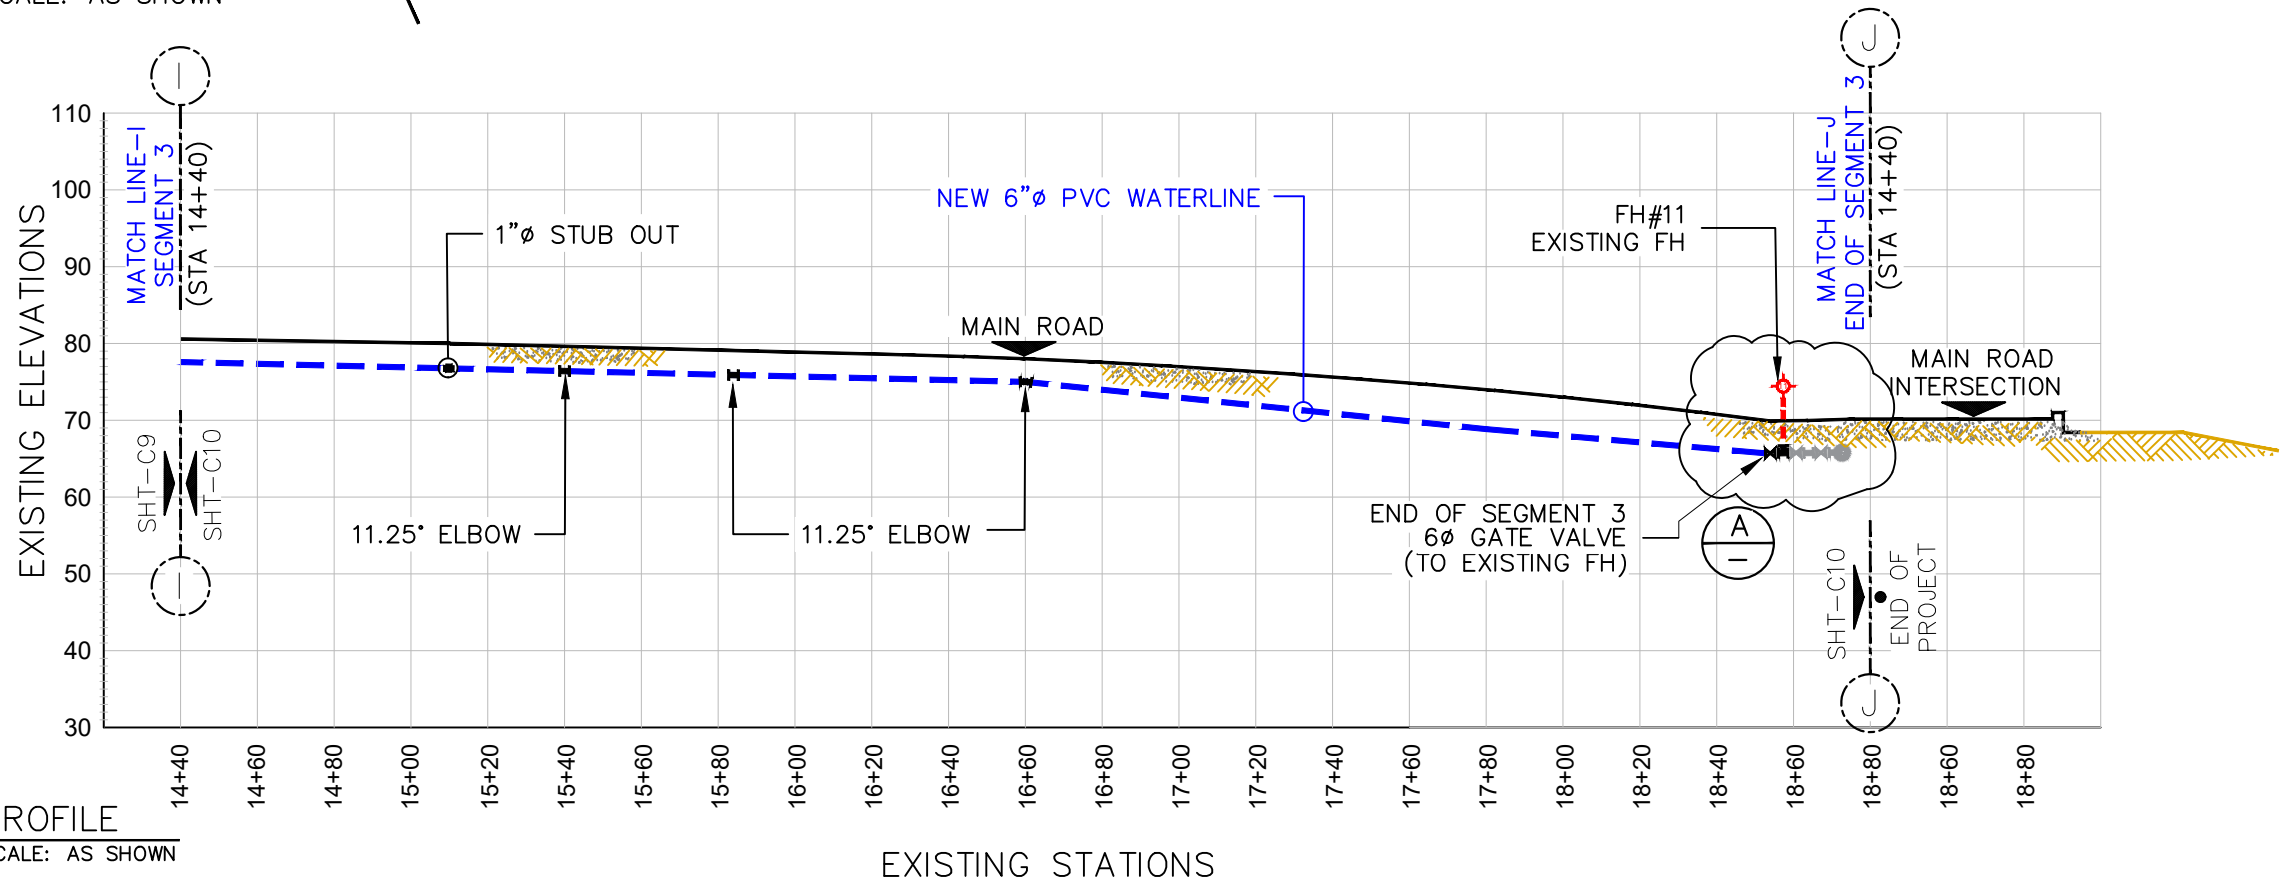


2 PROFILE
SCALE: AS SHOWN

LEGEND:	
EXISTING WATER SERVICE:	
EXISTING ACP WATER:	
NEW 6" PVC WATER:	
TELEPHONE CONDUIT:	
EXISTING STORM DRAIN:	
EXISTING SEWER MAIN:	
GATE VALVE:	
POWER/TEL POLE:	
AIR RELIEVE VALVE:	
ELBOWS:	
FIRE HYDRANT:	
BAC-T SAMPLING STN:	
SERVICE METER:	
STUB-OUT:	
PRV / PSV :	
EXISTING SERVICE LINE TRANSFERRED TO NEW LINE:	
TREES:	
ROCK WALL:	
WIRE FENCE:	

NOTES:
CONSTRUCTION CONTRACTOR SHALL FIELD VERIFY ALL EXISTING UNDERGROUND INFRASTRUCTURE TO ENSURE SAFETY OF ITS WORKERS AND AVOID ANY DAMAGES TO EXISTING GOVERNMENT UTILITIES.

ALL EXISTING FIRE HYDRANT TO BE TRANSFERRED TO NEW LINE.
SEE SHT-DO6 FOR FIRE HYDRANT CONNECTION DETAILS.

INSTALL 2"x6" SADDLE FOR NEW SERVICE CONNECTION @ EVERY 500 FEET

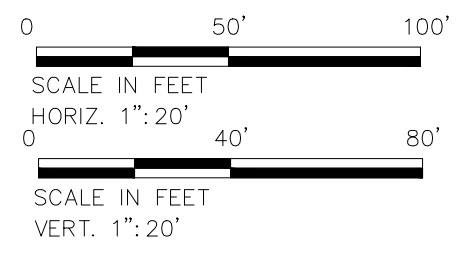

No.	Description	Date

REV. NO.:	PREPARED BY:
	F.Toala
REVISION:	CHECKED BY:
	L.Tyrell
CHECKED BY:	APPROVED BY:
	F.Aquila, L.Tyrell
APPROVED BY:	ISSUE FOR:
	Construction
DATE:	




AMERICAN SAMOA POWER AUTHORITY
ENGINEERING SERVICES DIVISION
P.O.BOX PPB, TAFUNA, PAGO PAGO, AS 96799

PROJECT NAME:	VAITOGI ACP WATERLINE REPLACEMENT
DRAWING TITLE:	END OF SEGMENT 3 PLAN & PROFILE (STA, 14+40 TO 19+00)
PROJECT LOCATION:	VAITOGI VILLAGE, AMERICAN SAMOA

SCALE:	PROJECT NO:
AS SHOWN	
DATE:	SIGNATURE:
SEP-2022	
SHEET NO.	DATE:
C10	

- ARV VALVE SECTION DETAILS
 - SCALE: $3/4" = 1'$

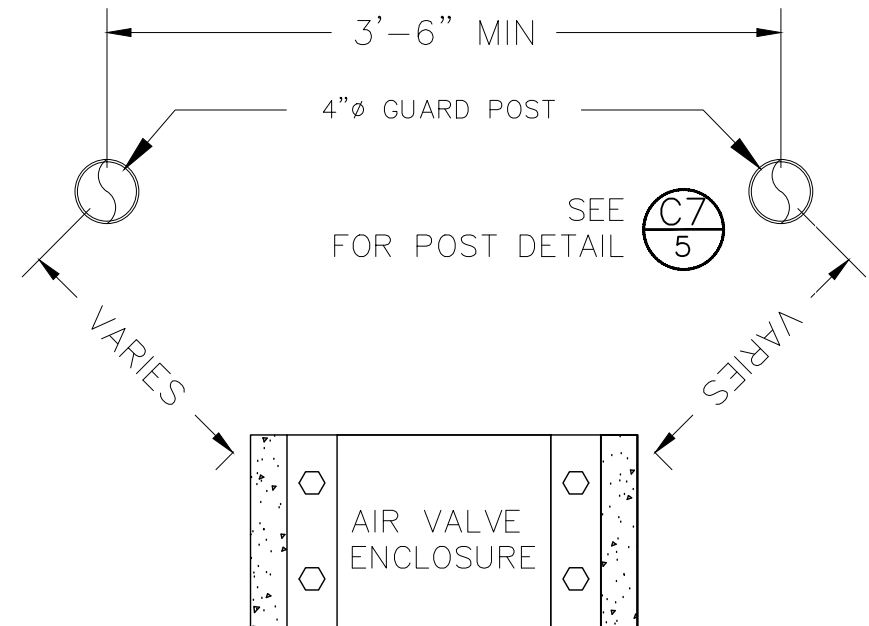

2 PLAN VIEW SHOWING
- ARV GUARD POST LOCATION
NOT TO SCALE

NOTE:
GUARD POST LOCATION
DETERMINED BY ENGINEER

No.	Description	Date	REV. NO.:	PREPARED BY:	 AMERICAN SAMOA POWER AUTHORITY ENVIRONMENTAL SERVICES DIVISION P.O.BOX PPB, TAFUNA, PAGO PAGO, AS 96799	PROJECT NAME:	SCALE:		PROJECT NO.:
			REVISION:	CHECKED BY:		VAITOGI WATERLINE REPLACEMENT PROJECT	AS SHOWN		
			CHECKED BY:	APPROVED BY:		DRAWING TITLE:	DATE:	SIGNATURE:	
			APPROVED BY:	ISSUE FOR:		AIR RELIEF VALVE & DETAILS	7-2022		
			DATE:			PROJECT LOCATION:	SHEET NO.		
						VAITOGI VILLAGE, AMERICAN SAMOA	D02	DATE:	




GENERAL NOTES:

- 1. TABLE IS BASED ON 2000#/SQ. FT. SOIL. IF CONDITIONS ARE FOUND TO INDICATE SOIL BEARING IS LESS, THE AREAS SHALL BE INCREASED ACCORDINGLY.
- 2. AREAS FOR PIPE LARGER THAN 18" SHALL BE CALCULATED.
- 3. CONCRETE SHALL HAVE A MINIMUM COMPRESSION STRENGTH OF 2500 PSI.
- 4. THRUST BLOCK IS TO EXTEND TO UNDISTURBED SOIL.
- 5. SIZE MAY BE DECREASED FOR LESSER DEGREE BENDS AS DETERMINED BY ENGINEER.
- 6. KEEP CONCRETE CLEAR OF M.J. OR BELL AND SPIGOT JOINTS.
- 7. BLOCK IN A SIMILAR MANNER AT TEES, HYDRANTS, PLUG OR OTHER LOCATIONS AS REQUIRED.
- 8. WHEN NECESSARY ADDITIONAL THRUST RESTRAINT METHODS MAY BE USED, SUCH AS MECHANICAL JOINT RESTRAINTS, TIE-RODS (INSTALLED PER MANUFACTURERS' RECOMMENDATIONS) OR OTHER APPROVED METHODS.

CONSTRUCTION KEY NOTES:


- A. LENGTH "Y & W" AS REQUIRED TO OBTAIN BEARING AREA AGAINST UNDISTURBED SOIL.
- B. ADDITIONAL EXCAVATION IF NECESSARY TO OBTAIN REQUIRED BEARING AREA.
- C. MINIMUM THRUST BLOCK AREA REQUIREMENTS FOR (Y & W) AS FOLLOWS:

PIPE SIZE	WATER PIPE	
	TEE, DEAD END 90° BEND	45° AND 22 1/2° BENDS
4" & LESS	3 SQ. FEET	3 SQ. FEET
6"	4 SQ. FEET	3 SQ. FEET
8"	6 SQ. FEET	3 SQ. FEET
10"	9 SQ. FEET	5 SQ. FEET
12"	13 SQ. FEET	7 SQ. FEET
16"	23 SQ. FEET	12 SQ. FEET
18"	29 SQ. FEET	15 SQ. FEET

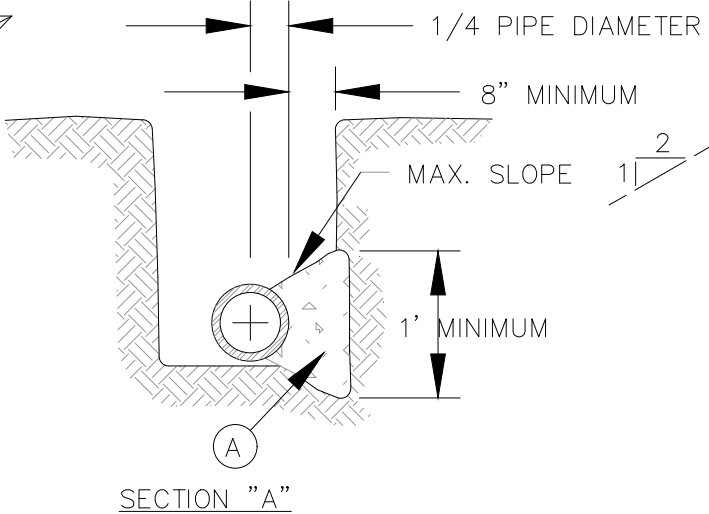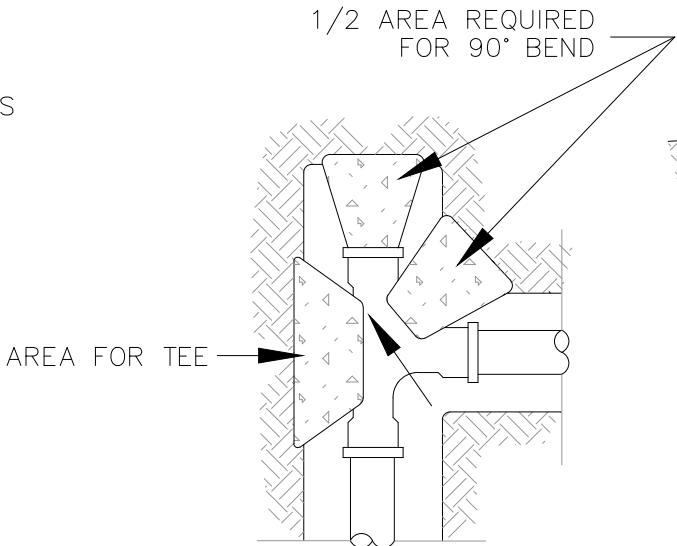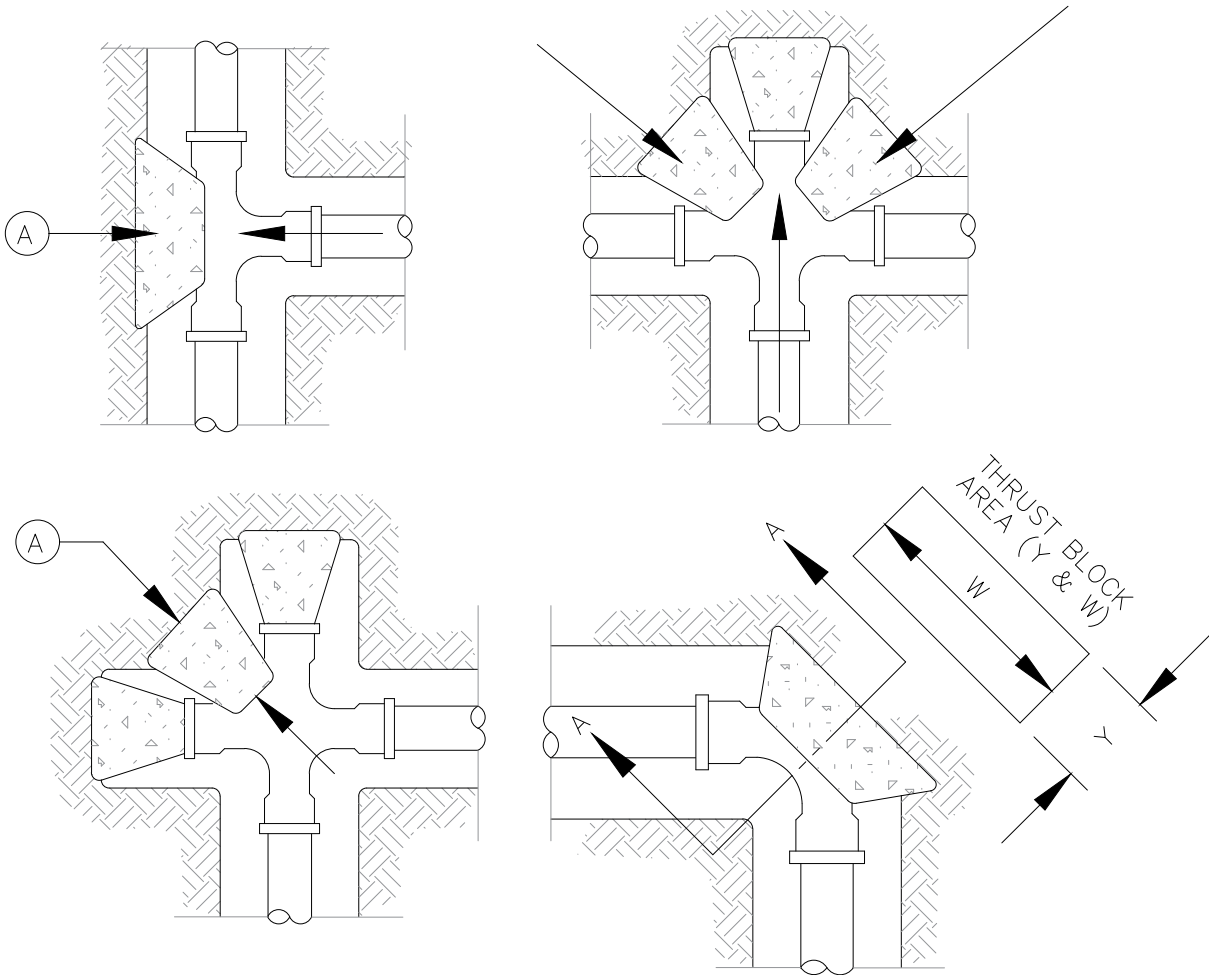


NOTES:

- 1. ALL ANCHOR RODS ARE TO BE COVERED WITH 80MILS OF BITUMASTIC COMPOUND.
- 2. WRAP EXTERIOR OF VALVE, ACTUATOR AND REBAR WITH 8 MIL POLYETHYLENE SHEETING AND TAPE.

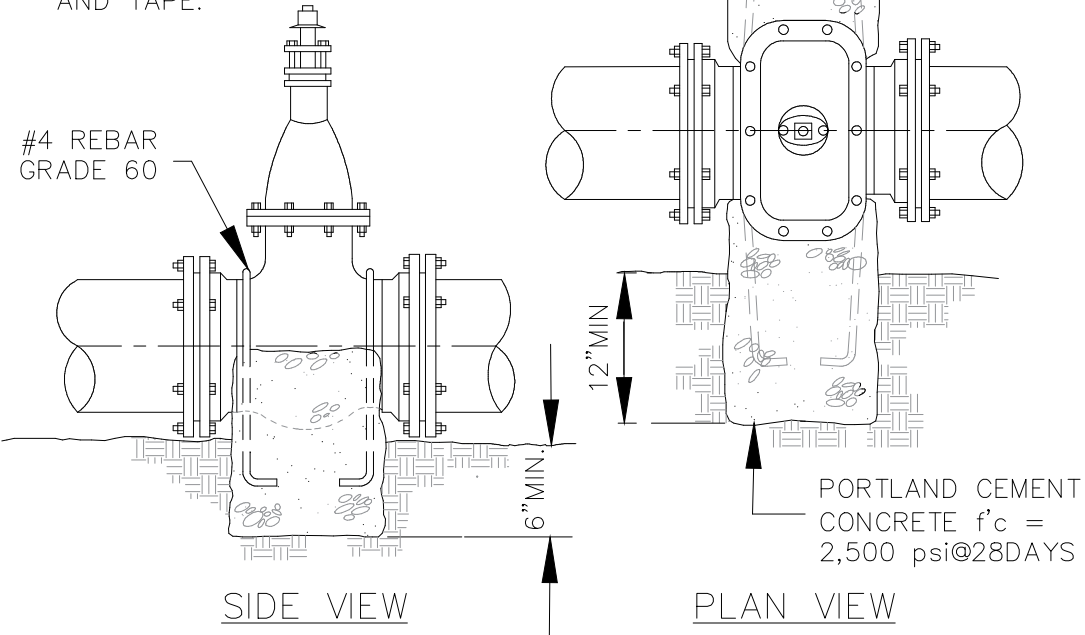


1 TYP. ANCHORING DETAILS Scale: NTS

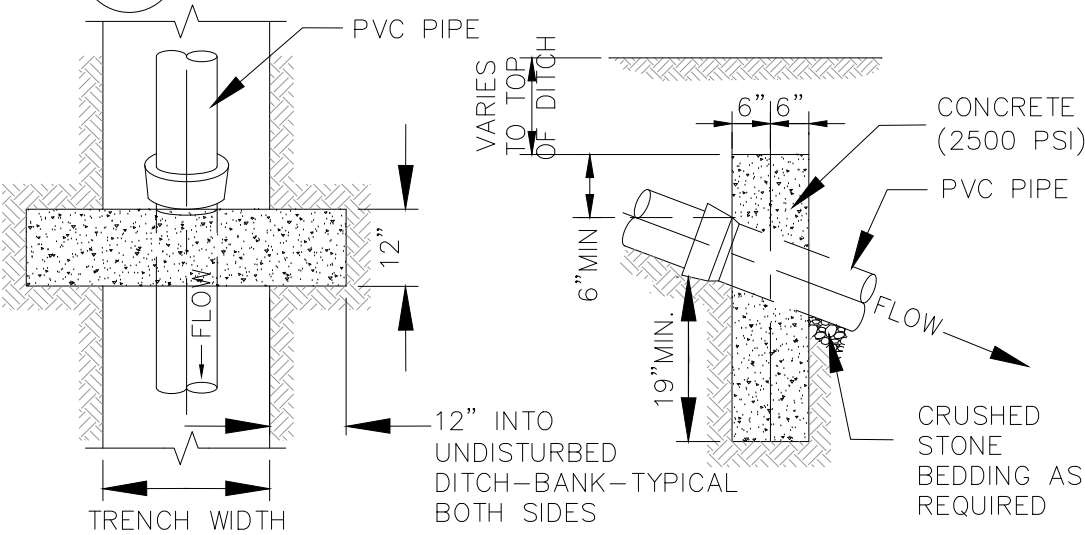

2 ANCHOR ON STEEP SLOPES Scale: NTS


No.	Description	Date	REV. NO.:	PREPARED BY:	PROJECT NAME:	SCALE:	PROJECT NO.:
			REVISION:	F.Toala.	VAITOGI WATERLINE REPLACEMENT PROJECT	AS SHOWN	
			CHECKED BY:	L.Tyrell	DRAWING TITLE:	DATE:	
			APPROVED BY:	F.Aquila	CONCRETE THRUST BLOCKING DETAILS	7-2022	
			DATE:	Construction	PROJECT LOCATION:	SHEET NO.	SIGNATURE:
					VAITOGI VILLAGE, AMERICAN SAMOA	D03	DATE:

AMERICAN SAMOA POWER AUTHORITY
ENVIRONMENTAL SERVICES DIVISION
P.O.BOX PPB, TAFUNA, PAGO PAGO, AS 96799

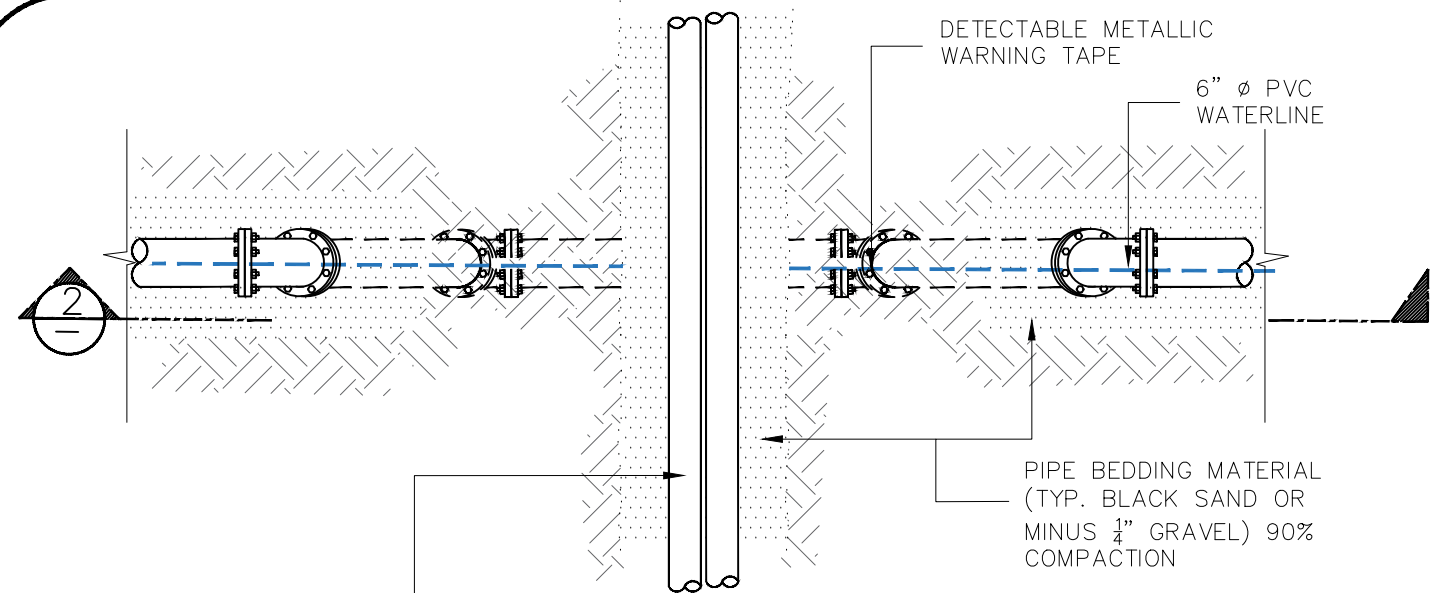


1 PIPE TRENCH PLAN (SECTION ELEVATION)
SCALE: 1/2" = 1'


TRENCH TABLE	
PIPE SIZE	PAYMENT TRENCH
1"	16"
4", 6", 8" OR 10"	24"
12"	30"
16"	34"
20"	38"
24"	42"

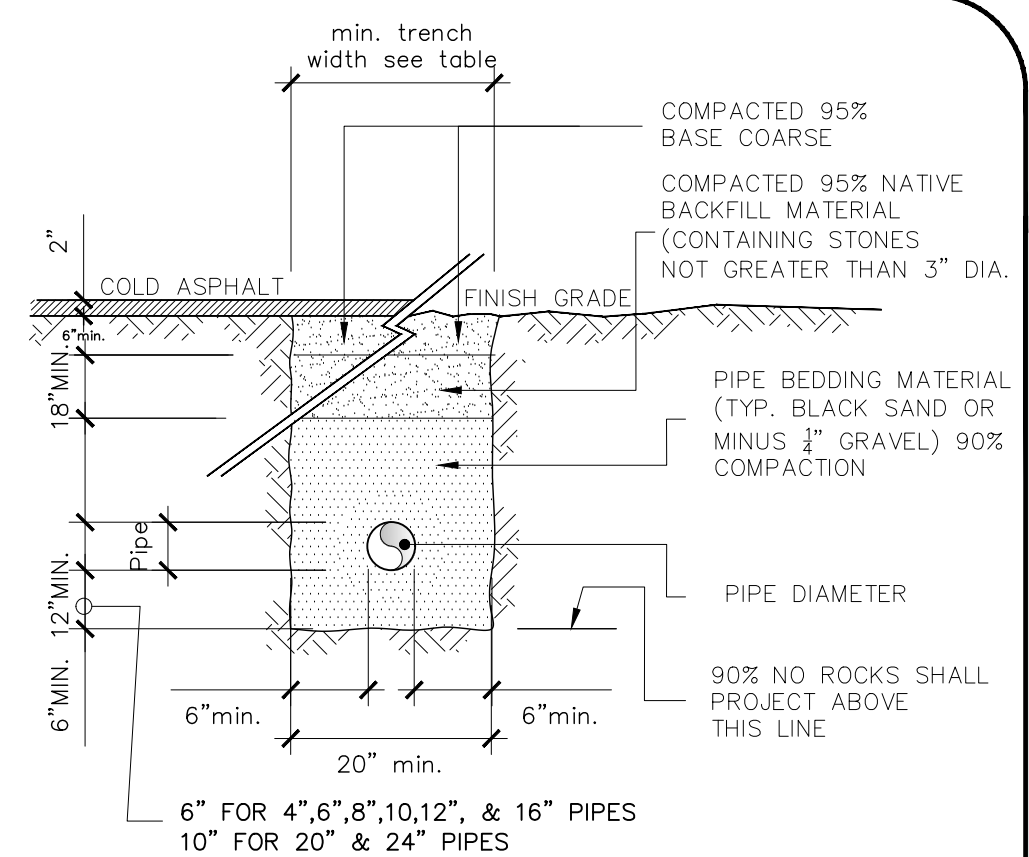


4 TYPICAL TRENCH SECTION
SCALE: 1/2" = 1'

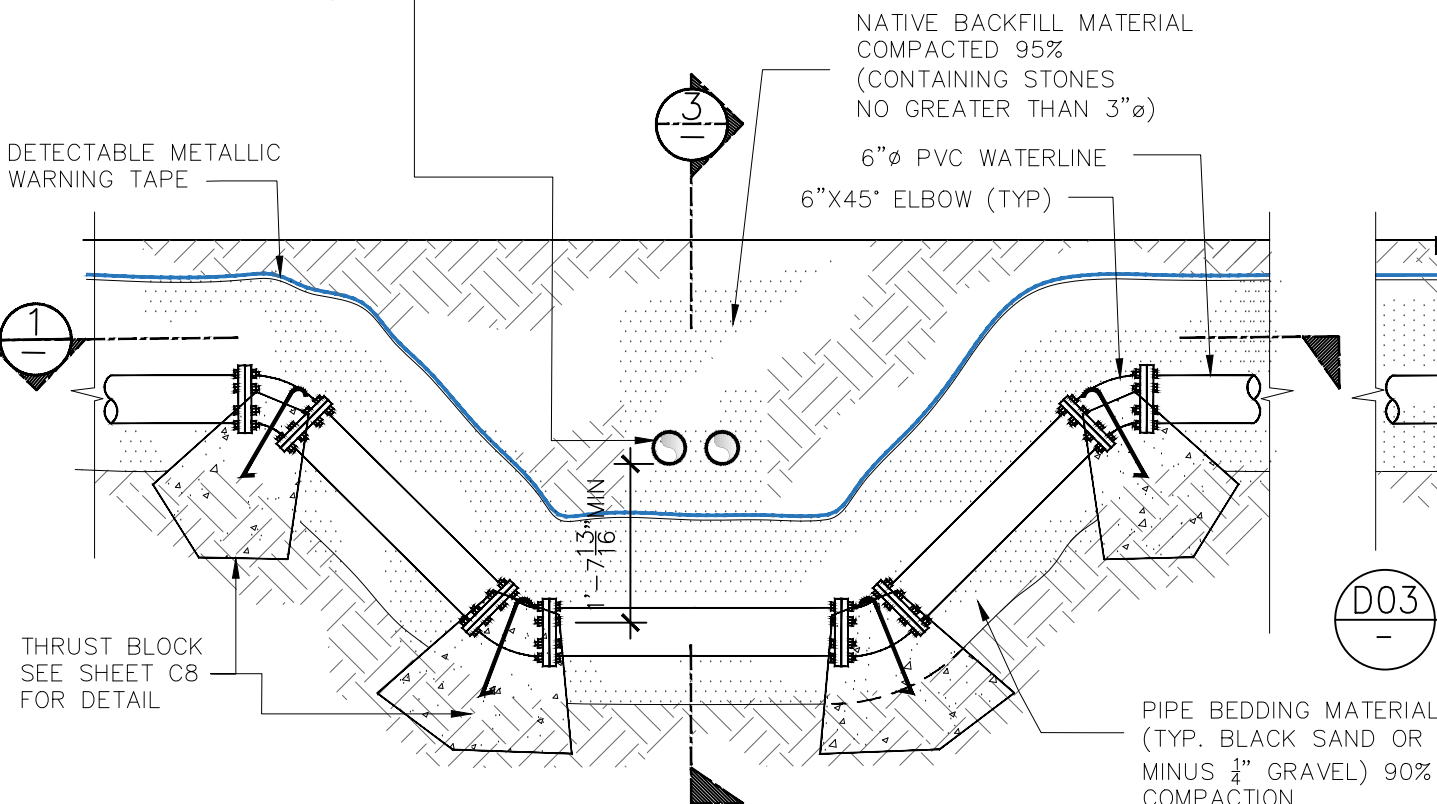

2 TYPICAL UTILITY CROSSING SECTION ELEVATION
SCALE: 1/2" = 1'

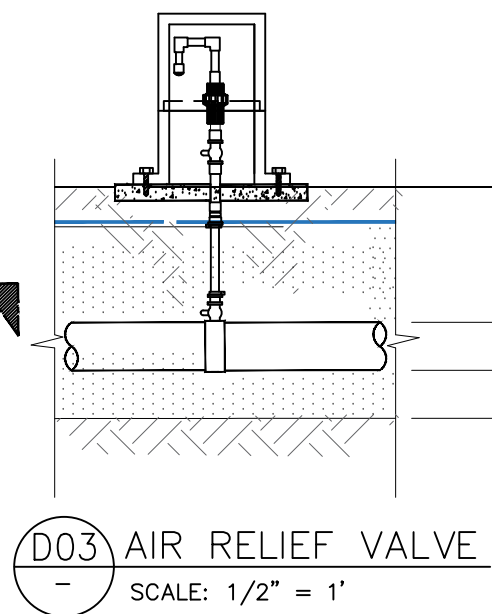

D03 AIR RELIEF VALVE
SCALE: 1/2" = 1'

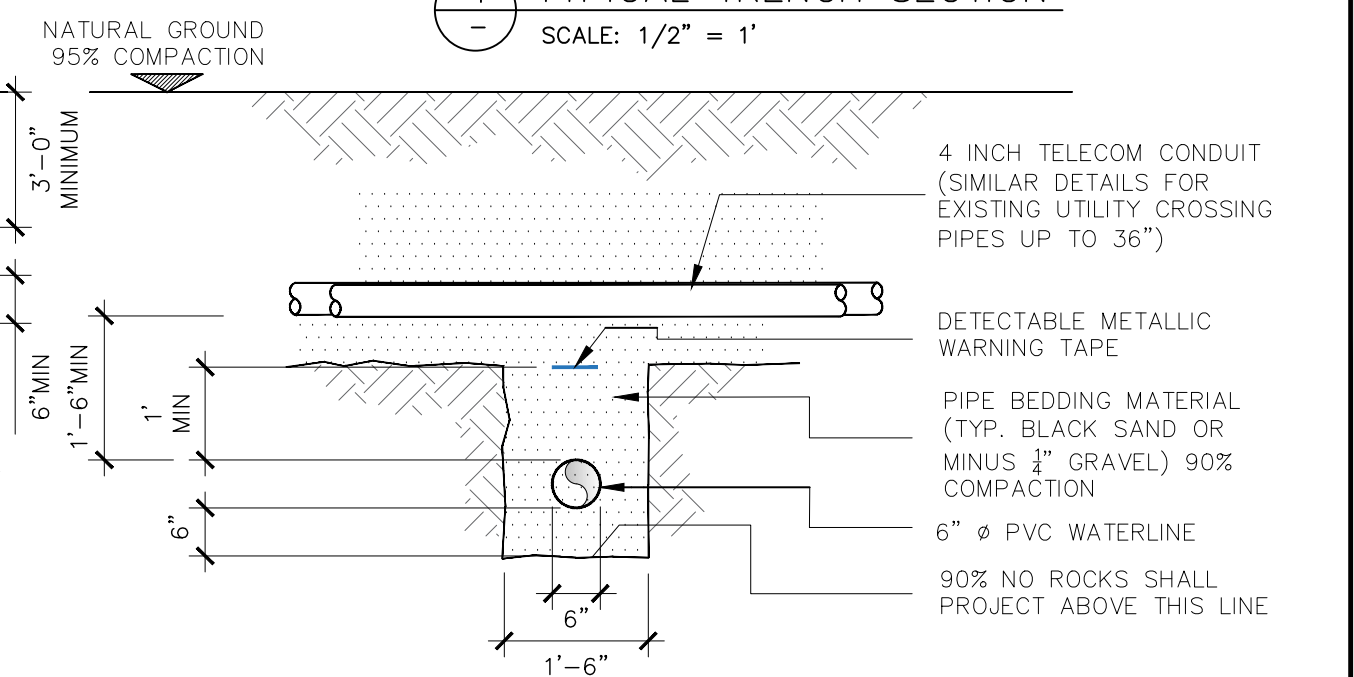

3 TYPICAL UTILITY CROSSING SECTION ELEVATION
SCALE: 1/2" = 1'



No.	Description	Date	REV. NO.:	PREPARED BY:
				F.Toala.
			REVISION:	CHECKED BY:
				L.Tyrell
			CHECKED BY:	APPROVED BY:
				F.Aquila
			APPROVED BY:	ISSUE FOR:
				Construction
			DATE:	



AMERICAN SAMOA POWER AUTHORITY
ENVIRONMENTAL SERVICES DIVISION
P.O.BOX PPB, TAFUNA, PAGO PAGO, AS 96799


PROJECT NAME:	VAITOGI WATERLINE REPLACEMENT PROJECT
DRAWING TITLE:	UTILITY CROSSING & TRENCH DETAILS
PROJECT LOCATION:	VAITOGI VILLAGE, AMERICAN SAMOA

SCALE:	AS SHOWN	PROJECT NO.:	
DATE:	7-2022	SIGNATURE:	
SHEET NO.	D04	DATE:	

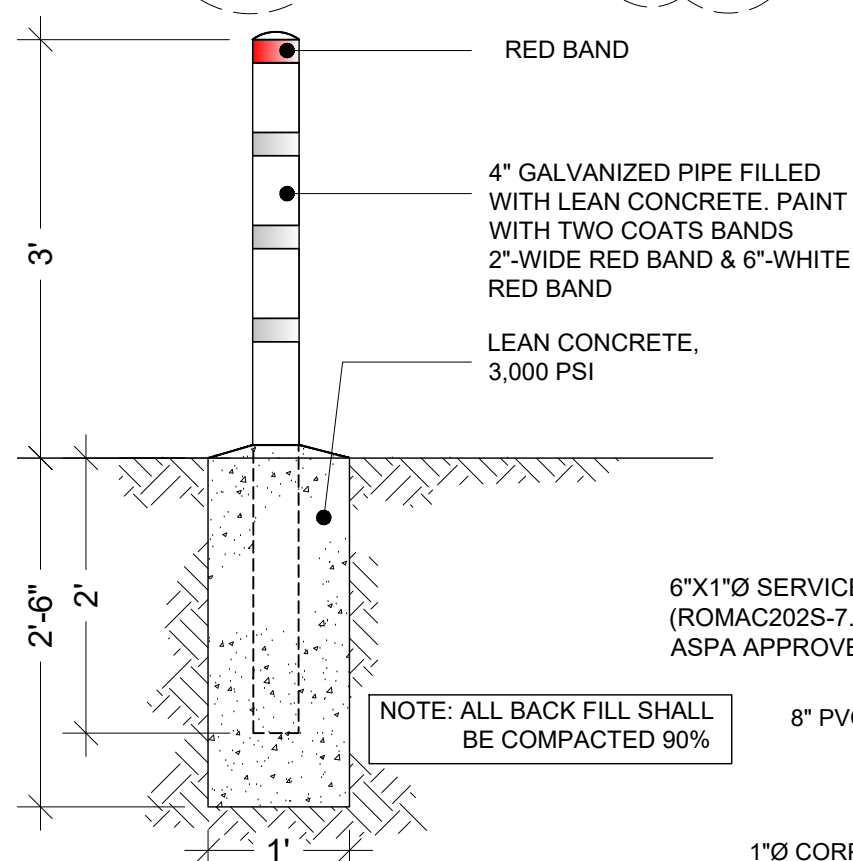 

SAFETY GUARD BACTERIOLOGICAL
SAMPLING STATION ELEVATION

NOT TO SCALE (SEE SUPPLEMENTAL SPECIFICATION)

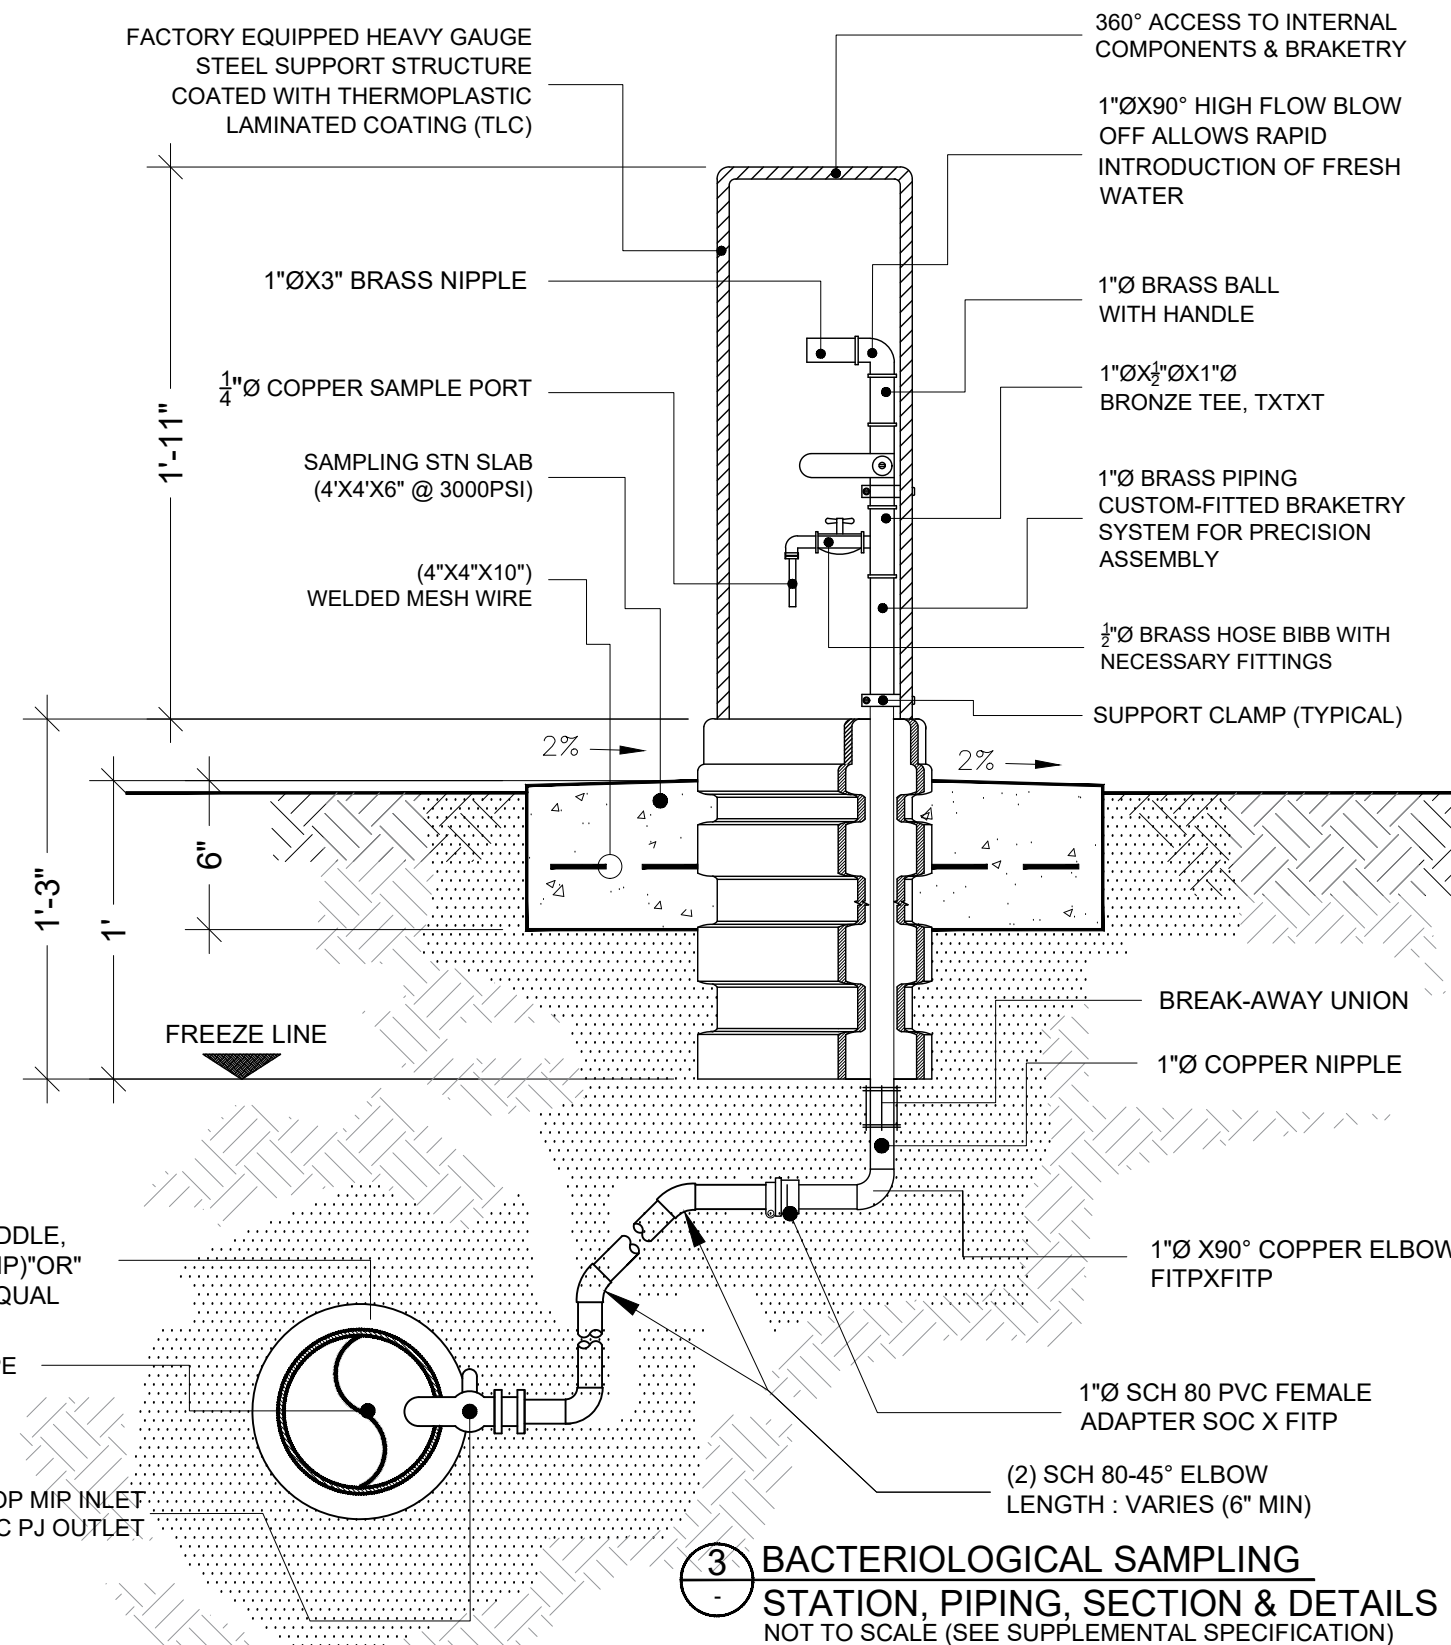

3 BACTERIOLOGICAL SAMPLING
STATION, PIPING, SECTION & DETAILS
NOT TO SCALE (SEE SUPPLEMENTAL SPECIFICATION)

[illegible]

AMERICAN SAMOA POWER AUTHORITY
ENVIRONMENTAL SERVICES DIVISION
P.O. BOX PPB, TAFUNA, PAGO PAGO, AS 96799

PROJECT NAME:

VAITOGI WATERLINE REPLACEMENT PROJECT

DRAWING TITLE:

BACTERIOLOGICAL SAMPLING STATION & DETAILS

PROJECT LOCATION:

VAITOGI VILLAGE, AMERICAN SAMOA

SCALE:

NTS

DATE:	
-------	--

7-2022




 



SHEET NO.

D05



PROJECT NO:

SIGNATURE:

DATE: _____

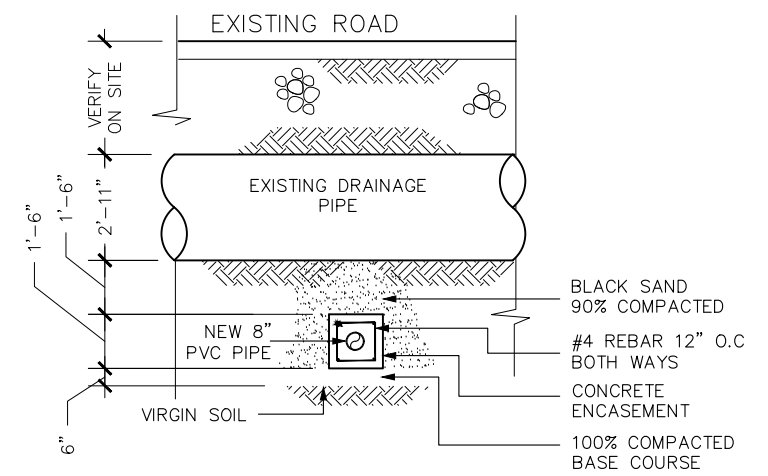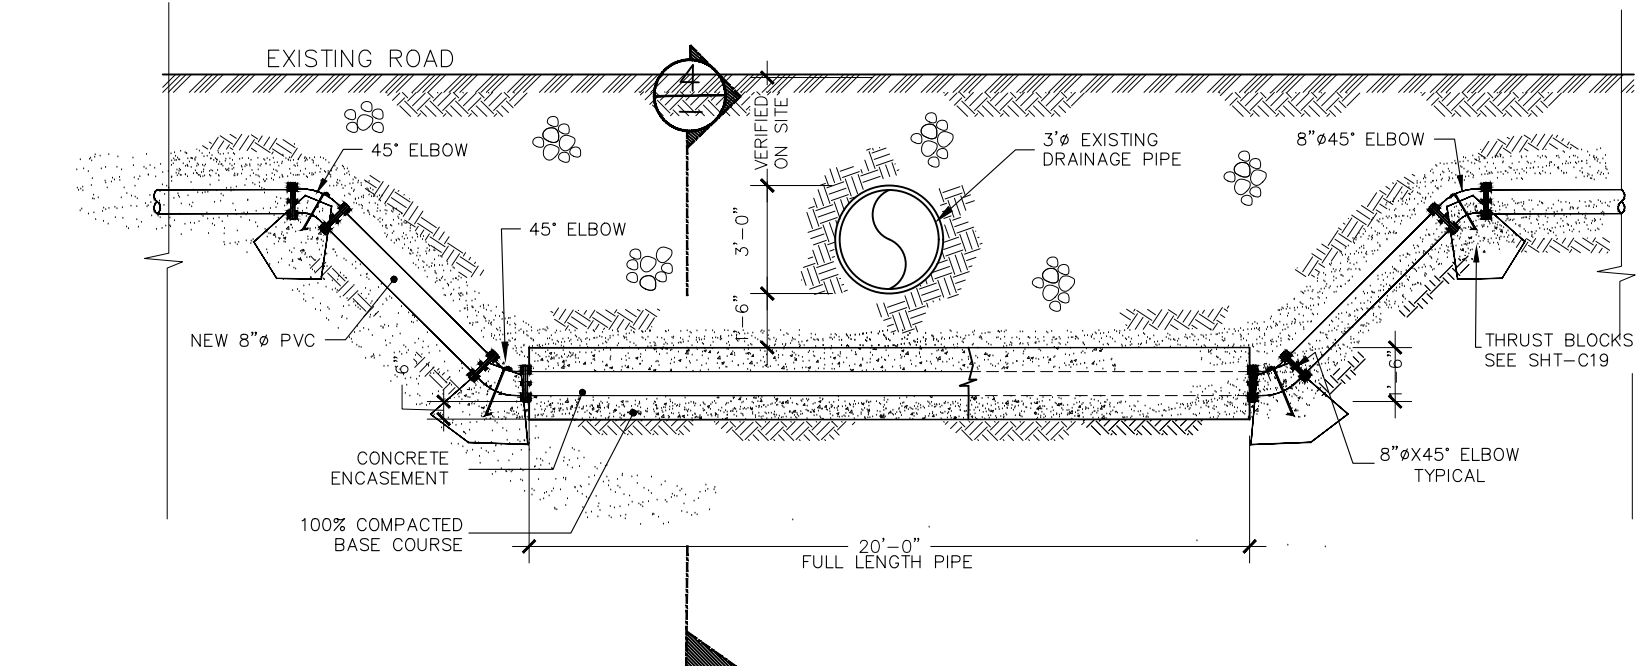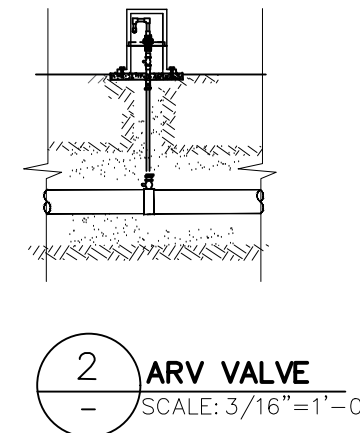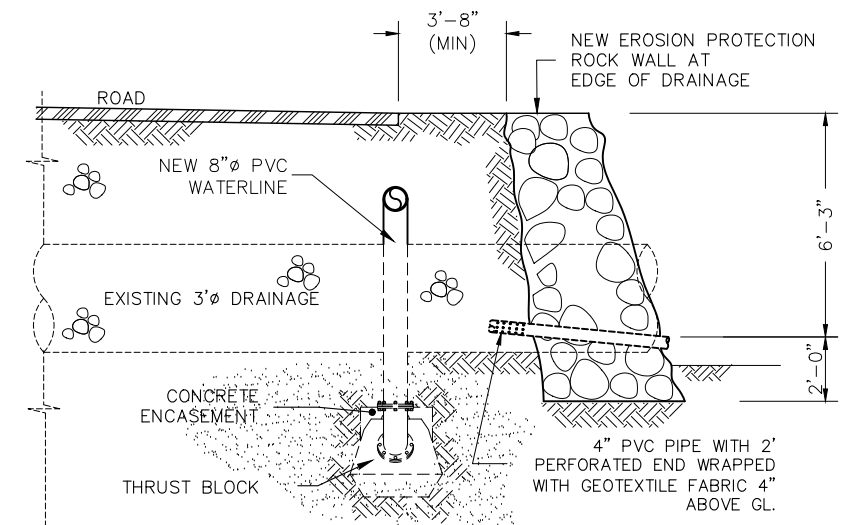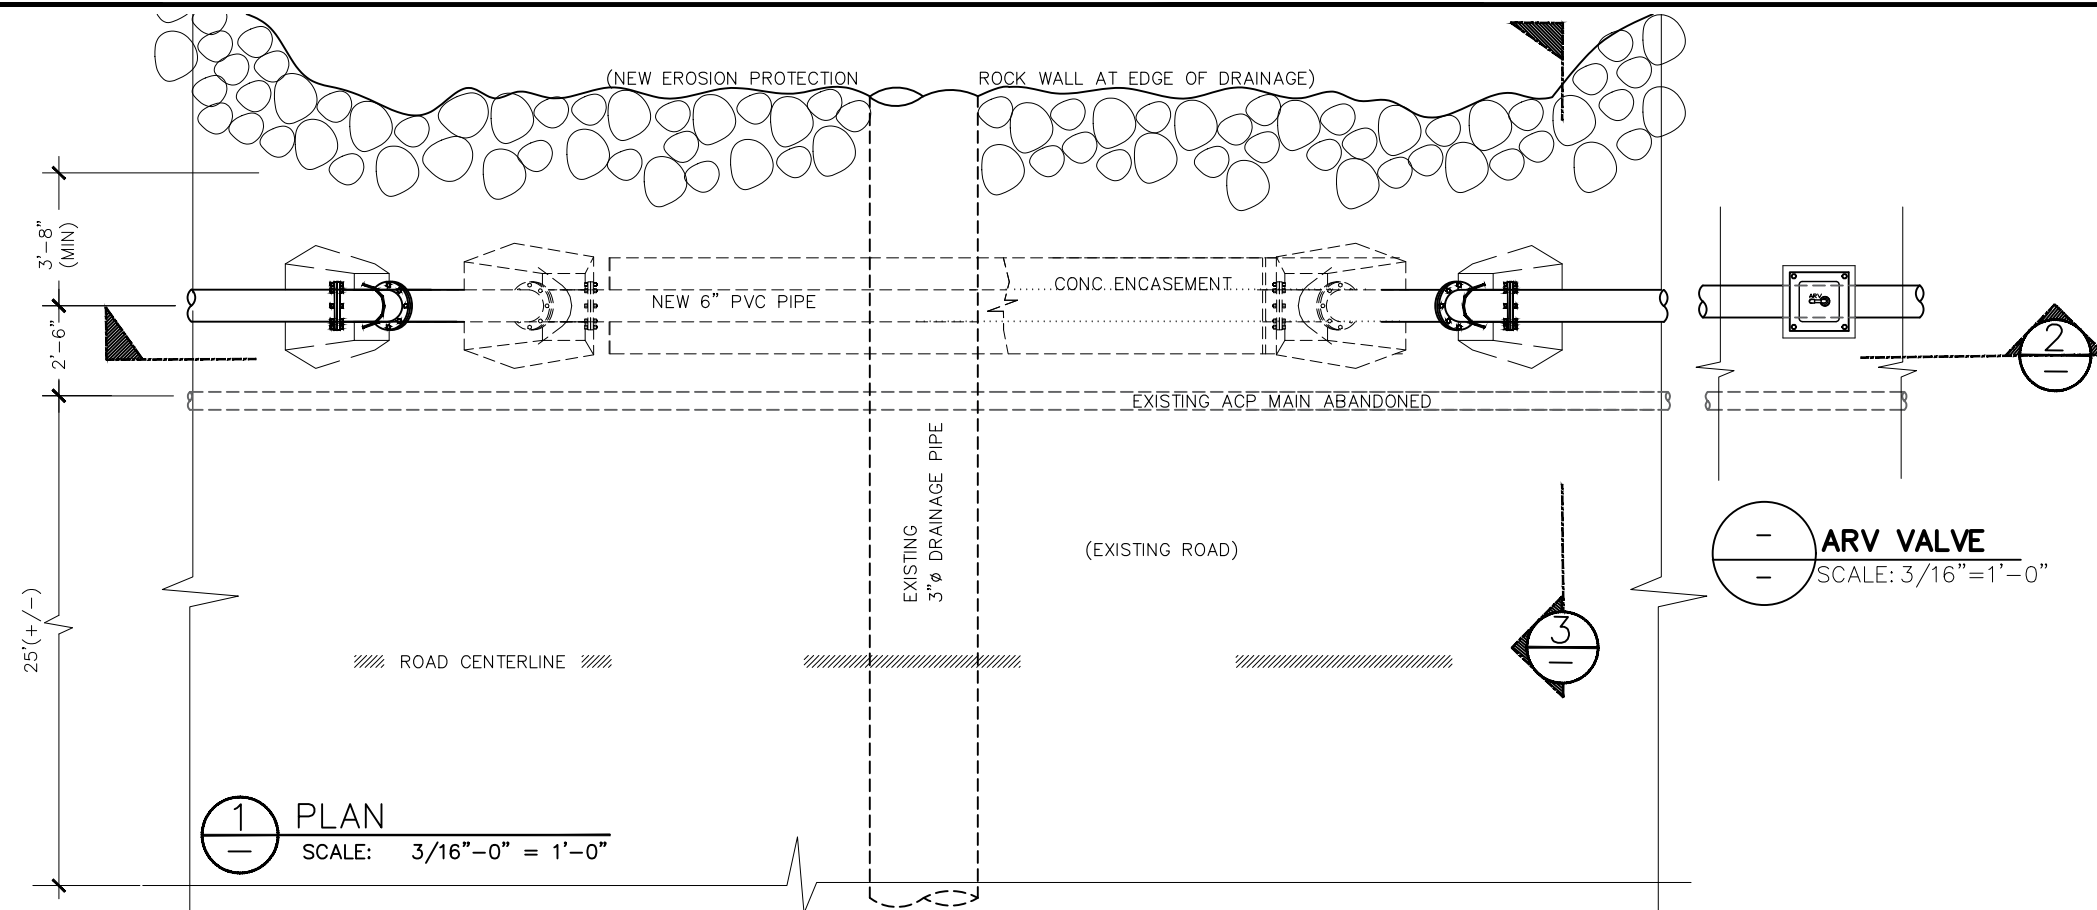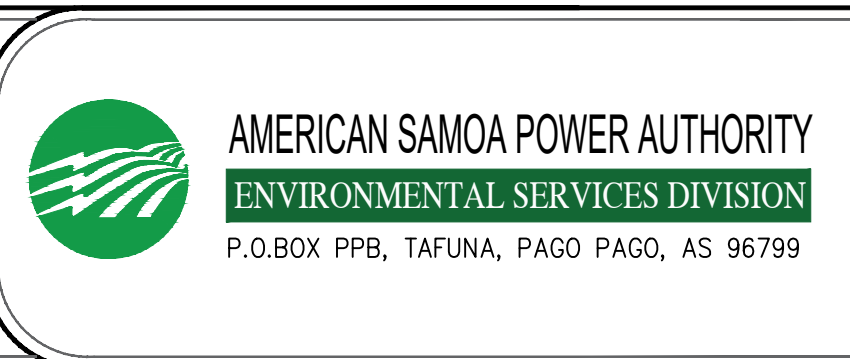[illegible]










PROJECT NAME: VAITOGI WATERLINE REPLACEMENT PROJECT		SCALE: AS SHOWN		PROJECT NO: 	
DRAWING TITLE: TYPICAL MAIN ROAD DRAINAGE CROSSING SECTIONS & DETAILS		DATE: 7-2022	SIGNATURE: DATE:		
PROJECT LOCATION: VAITOGI VILLAGE, AMERICAN SAMOA		SHEET NO. D07			

  

PREPARED BY:	F.Toala.
CHECKED BY:	L.Tyrell
APPROVED BY:	F.Aquila
ISSUE FOR:	Construction



SCALE:		PROJECT NO:	
AS SHOWN			
DATE:			
7-2022			
SHEET NO.		SIGNATURE:	
D08		DATE:	

  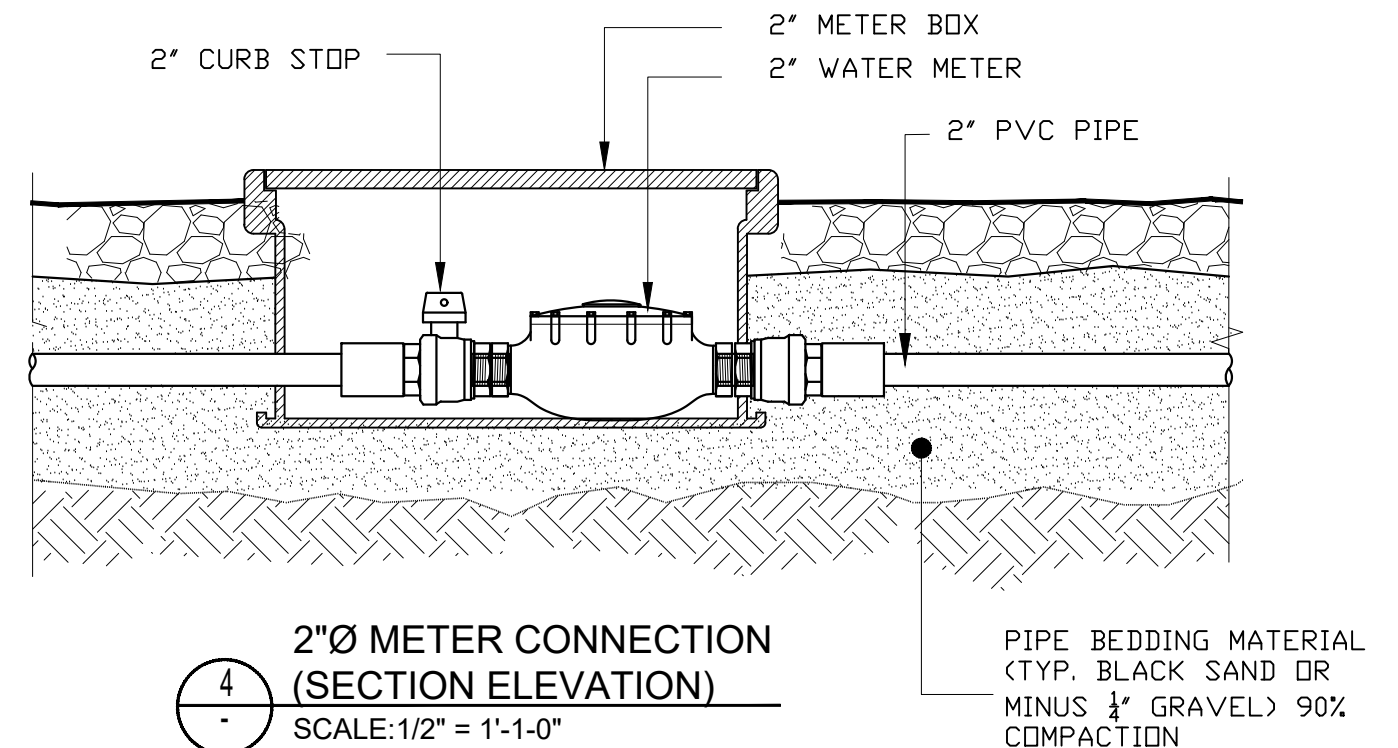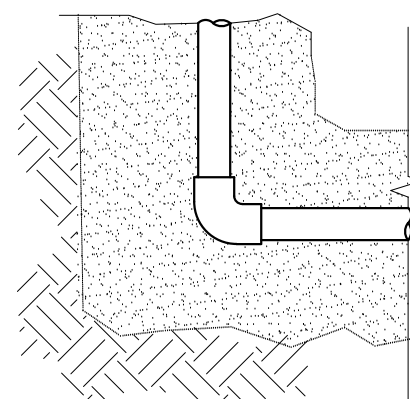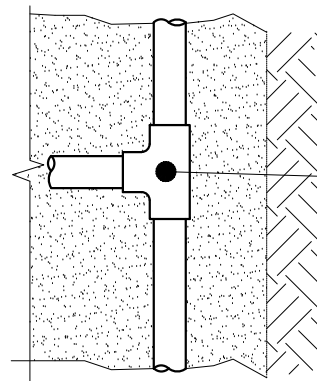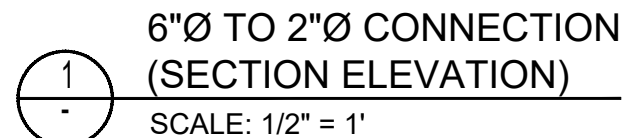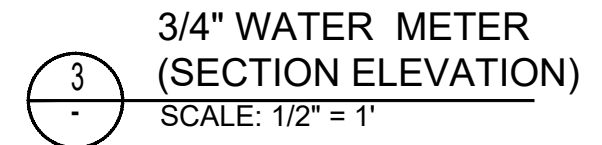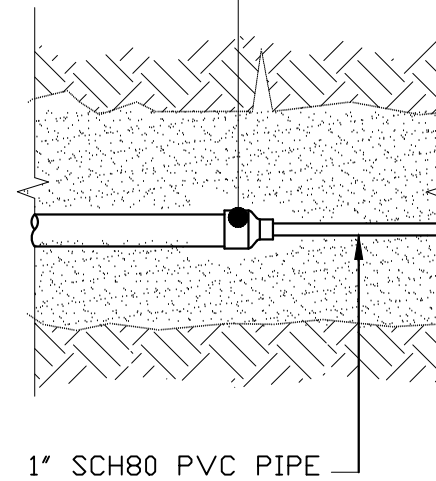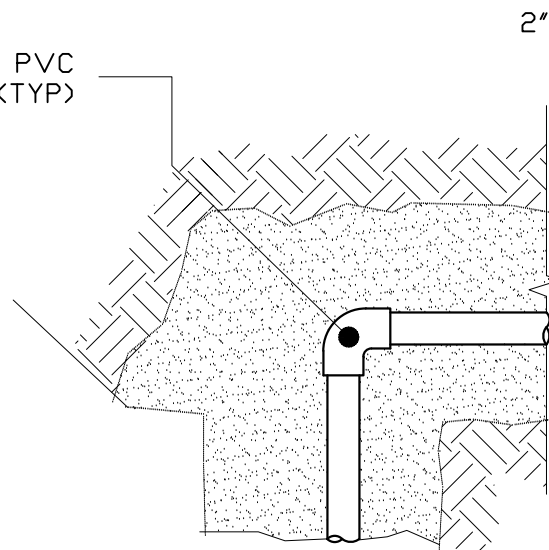

AMERICAN SAMOA POWER AUTHORITY
ENVIRONMENTAL SERVICES DIVISION
P.O. BOX PPB, TAFUNA, PAGO PAGO, AS 96799

VAITOGI WATERLINE REPLACEMENT PROJECT

TYPICAL PVC PIPE SERVICE LINE LAYOUT & CONNECTION DETAILS

VAITOGI VILLAGE, AMERICAN SAMOA

AS SHOWN

 

7-2022

SHEET NO.


D09

SIGNATURE:

DATE: _____

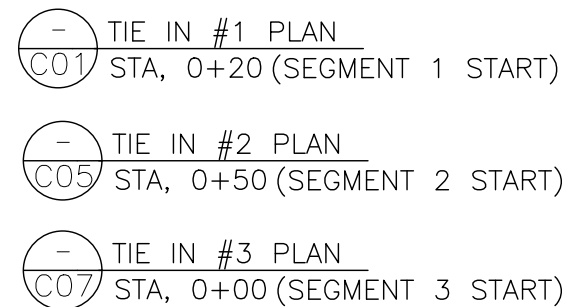

DATE: _____

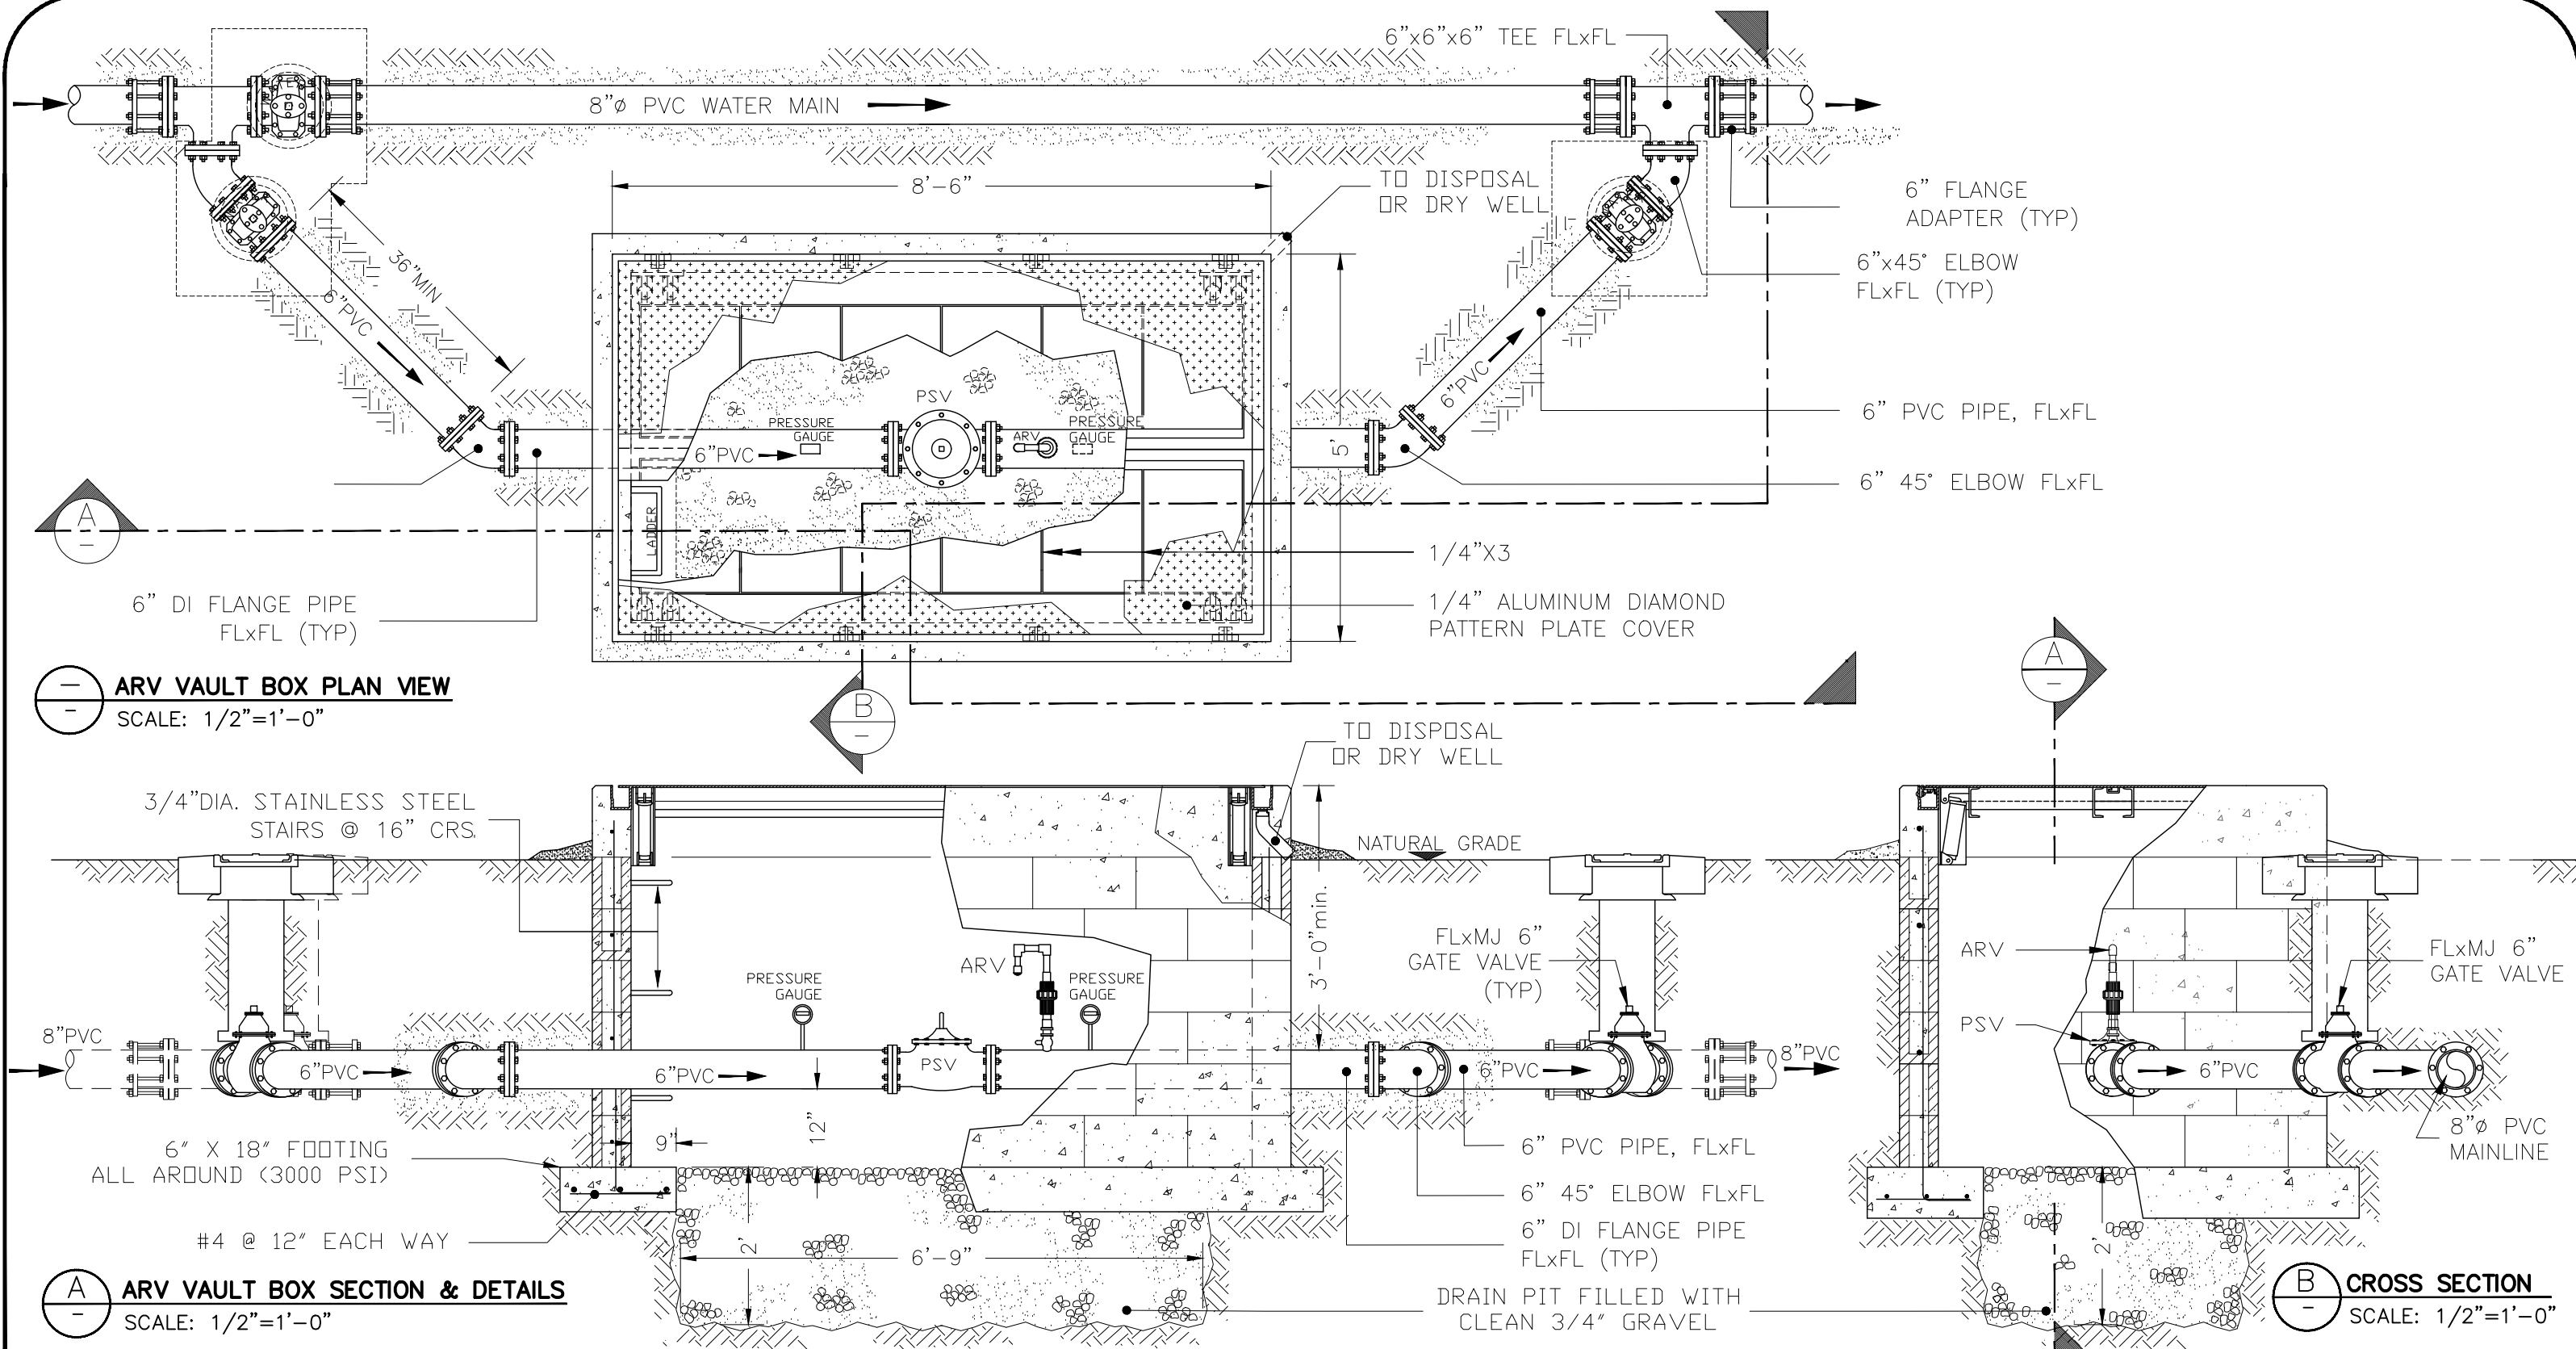

No.	Description	Date

REV. NO.:	
REVISION:	
CHECKED BY:	
APPROVED BY:	
DATE:	

PREPARED BY:	F.Toala.
CHECKED BY:	L.Tyrell
APPROVED BY:	F.Aquila
ISSUE FOR:	Construction



AMERICAN SAMOA POWER AUTHORITY
ENVIRONMENTAL SERVICES DIVISION
P.O.BOX PPB, TAFUNA, PAGO PAGO, AS 96799

PROJECT NAME:	VAITOGI WATERLINE REPLACEMENT PROJECT
DRAWING TITLE:	AIR RELIEF VALVE VAULT SECTION DETAIL
PROJECT LOCATION:	VAITOGI VILLAGE, AMERICAN SAMOA

SCALE:	AS SHOWN	PROJECT NO:	
DATE:	7-2022	SIGNATURE:	
SHEET NO.	D11	DATE:	

- EROSION AND TEMPORARY DUST CONTROL
1. DURING CONSTRUCTION, PREVENTIVE MAINTENANCE MEASURES SHALL BE USED TO CONTROL FORESEEABLE DUST, EROSION OR SEDIMENTATION PROBLEMS WHICH MAY ARISE AS THE JOB PROGRESSES.
 2. FUGITIVE DUST AND SOLID WASTE DISPOSAL DURING GRUBBING ACTIVITIES SHALL MEET REQUIREMENTS OF ADMINISTRATIVE RULES, TITLE II, CHAPTER 60, AIR POLLUTION CONTROL AND CHAPTER 58, SOLID WASTE MANAGEMENT CONTROL.
 3. THE CONTRACTOR AT HIS OWN EXPENSE, SHALL KEEP THE PROJECT AREA AND SURROUNDING AREA FREE FROM DUST NUISANCE. THE WORK SHALL BE IN CONFORMANCE WITH THE AIR POLLUTION CONTROL STANDARDS AND REGULATIONS OF THE STATE DEPARTMENT OF HEALTH.
 4. WHERE CONSTRUCTION ACTIVITY ON A PORTION OF THE SITE IS TEMPORARILY CEASED, AND EARTH DISTURBING ACTIVITIES WILL BE RESUMED WITHIN 14 DAYS, TEMPORARILY STABILIZATION MEASURES DO NOT HAVE TO BE INITIATED ON THAT PORTION OF THE SITE. ALL EXPOSED AREAS TO BE LEFT EXPOSED FOR LONGER THAN FOURTEEN (14) DAYS SHALL BE HYDROMULCH SEEDED WITH RYE GRASS.
 5. ALL SLOPES AND EXPOSED AREAS SHALL BE SODDED OR PLANTED AS SOON AS FINAL GRADES HAVE BEEN ESTABLISHED. PLANTING SHALL NOT BE DELAYED UNTIL ALL GRADING WORKS HAS BEEN COMPLETED. GRADING TO FINAL GRADE SHALL BE CONTINUOUS, AND ANY AREA WITHIN WHICH WORK HAS BEEN INTERRUPTED OR DELAYED SHALL BE PLANTED.


BEST MANAGEMENT PRACTICE NOTES

1. MEASURES TO CONTROL EROSION AND OTHER POLLUTANTS SHALL BE IN PLACE BEFORE ANY WORK IS INITIATED. THESE MEASURES SHALL BE PROPERLY CONSTRUCTED AND MAINTAINED THROUGHOUT THE CONSTRUCTION PERIOD.
2. ALL TEMPORARY EROSION CONTROL MEASURES SHALL BE CHECKED AND REPAIRED AS NECESSARY.
3. GRASSING OR MULCHING OF EXPOSED AREAS TO BE DONE AS FINISH GRADES ARE ESTABLISHED.
4. DIVERSION OF STORM RUNOFF AWAY FROM THE FILL SLOPES UNTIL GRASSING ON THE FILL SLOPES ARE ESTABLISHED.
5. PROVIDE STABILIZED CONSTRUCTION ENTRANCE.

NOTES:

1. STABILIZED CONSTRUCTION ENTRANCE SHALL BE MAINTAINED AT THE EGRESS AND INGRESS TO THE SITE. TIRE WASH MAY BE USED IN LIEU OF STABILIZED CONSTRUCTION ENTRANCE. CONTRACTOR IS RESPONSIBLE TO KEEP ROADWAYS CLEAN FROM SOIL AND CONSTRUCTION DEBRIS.
2. DUST CONTROL SHOULD BE APPLIED TO REDUCE DUST EMISSIONS. WATER THE AREA DURING CONSTRUCTION TO CONTROL DUST.
3. ALL STORM DRAIN INLETS ON SITE AND THOSE OFF SITE WHICH MAY RECEIVE RUN OFF FROM THE SITE SHALL USE AN INLET PROTECTION DEVICE.

	CONSTRUCTION ENTRANCE	(CE)
	SILT FENCE	(SF)
	DIVERSION DIKE	(DD)
	RIGHT-OF-WAY DIVERSION	(RWD)
	TEMPORARY LEVEL SPREADER	(LS)
	TEMPORARY LEVEL DIVERSION	(LD)
	TEMPORARY FILL DIVERSION	(TFD)
	INLET PROTECTION	(IP)
	EC-2 MATTING	(B/M)
	EC-3 MATTING	(B/M)
	EXISTING TREELINE	
	EXISTING WATERS	
	EXISTING 100' STREAM BUFFER	
	PROPOSED TREELINE	
	PROPOSED GRADING	
	SEDIMENT BASIN DRAINAGE AREA	
	PEA GRAVEL LEVEL SPREADER	
	PEA GRAVEL LEVEL SPREADER	
	LIMIT OF DISTURBANCE	
	NOTE: DUST CONTROL MEASURES ARE TO BE USED ONSITE AS NECESSARY THROUGHOUT THE CONSTRUCTION ACTIVITY	

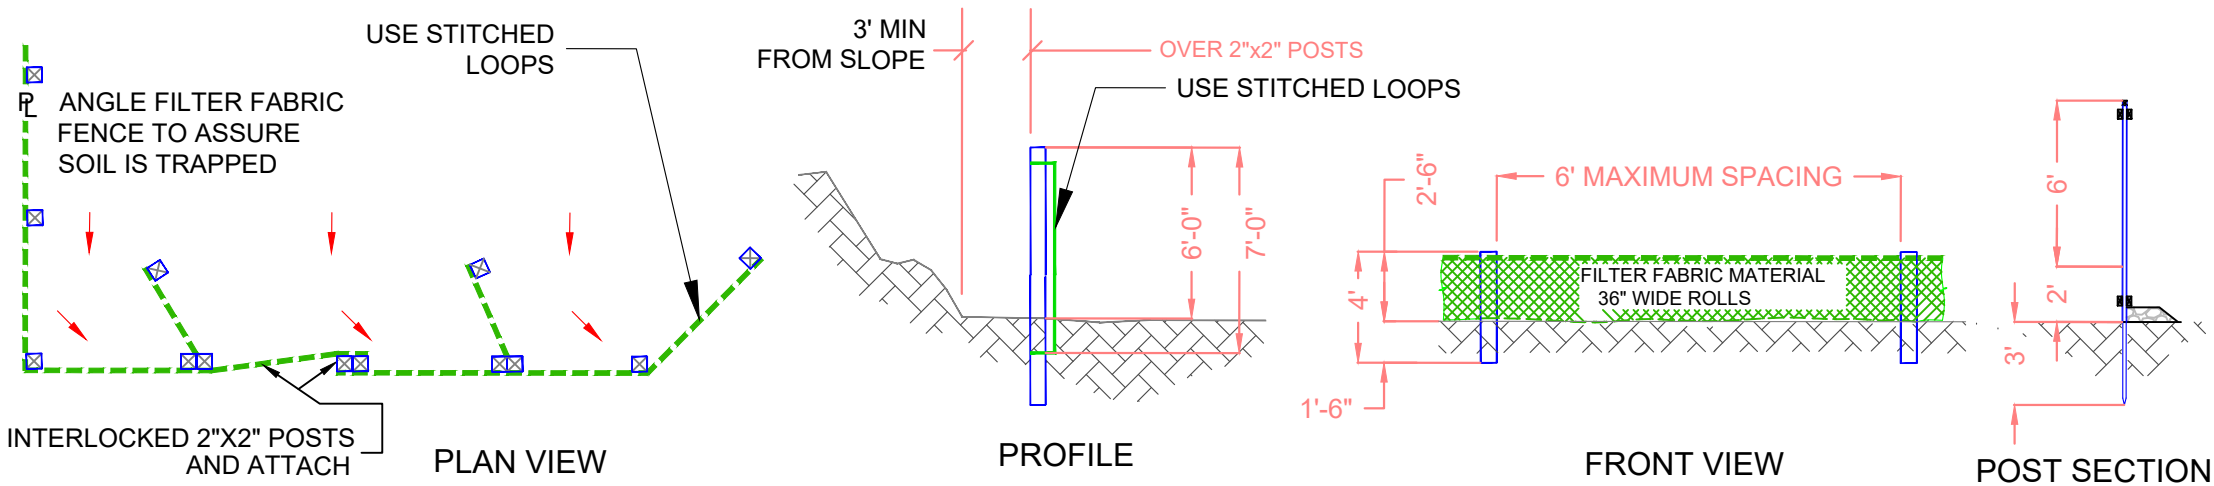

NOTES:

1. BURY BOTTOM OF FILTER FABRIC 6" VERTICALLY BELOW FINISHED GRADE.
2. 2"X2" FIR, PINE OR STEEL FENCE POSTS.
3. POSTS TO BE INSTALLED ON UPHILL SIDE OF SLOPE.
4. COMPACT BOTH SIDES OF FILTER FABRIC TRENCH.
5. PANELS MUST BE PLACED ACCORDING TO SPACING ON DETAIL NO.940

No.	Description	Date

REV. NO.:
REVISION:
CHECKED BY:
APPROVED BY:
DATE:

PREPARED BY:	F.Toala.
CHECKED BY:	L.Tyrell
APPROVED BY:	F.Aquila
ISSUE FOR:	Construction




AMERICAN SAMOA POWER AUTHORITY
ENVIRONMENTAL SERVICES DIVISION
P.O.BOX PPB, TAFUNA, PAGO PAGO, AS 96799

PROJECT NAME:	VAITOGI WATERLINE REPLACEMENT PROJECT
DRAWING TITLE:	EROSION AND SEDIMENTATION CONTROL GENERAL NOTES, CONSTRUCTION SITE SIGNS & SYMBOLS DEFINITIONS.
PROJECT LOCATION:	VAITOGI VILLAGE, AMERICAN SAMOA

SCALE:	SCALE TO FIT	PROJECT NO:
DATE:	OCT-22	
SHEET NO.	ESC-1	SIGNATURE:
		DATE:



MAP OF TUTUILA
AMERICAN SAMOA

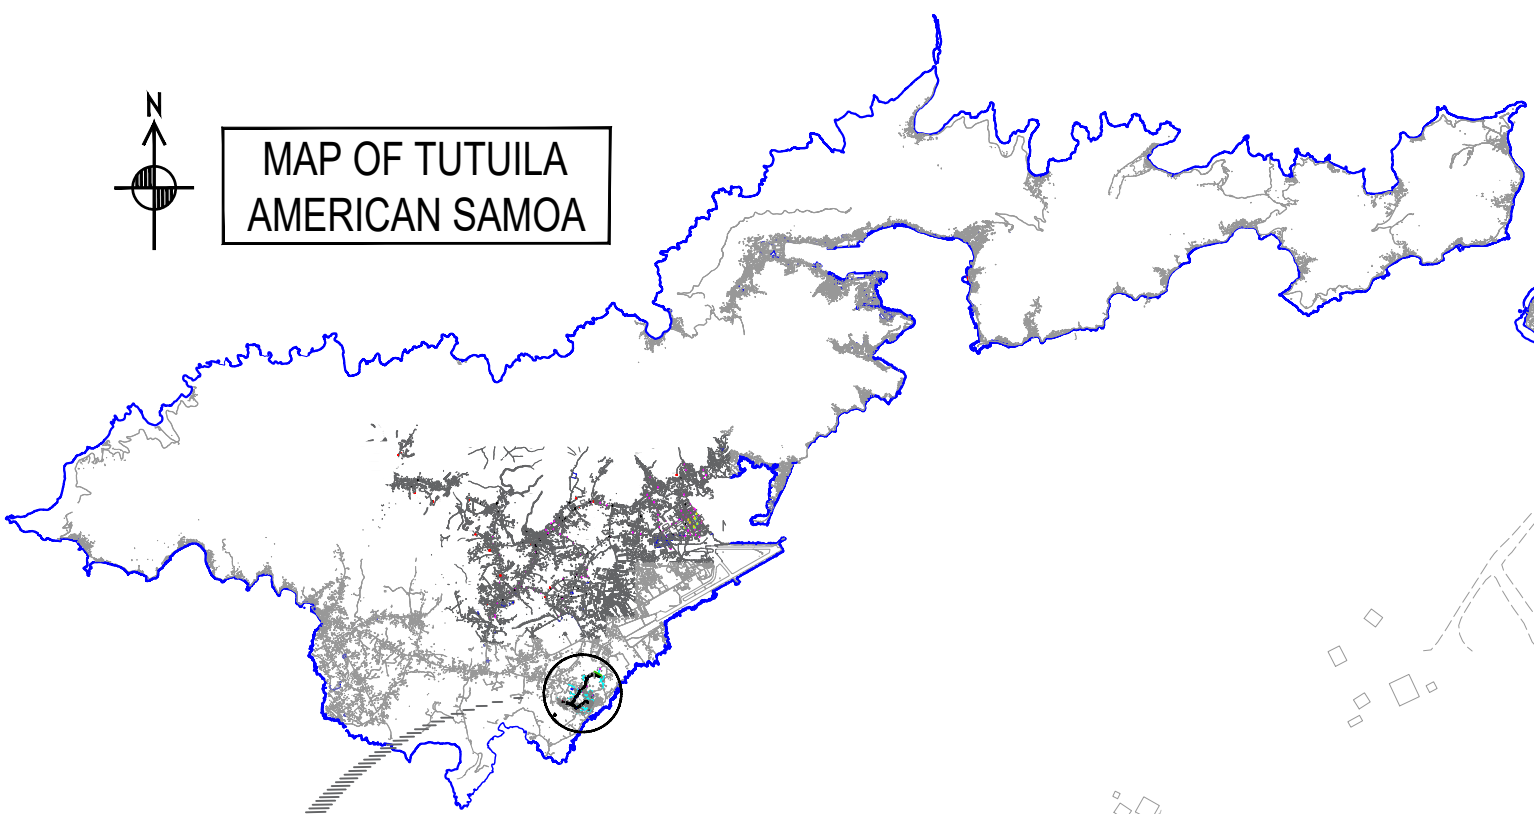

PROJECT LOCATION
SCALE TO FIT



END OF
SEGMENT 1

SEGMENT 2

START OF
SEGMENT 2

END OF
SEGMENT 2

START OF
SEGMENT 3

SEGMENT 3

END OF
SEGMENT 3

SHT ESC-3

SEGMENT 1

SHT ESC-4

SHT ESC-5

(STA. 0+00 TO STA. 18+63)

(STA. 0+00 TO STA. 17+60)

(STA. 0+00 TO STA. 20+00)

SHT-C09

SHT-C10

SHT-C07

SHT-C08

SHT-C01

SHT-C02

SHT-C03

SHT-C04

SHT-C05

SHT-C06

VAITOGI

2" GIP

No.	Description	Date

REV. NO.:
REVISION:
CHECKED BY:
APPROVED BY:
DATE:

PREPARED BY: F.Toala.
CHECKED BY: L.Tyrell
APPROVED BY: F.Aquila
ISSUE FOR: Construction




AMERICAN SAMOA POWER AUTHORITY
ENVIRONMENTAL SERVICES DIVISION
P.O.BOX PPB, TAFUNA, PAGO PAGO, AS 96799

PROJECT NAME: VAITOGI WATERLINE REPLACEMENT PROJECT
DRAWING TITLE: EROSION AND SEDIMENTATION CONTROL (VICINITY MAP)
PROJECT LOCATION: VAITOGI VILLAGE, AMERICAN SAMOA

SCALE: SCALE TO FIT	PROJECT NO.:
DATE: OCT-22	SIGNATURE:
SHEET NO. ESC-2	DATE:

NOTE:
REFER TO SHEET ESC-1
FOR NOTES, SIGNS &
SYMBOL DEFINITIONS

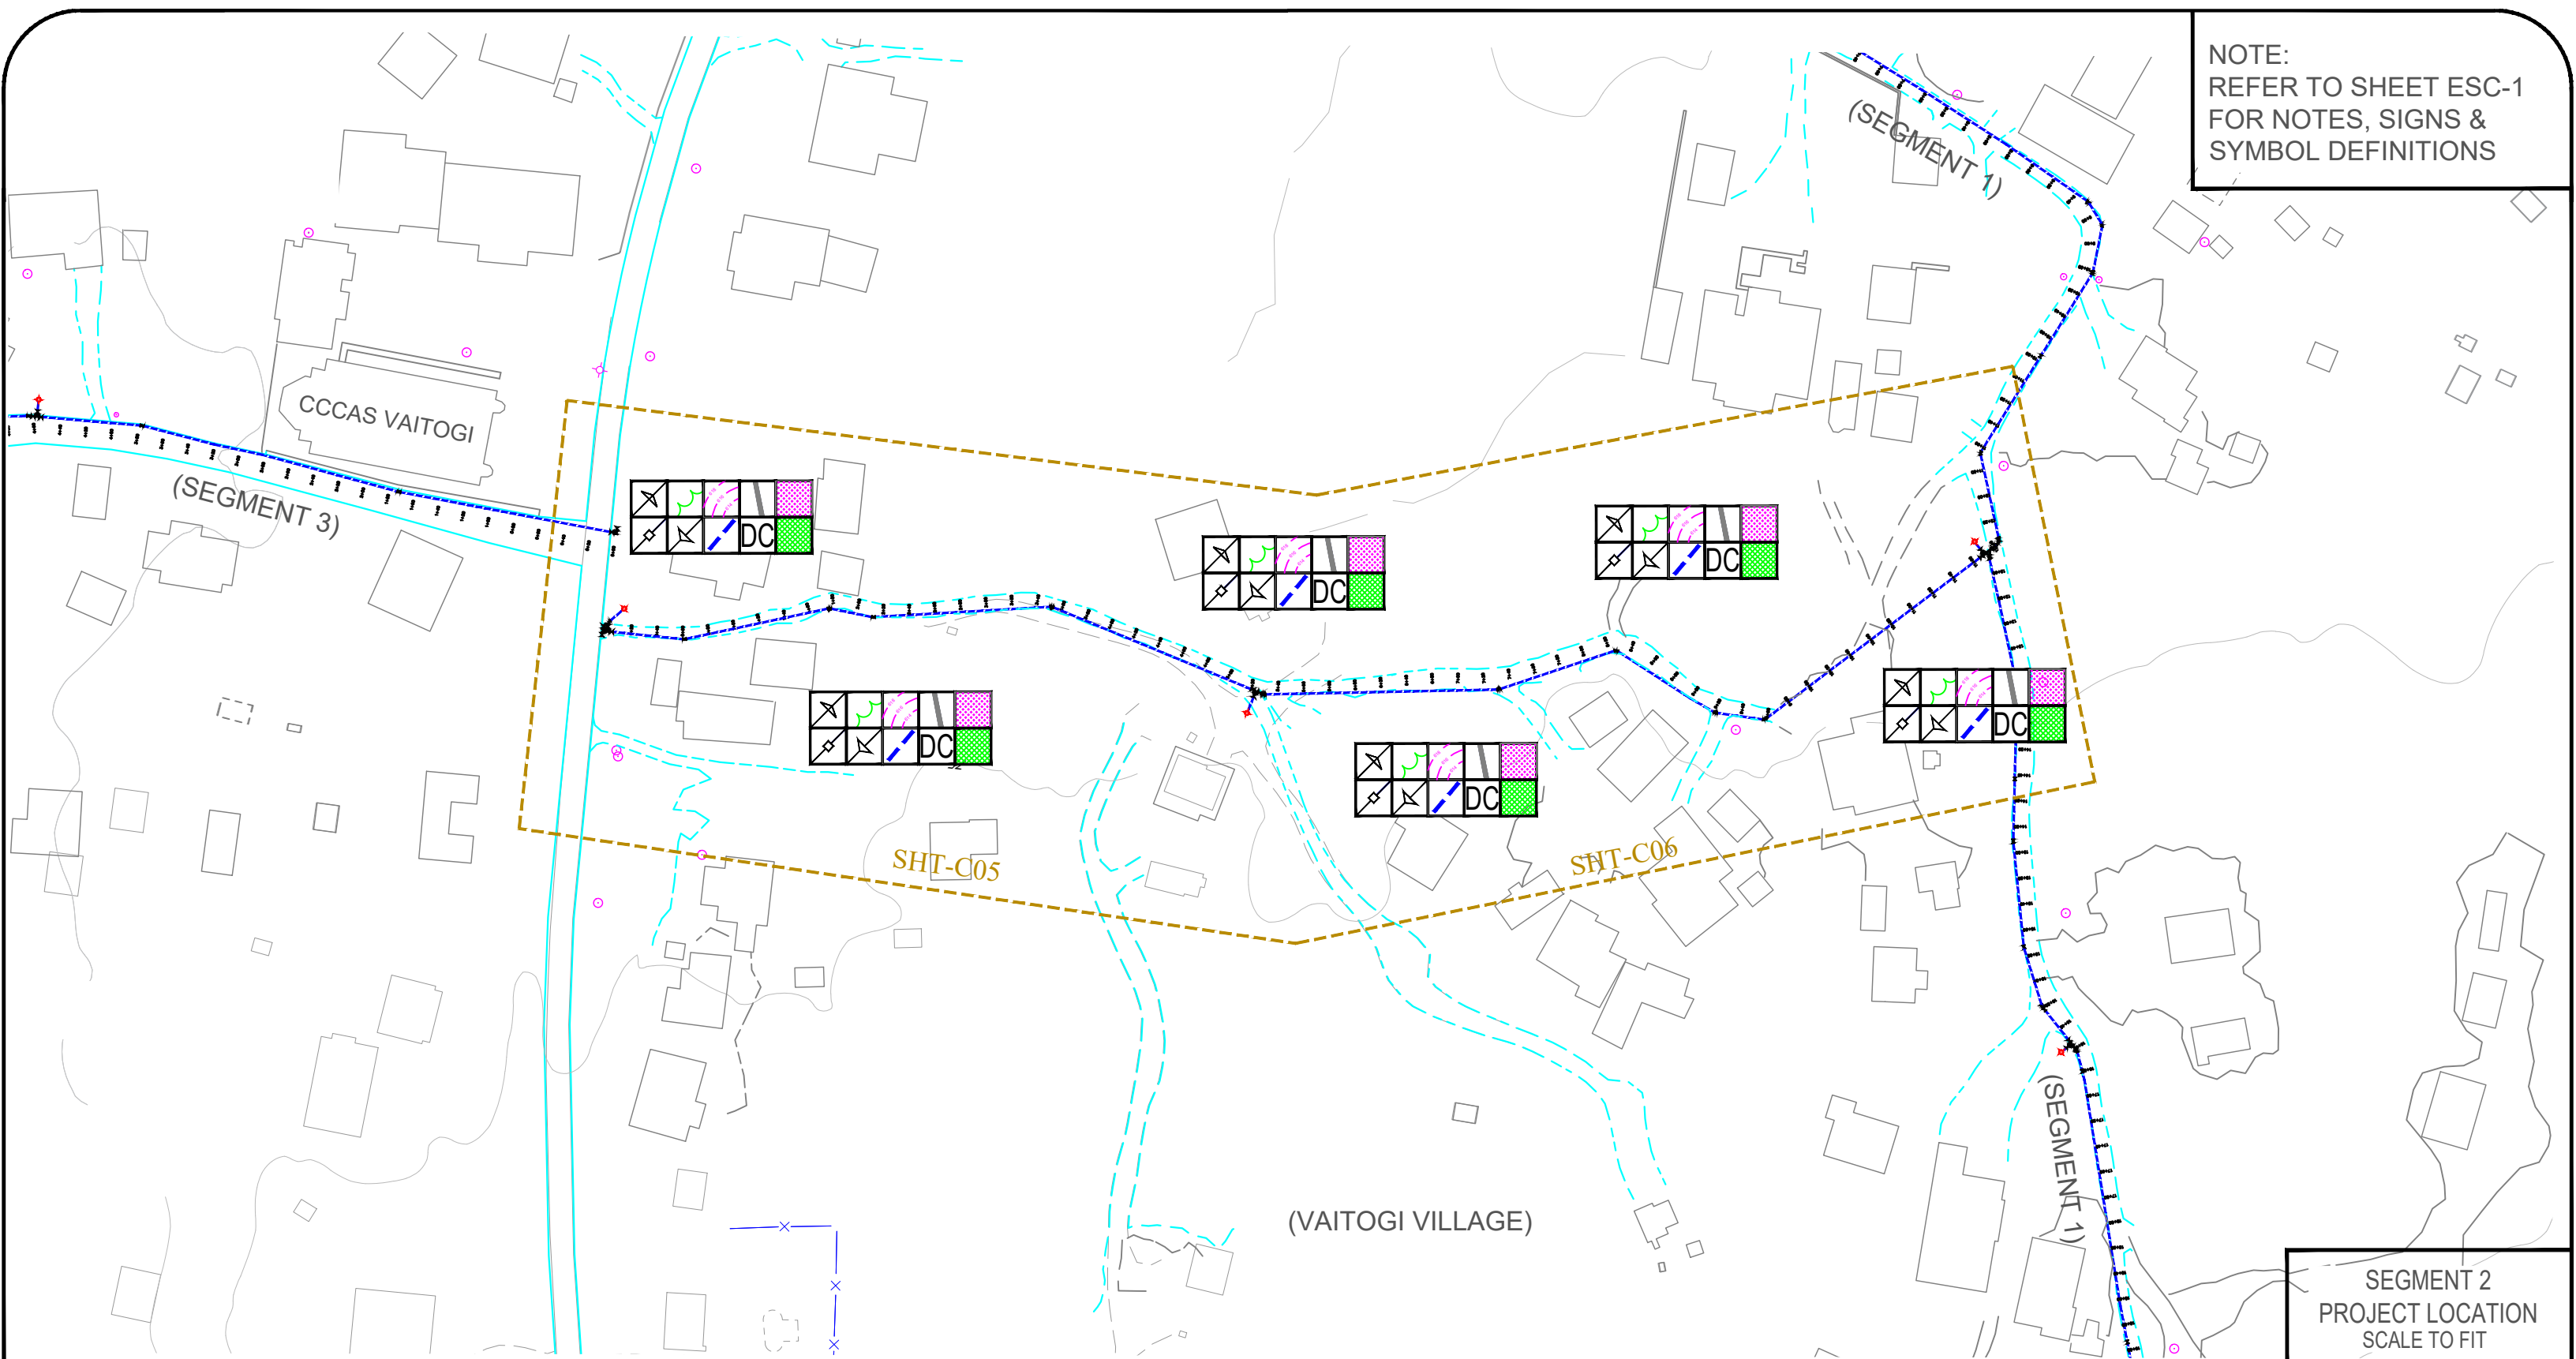

SEGMENT 2
PROJECT LOCATION
SCALE TO FIT

No.	Description	Date

REV. NO.:	PREPARED BY: F.Toala.
REVISION:	CHECKED BY: L.Tyrell
CHECKED BY:	APPROVED BY: F.Aquila
APPROVED BY:	ISSUE FOR: Construction
DATE:	



AMERICAN SAMOA POWER AUTHORITY

ENVIRONMENTAL SERVICES DIVISION

P.O.BOX PPB, TAFUNA, PAGO PAGO, AS 96799

PROJECT NAME: VAITOGI WATERLINE REPLACEMENT PROJECT
DRAWING TITLE: SEGMENT 2, EROSION AND SEDIMENTATION CONTROL (STA. 0+00 TO STA. 11.80)
PROJECT LOCATION: VAITOGI VILLAGE, AMERICAN SAMOA




SCALE: SCALE TO FIT	PROJECT NO.:
DATE: OCT 22	SIGNATURE:
SHEET NO. ESC-4	
	DATE:

VAITOGI WATERLINE REPLACEMENT PROJECT

TUTUILA ISLAND, AMERICAN SAMOA.

SHEET #		DESCRIPTION				ABBREVIATIONS:			
G1		VICINITY MAP, LOCATION PLAN				@	AT	PROP	PROPOSED
G2		TABLE OF CONTENTS. ABBREVIATIONS				AFF	ABOVE FINISHED FLOOR	PVC	POLYVINYL CHLORIDE PIPE
G3		LEGEND, GENERAL NOTES				AFG	ABOVE FINISHED GRADE	PE	POLYETHYLENE PIPE
G4		CONSTRUCTION NOTES				AGG	AGGREGATE	ACP	ASBESTOS CEMENT PIPE
						ARV	AIR/VAC RELEASE VALVE	GA	GAUGE
ESC1		VICINITY MAP FOR EROSION AND SEDIMENTATION CONTROL / GENERAL NOTES				AS-EPA	AMERICAN SAMOA ENVIRONMENTAL PROTECTION AGENCY	GALV	GALVANIZED
ESC2		EROSION AND SEDIMENTATION CONTROL & DETAILS				BLDG	BUILDING	GR	GRADE
ESC3		EROSION AND SEDIMENTATION CONTROL				CB	CATCH BASIN	GV	GATEVALVE
						CI	CAST IRON	HB	HOSE BIB
		SEGMENT 1				CL	CENTER LINE	HWY	HIGHWAY
C01		START OF SEGMENT 1, PLAN & PROFILE (STA 0+00 – STA 5+00)				CMP	CORRUGATED METAL PIPE	ID	INSIDE DIAMETER
C02		SEGMENT 1, PLAN & PROFILE (STA 5+00 – STA 10+00)				CO	CLEAN OUT	INSUL	INSULATION
C03		SEGMENT 1, PLAN & PROFILE (STA 10+00 – STA 15+00)				CONC	CONCRETE	INV	INVERT
C04		END OF SEGMENT 1, PLAN & PROFILE (STA 15+00 – STA 20+00)				CP	CONTROL POINT	IR	IRON ROD
						DET	DETAIL	JT	JOINT
		SEGMENT 2				DIA	DIAMETER	LT	LEFT
C05		START OF SEGMENT 2, PLAN & PROFILE (STA 0+00 – STA 5+60)				DIM	DIMENSION	M	METER
C06		END OF SEGMENT 2, PLAN & PROFILE (STA 5+60 – STA 11+80)				DIP	DUCTILE IRON PIPE	MANUF	MANUFACTURED
						DW	DRIVEWAY	MAX	MAXIMUM
		SEGMENT 3				E	EAST	MFR	MANUFACTURER
C07		START OF SEGMENT 3, PLAN & PROFILE (STA 0+00 – STA 4+80)				ELEV	ELEVATION	MH	MANHOLE
C08		SEGMENT 3, PLAN & PROFILE (STA 4+80 – STA 9+60)				ELEC	ELECTRICAL	MIN	MINIMUM
C09		SEGMENT 3, PLAN & PROFILE (STA 9+60 – STA 14+40)				EOL	END OF LINE	MISC	MISCELLANEOUS
C10		END OF SEGMENT 3, PLAN & PROFILE (STA 14+40 – STA 19+00)				EOP	EDGE OF PAYMENT	(N)	NEW
						EQ	EQUAL	N	NORTH
D01		GATE VALVE, GATE VALVE BOX DETAILS				EXT'G	EXISTING	NIC	NOT IN CONTRACT
D02		AIR RELIEF VALVE DETAILS				EXT	EXTERIOR	NO	NOT OPEN
D03		THRUST BLOCK DETAILS				FD	FLOOR DRAIN	NC	NORMALLY CLOSED
D04		UTILITY CROSSING DETAILS				FH	FIRE HYDRANT	NTS	NOT TO SCALE
D05		BACTERIOLOGICAL SAMPLING STATION DETAILS				FIN	FINISHED	OC	ON CENTER
D06		FIRE HYDRANT DETAILS				FLR	FLOOR	OD	OUTSIDE DIAMETER
D07		TYPICAL MAIN ROAD CROSSING SECTION DETAIL				FND	FOUND	OH	OVERHEAD
D08		TYPICAL ROAD SECTION DETAILS				FT	FEET	OSHA	OCCUPATIONAL SAFETY HEALTH ADMINISTRATION
D09		MAINLINE SUPPLY TO SERVICE LINE CONNECTION				FTG	FOOTING	SC	SERVICE CONNECTION
D10		TIE-IN DETAILS				PL	PROPERTY LINE		
D11		PRESSURE SUSTAINING VALVE DETAILS							

<table><tr><td>No.</td><td>Description</td><td>Date</td></tr><tr><td></td><td></td><td></td></tr><tr><td></td><td></td><td></td></tr><tr><td></td><td></td><td></td></tr><tr><td></td><td></td><td></td></tr></table>	No.	Description	Date													REV. NO.:	PREPARED BY:	 AMERICAN SAMOA POWER AUTHORITY ENVIRONMENTAL SERVICES DIVISION P.O.BOX PPB, TAFUNA, PAGO PAGO, AS 96799	PROJECT NAME:	SCALE:	PROJECT NO.:
	No.	Description	Date																		
REVISION:	CHECKED BY:	CHECKED BY:	VAITOGI WATERLINE REPLACEMENT PROJECT	NTS																	
CHECKED BY:	APPROVED BY:	APPROVED BY:	DRAWING TITLE:	DATE:	SIGNATURE: DATE:																
APPROVED BY:	DATE:	DATE:	TABLE OF CONTENTS & ABBREVIATIONS	7-2022																	
DATE:	DATE:	DATE:	PROJECT LOCATION:	SHEET NO.																	
				G1																	

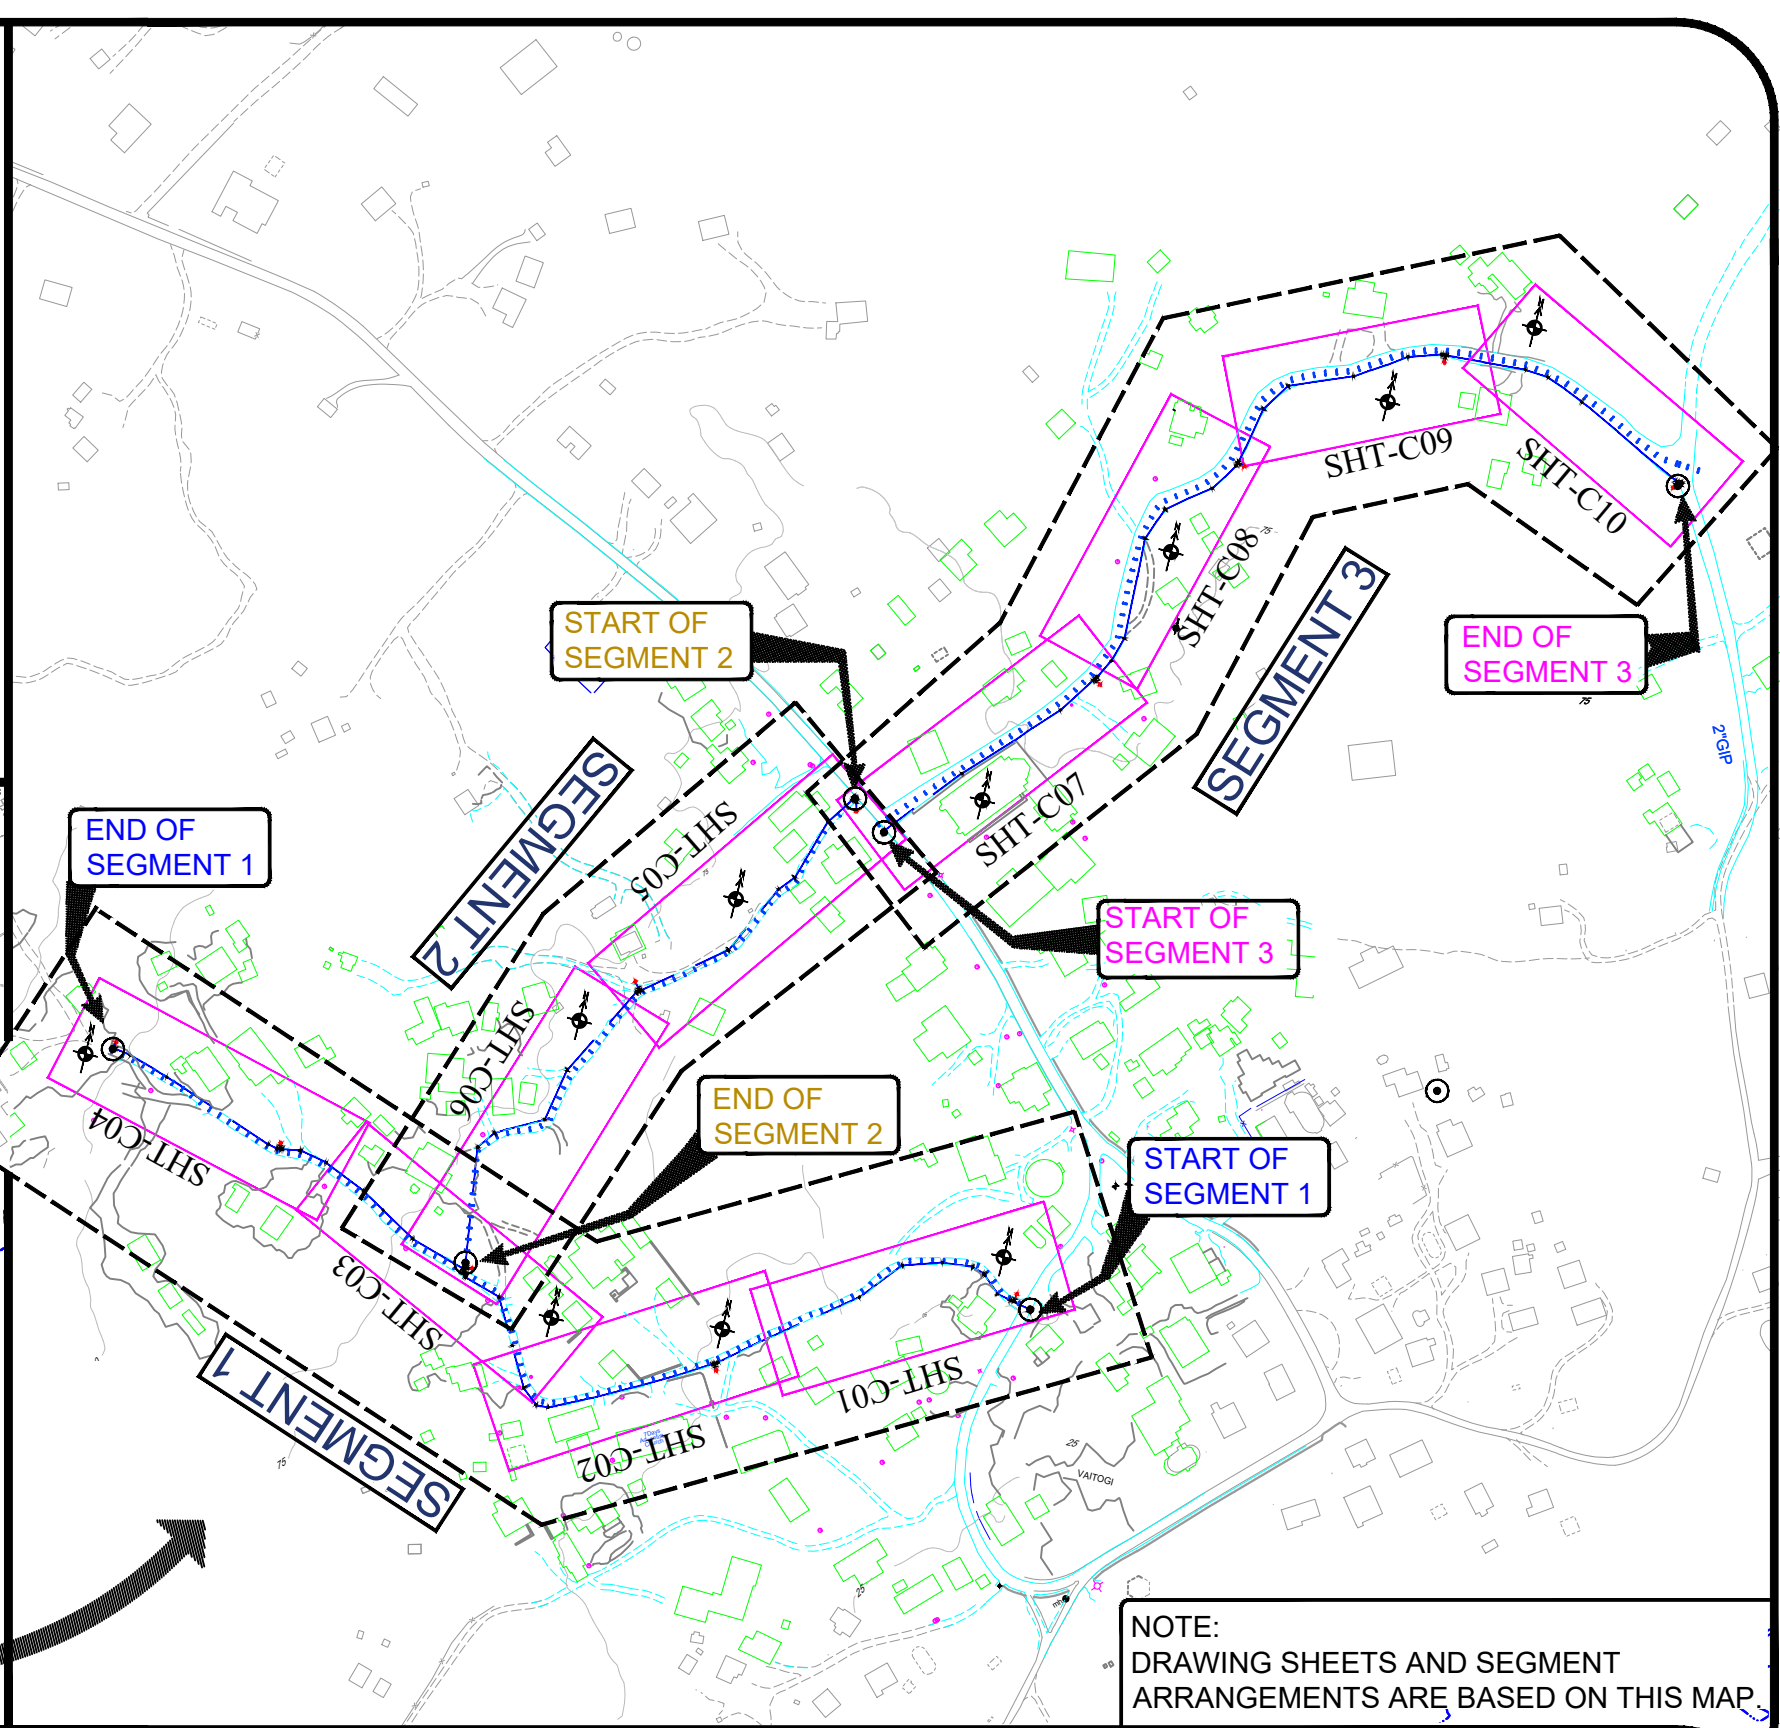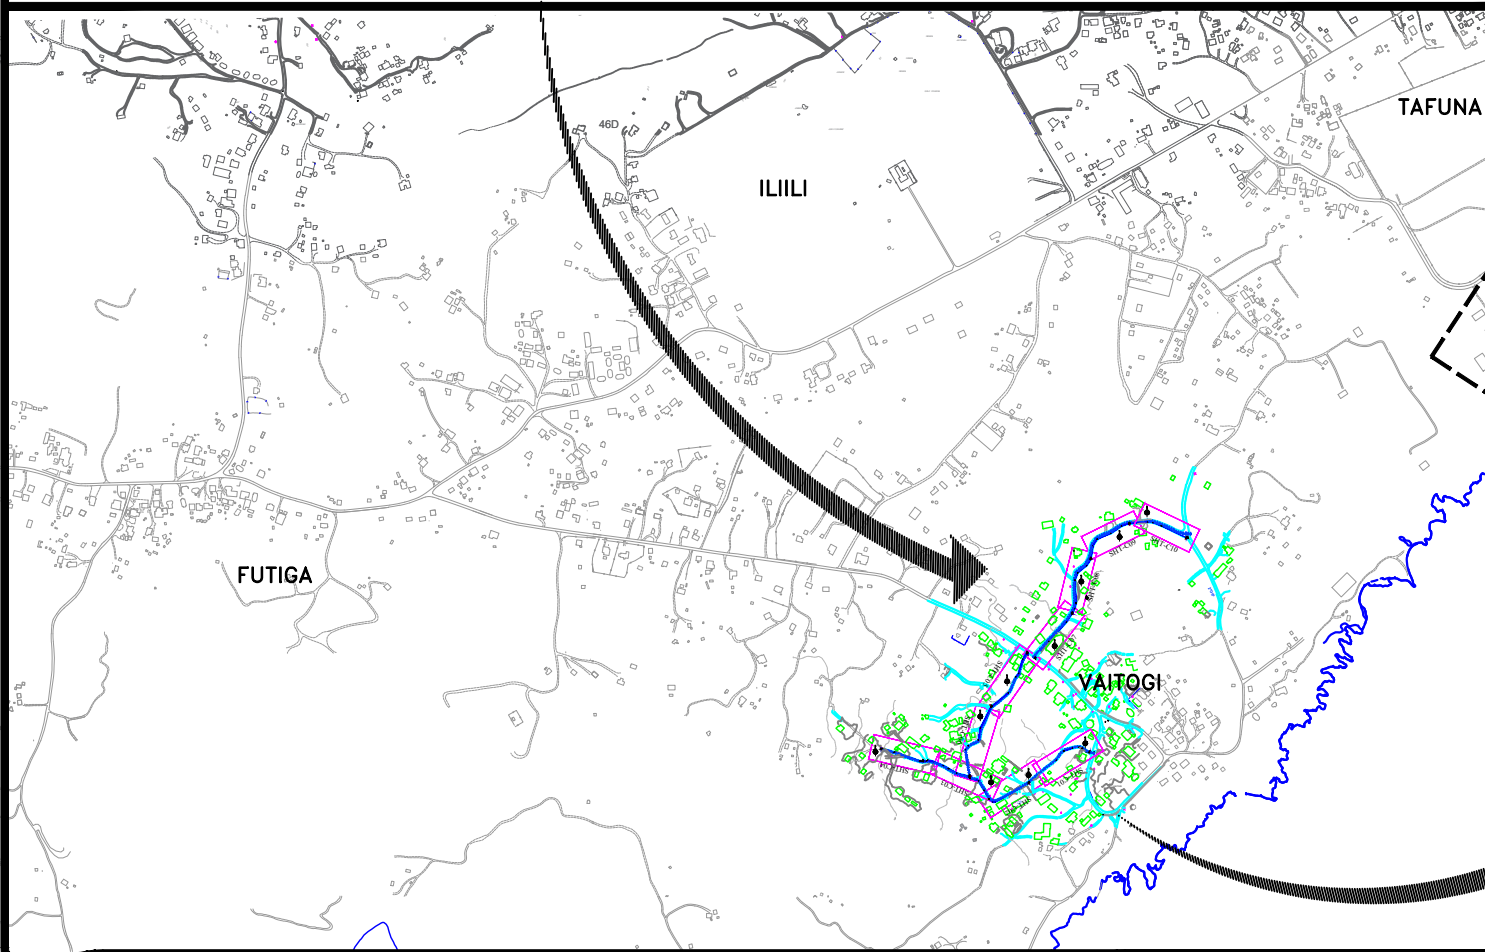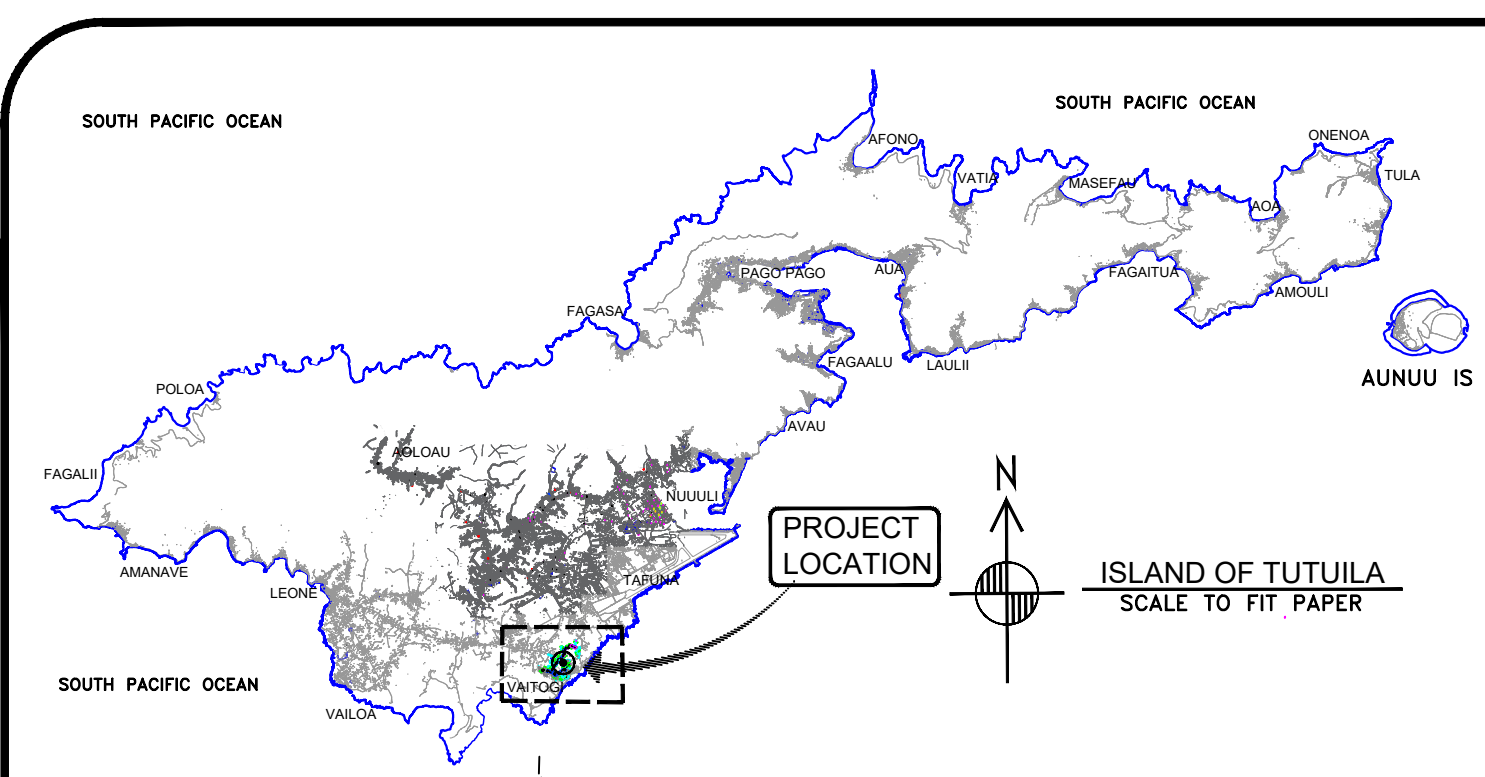

No.	Description	Date

REV. NO.:
REVISION:
CHECKED BY:
APPROVED BY:
DATE:

PREPARED BY:	F.Toala.
CHECKED BY:	L.Tyrell
APPROVED BY:	F.Aquila
ISSUE FOR:	Construction



AMERICAN SAMOA POWER AUTHORITY

ENVIRONMENTAL SERVICES DIVISION


P.O.BOX PPB, TAFUNA, PAGO PAGO, AS 96799

PROJECT NAME:	VAITOGI WATERLINE REPLACEMENT PROJECT
DRAWING TITLE:	VICINITY MAP
PROJECT LOCATION:	VAITOGI VILLAGE, AMERICAN SAMOA

SCALE:	NTS
DATE:	7-2022
SHEET NO.	G2

PROJECT NO:	
SIGNATURE:	
DATE:	

LEGEND:

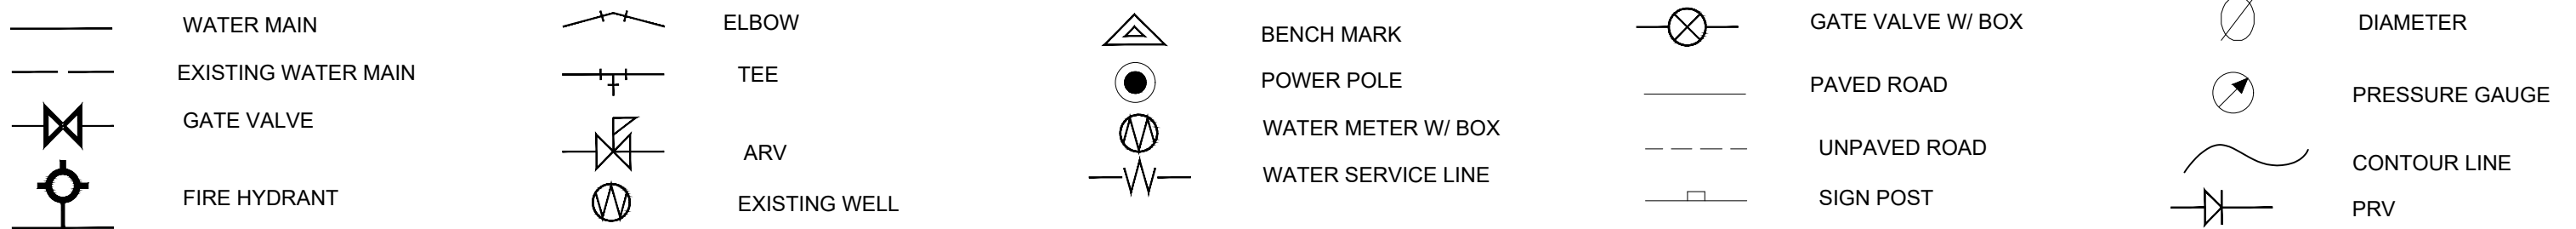

UTILITY GENERAL NOTES:

1. EXISTING WATERLINE LOCATIONS ARE APPROXIMATE. CONTRACTOR SHALL COORDINATE LOCATING EXISTING UTILITY WITH ASPA OR OWNERS OF UTILITY LINES PRIOR TO EXCAVATION WITH APPROPRIATE ADVANCE NOTIFICATION.

2. ABANDON EXISTING WATER MAIN AND SERVICES IN PLACE ONLY AFTER THE NEW WATER MAIN HAS BEEN DISINFECTED AND APPROVED BY THE AMERICAN SAMOA POWER AUTHORITY (ASPA) AND THE AMERICAN SAMOA ENVIRONMENTAL PROTECTION AGENCY.

3. ALL GATE VALVES ARE TO BE INSTALLED WITH VALVE BOXES PER DRAWINGS AND SPECIFICATIONS.

4. ALL FLUSH VALVES ARE TO BE INSTALLED IN VALVE BOXES PER DRAWINGS AND SPECIFICATIONS.

5. ALL STATION LOCATIONS ARE APPROXIMATE.

6. CONTRACTOR IS RESPONSIBLE FOR MEETING CONDITIONS OF THE PNRS LAND-USE PERMIT.

7. FOR CONFLICT BETWEEN DRAWINGS AND SPECIFICATIONS, PNRs PERMIT REQUIREMENTS AND CONDITIONS SHALL APPLY, THEN SPECIFICATIONS, THEN DRAWINGS.

8. CONTRACTOR MUST CONFORM WITH ALL REQUIREMENTS OF THE OSHA STANDARD FOR EXCAVATION SAFETY (29 CFR 1926 SUBPART P). INCLUDED AMONG THE OSHA STANDARDS IS THE REQUIREMENT FOR PROTECTION OF WORKERS IN EXCAVATIONS 4 FEET OR GREATER IN DEPTH. PROTECTIVE SYSTEMS MUST BE SLOPING/BENCHING OF EXCAVATION WALLS, OR INSTALLATION OF SUPPORT/SHIELDING DEVICES. DESIGN OF PROTECTIVE SYSTEMS MUST BE BASED ON FIELD CLASSIFICATION OF THE SOIL BY A COMPETENT PERSON. PROTECTIVE SYSTEMS MUST BE IN ACCORDANCE WITH THE TABLES AND FIGURES SHOWN IN THE OSHA STANDARDS, OR MUST BE A MANUFACTURED PROTECTION SYSTEM USED IN STRICT CONFORMANCE WITH MANUFACTURER'S INSTRUCTIONS, OR MUST BE A PROTECTION SYSTEM DESIGNED BY A REGISTERED PROFESSIONAL ENGINEER. THE

9. CONTRACTOR SHALL PROVIDE BOTH CONC. ANCHORS & CLAY DIKES AS REQUIRED BY THE ENGINEER AS FOLLOWS:

10%<SLOPE<15%: ONE EVERY 200 LINEAR FEET
CLAY DIKES ONLY
15% OR GREATER SLOPES:
EVERY 100 LINEAR FEET-CONC. ANCHORS &
CLAY DIKES.

A.) CLAY DIKES SHALL EXTEND FOR THE FULL TRENCH WIDTH (USED FOR PIPE BEDDING AND COVER) AND HAVE A LENGTH OF 5 FEET. LOCATED IN THE MIDDLE OF PIPE LENGTH, AT LEAST 2 FEET FROM A PIPE JOINT. MATERIALS SHALL BE CLAY AS DESIGNATED "CL" AND DEFINED UNDER THE UNIFIED SOIL CLASSIFICATION SYSTEM.

B.) CONC. ANCHORS SHALL BE LOCATED AT THE DOWNSTREAM SIDE OF JOINTS, SHALL BE UNREINFORCED AND SHALL BE MINIMUM OF TRENCH WIDTH, 3 FEET HIGH (REPLACING PIPE BEDDING AND COVER) AND 2 FEET THICK.

10. LEVEL SURVEY & TOPOGRAPHIC MAPS USED FOR PLAN SHEETS ARE DATED FEB. 2006, CONDUCTED BY ASG/SURVEY DEPT. BUILDINGS AND ROADWAYS WERE UPDATED BY AERIAL PHOTOGRAPHY DURING AUGUST/SEPTEMBER 1990. LOCATIONS, BUILDING LOCATIONS, AND OTHER FEATURES MAY HAVE CHANGED SINCE THE LAST MAP UPDATE.

11. UTILITIES KNOWN TO EXIST BY THE ENGINEER FROM RESEARCH OF THE AVAILABLE RECORDS ARE SHOWN ON THE DRAWINGS. NO RESPONSIBILITY IS CLAIMED FOR COMPLETENESS OR ACCURACY. PRIOR TO STARTING CONSTRUCTION, VERIFY LOCATION AND ELEVATION OF ALL EXISTING UTILITIES WHICH MAY INTERFERE WITH THE FACILITIES INSTALLED UNDER THIS CONTRACT.

12. ELEVATIONS USED IN THE DRAWINGS ARE BASED ON 0.00 AT THE MEAN SEA LEVEL, HORIZONTAL COORDINATES ARE BASED ON THE AMERICAN SAMOA COORDINATE SYSTEM GRID.

13. PROVIDE, INSTALL, AND MAINTAIN SIGNS BARRICADES, MARKERS, CONES AND PROTECTIVE FACILITIES AND TAKE ALL NECESSARY PRECAUTIONS FOR THE PROTECTION, CONVENIENCE AND SAFETY OF THE PUBLIC DURING THE CONSTRUCTION OPERATIONS, CONFORM TO THE REQUIREMENTS OF THE DEPARTMENT OF PUBLIC SAFETY AND THE DEPARTMENT OF PUBLIC WORKS IN REGARD TO TRAFFIC SAFETY WHILE WORKING IN THE PUBLIC RIGHT-OF-WAY. ALL TRAFFIC CONTROL PLANS MUST BE APPROVED BY DPS AND PUBLIC WORKS PRIOR TO START OF CONSTRUCTION.

14. MAINTAIN TWO-WAY TRAFFIC ON HIGHWAY AT ALL TIMES UNLESS PRIOR PERMISSION TO CLOSE ONE LANE IS OBTAINED FROM THE DEPARTMENT OF PUBLIC SAFETY. IF THE LANE CLOSURE IS REQUIRED, PROPER ADVANCE NOTICE TO PUBLIC VIA NORMAL PUBLICATION OR RADIO ANNOUNCEMENTS IS REQUIRED.

15. KEEP THE WORK SITE AND SURROUNDING AREAS FREE FROM DUST NUISANCE. DUST CONTROL, SEDIMENTATION CONTROL, AND ALL SUCH PLANS MUST BE APPROVED BY THE AMERICAN SAMOA ENVIRONMENTAL PROTECTION AGENCY PRIOR TO START OF CONSTRUCTION.

16. REMOVE ALL SILT AND DEBRIS RESULTING FROM THE WORK AND DEPOSITED IN DRAINAGE FACILITIES, ROADWAYS, AND OTHER AREAS WHEN NECESSARY. CONSTRUCT SILT FENCES AND OTHER EROSION CONTROL DEVICES AROUND THE WORK TO PREVENT DAMAGE TO STREAMS OR OTHER WATERWAYS.

17. BARRICADE OPEN EXCAVATIONS AND POST WITH WARNING LIGHTS. KEEP UNATTENDED EXCAVATIONS FREE OF WATER AND MAINTAIN SLOPING AND STABLE WALLS WHEN OVER 4 FEET DEEP. LEAVE A LADDER OR OTHER DEVICE TO ALLOW ESCAPE FROM EXCAVATION. WHEN PERSONNEL ARE IN THE EXCAVATION, AT LEAST 2 MEANS OF EGRESS ARE REQUIRED. LADDERS ARE REQUIRED TO ALLOW NOT MORE THAN 25 FEET OF LATERAL TRAVEL FOR TRENCH EGRESS.

18. THE CONTRACTOR IS RESPONSIBLE FOR PROVIDING ALL NECESSARY EQUIPMENT AND MATERIALS FOR TESTING WATERLINES.

19. ROADS AND PROPERTIES AFFECTED BY EXCAVATION MUST BE REFURBISHED TO ORIGINAL STATUS OR BETTER AT COMPLETION OF PROJECT.

20. CONTRACTOR TO PROVIDE ELECTRONIC AS-BUILT DRAWINGS IN AUTODESK LAND DEVELOPMENT 2006 OR A RECENT VERSION THEREOF, OF ALL APPURTENANCES AND SURVEY REFERENCE POINTS TO ACCEPTABLE LOCATIONS. MINIMAL REQUIREMENT OF 2 POINTS FOR MINOR AND 3 POINTS FOR MAJOR APPURTENANCES.

21. MAINTAIN WATER AND SEWER LINE SEPARATION IN ACCORDANCE WITH REGULATIONS.

22. INSTALL DETECTABLE WARNING TAPE AND CONDUCTOR TAPE ON TOP OF ALL PIPE.

23. ALL REBARS SHOULD BE EPOXY COATED.
UNLESS DIRECTED BY ENGINEER

24. CONSTRUCT SWALES AS SHOWN IN DETAILS
WHENEVER SLOPE EXCEEDS 8%.

No.	Description	Date	REV. NO.:	PREPARED BY:	 AMERICAN SAMOA POWER AUTHORITY ENVIRONMENTAL SERVICES DIVISION P.O.BOX PPB, TAFUNA, PAGO PAGO, AS 96799	PROJECT NAME:	SCALE:		PROJECT NO.:
			REVISION:	CHECKED BY:		VAITOGI WATERLINE REPLACEMENT PROJECT	NTS		
			CHECKED BY:	APPROVED BY:		DRAWING TITLE:	DATE:	SIGNATURE:	
			APPROVED BY:	ISSUE FOR:		LEGEND UTILITY GENERAL NOTES	7-2022		
			DATE:	Construction		PROJECT LOCATION:	SHEET NO.		
					VAITOGI VILLAGE, AMERICAN SAMOA	G3	DATE:		

CONSTRUCTION NOTES:

1. THE CONTRACTOR SHALL CLEAR HIS HAUL ROUTE STAGING AREA AND ALL ASSOCIATED REQUIREMENTS, SUCH AS, LAND USE PERMIT, WITH THE PNRS, CONTRACTING OFFICER, AND AFFECTED LANDOWNER.
2. A SEPARATE LAND USE PERMIT MUST BE OBTAINED BY THE CONTRACTOR IF THE CONTRACTOR'S STAGING AREA OR ANY WORK IS OUTSIDE THE LIMITS OF THE CONTRACT. THE EXISTING LAND USE PERMIT IS CONDITIONED ON A DIVISION OF MARINE AND WILDLIFE RESOURCES REVIEW PRIOR TO CONSTRUCTION.
3. THE CONTRACTOR SHALL BE RESPONSIBLE FOR THE CLEARING AND REMOVAL OF ALL SILT AND DEBRIS GENERATED BY HIS GRADING AND CONSTRUCTION WORK AND DEPOSITED AND ACCUMULATED ON ROADWAYS AND OTHER AREAS.
4. ALL EXISTING UTILITIES, CONCRETE WALKWAYS, STEPS AND WALLS, WHETHER OR NOT SHOWN ON THE DRAWINGS, EXCEPT THOSE DESIGNATED TO BE REMOVED, SHALL BE PROTECTED FROM DAMAGED AT ALL TIMES DURING CONSTRUCTION AND GRADING WORK. ANY DAMAGES TO THEM SHALL BE REPAIRED BY THE CONTRACTOR AT HIS EXPENSE.
5. THE CONTRACTOR SHALL VERIFY DIMENSIONS, LOCATIONS, ELEVATIONS, ETC. THAT ARE INDICATED FOR VERIFICATION AND INFORM THE CONTRACTING OFFICER IN WRITING OF ANY DIFFERENCES PRIOR TO INSTALLATION OF NEW FACILITIES.
6. THE CONTRACTOR SHALL TONE AND PROBE THE AREA PRIOR TO ALL EXCAVATION AND TRENCHING TO VERIFY THE LOCATION OF ALL EXISTING UTILITIES AND SHALL BE RESPONSIBLE FOR REPAIR OR REPLACEMENT OF SAME IN THE EVENT OF DAMAGES DUE TO CONTRACTORS CONSTRUCTION PRACTICES. WHENEVER CONNECTIONS OF NEW UTILITIES TO EXISTING UTILITIES ARE SHOWN ON THE PLANS, THE CONTRACTOR SHALL EXPOSE THE EXISTING LINES AT THE PROPOSED CONNECTIONS TO VERIFY THEIR LOCATIONS, DEPTHS AND ASSURE THAT CONNECTIONS CAN BE MADE PRIOR TO EXCAVATION FOR THE NEW LINES AT NO COST TO THE OWNER. ANY NECESSARY ADJUSTMENTS FOR THE NEW LINES TO ENSURE PROPER CONNECTIONS TO THE EXISTING SHALL BE THE CONTRACTOR'S RESPONSIBILITY. THE CONTRACTOR SHALL ALSO CONTACT ASPA, BLUESKY AND ASTCA TO PROPERLY LOCATE THE UNDERGROUND UTILITIES AND CABLES THAT LIE IN AND ADJACENT TO THE WORK AREA.
7. WORK SHALL BE DONE BETWEEN 7:30AM AND 4:00PM SAMOA STANDARD

TIME. NO WORK SHALL BE DONE ON SATURDAYS, SUNDAYS, FEDERAL HOLIDAYS OR AFTER NORMAL WORK HOURS AT ANY TIME, WITHOUT SPECIAL ARRANGEMENT AND PRIOR APPROVAL BY THE CONTRACTING OFFICER. PROJECT WORK SHALL BE IN CONFORMANCE WITH APPLICABLE FEDERAL AND LOCAL LAWS AND REGULATIONS REGARDING COMMUNITY NOISE CONTROL.

8. THE CONTRACTOR SHALL BE RESPONSIBLE FOR THE PROTECTION OF ALL WATERLINES DURING CONSTRUCTION. THE CONTRACTOR SHALL BE ESPECIALLY CAREFUL WHEN EXCAVATING BEHIND WATERLINE TEES AND BENDS WHEREVER THERE IS POSSIBILITY OF WATERLINE MOVEMENT DUE TO REMOVAL OF THE SUPPORTING EARTH BEYOND THE EXISTING REACTION BLOCKS. THE CONTRACTOR SHALL TAKE WHATEVER MEASURE TO PROTECT THE WATERLINE SUCH AS CONSTRUCTING SPECIAL REACTION BLOCKS AND/OR MODIFYING HIS CONSTRUCTION METHODS.
9. NO BLASTING WILL BE ALLOWED ON THIS PROJECT.
10. THE CONTRACTOR SHALL PROTECT EXISTING PUBLIC AND PRIVATE FACILITIES AND UTILITIES, AND PROVIDE SHORING DURING EXCAVATION. THE CONTRACTOR SHALL REPAIR, AT HIS COST, ALL DAMAGES DUE TO EXCAVATION.
11. THE CONTRACTOR SHALL COORDINATE WITH ASPA, ASC, BLUESKY COMMUNICATIONS AND ASTCA FOR ALL NEW POLE INSTALLATION, POWER, TELEVISION AND COMMUNICATIONS RELOCATIONS, AND REMOVAL OF EXISTING POLES. IF THE CONTRACTOR SHALL PROVIDE RELOCATIONS, REMOVAL OF EXISTING POLES. THE CONTRACTOR SHALL PROVIDE SUPPORTS FOR THE EXISTING POLES AFFECTED BY EXCAVATION. THE CONTRACTOR SHALL NOTIFY AFFECTED VILLAGES AND THE UTILITY COMPANIES SEVEN (7) DAYS PRIOR TO SERVICE INTERRUPTIONS. THESE NOTIFICATIONS SHALL BE AT THE CONVENIENCE OF ASPA, ASC, BLUESKY COMMUNICATION AND ASTCA.
12. THE CONTRACTOR SHALL PROVIDE ALL LAND SURVEY CONSTRUCTION STAKEOUT SERVICES, SOIL AGGREGATE, CONCRETE AND PAVEMENT MONITORING, AND SAMPLING AND TESTING SERVICES.
13. WASTE MATERIAL WILL BE DISPOSED OF AT AN APPROVED, PNRS-COMPLIANT, OFF-SITE DISPOSAL AREA. THE CONTRACTOR SHALL BE RESPONSIBLE FOR OBTAINING DISPOSAL AREA.
14. THE CONTRACTOR SHALL TAKE EXTREME CARE IN PERFORMING WORK NEAR EXISTING CONCRETE ELECTRICAL/COMMUNICATION DUCTS.

APPROPRIATE PROTECTION SHALL BE IMPLEMENTED AS REQUIRED TO PREVENT DAMAGE TO THIS LINE.

15. THE CONTRACTOR SHALL VERIFY, BASED ON THE SITE CONDITIONS AND CONTRACT BASELINE DATA, WITH OVERVIEW AND APPROVAL BY AN AUTHORIZED REPRESENTATIVE OF AMERICAN SAMOA POWER AUTHORITY, THE LOCATION OF ALL EXISTING POLES WHICH IMPACT THE CONSTRUCTION AND ULTIMATE USE OF THE PROPOSED ROAD.
16. THE CONTRACTOR SHALL VERIFY, BASED ON OVERVIEW AND APPROVAL BY AUTHORIZED REPRESENTATIVE OF AMERICAN SAMOA GOVERNMENT OFFICE OF COMMUNICATIONS, THE LOCATIONS AND DEPTH OF EXISTING UNDERGROUND TELEPHONE CABLES. RELOCATE EXISTING DIRECT BURIED CABLES WHICH IMPACT THE CONSTRUCTION AND FINAL USE OF THE PROPOSED ROAD. EITHER INTO A NEW TRENCH AWAY FROM THE ROAD OR IN PVC SCHEDULE80 SLEEVES THROUGH THE ROAD AT A MINIMUM DEPTH OF 3' BELOW FINISHED GRADE IF THE CABLES CANNOT BE RELOCATED. TO EXPOSE THE CABLE, THE CONTRACTOR SHALL TONE FOR THE CABLE AND HAND EXCAVATE THE CABLE TAKING CARE NOT TO DAMAGE THE JACKET AND INSULATION. BASIS OF BID SHALL BE 100 LINEAR FEET OF DIRECT BURIED CABLE.
17. THE CONTRACTOR SHALL REMOVE ALL EXISTING PAVEMENT AND CROSSING ALONG THE NEW ROADWAY. ALL DEMOLITION AND REMOVAL OF EXISTING PAVEMENT SHALL BE CONSIDERED INCIDENTAL TO ROADWAY CONSTRUCTION.
18. ALL TRAFFIC SIGN AND PAVEMENT MARKERS SHALL BE IN ACCORDANCE WITH THE MANUAL ON UNIFORM TRAFFIC CONTROL DEVICES (MUTCD) 2003 EDITION, AND ALL SUBSEQUENT AMENDMENTS AND ADDITIONS.
19. AT THE END OF THE WORKDAY OR AS SOON AS WORK IS COMPLETED, THE CONTRACTOR SHALL TAKE NECESSARY MEASURES TO ENSURE THAT PUBLIC TRAFFIC HAS SAFE PASSAGE AND THAT ALL OPEN HOLES ARE PROPERLY COVERED AND MAINTAINED DURING THE DURATION OF THE PROJECT.
20. IF THE CONTRACTOR UNCOVERS ANY CULTURAL REMAINS, DURING EXCAVATION WORK, THE CONTRACTOR SHALL STOP WORK IN THE AREA OF THE FINDINGS AND NOTIFY THE CONTRACTING OFFICER AND THE AMERICAN SAMOA GOVERNMENT (ASHPO AND ASPA)

No.	Description	Date	REV. NO.:	PREPARED BY:	 AMERICAN SAMOA POWER AUTHORITY ENVIRONMENTAL SERVICES DIVISION P.O.BOX PPB, TAFUNA, PAGO PAGO, AS 96799	PROJECT NAME:	SCALE:		PROJECT NO:
			REVISION:	CHECKED BY:		VAITOGI WATERLINE REPLACEMENT PROJECT	NTS		
			CHECKED BY:	APPROVED BY:		DRAWING TITLE:	DATE:	SIGNATURE:	
			APPROVED BY:	ISSUE FOR:		CONSTRUCTION NOTES	7-2022		
			DATE:			PROJECT LOCATION:	SHEET NO.		
						VAITOGI VILLAGE, AMERICAN SAMOA	G4	DATE:	