

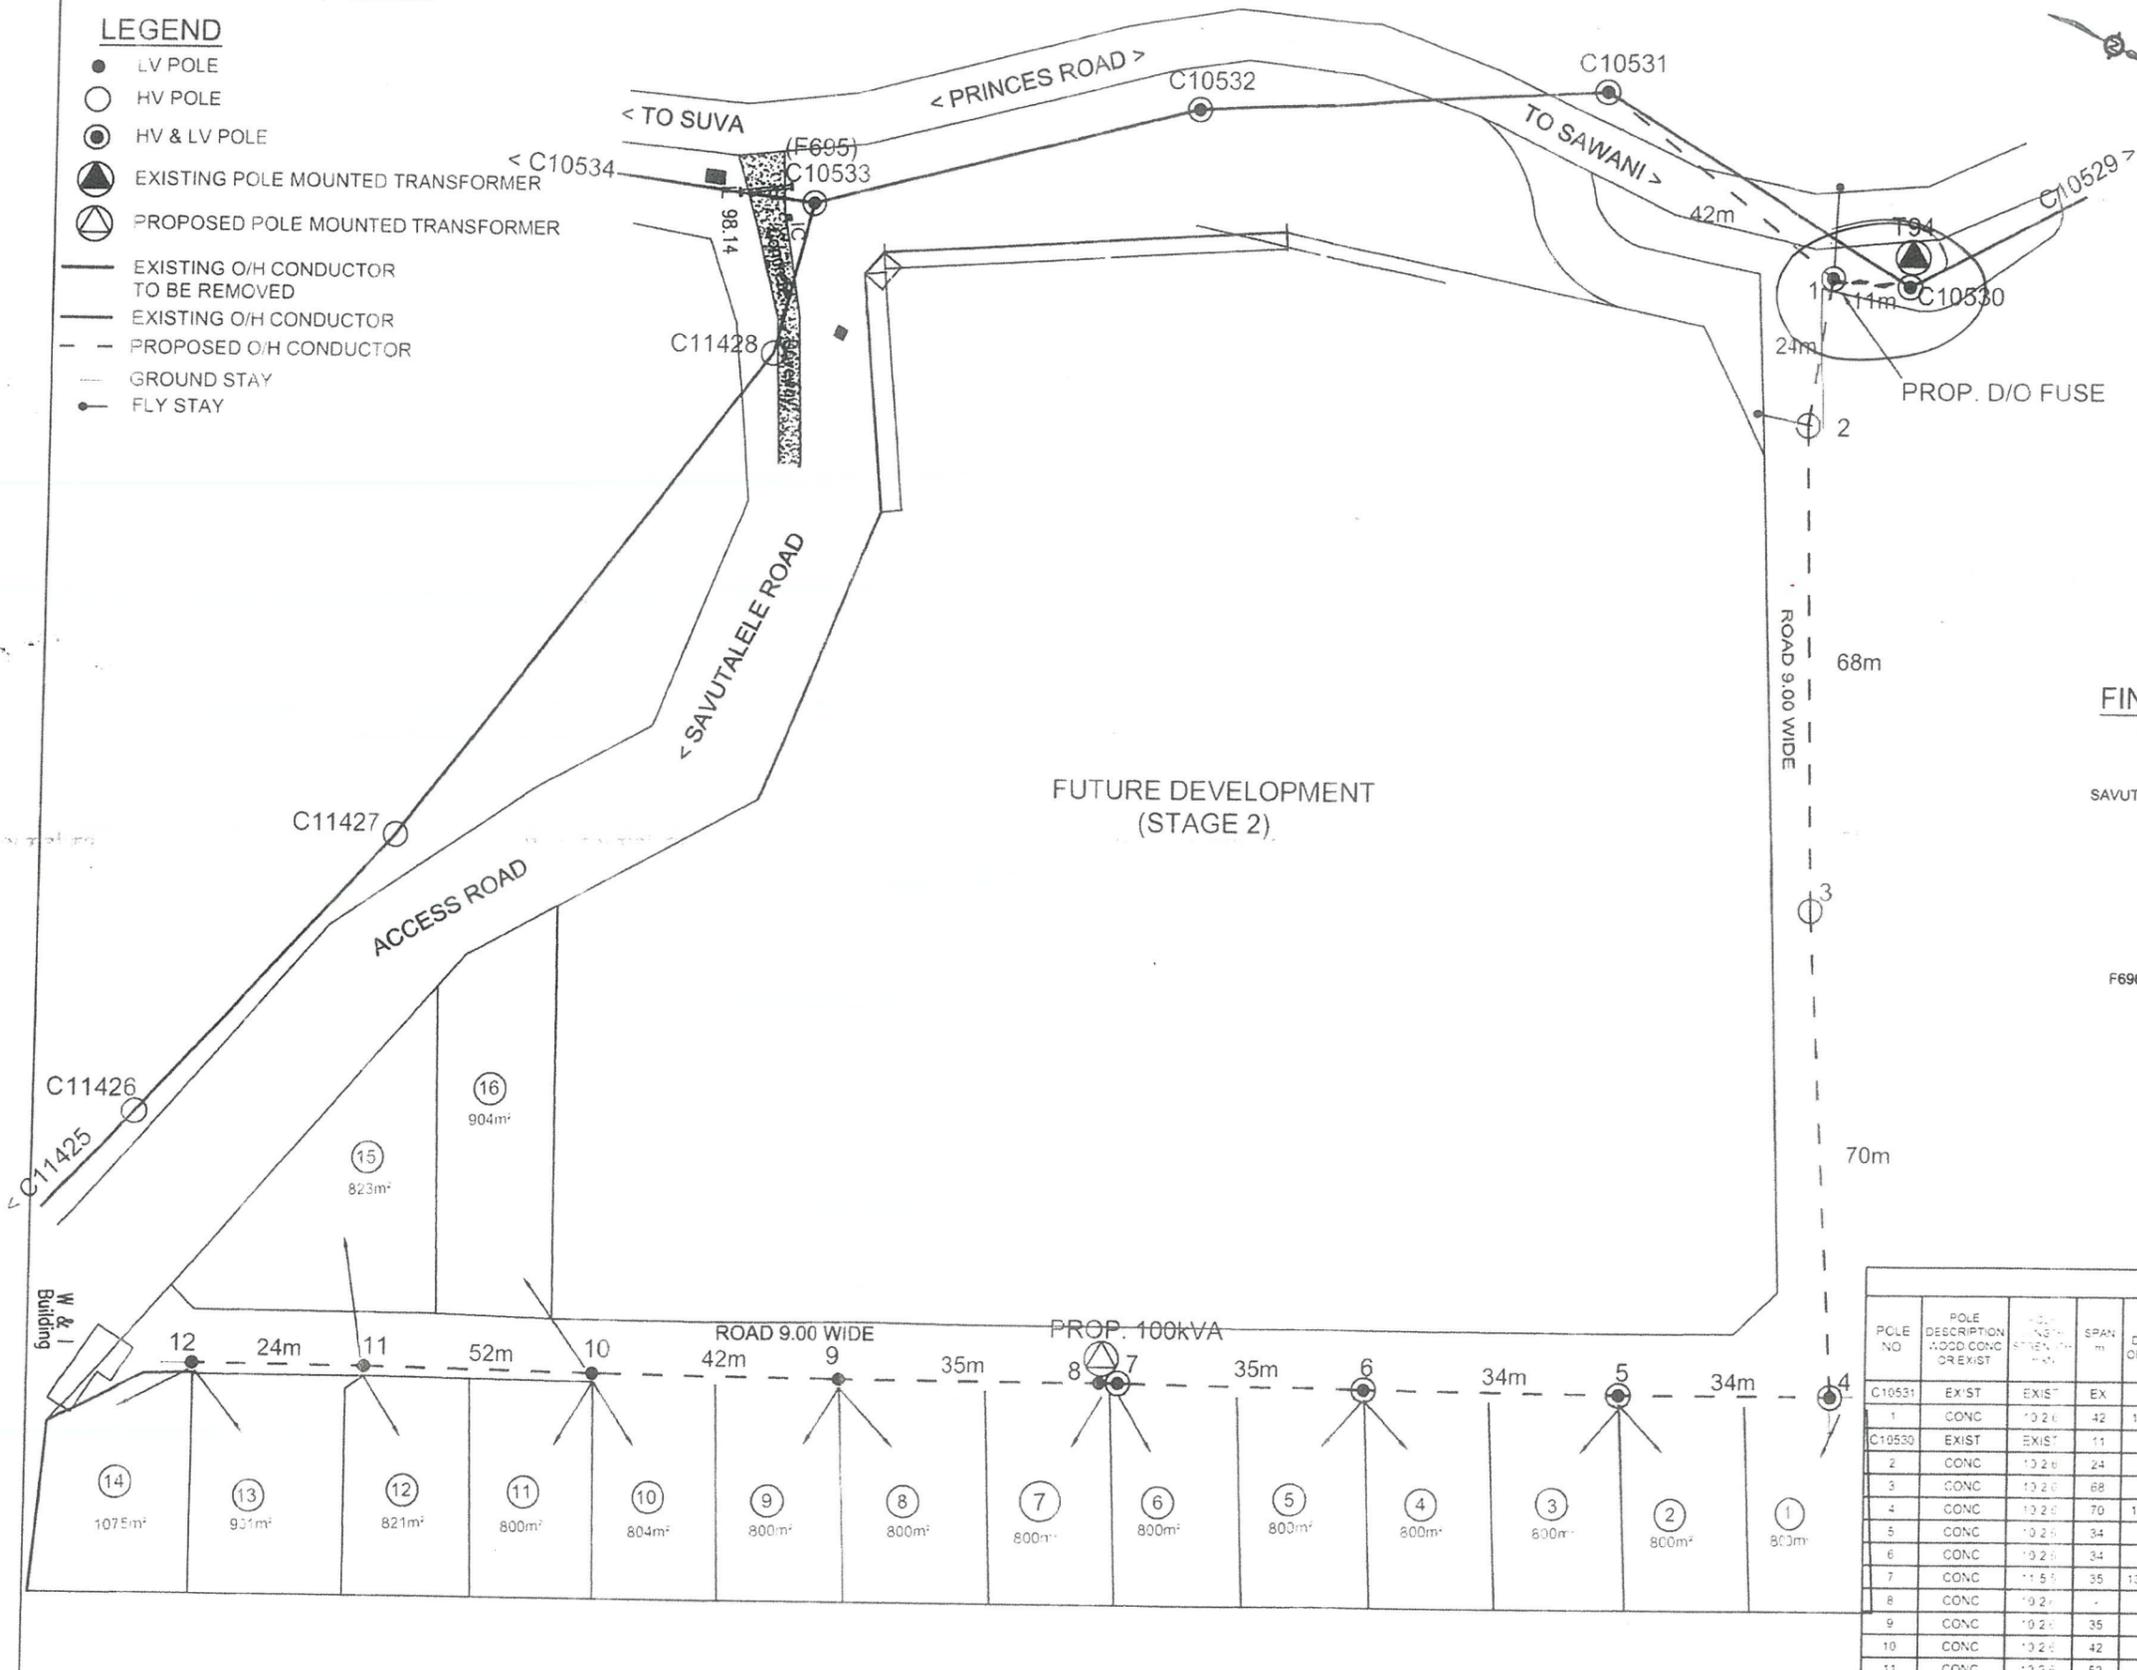


- LEGEND**
- LV POLE
  - HV POLE
  - ⊙ HV & LV POLE
  - ▲ EXISTING POLE MOUNTED TRANSFORMER
  - △ PROPOSED POLE MOUNTED TRANSFORMER
  - EXISTING O/H CONDUCTOR TO BE REMOVED
  - EXISTING O/H CONDUCTOR
  - - - PROPOSED O/H CONDUCTOR
  - GROUND STAY
  - FLY STAY

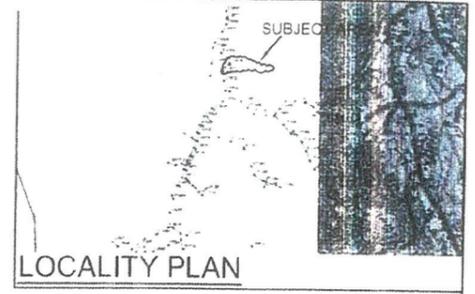

**FINAL SINGLE LINE DIAGRAM**  
REF SLD NO. 04 N10 010

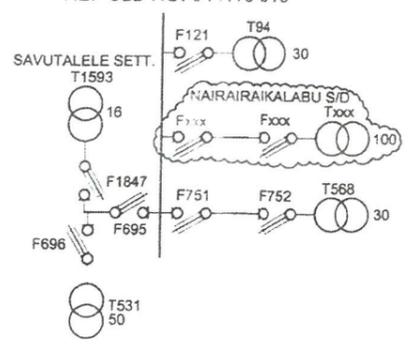

POLE SCHEDULE							
POLE NO	POLE DESCRIPTION (ADD CONC OR EXIST)	POLE HEIGHT (M)	SPAN (M)	POLE TOP DESCRIPTION OR DIMENSIONS	STAYS		REMARKS
					GRND	FLY	
C10531	EXIST	EXIST	EX	EXIST			EXISTING POLE
1	CONC	10.2	42	14B+18B+4A	1		PROP 30 HV - PROP 10 LV - INSTALL D/O FUSE
C10530	EXIST	EXIST	11	EXIST			EXISTING POLE
2	CONC	10.2	24	11B	1		PROP 30 HV
3	CONC	10.2	88	11B			
4	CONC	10.2	70	12B+13B+3B	2		PROP 10 HV - PROP 10 LV
5	CONC	10.2	34	11B+1B			
6	CONC	10.2	34	11B+1B			
7	CONC	11.5	35	12B+3B+REM			PROP 30 HV - PROP 30 LV - PROP 100kVA
8	CONC	10.2	-	3B+REM	1		PROP H - POLE STRUCTURE
9	CONC	10.2	35	1B			PROP 30 LV
10	CONC	10.2	42	1B			
11	CONC	10.2	52	1B			
12	CONC	10.2	24	3B	1		

No.	REVISION	DATE	BY	CHK	DEPT	ENG	HOD
0	ORIGINAL ISSUE FOR SD24.23	09.06.25	PS		RJ		



DRAWN	PRIYA	09.06.25
CHECKED		
GIS COORDINATOR		
TEAM LEADER DESIGN & PLANNING	<i>[Signature]</i>	20.06.25
ENGINEER	<i>[Signature]</i>	21/06/25
HEAD OF DEPARTMENT	<i>[Signature]</i>	24.6.25

**ENERGY FIJI LIMITED**

SUPPLY TO NAIRAIRAIKALABU SUBDIVISION  
AT LOT 13 SO4335, OFF PRINCES ROAD,  
TACIRUA, NASINU DISTRICT (SD24.23)

DRAWING NUMBER			
A3	04	N78	083
SCALE 1:1000			

